
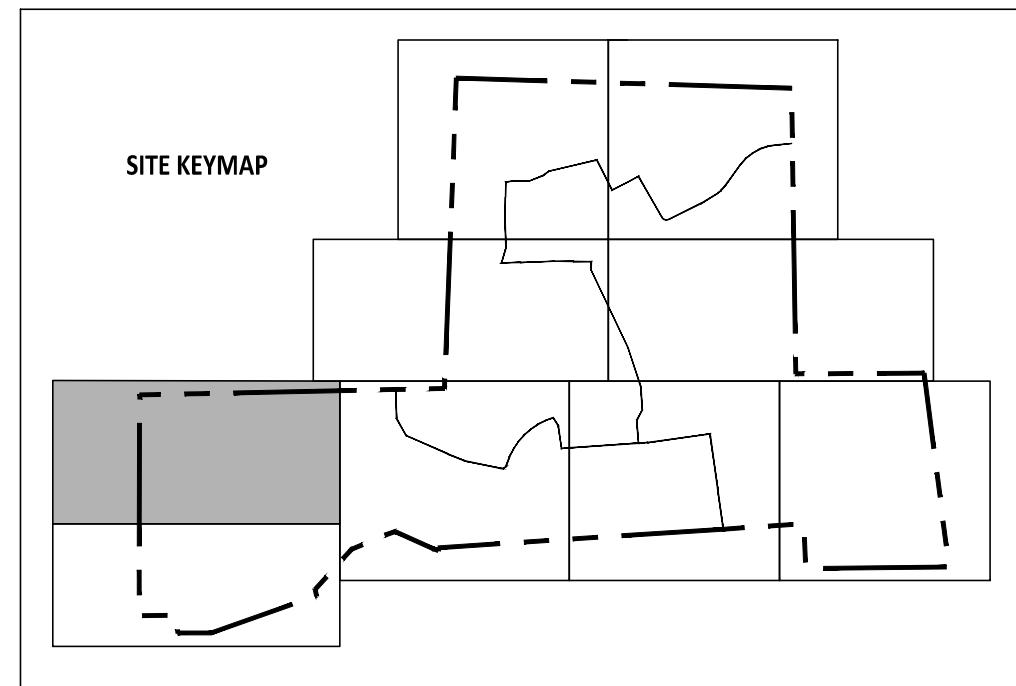


UTILITY PLAN LEGEND	
WATER VALVE	
SEWER METER	
WATER METER	
FH	
MANHOLE	
WATER LINE	
SCM LOCATIONS	
SEWER LINE	
30' STREETScape BUFFER	
PERIMETER BUFFER	
NEUSE RIVER BUFFER	

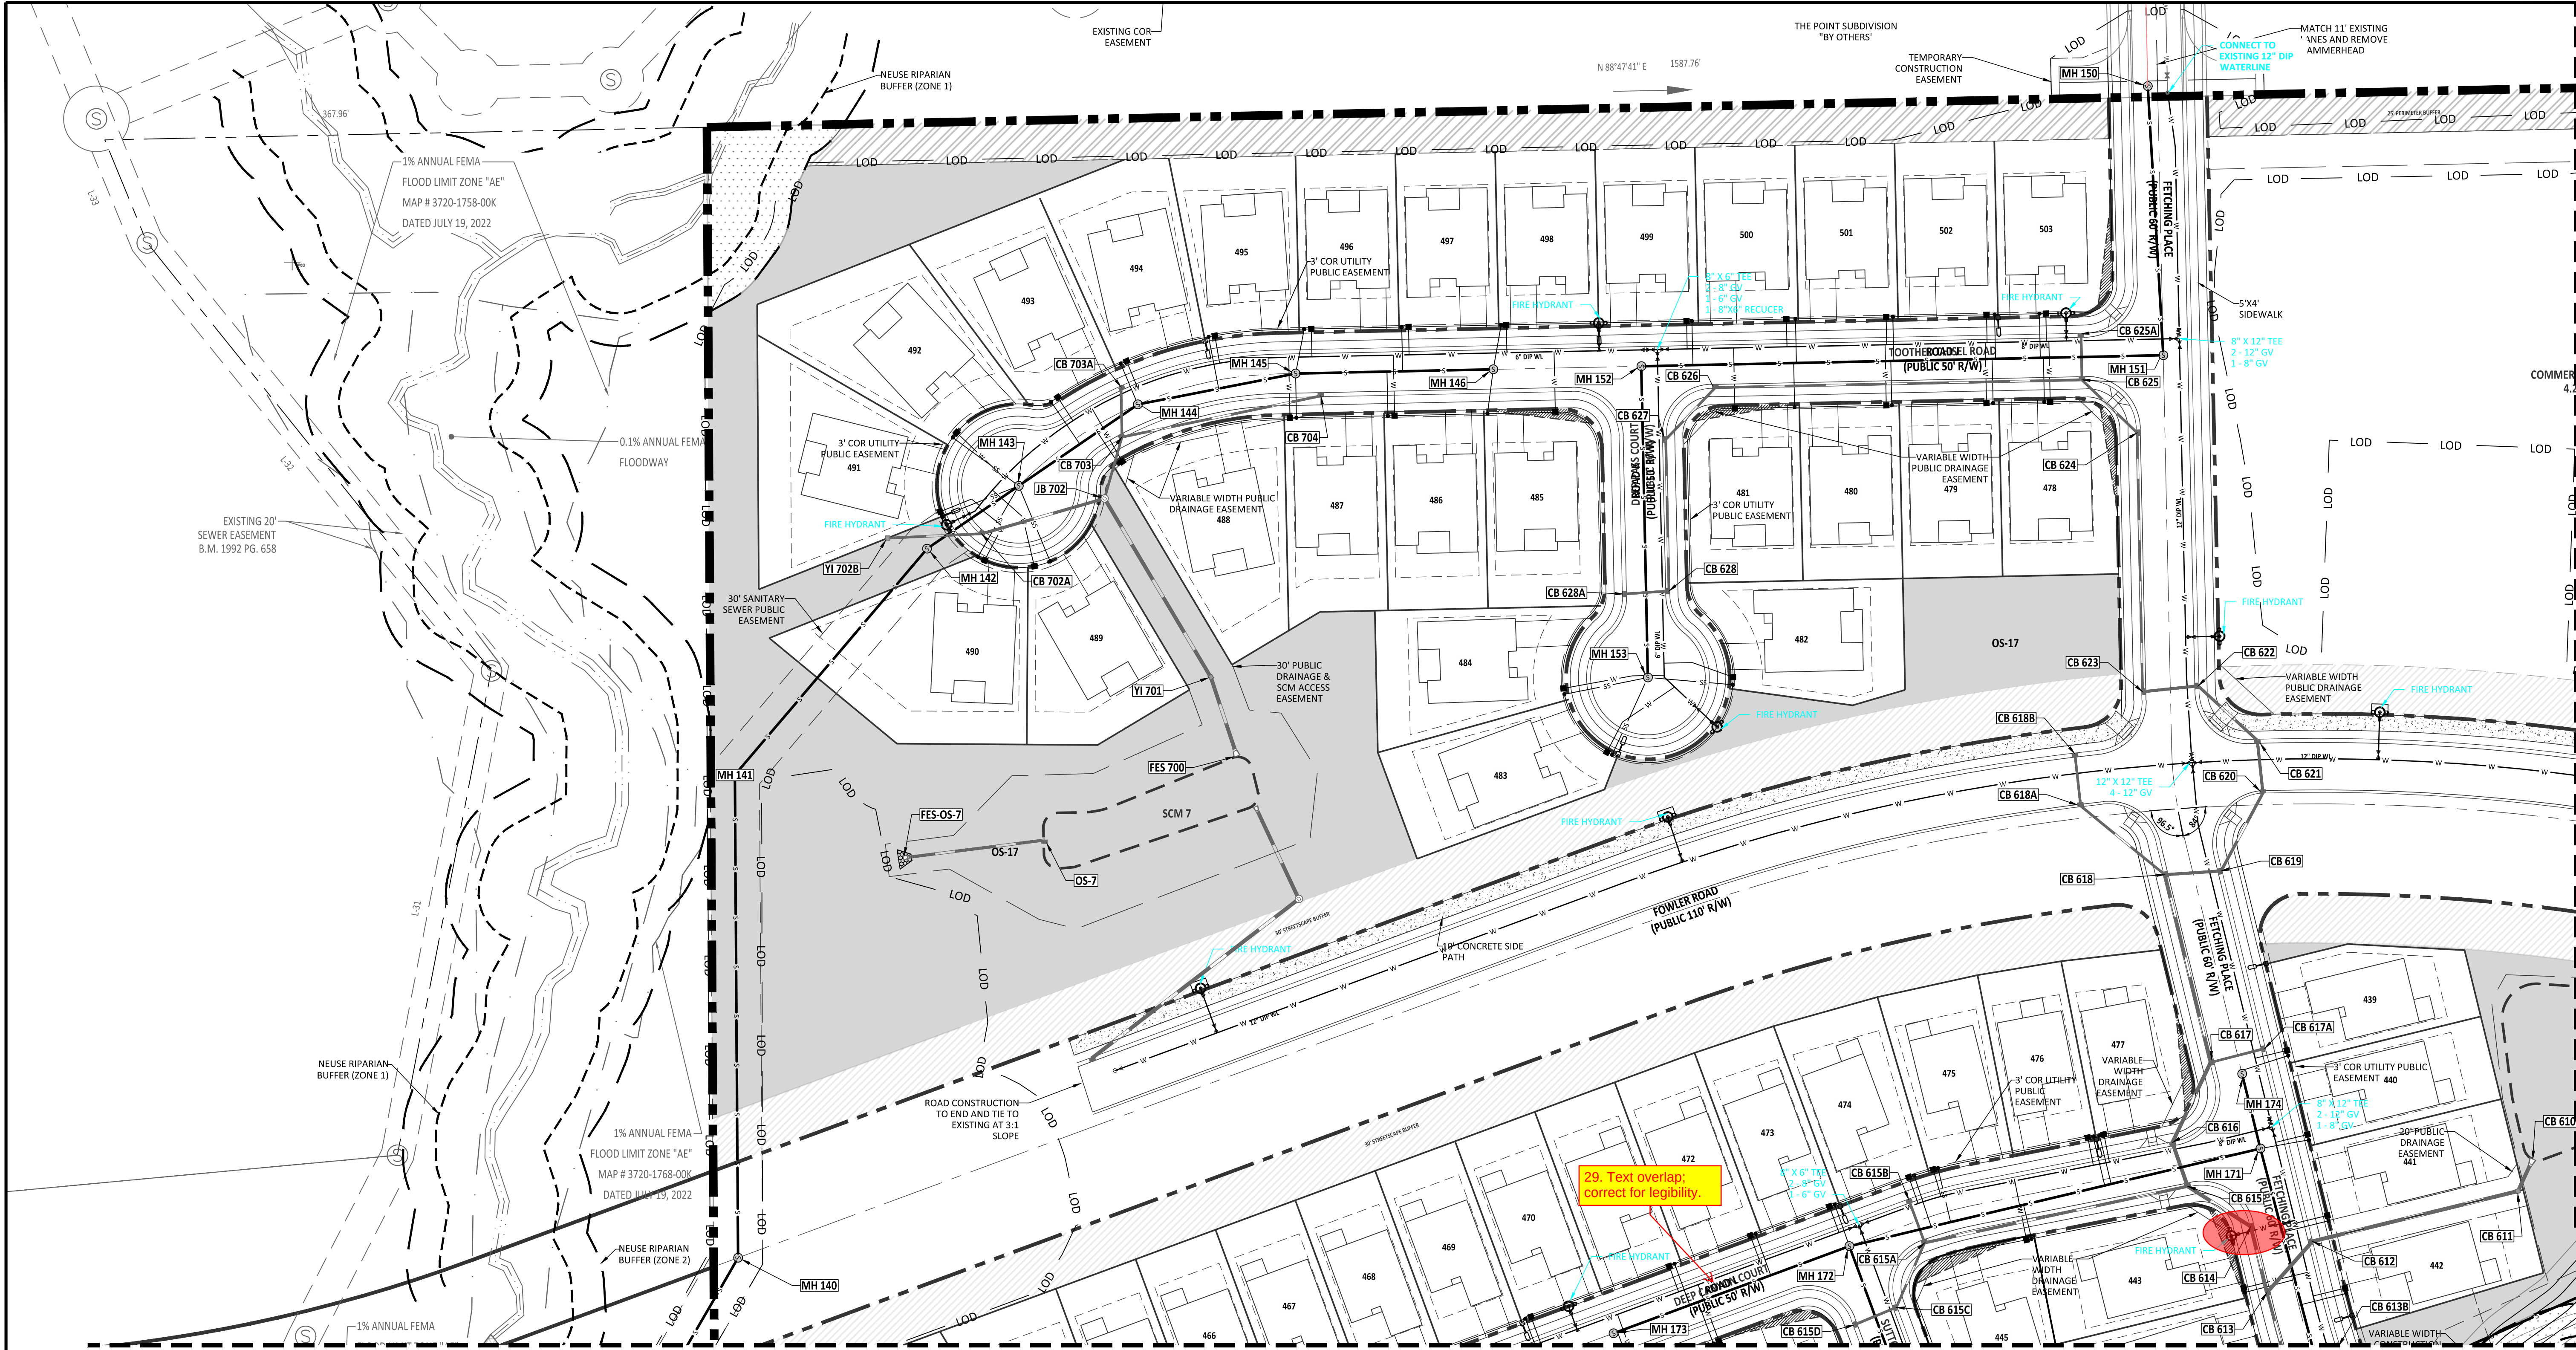

AMERICAN
Engineering

American Engineering Associates - Southeast, P.A.
4020 Westchase Boulevard, Suite 450
Raleigh, NC 27607
919-469-1101

PRELIMINARY
PRELIMINARY
DO NOT USE FOR
CONSTRUCTION
JOB P. KLE
FOR INFORMATION, ONLY

NO.	DATE	REVISION:

STIPULATION FOR REUSE

THIS DRAWING WAS PREPARED FOR USE ON THE SPECIFIC SITE, NAMED HEREON, CONTEMPORANEOUSLY WITH ITS ISSUE DATE AS LISTED, HEREON, AND IT IS NOT SUITABLE FOR USE ON A DIFFERENT PROJECT SITE OR AT A LATER TIME. USE OF THIS DRAWING FOR REFERENCE OR EXAMPLE ON ANOTHER PROJECT REQUIRES THE SERVICES OF PROPERLY LICENSED ARCHITECTS AND ENGINEERS. REPRODUCTION OF THIS DRAWING FOR REUSE ON ANOTHER PROJECT IS NOT AUTHORIZED AND MAY BE CONTRARY TO THE LAW.

MERRITT RESERVE

UTILITY PLAN

ROLESVILLE RD
WAKE COUNTY NC 27312

JOB NUMBER: 23-0004

CHECKED BY: BH





DRAWN BY: DH/RC/SM/GE/MA/LL/JB

DATE: 05/01/2025

SHEET TITLE:

UTILITY PLAN

SHEET NO.:
CU-108

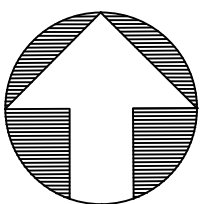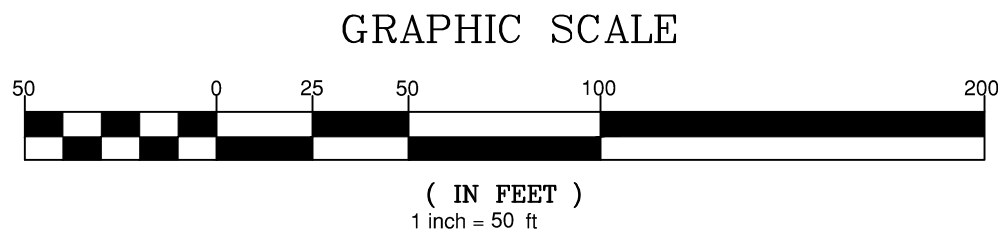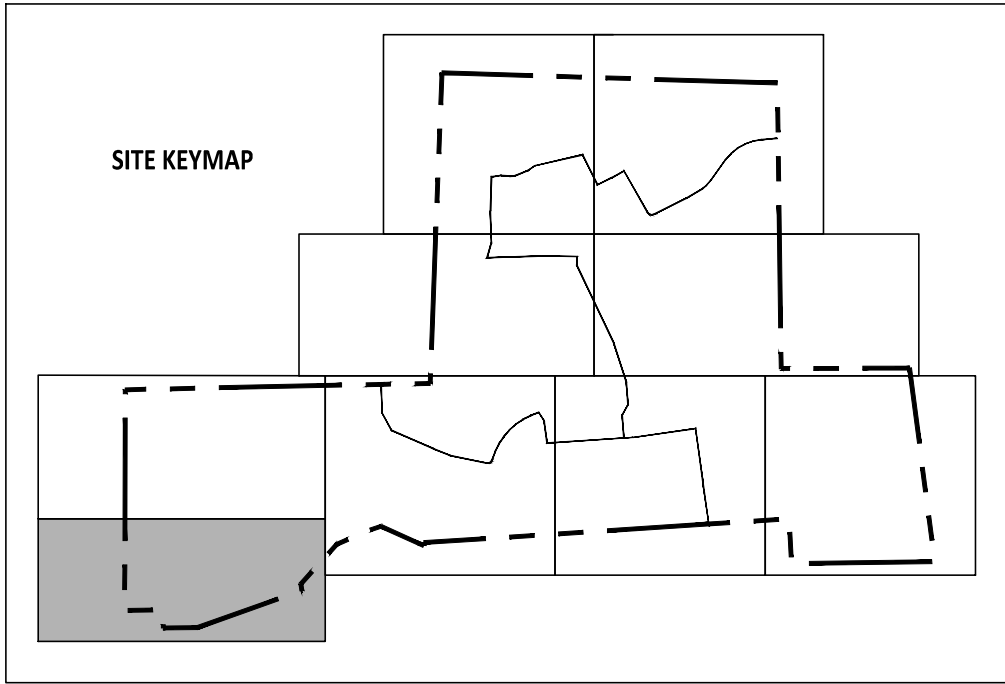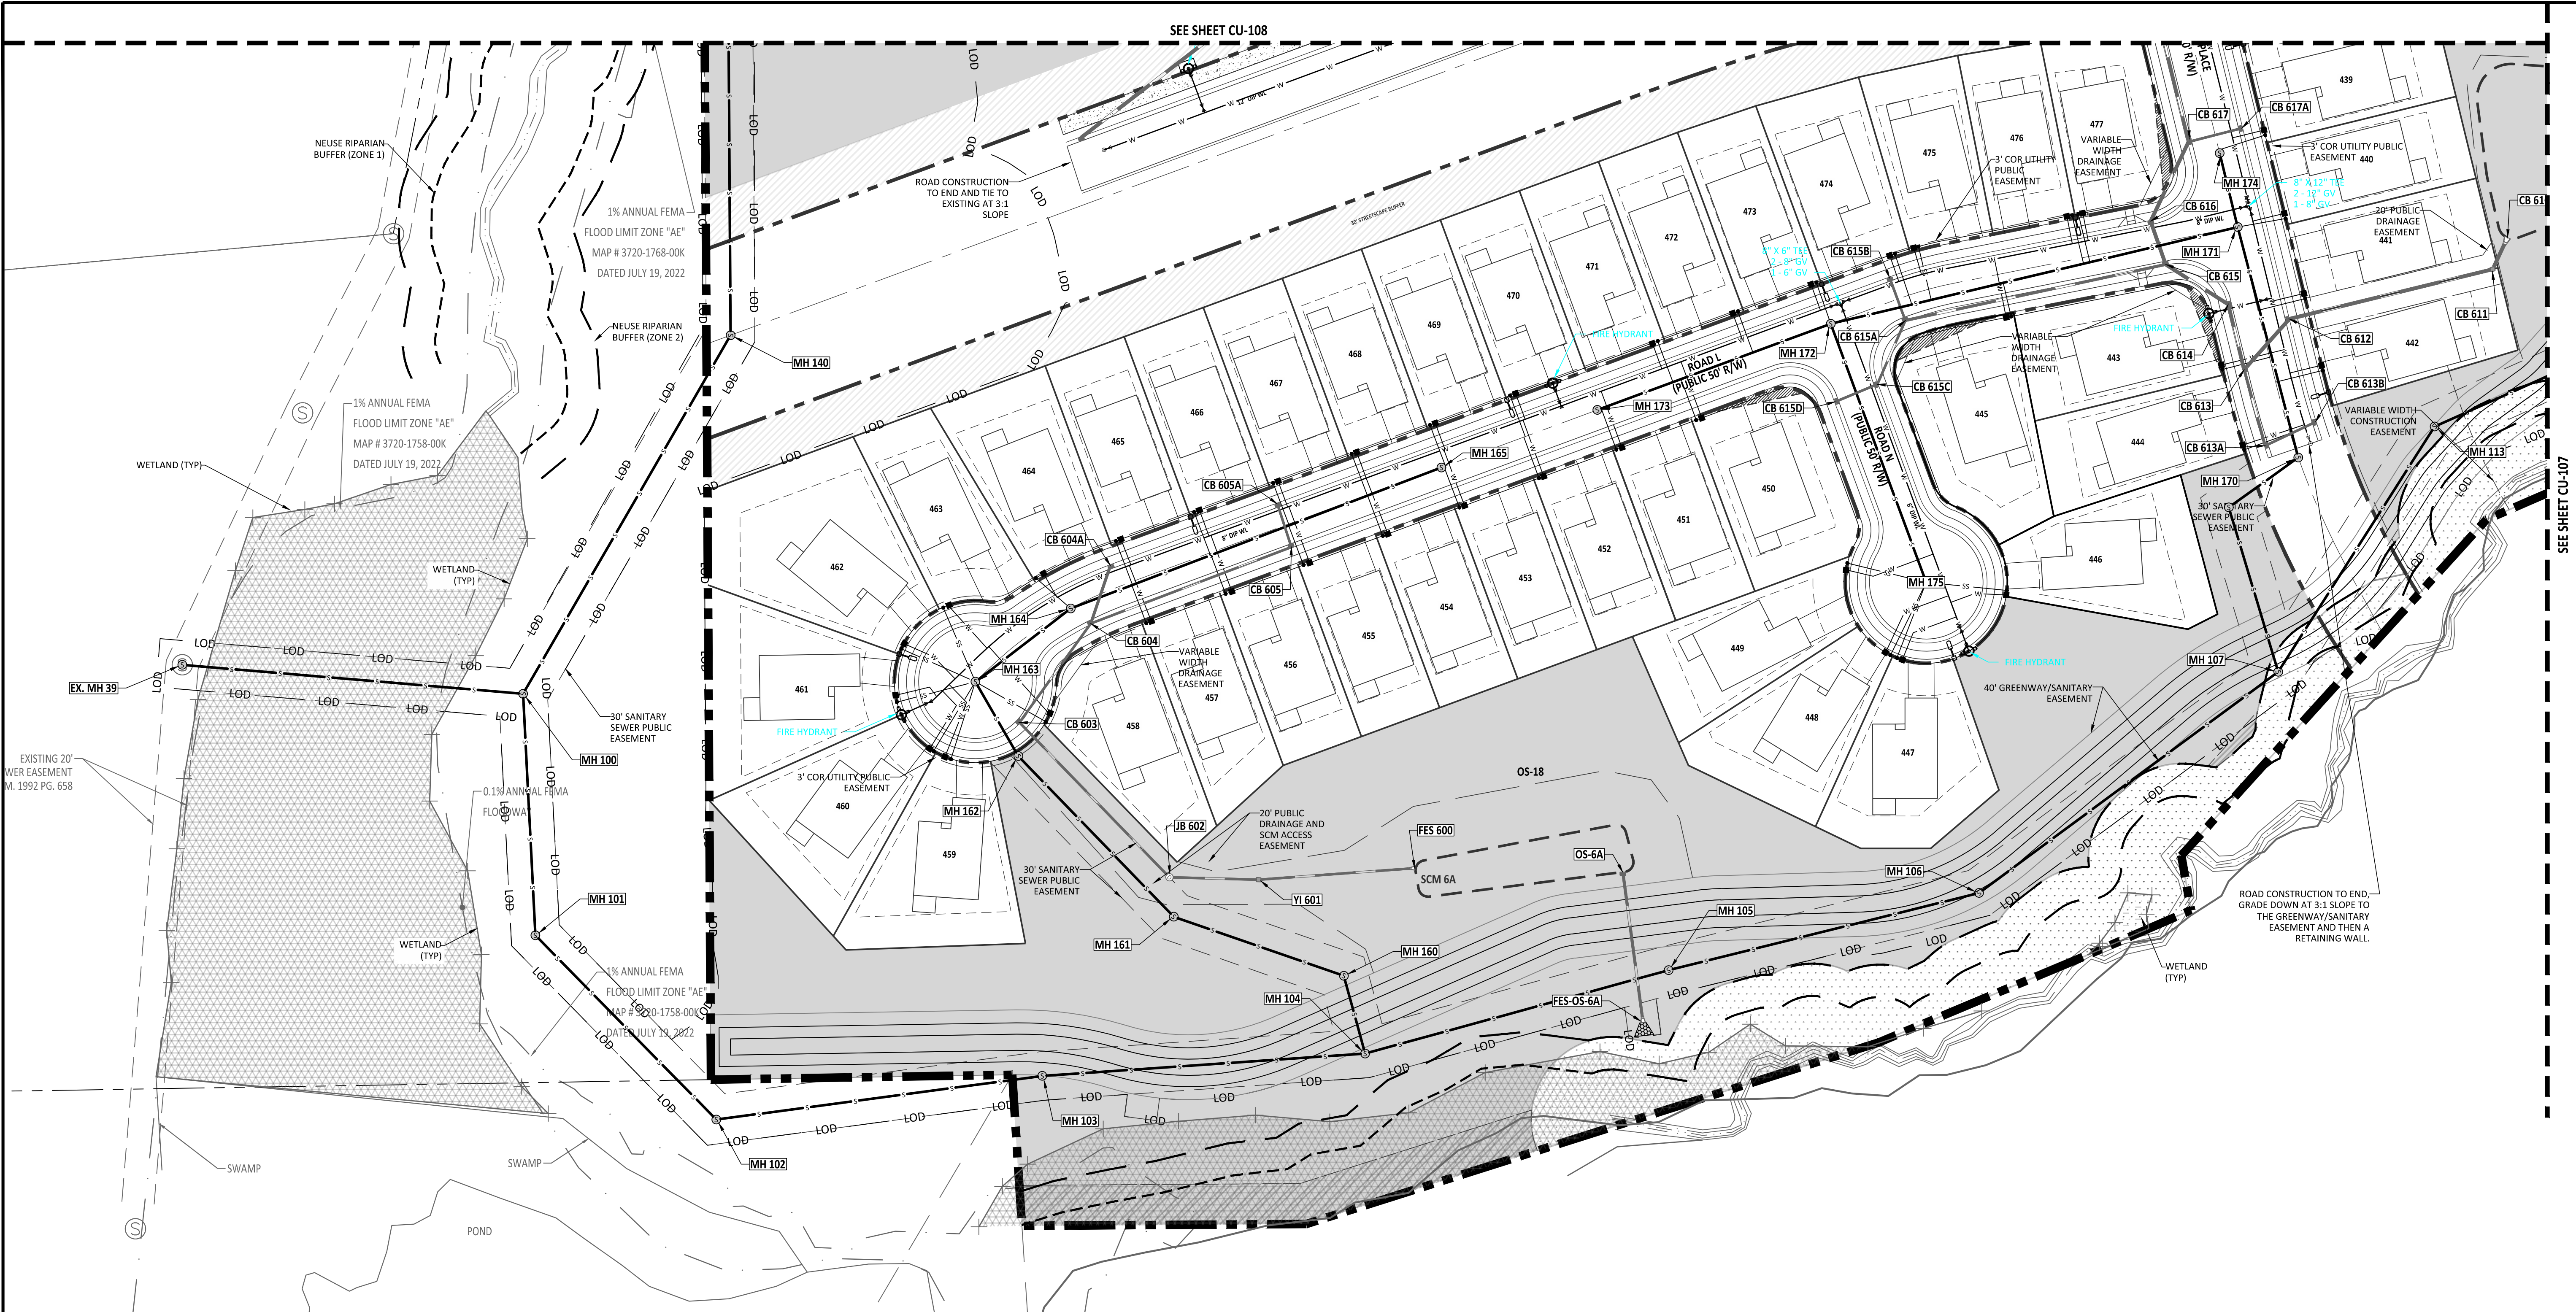

UTILITY PLAN LEGEND	
WATER VALVE	
SEWER METER	
WATER METER	
FH	
MANHOLE	
WATER LINE	
SCM LOCATIONS	
SEWER LINE	
30' STREETSCAPE BUFFER	
PERIMETER BUFFER	
NEUSE RIVER BUFFER	



AMERICAN Engineering
American Engineering Associates - Southeast, P.A.
4020 Westchase Boulevard, Suite 450
Raleigh, NC 27607
919-469-1101

PRELIMINARY
PRELIMINARY
NO USE FOR CONSTRUCTION
FOR INFORMATION, ONLY

NO.	DATE	REVISION

STIPULATION FOR REUSE
THIS DRAWING WAS PREPARED FOR USE ON THE SPECIFIC SITE, NAMED HEREIN, CONTEMPORANEOUSLY WITH ITS ISSUE DATE AS LISTED, HEREON, AND IT IS NOT SUITABLE FOR USE ON A DIFFERENT PROJECT SITE OR AT A LATER TIME. USE OF THIS DRAWING FOR REFERENCE OR EXAMPLE ON ANOTHER PROJECT REQUIRES THE SERVICES OF PROPERLY LICENSED ARCHITECTS AND ENGINEERS. REPRODUCTION OF THIS DRAWING FOR REUSE ON ANOTHER PROJECT IS NOT AUTHORIZED AND MAY BE CONTRARY TO THE LAW.

MERRITT RESERVE

UTILITY PLAN

ROLESVILLE RD

WAKE COUNTY NC 27312

JOB NUMBER: 23-0004

CHECKED BY: BH



DRAWN BY: DH/RC/SM/GE/MA/LL/JB

DATE: 05/01/2025


SHEET TITLE:

UTILITY PLAN

SHEET NO.: **CU-109**

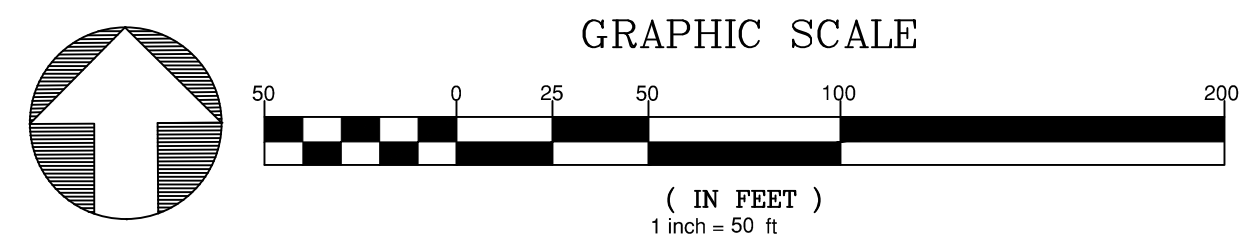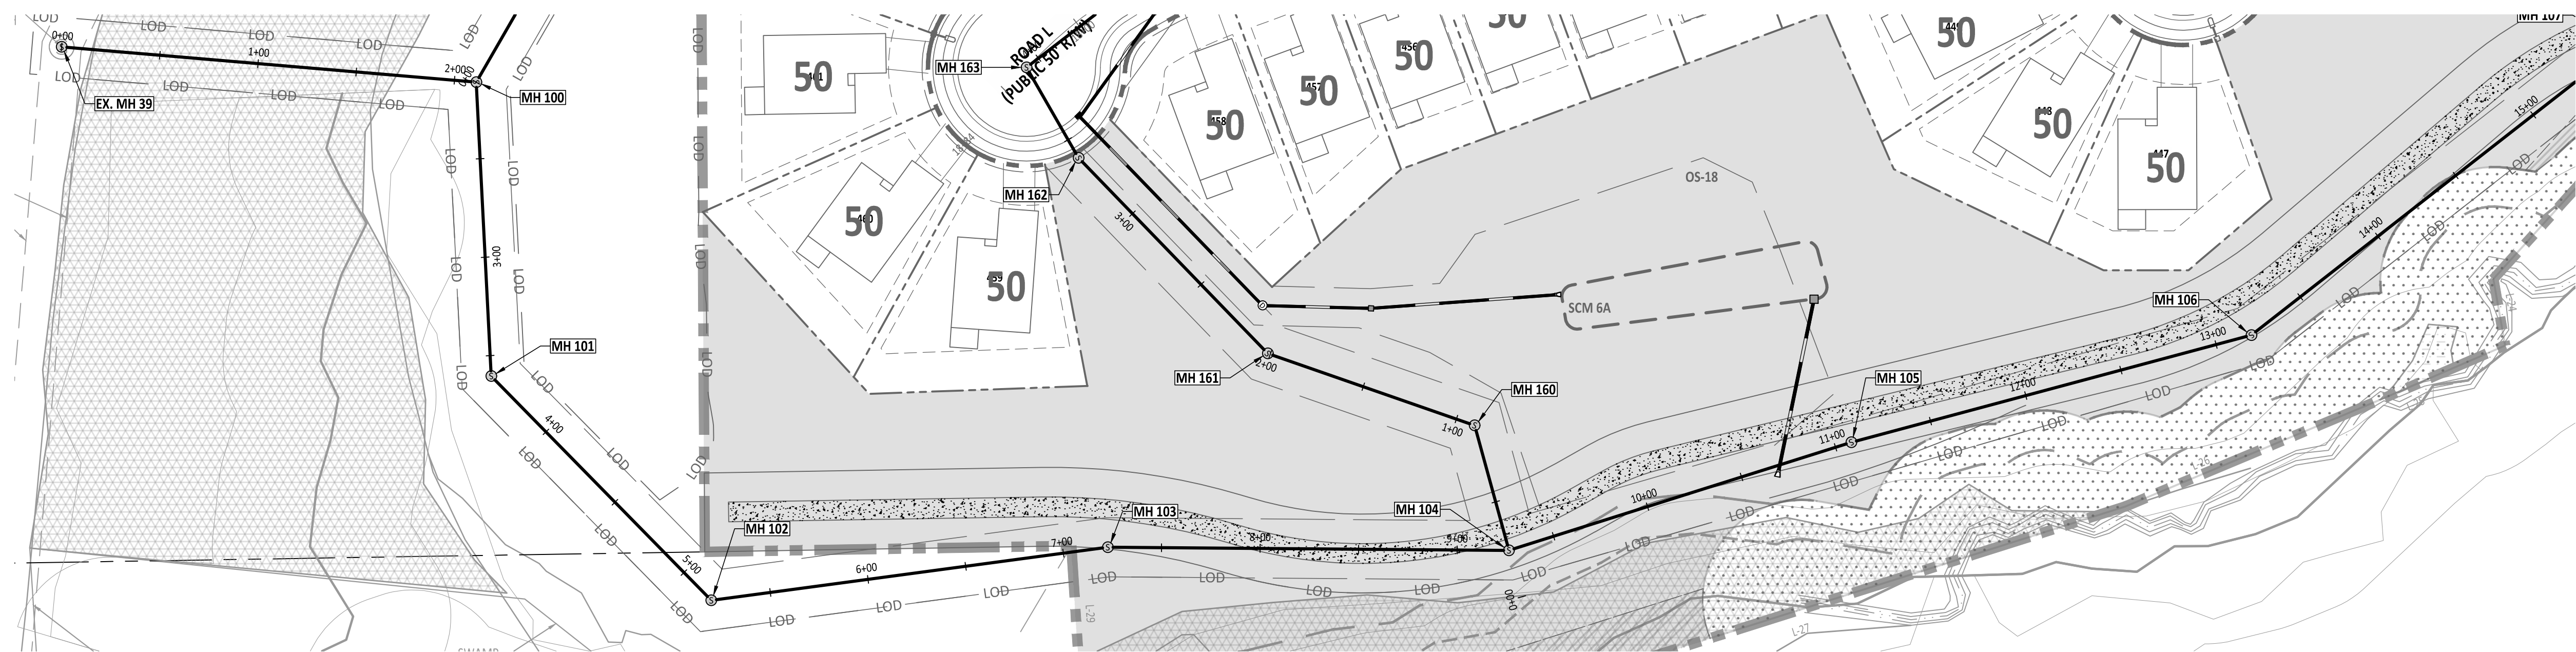


EX. MH# 39 TO MH# 105

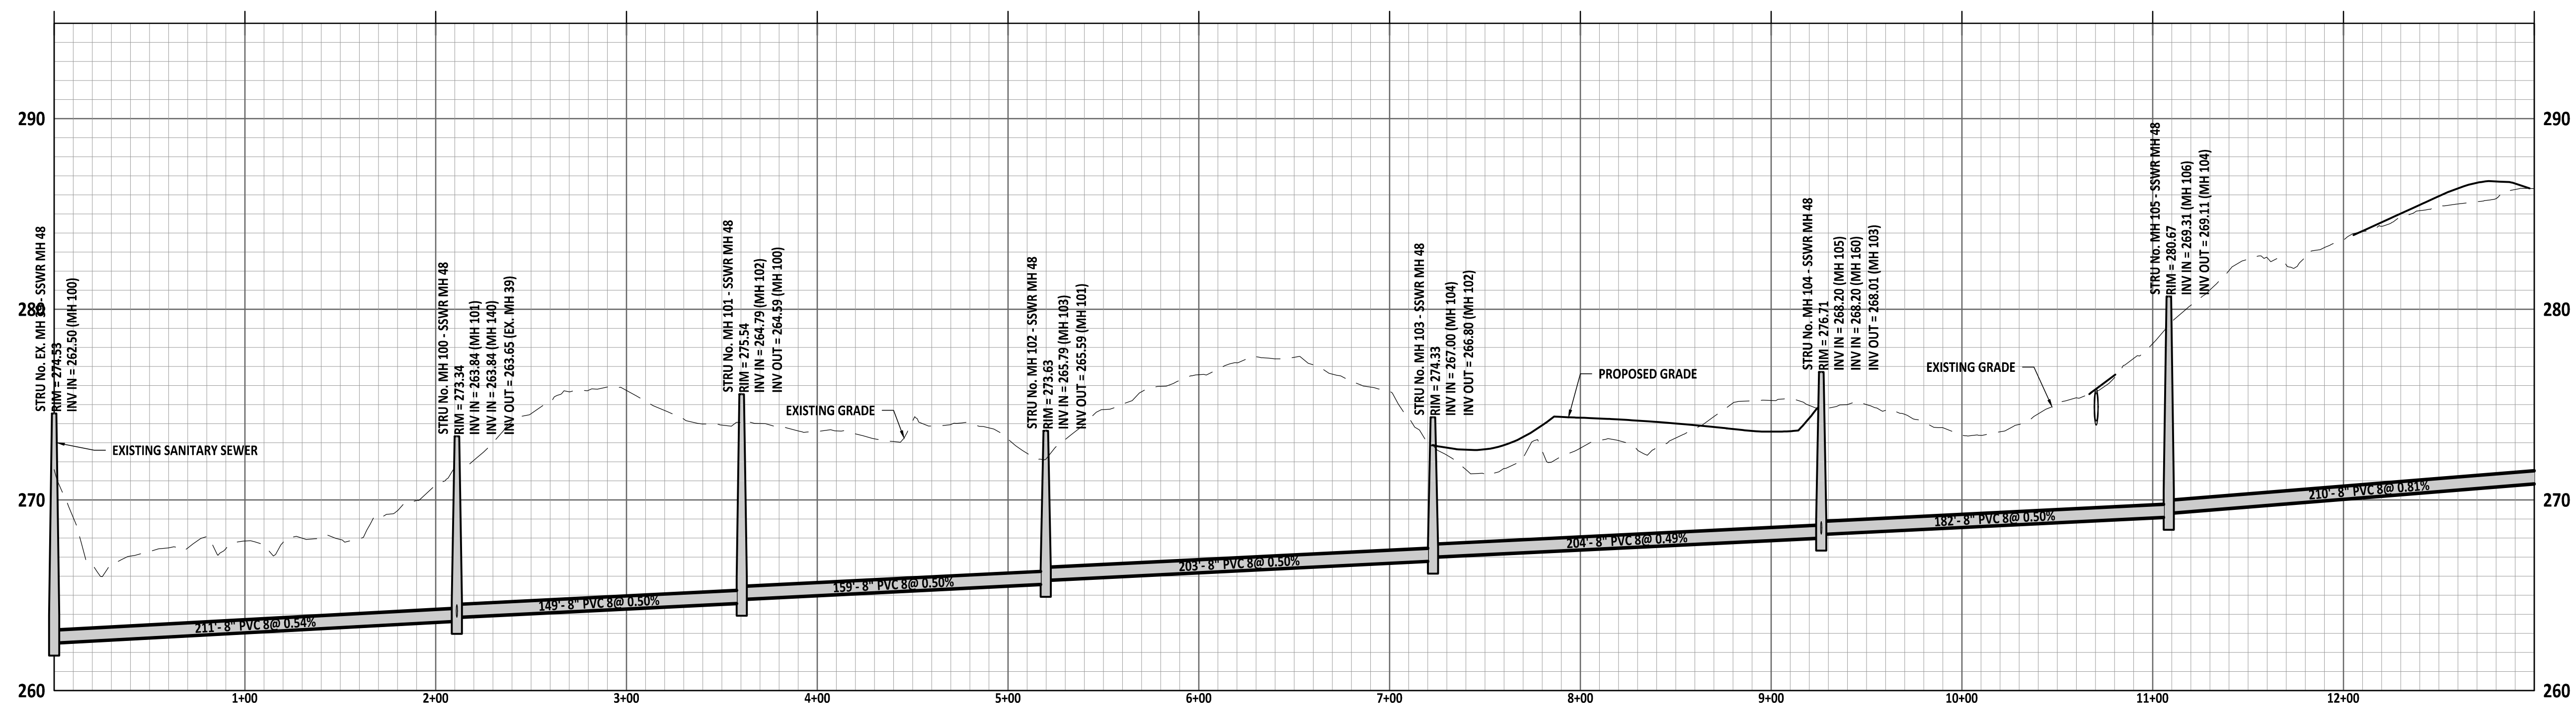

99. Correct sheet number. This applies to multiple sheets.




 PROJECT NUMBER = PSP-24-07



AMERICAN
Engineering

American Engineering Associates - Southeast, P.A.
4020 Westchase Boulevard, Suite 450
Raleigh, NC 27607
919-468-1101

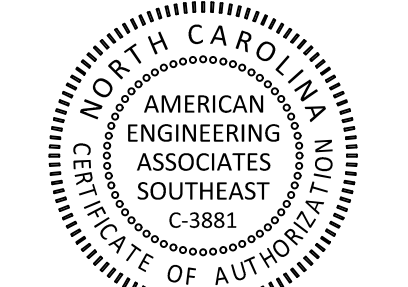

PRELIMINARY

PRELIMINARY

DO NOT USE FOR
56528

FOR INFORMATION, ONLY

[illegible]

STIPULATION FOR REUSE

THIS DRAWING WAS PREPARED FOR USE ON THE SPECIFIC SITE, NAMED HEREON, CONTEMPORANEOUSLY WITH ITS ISSUE DATE AS LISTED, HEREON. AND IT IS NOT SUITABLE FOR USE ON A DIFFERENT PROJECT SITE OR AT A LATER TIME. USE OF THIS DRAWING FOR REFERENCE OR EXAMPLE ON ANOTHER PROJECT REQUIRES THE SERVICES OF PROPERLY LICENSED ARCHITECTS AND ENGINEERS. REPRODUCTION OF THIS DRAWING FOR REUSE ON ANOTHER PROJECT IS NOT AUTHORIZED AND MAY BE CONTRARY TO THE LAW.

MERRITT RESERVE
CU-200 PLAN & PROFILE
ROLESVILLE RD
WAKE COUNTY NC 27312

JOB NUMBER: 23-0004

CHECKED BY: BH





DRAWN BY: DH/RC/SM/GE/MA/LL/JB






SET TITLE:

S SET THREE.

**CU-200 PLAN
& PROFILE**

SHEET NO.:

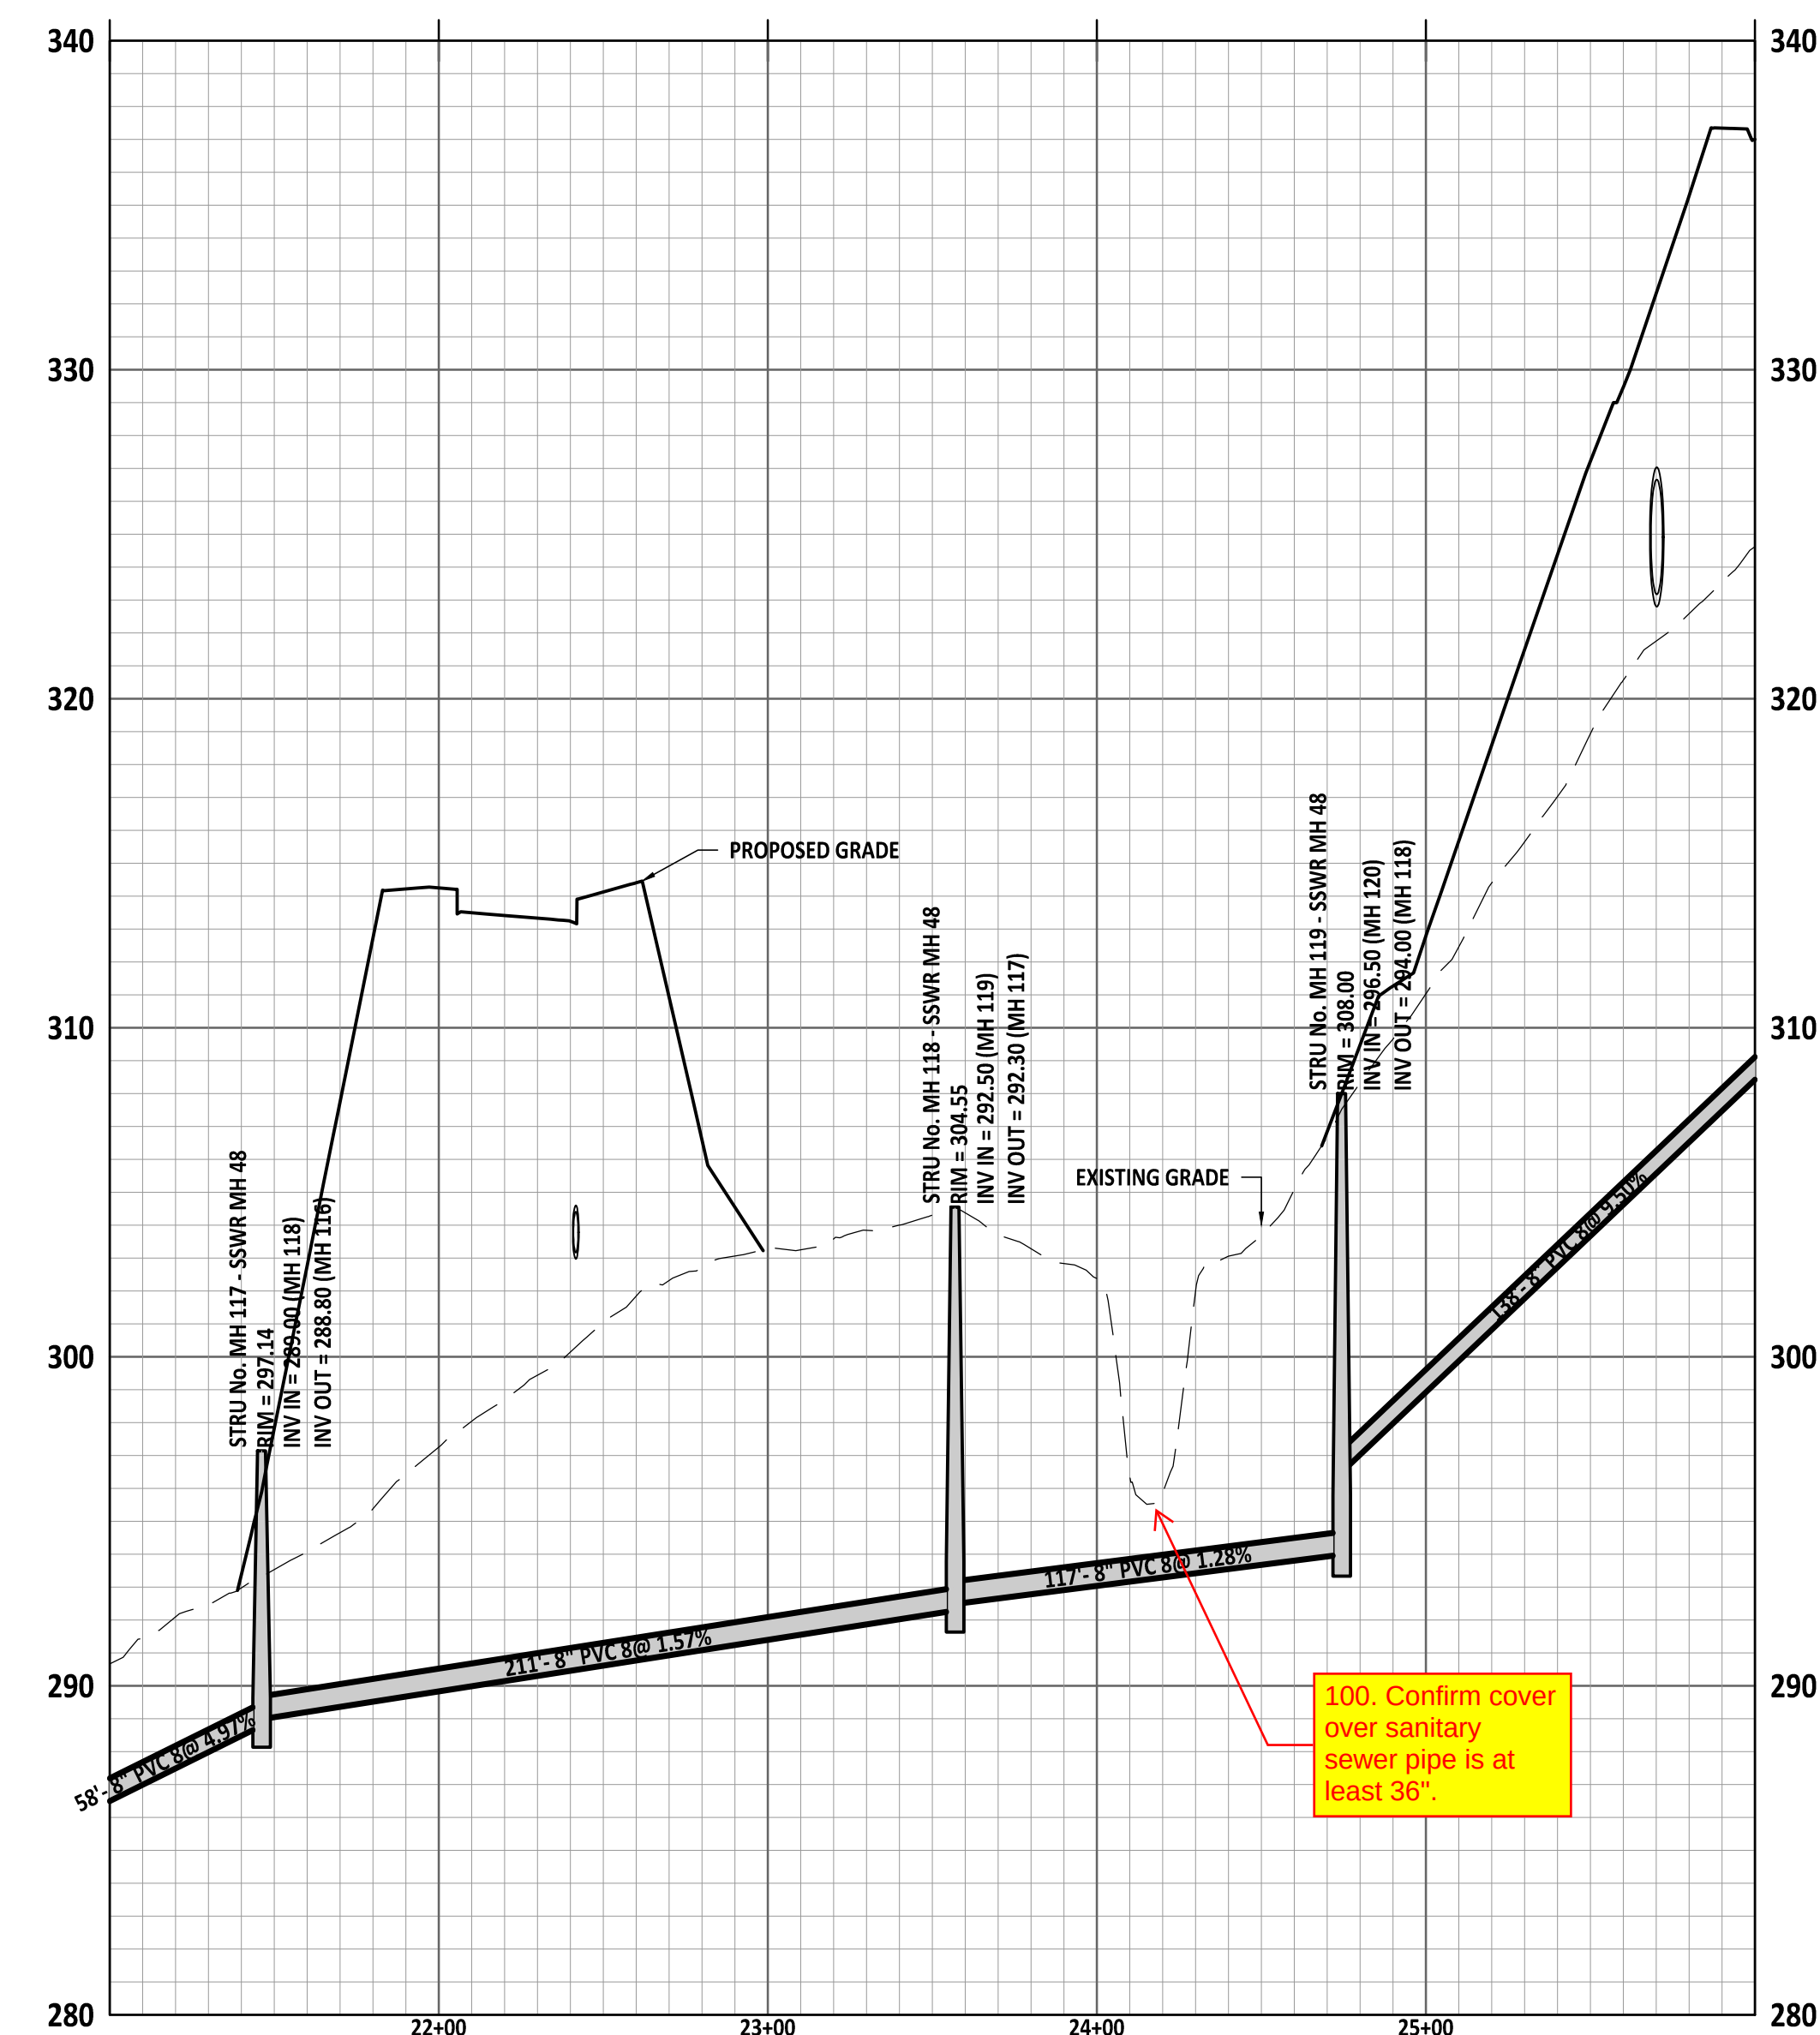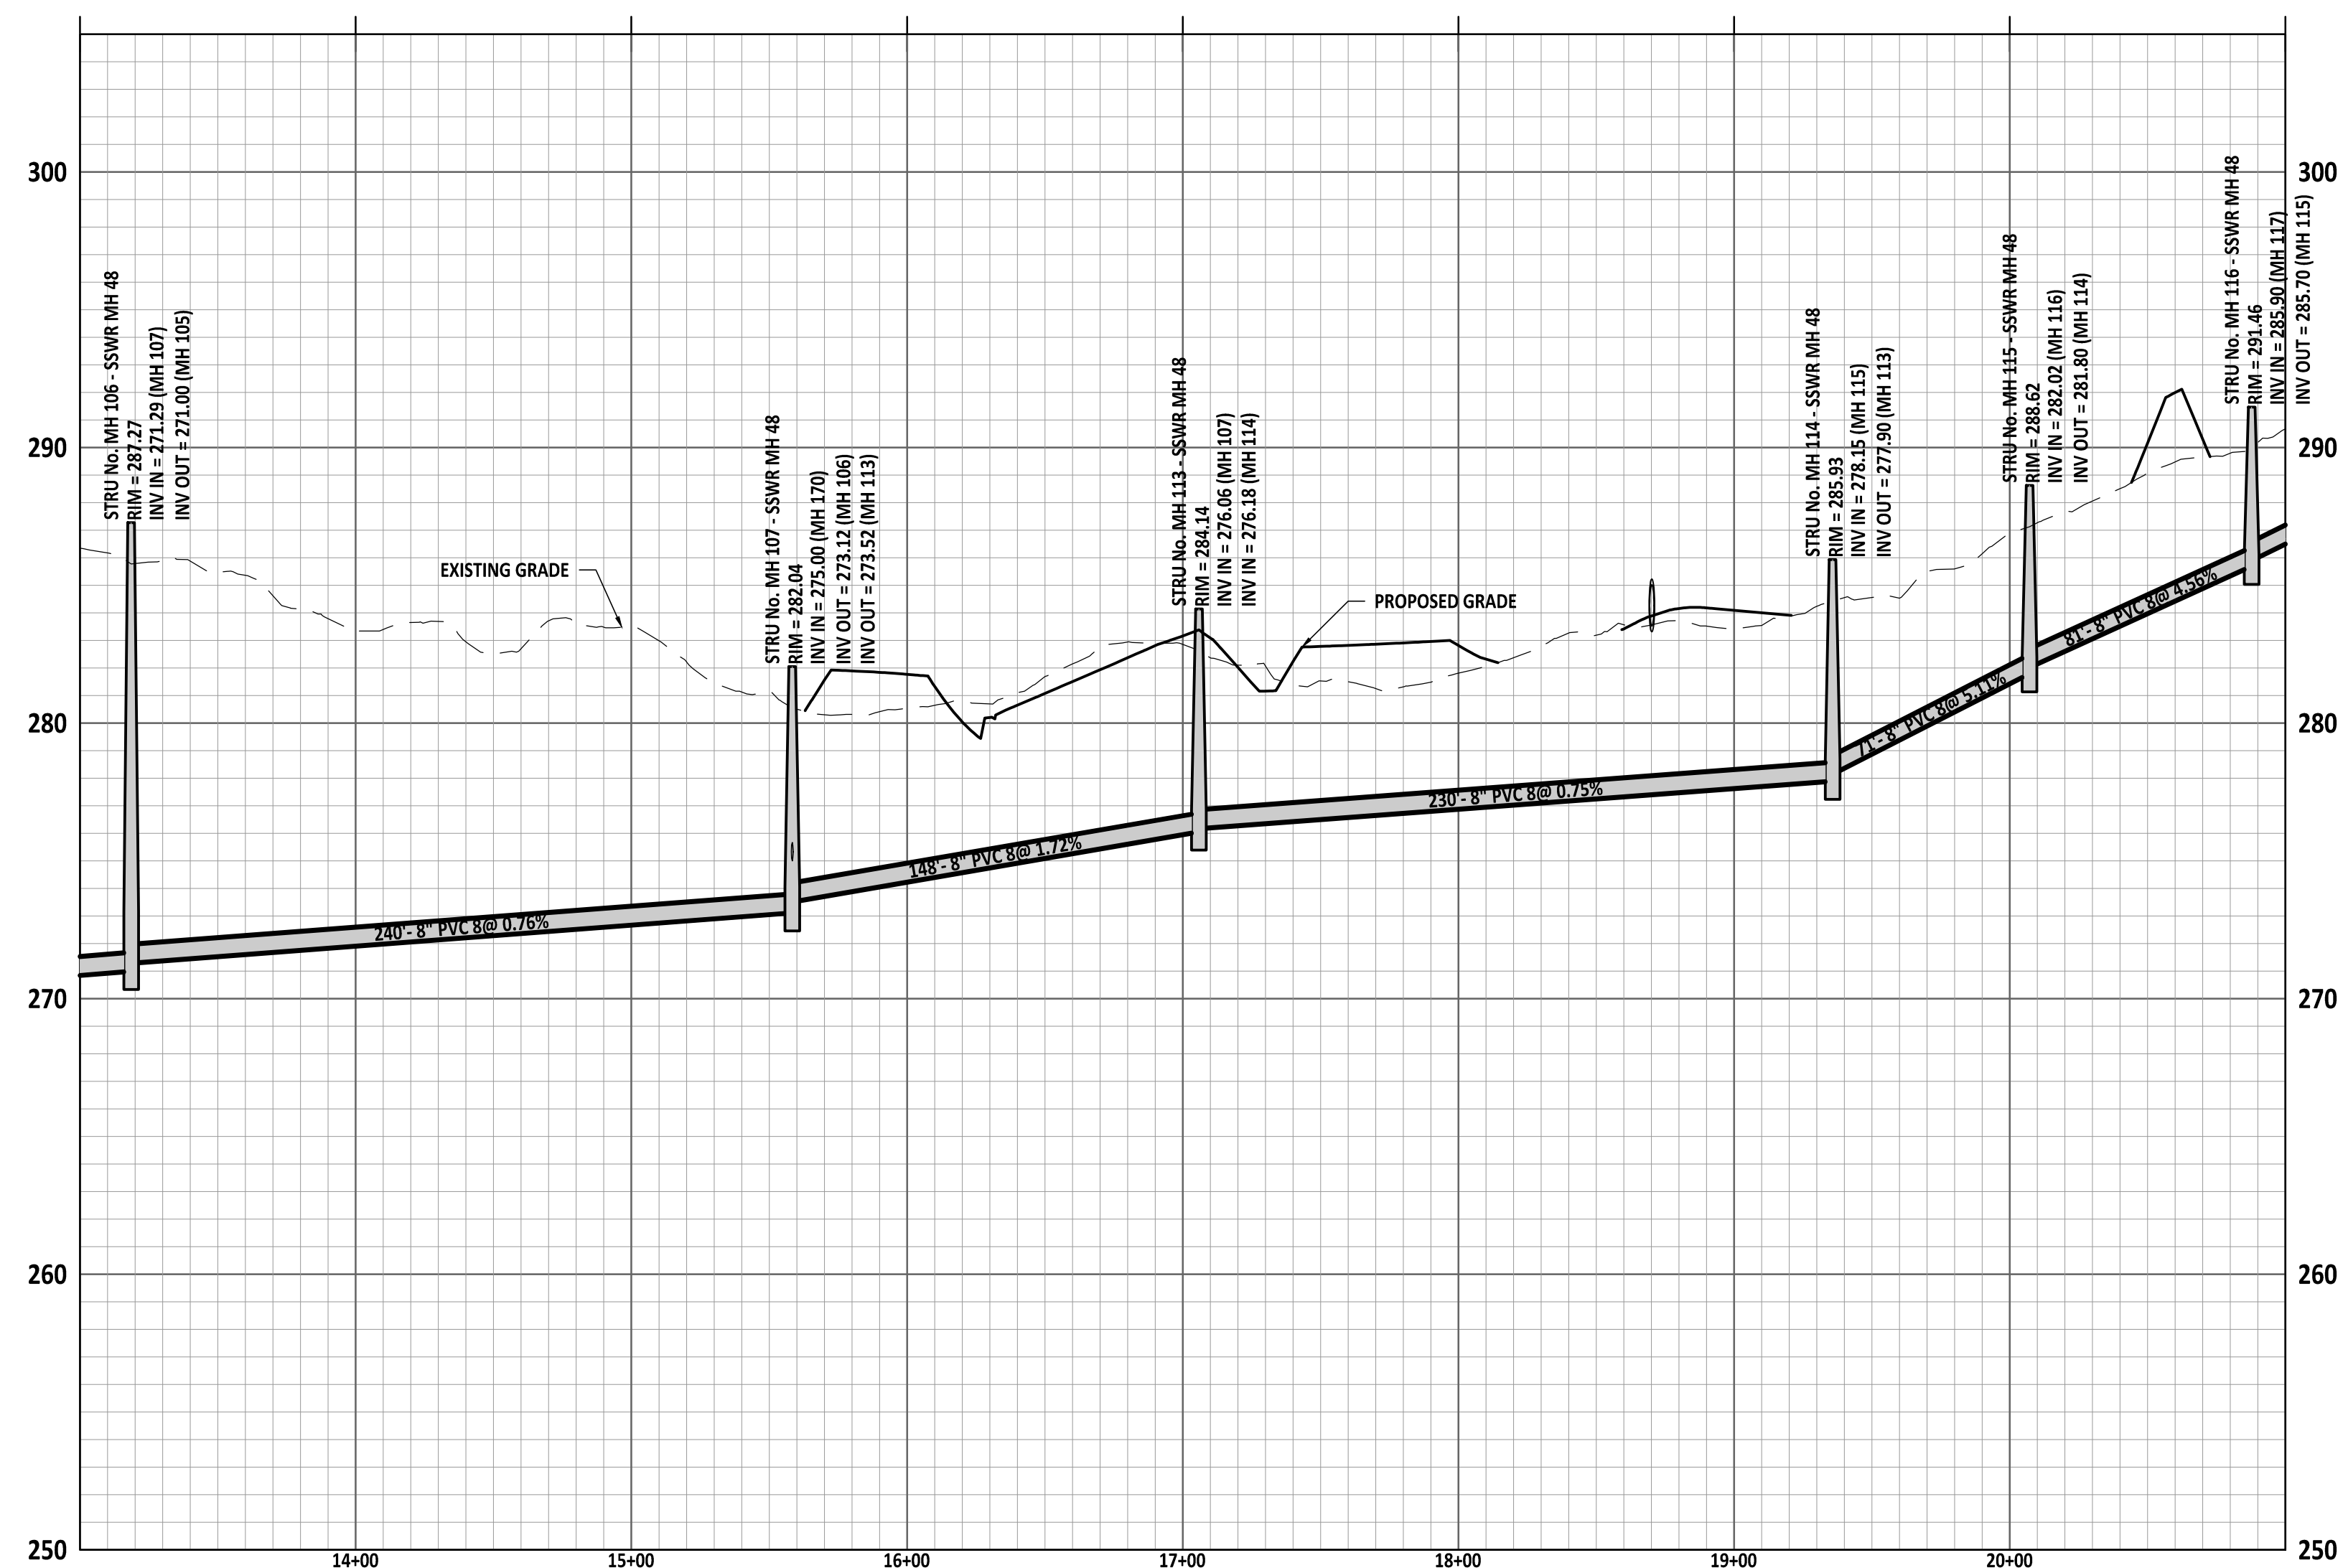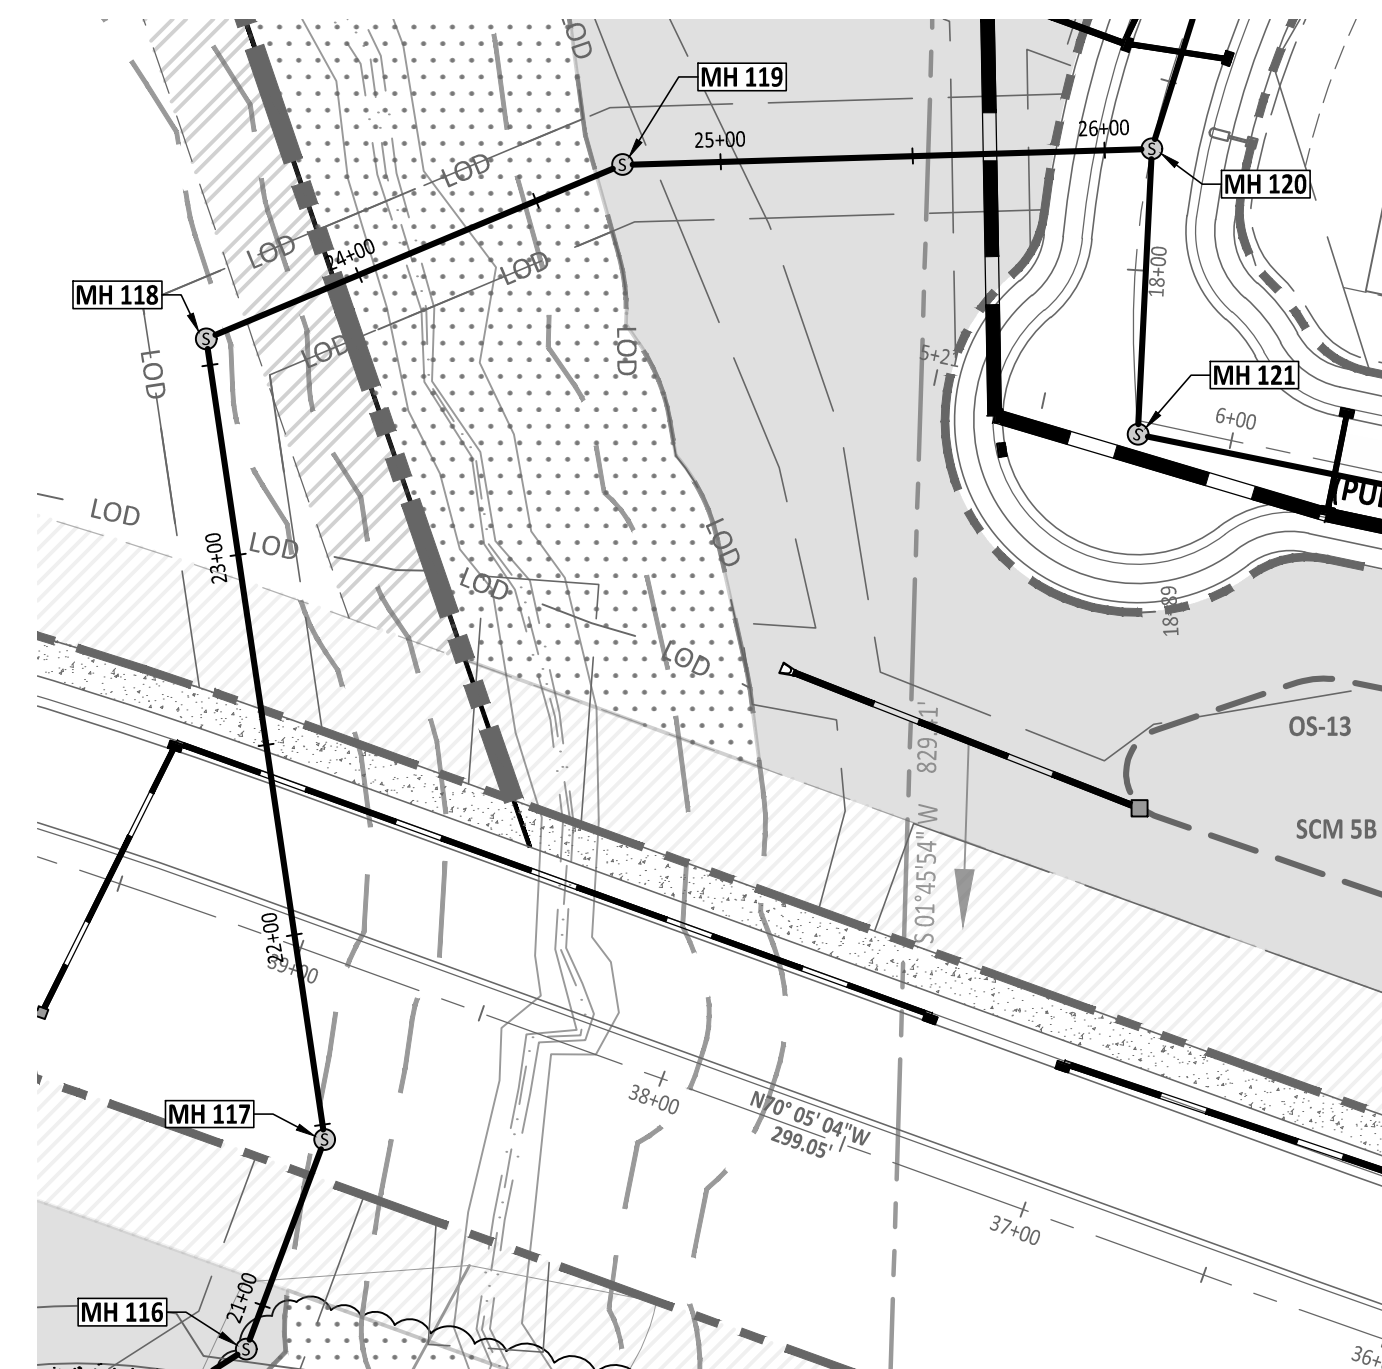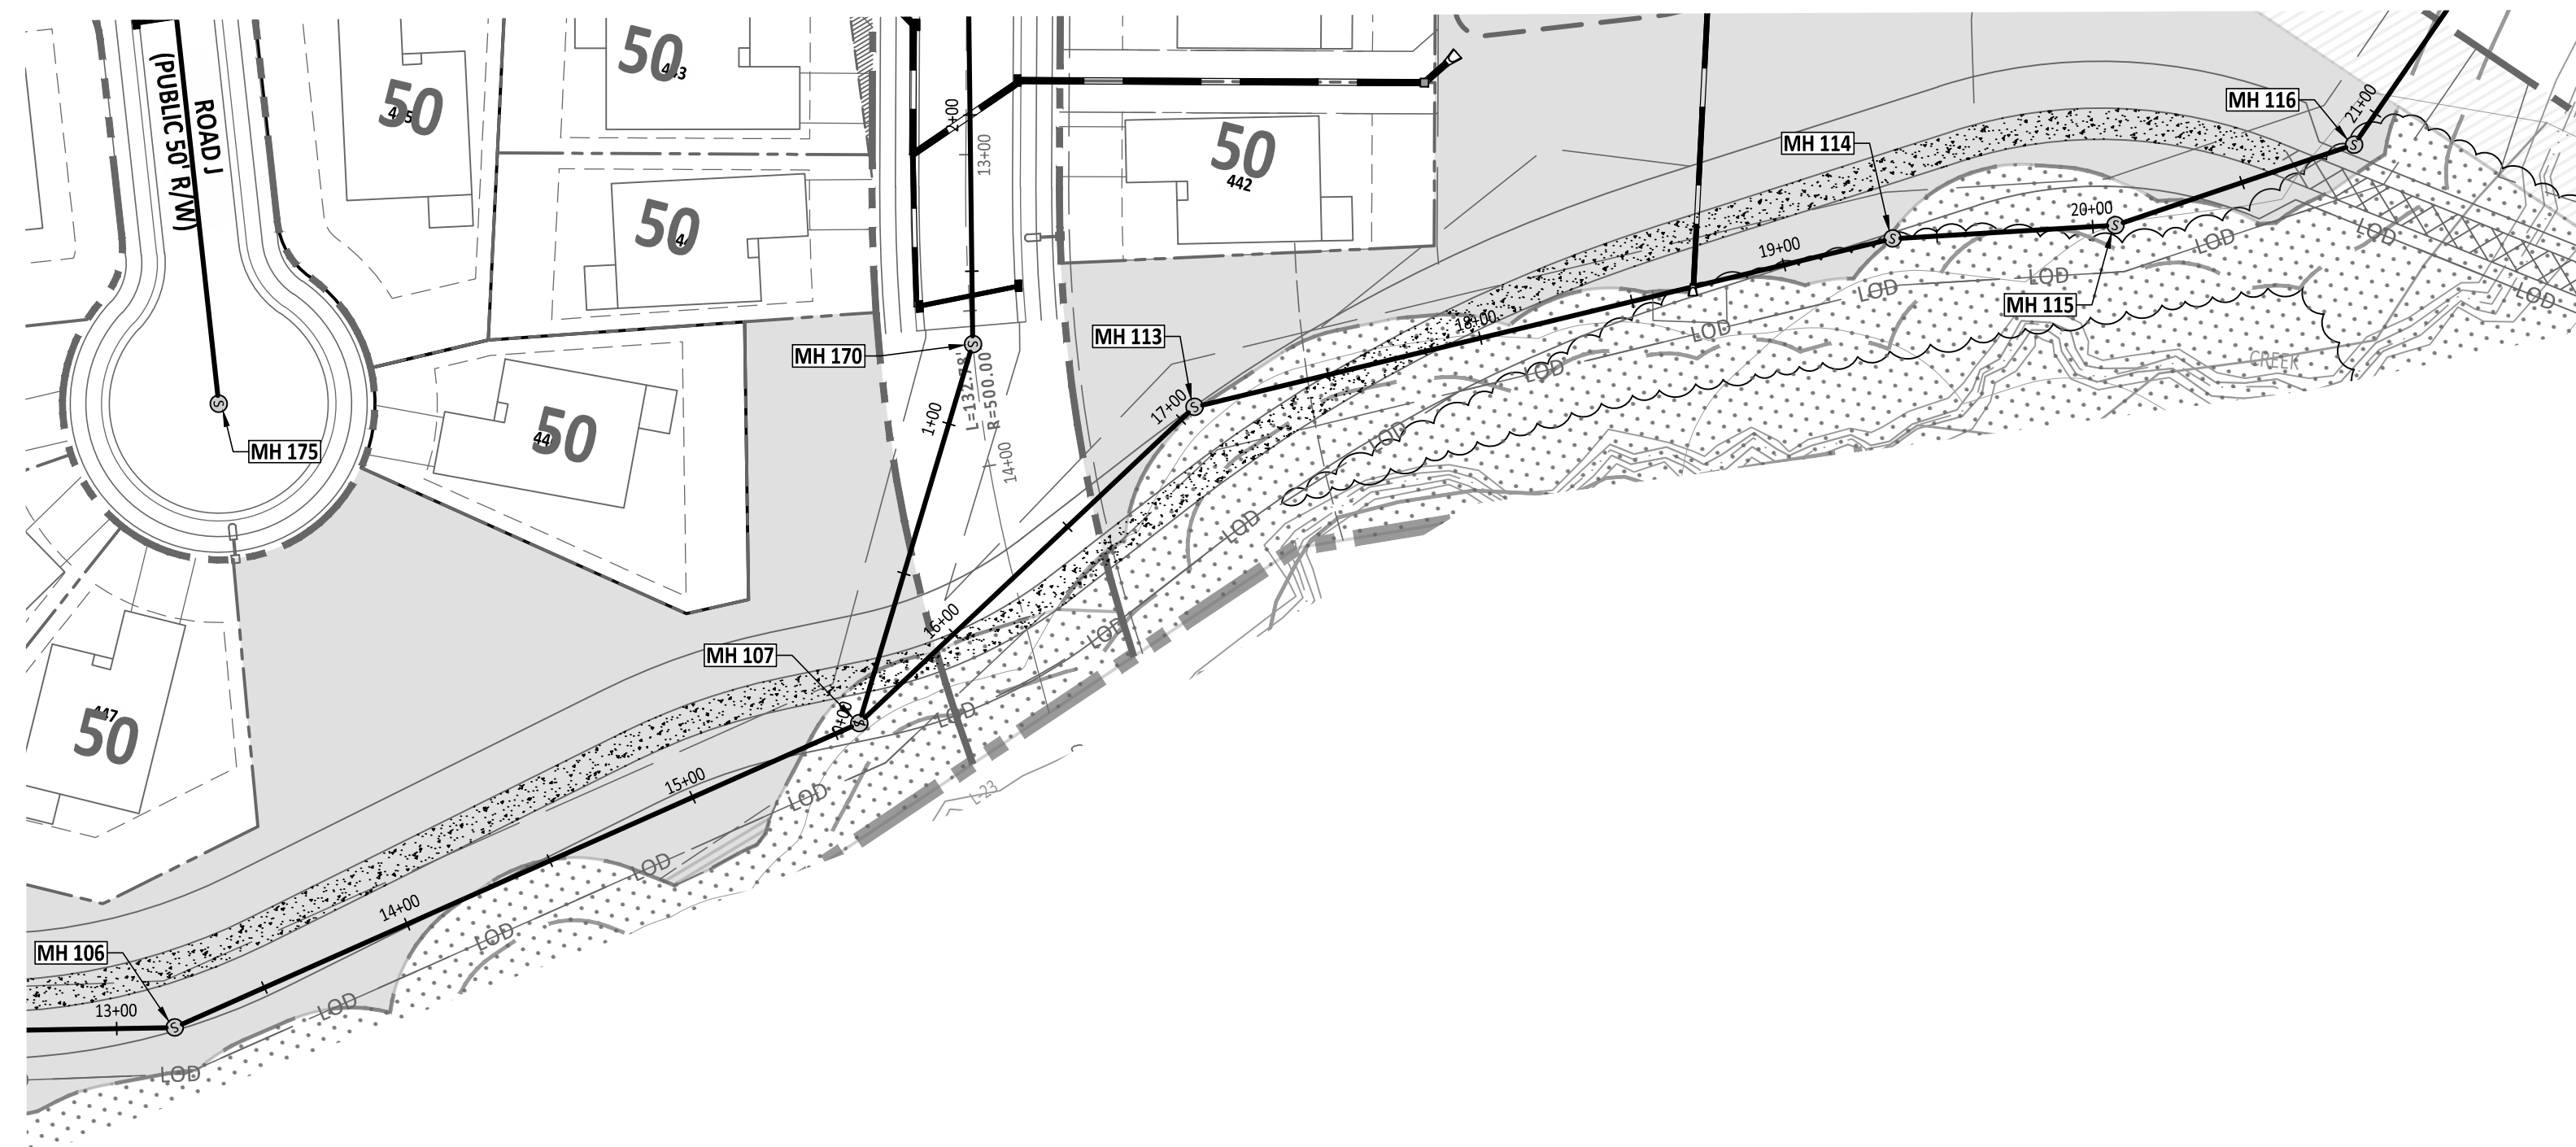

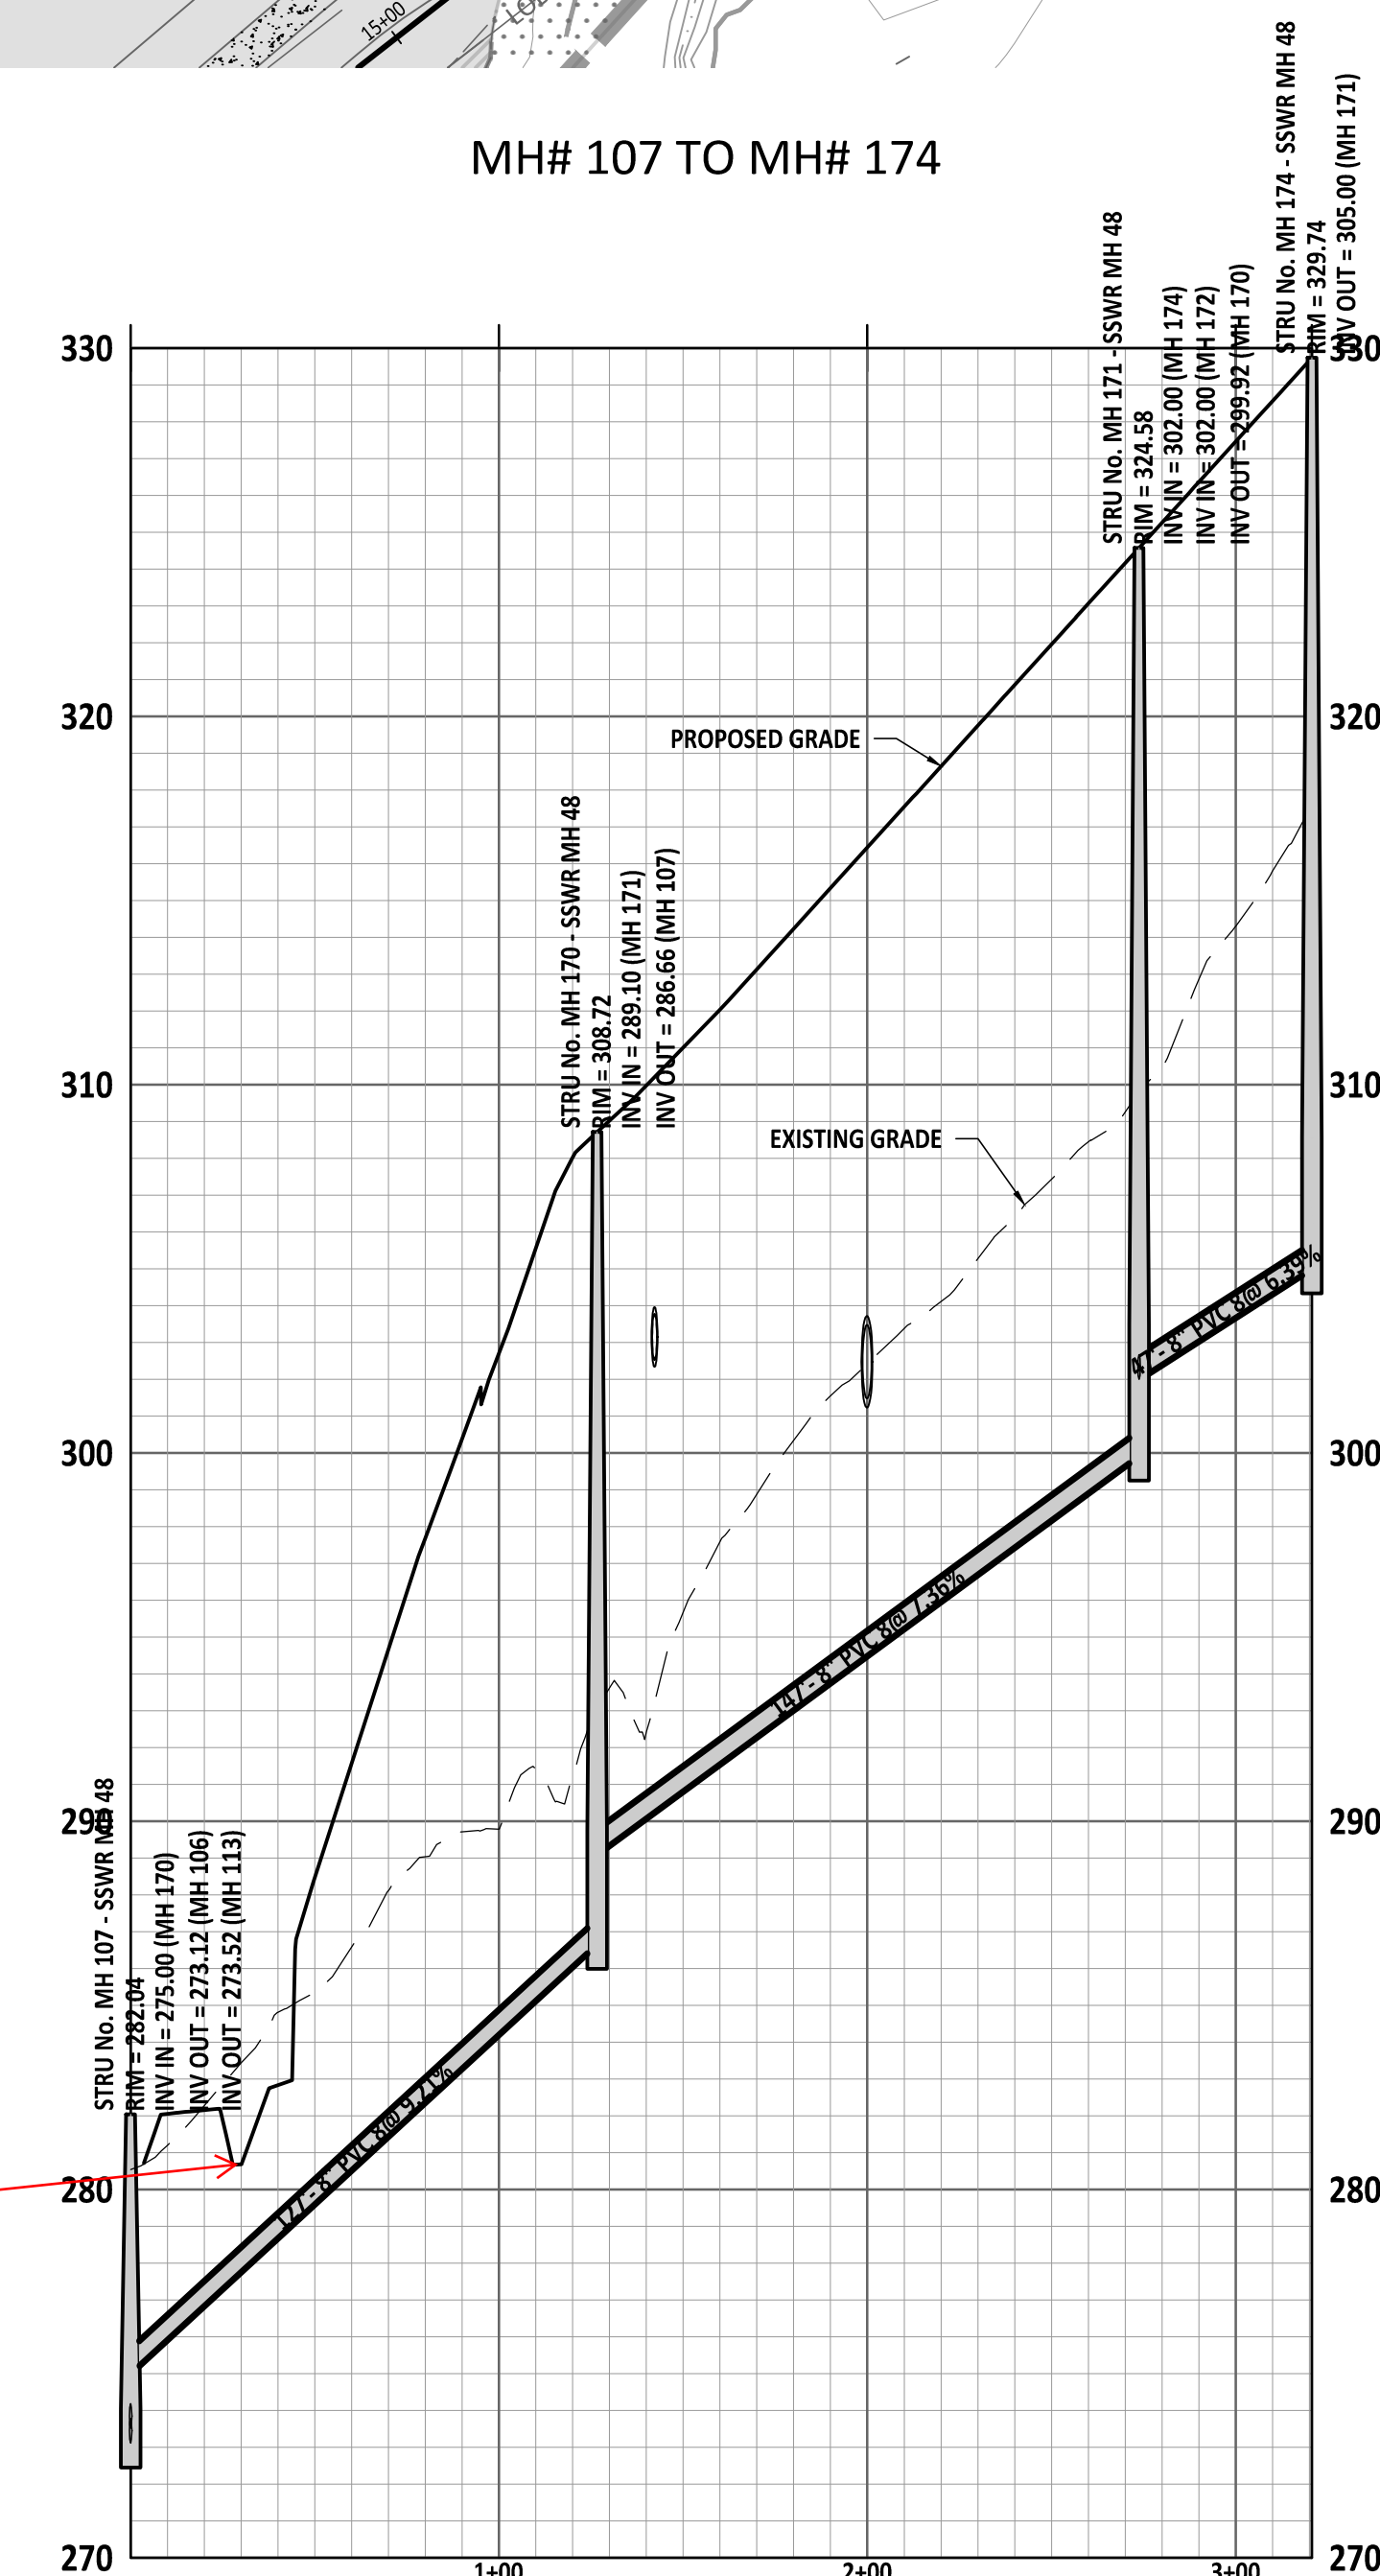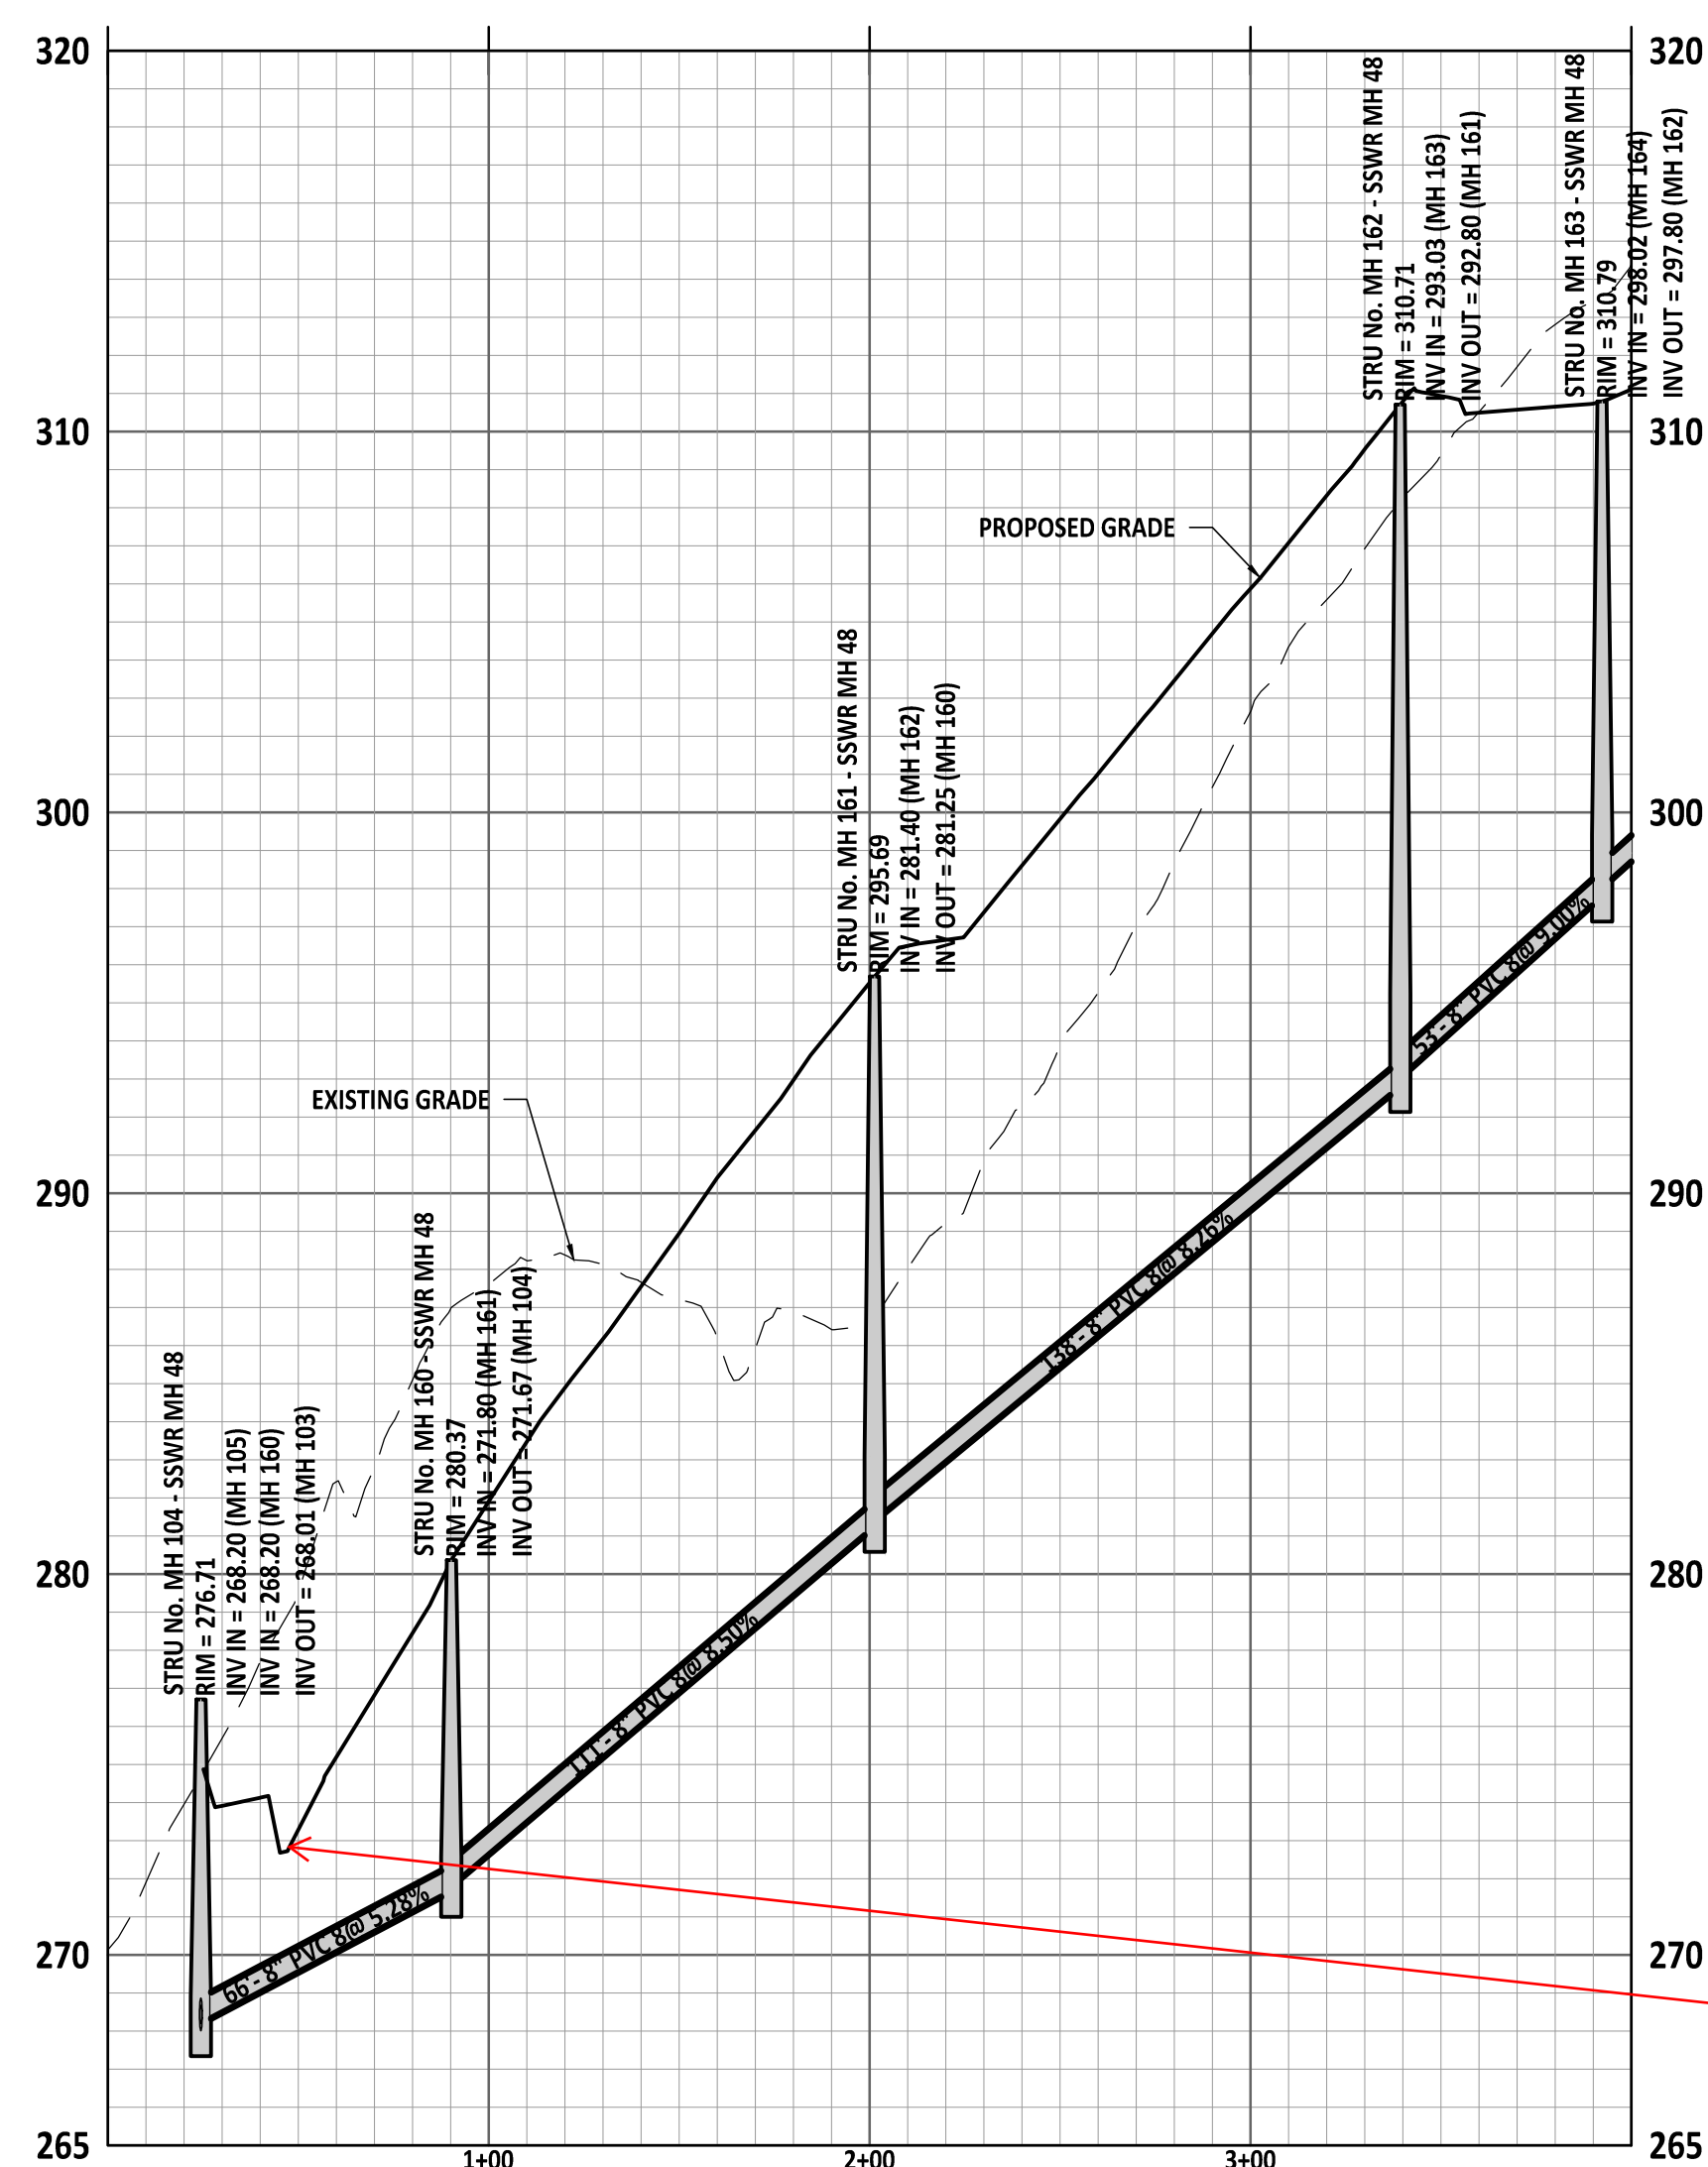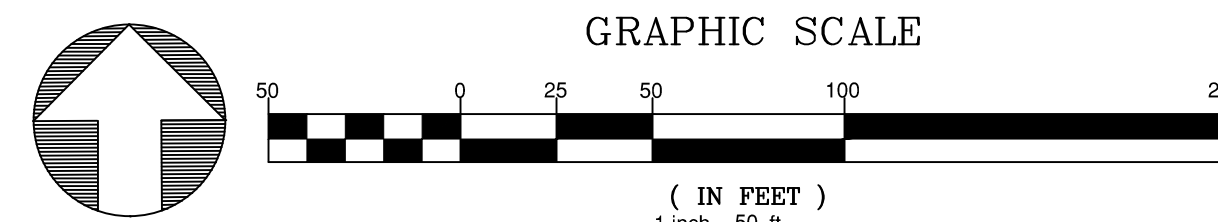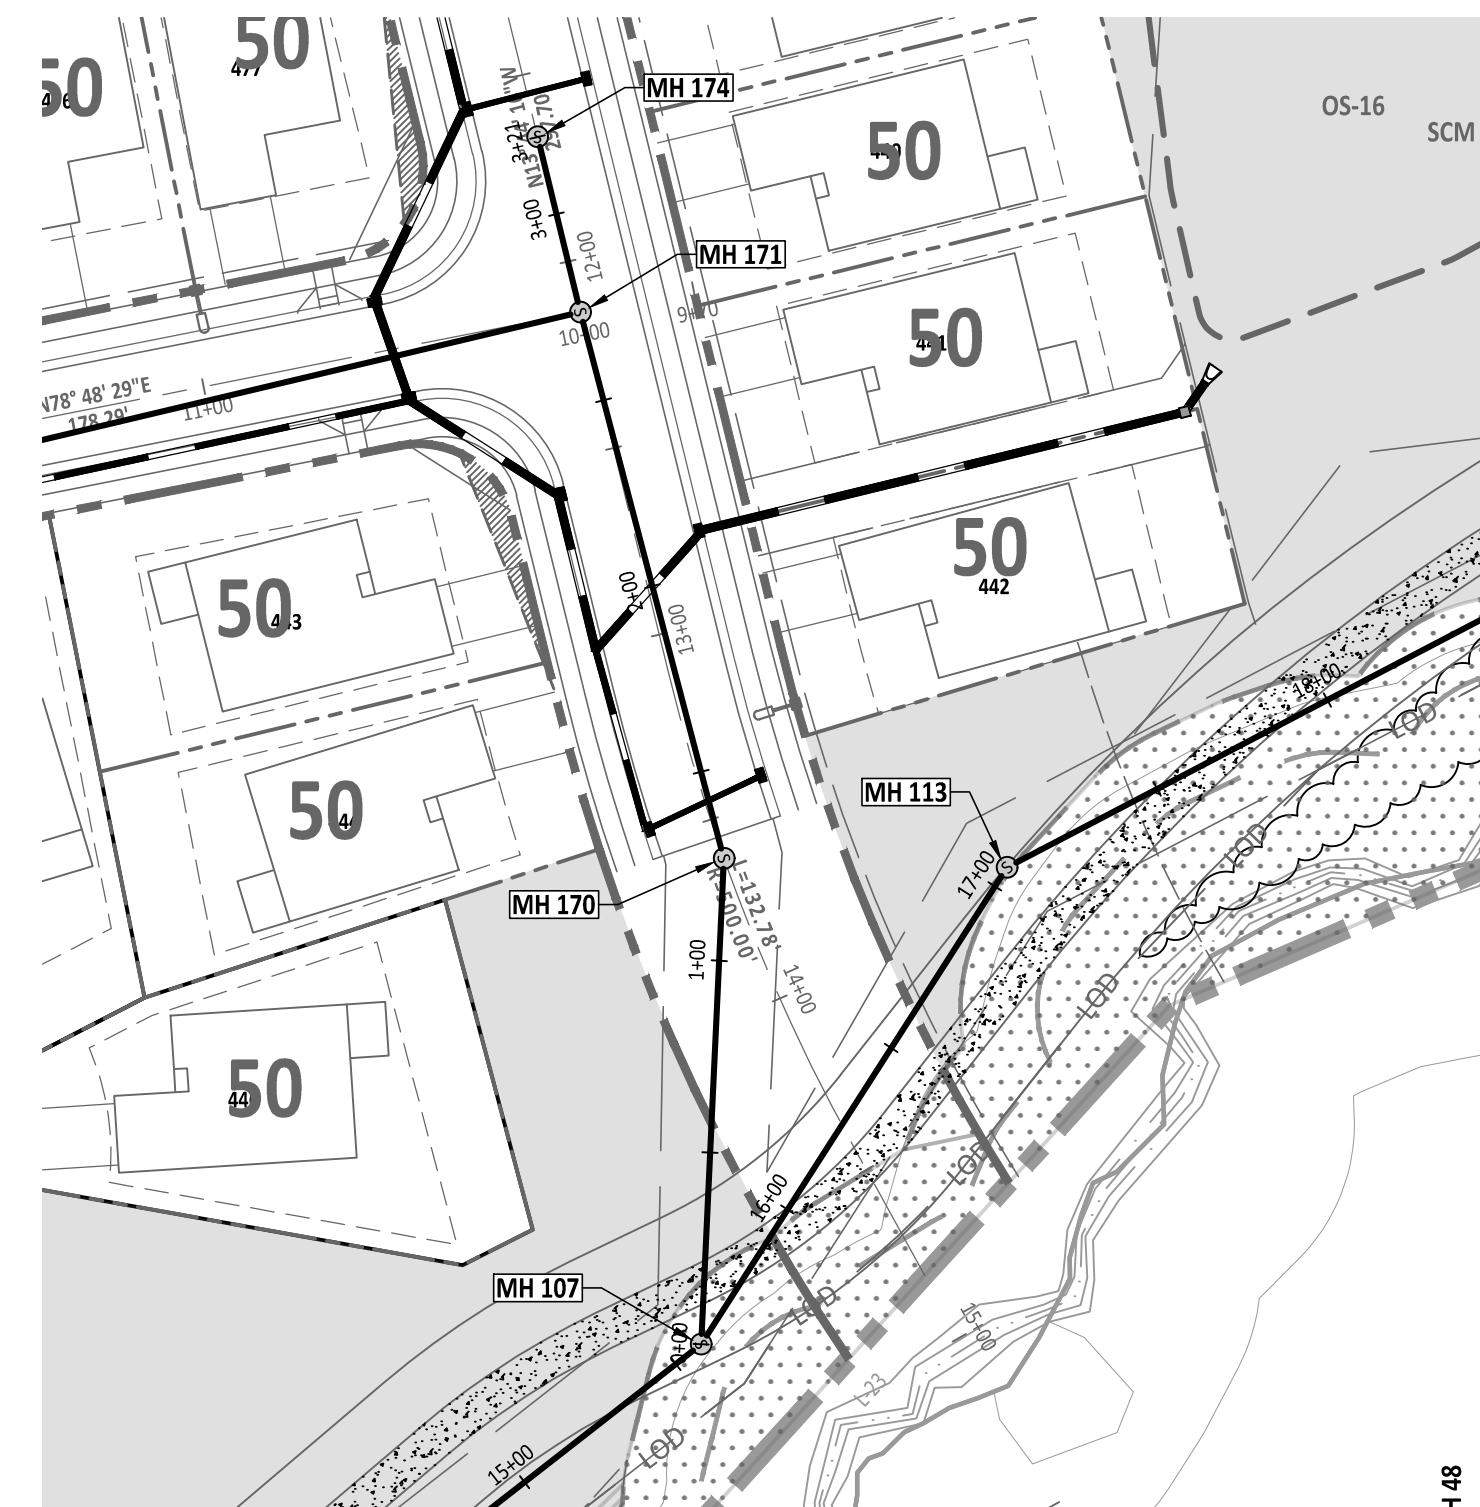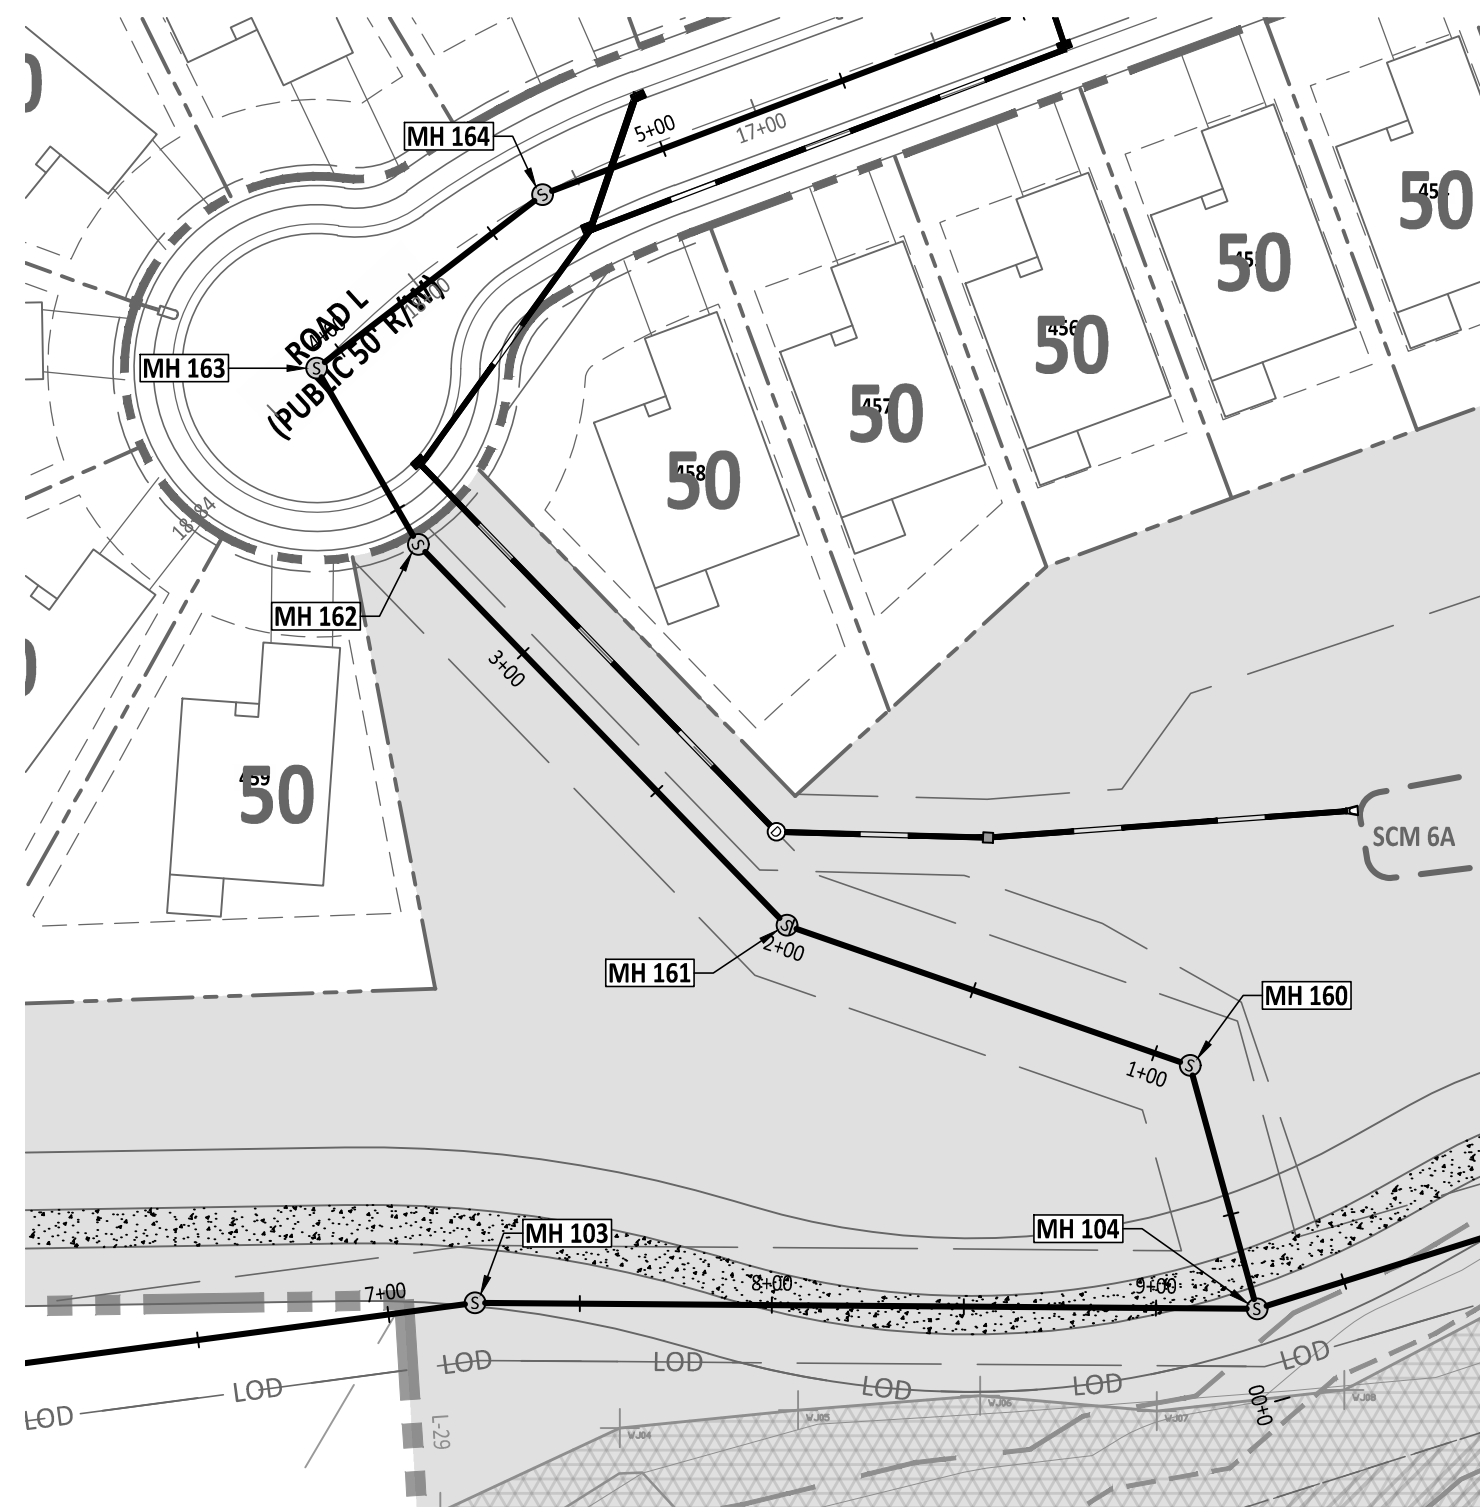

100. Confirm cover over sanitary sewer pipe is at least 36".

PROJECT NUMBER = PSP-24-07



AMERICAN
Engineering

American Engineering Associates - Southeast, P.A.
4020 Westchase Boulevard, Suite 450
Raleigh, NC 27607
919-469-1101

PRELIMINARY
PROPOSED
DO NOT USE FOR
CONSTRUCTION

FOR INFORMATION, ONLY

[illegible]





STIPULATION FOR REUSE

THIS DRAWING WAS PREPARED FOR USE ON THE SPECIFIC SITE, NAMED HEREON, CONTEMPORANEOUSLY WITH ITS ISSUE DATE AS LISTED, HEREON, AND IT IS NOT SUITABLE FOR USE ON A DIFFERENT PROJECT SITE OR AT A LATER TIME. USE OF THIS DRAWING FOR REFERENCE OR EXAMPLE ON ANOTHER PROJECT REQUIRES THE SERVICES OF PROPERLY LICENSED ARCHITECTS AND ENGINEERS. REPRODUCTION OF THIS DRAWING FOR REUSE ON ANOTHER PROJECT IS NOT AUTHORIZED AND MAY BE CONTRARY TO THE LAW.

MERRITT RESERVE
CU-203 PLAN & PROFILE
ROLESVILLE RD
WAKE COUNTY NC 27312

JOB NUMBER:	23-000
CHECKED BY:	B
DRAWN BY:	DH/RC/SM/GE/MA/LL/J
DATE:	04/14/202
SHEET TITLE:	

SHEET NO.:

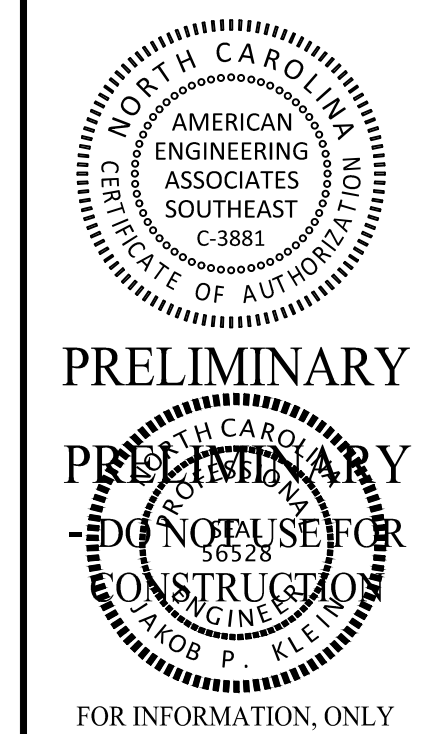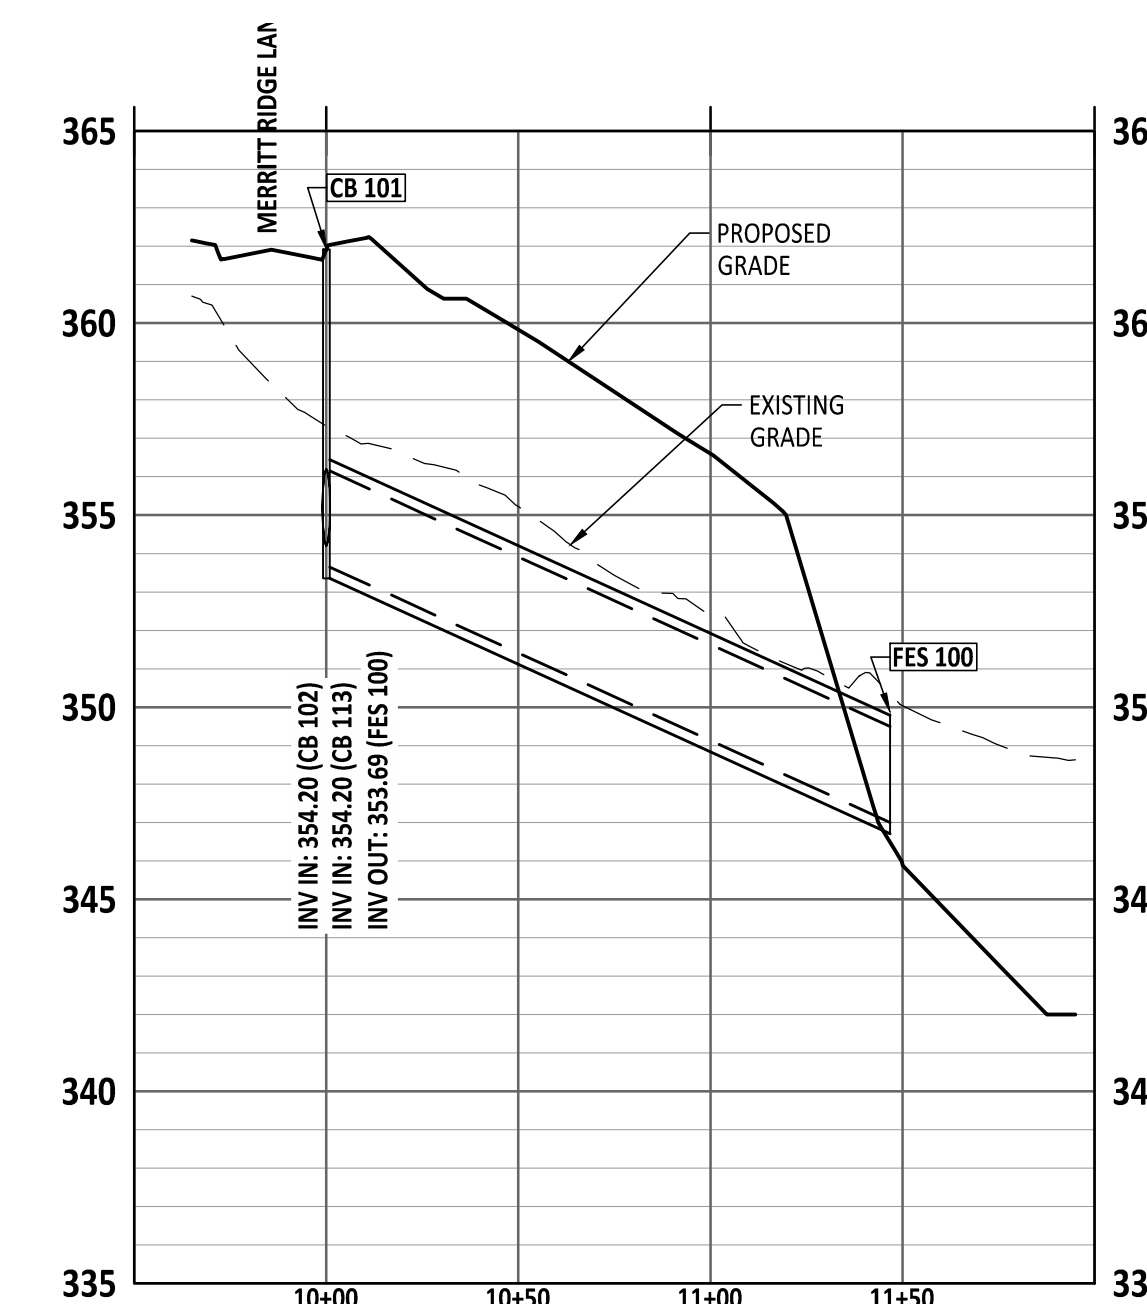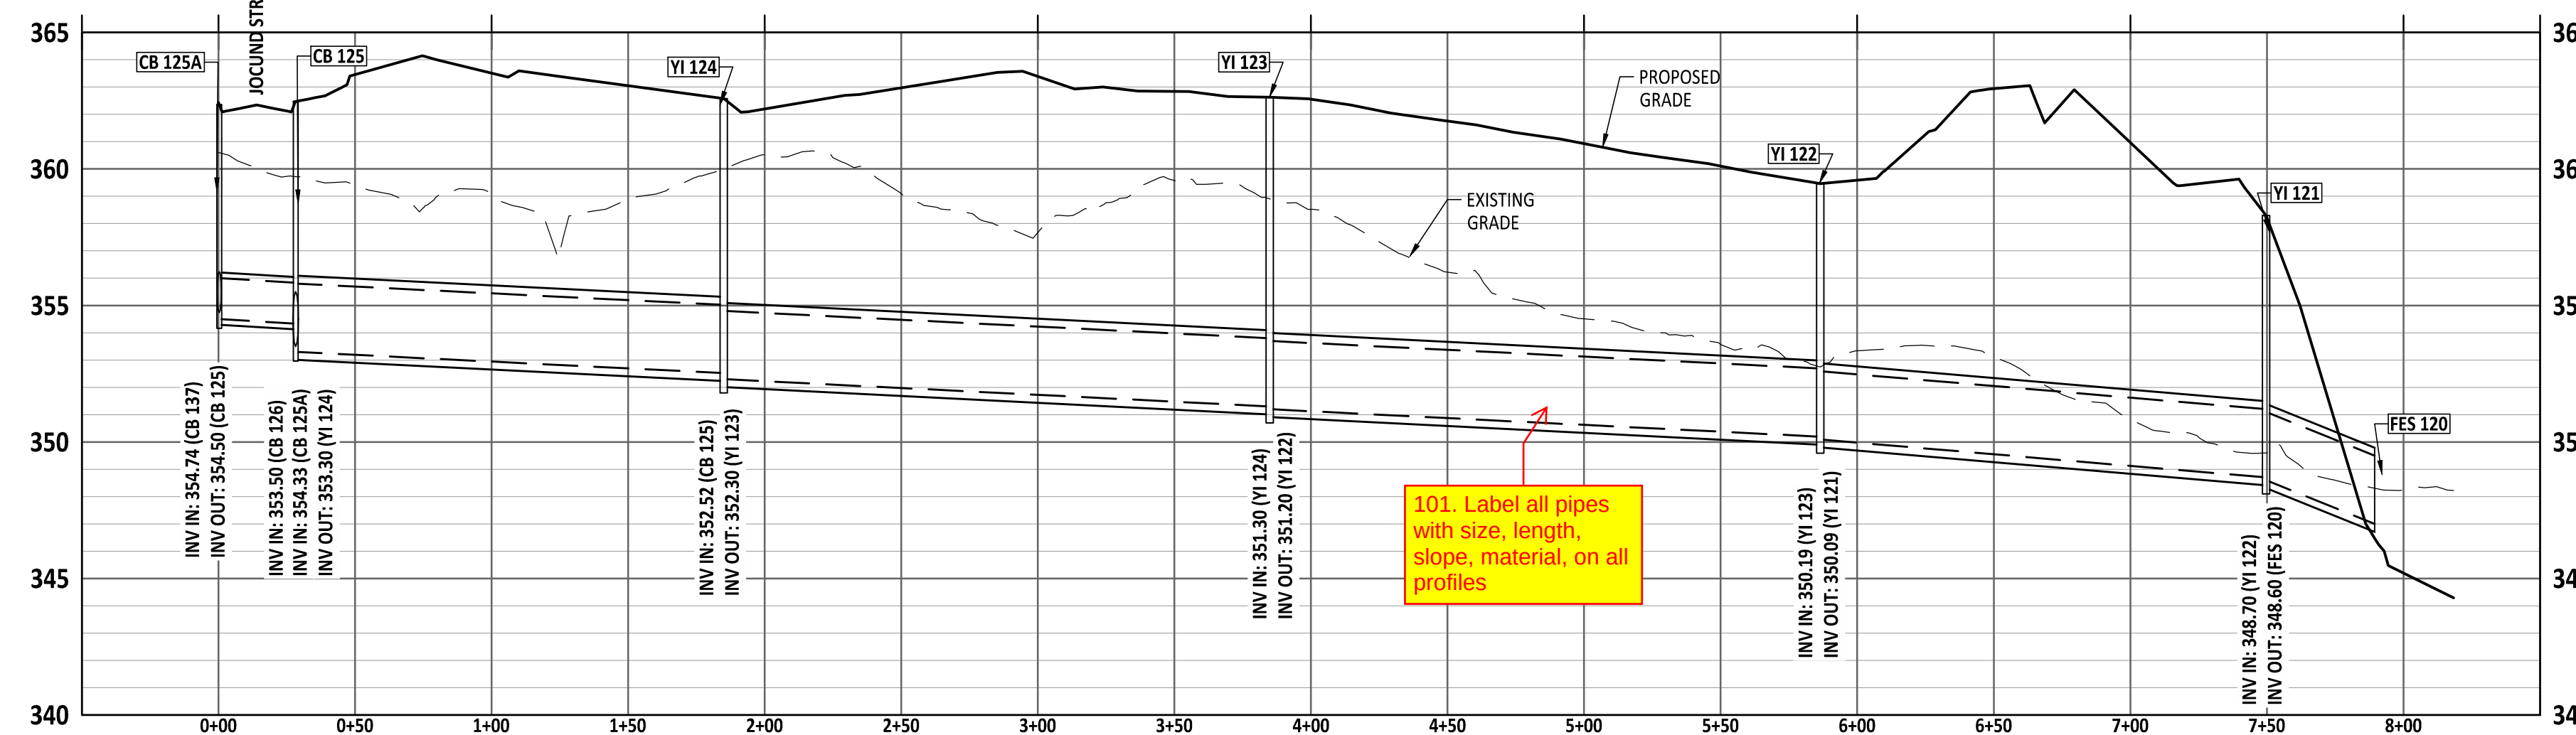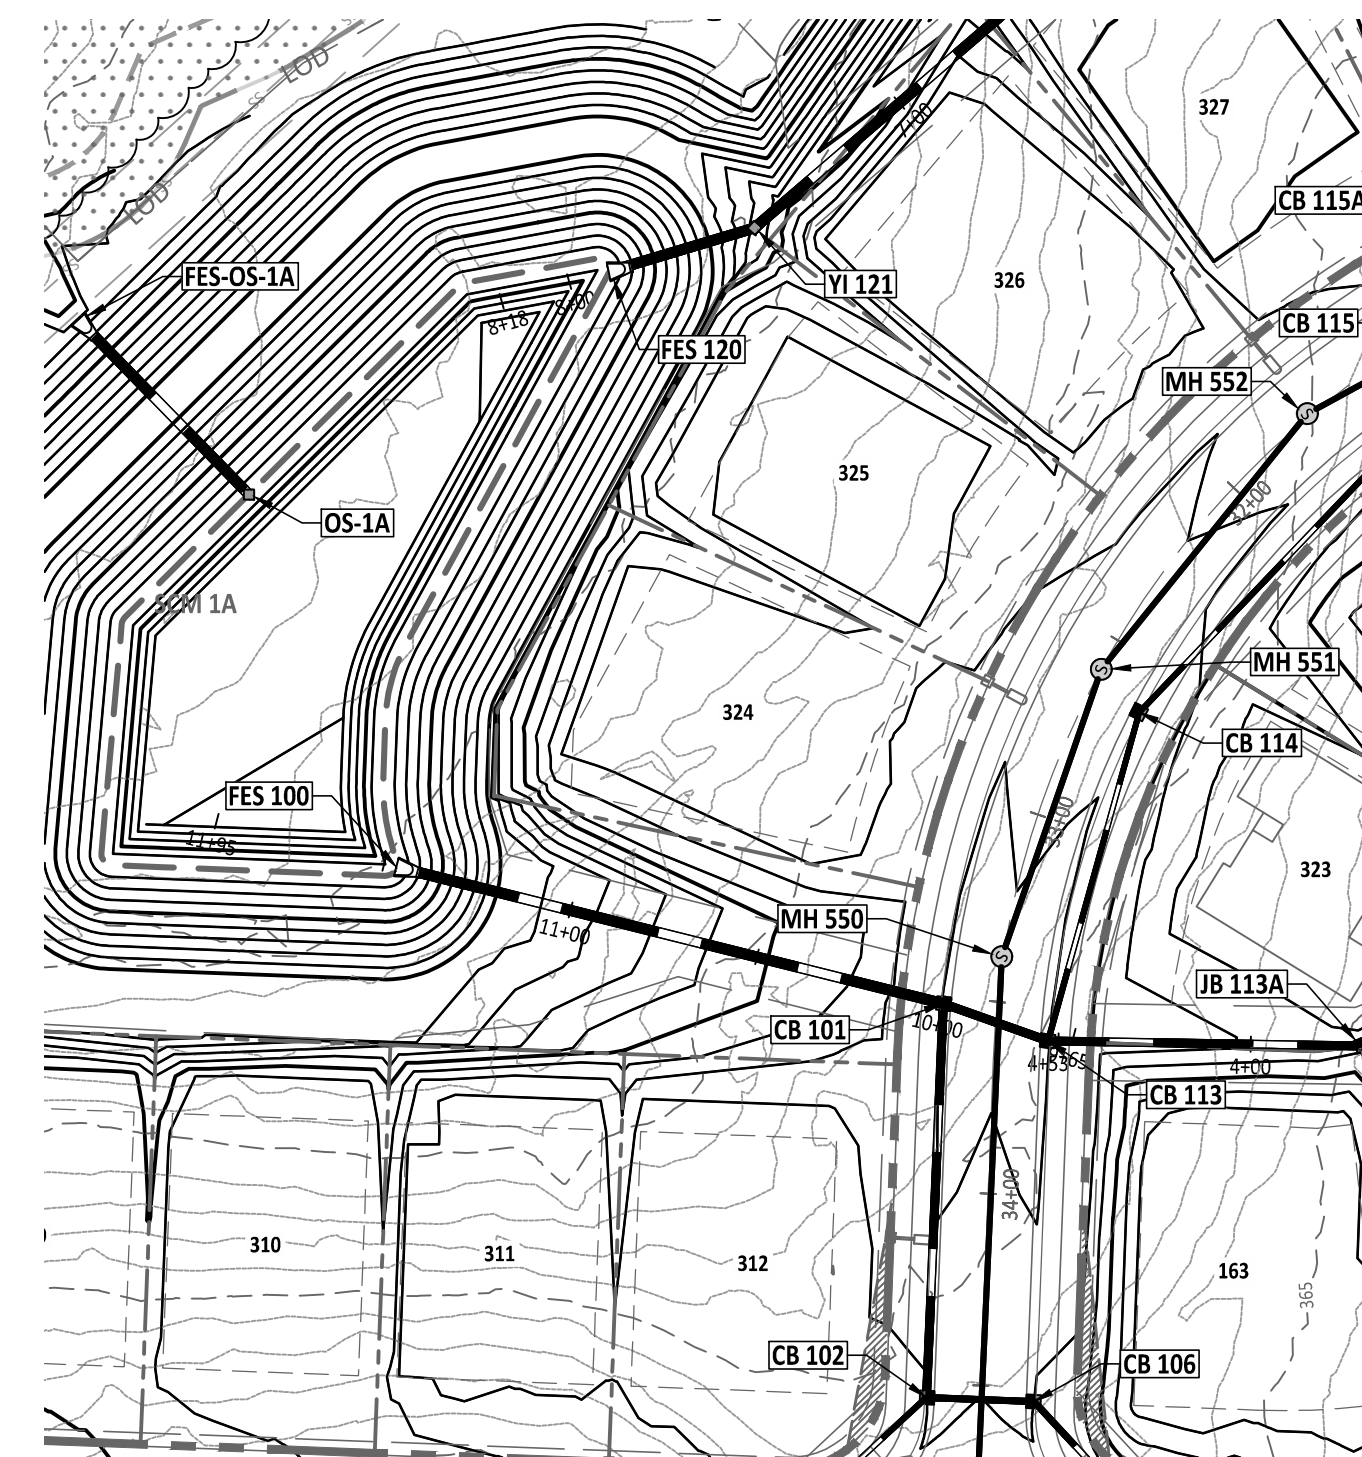[illegible]

STIPULATION FOR REUSE





THIS DRAWING WAS PREPARED FOR USE ON THE SPECIFIC SITE, NAMED HEREON, CONTEMPORANEOUSLY WITH ITS ISSUANCE DATE AS LISTED, HEREON, AND IT IS NOT SUITABLE FOR USE ON A DIFFERENT PROJECT SITE OR AT A LATER TIME. USE OF THIS DRAWING FOR REFERENCE OR EXAMPLE ON ANOTHER PROJECT REQUIRES THE SERVICES OF PROPERLY LICENSED ARCHITECTS AND ENGINEERS. REPRODUCTION OF THIS DRAWING FOR REUSE ON ANOTHER PROJECT IS NOT AUTHORIZED AND MAY BE CONTRARY TO THE LAW.

MERRITT RESERVE
STORM OUTFALL PLAN & PROFILE
ROLESVILLE RD
WAKE COUNTY NC 27312

JOB NUMBER:	23-000
CHECKED BY:	B
DRAWN BY:	DH/RC/SM/GE/MA/LL/J
DATE:	05/01/202


STORM OUFALL PLAN & PROFILE

SHEET NO.: **CU-300**

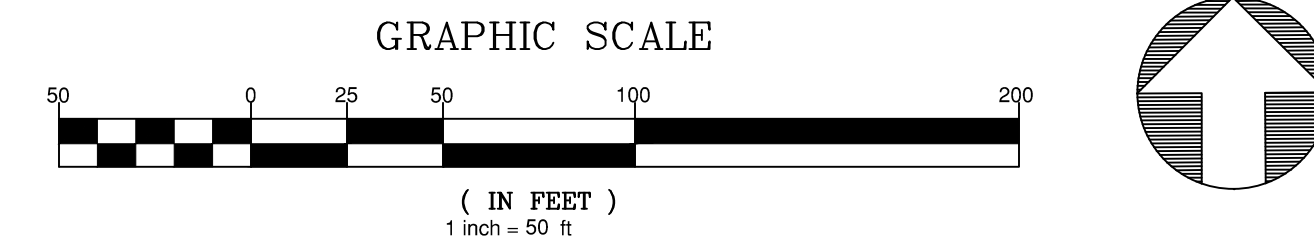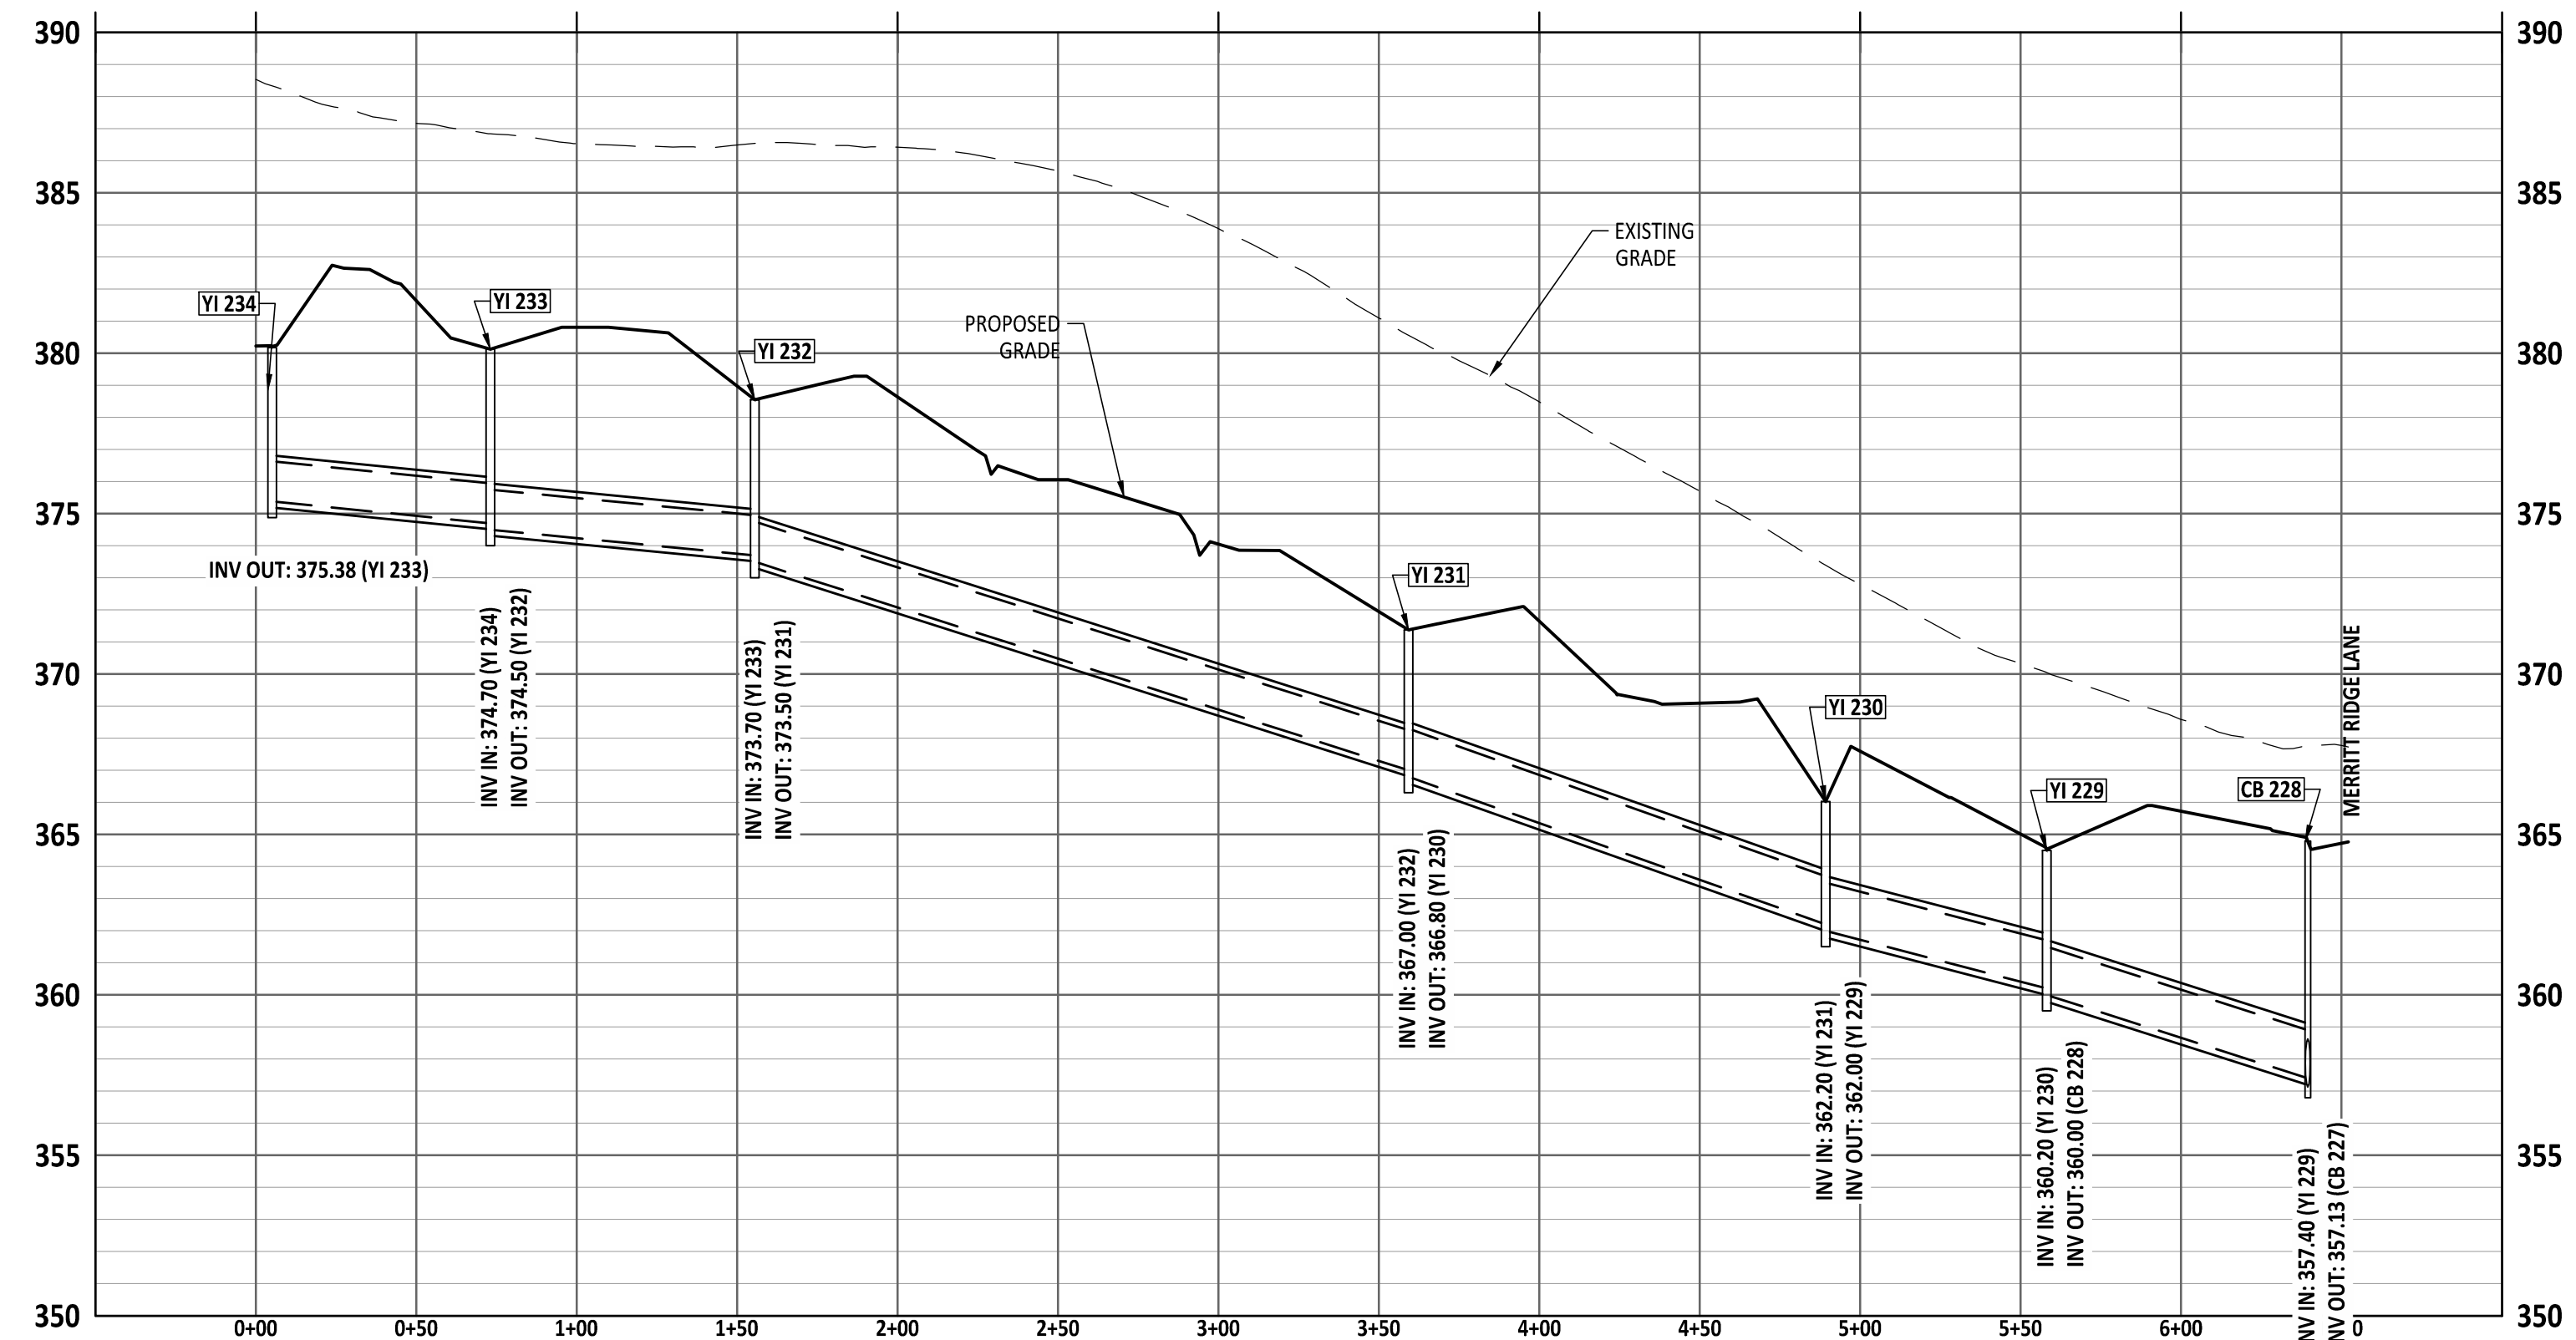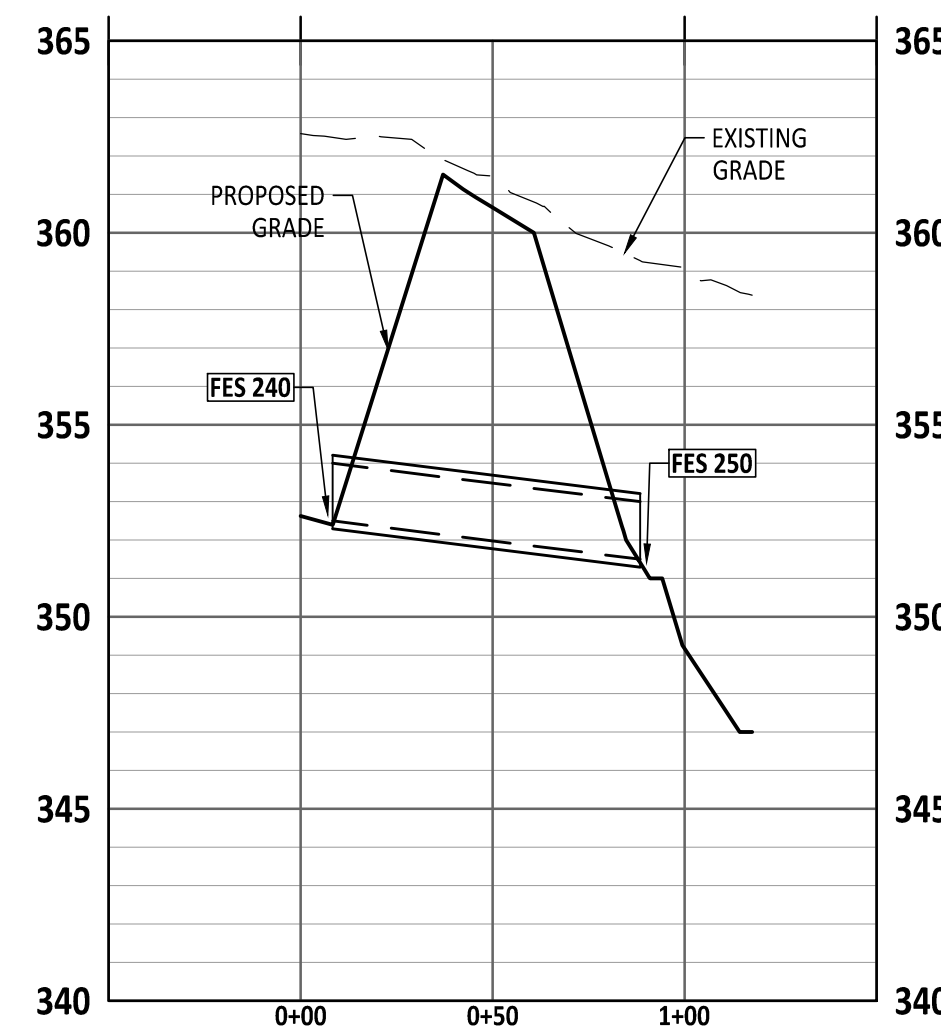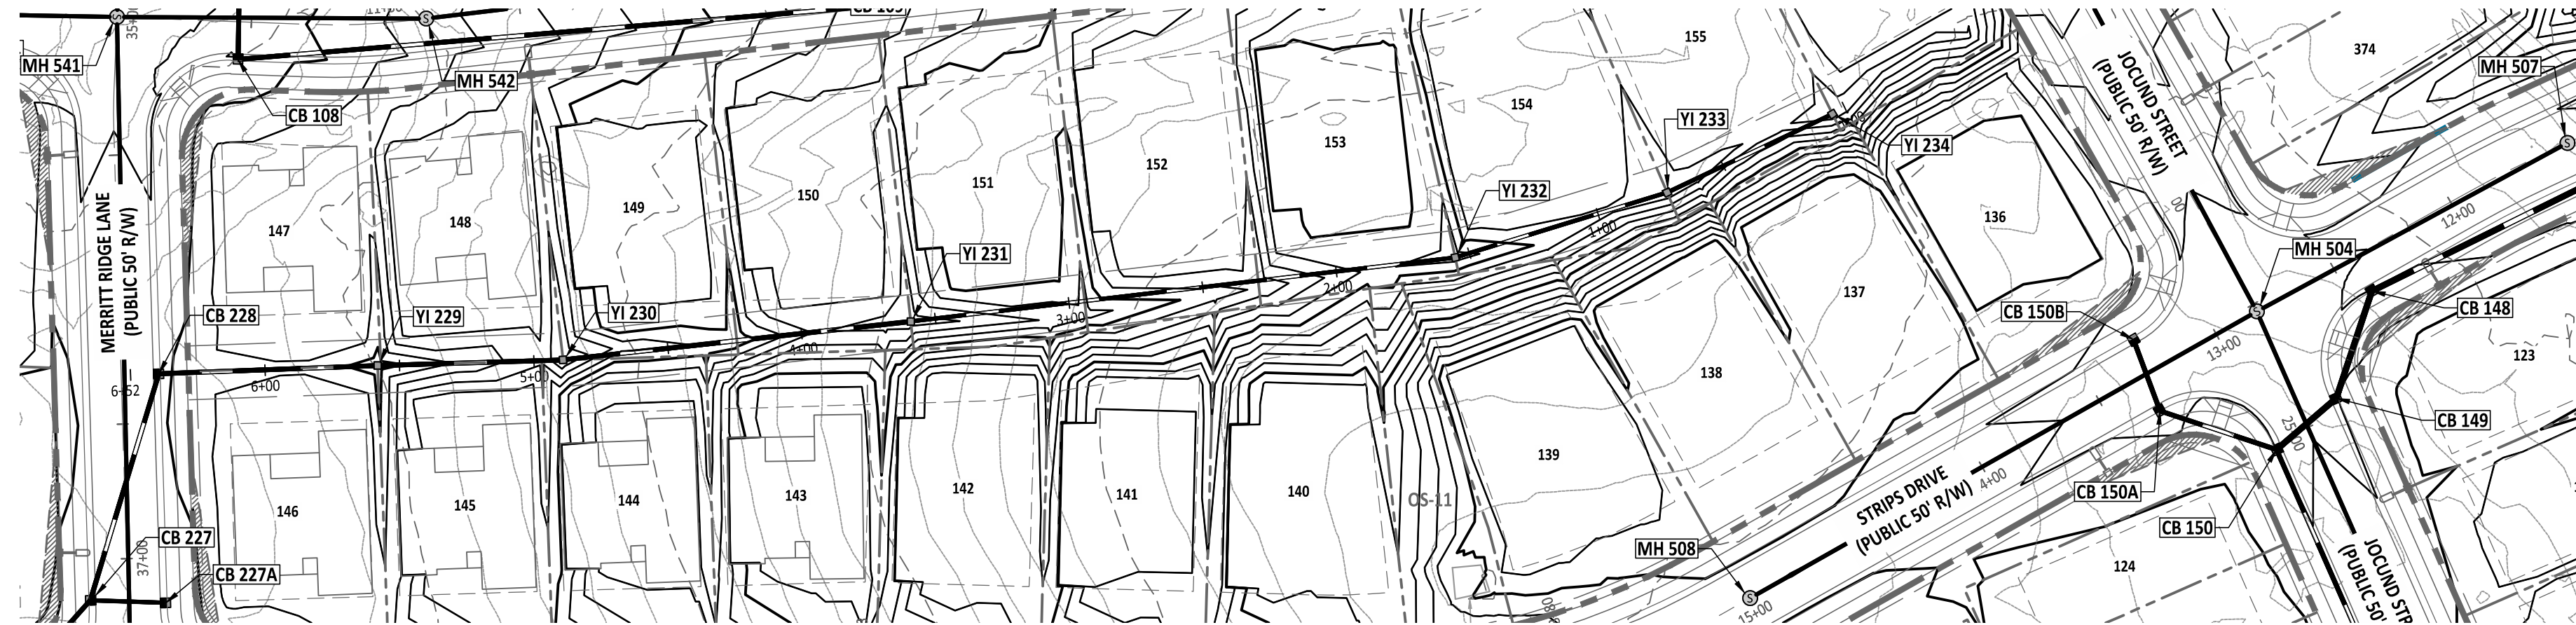The logo for American Engineering Associates features a stylized graphic of three horizontal, slightly curved lines in shades of gray and black, resembling a flame or a stylized 'A'.

AMERICAN
Engineering

American Engineering Associates - Southeast, P.A.
4020 Westchase Boulevard, Suite 450
Raleigh, NC 27607 919-469-1101

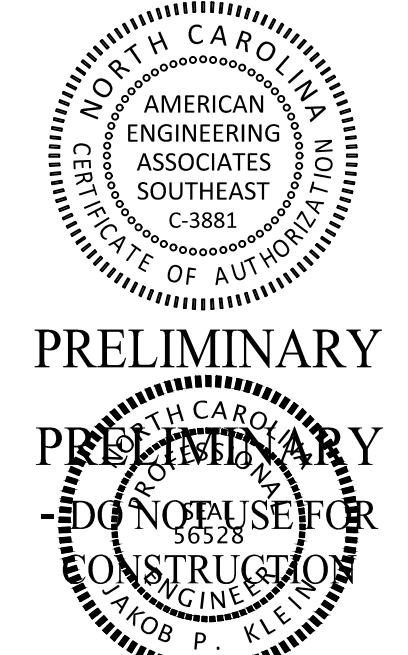

PRELIMINARY
 PRELIMINARY
 -DO NOT USE FOR
 CONSTRUCTION
 FOR INFORMATION, ONLY

[illegible]

STIPULATION FOR REUSE

THIS DRAWING WAS PREPARED FOR USE ON THE SPECIFIC SITE, NAMED HEREON, CONTEMPORANEOUSLY WITH ITS ISSUE DATE AS LISTED, HEREON, AND IT IS NOT SUITABLE FOR USE ON A DIFFERENT PROJECT SITE OR AT A LATER TIME. USE OF THIS DRAWING FOR REFERENCE OR EXAMPLE ON ANOTHER PROJECT REQUIRES THE SERVICES OF PROPERLY LICENSED ARCHITECTS AND ENGINEERS. REPRODUCTION OF THIS DRAWING FOR REUSE ON ANOTHER PROJECT IS NOT AUTHORIZED AND MAY BE CONTRARY TO THE LAW.

**MERRITT RESERVE
STORM OUTFALL PLAN & PROFILE
ROLESVILLE RD
WAKE COUNTY NC 27312**







JOB NUMBER:	23-0004
CHECKED BY:	BH
DRAWN BY:	DH/RC/SM/GE/MA/LL/JB
DATE:	05/01/2025

STORM OUFALL PLAN & PROFILE

SHEET NO.: **CU-303**

North Carolina 811
www.nc.811.org
*** 3 Days Before Digging ***
North Carolina 811
811 or 1-800-632-4949
Remote Ticket Entry
<http://nc811.org/remoteticketentry.htm>

PROJECT NUMBER = PSP-24-07

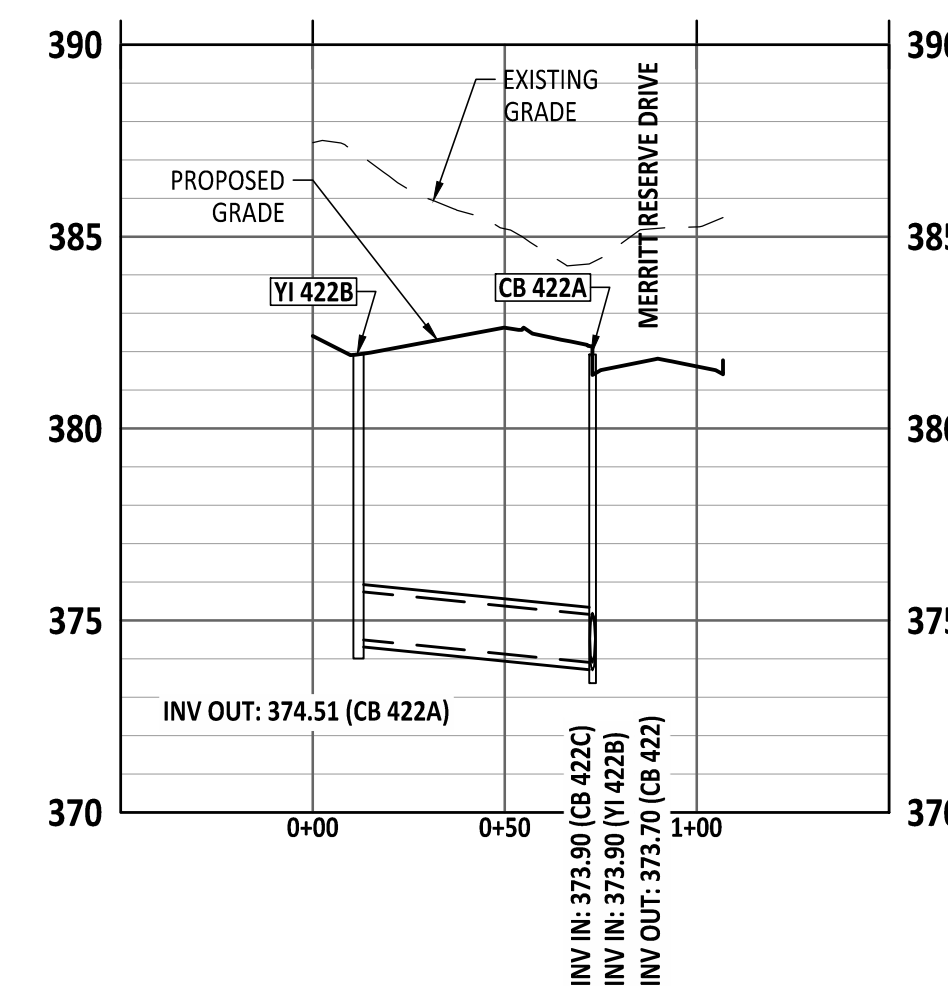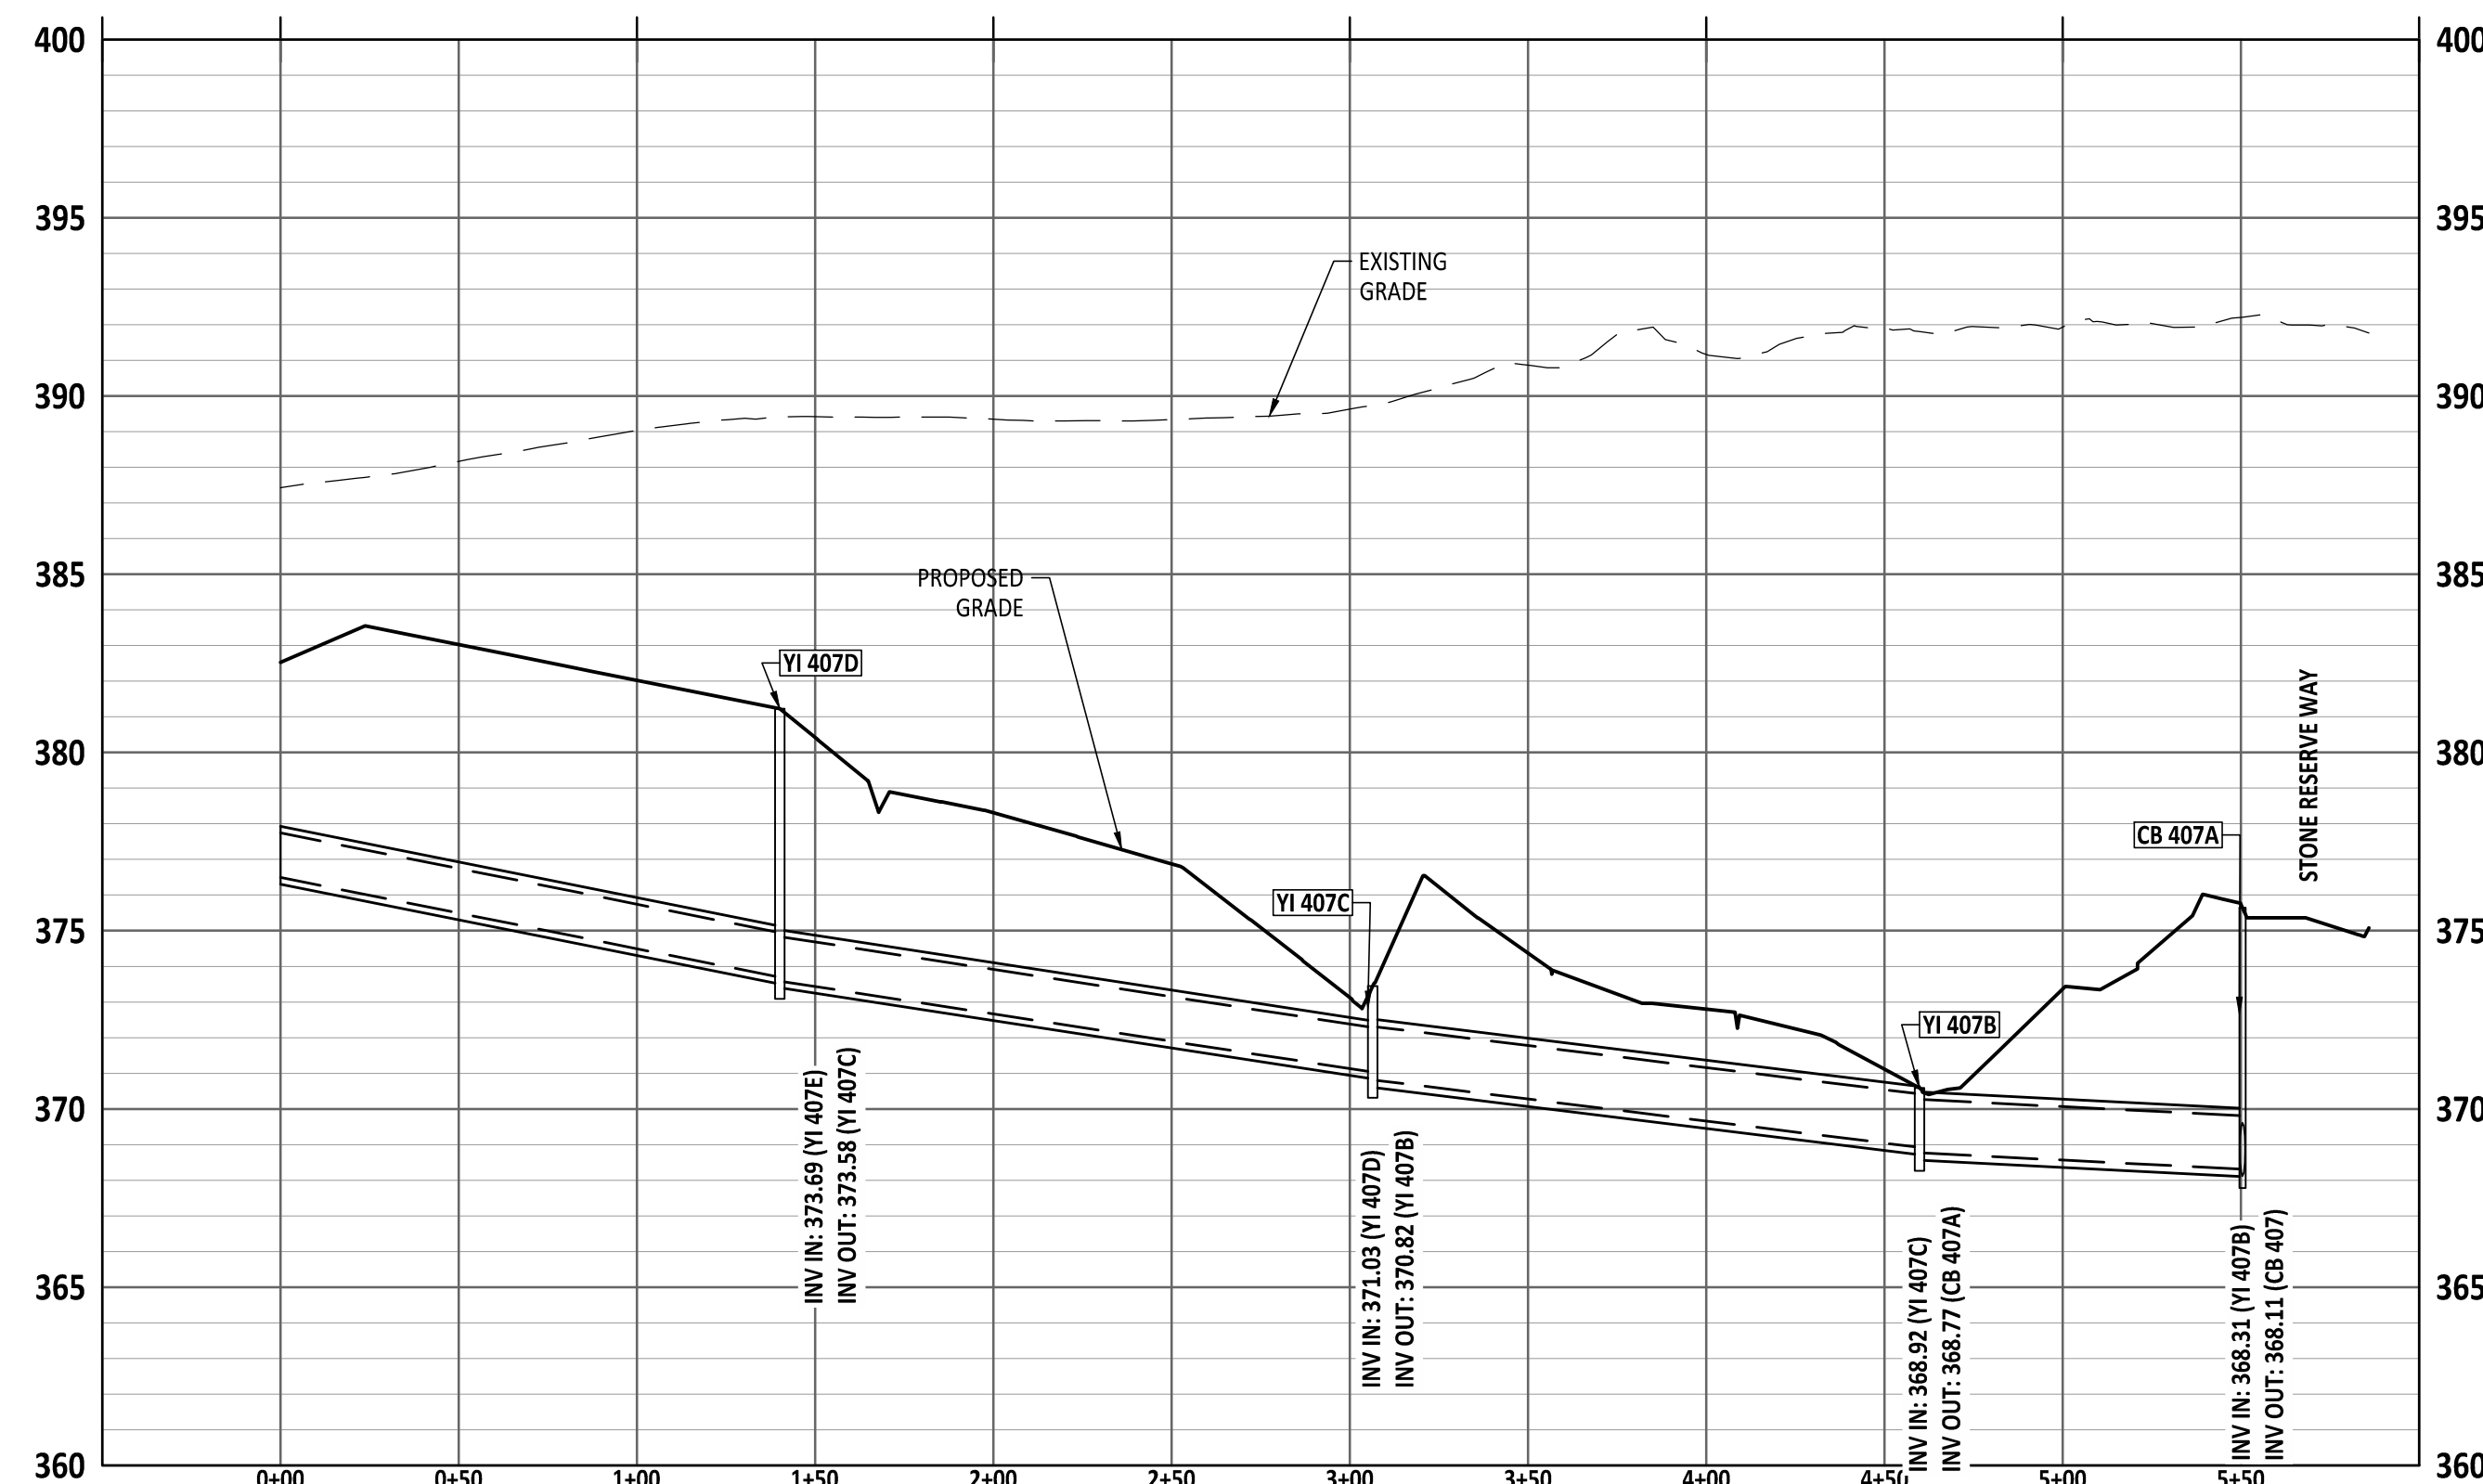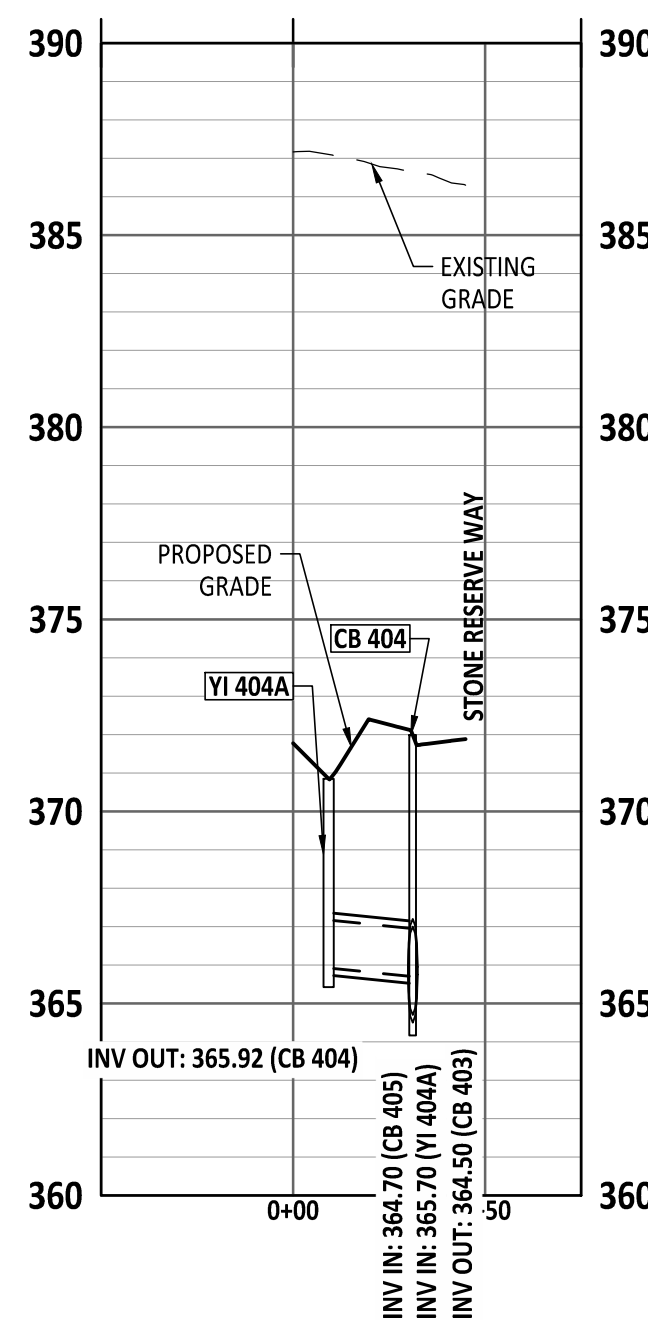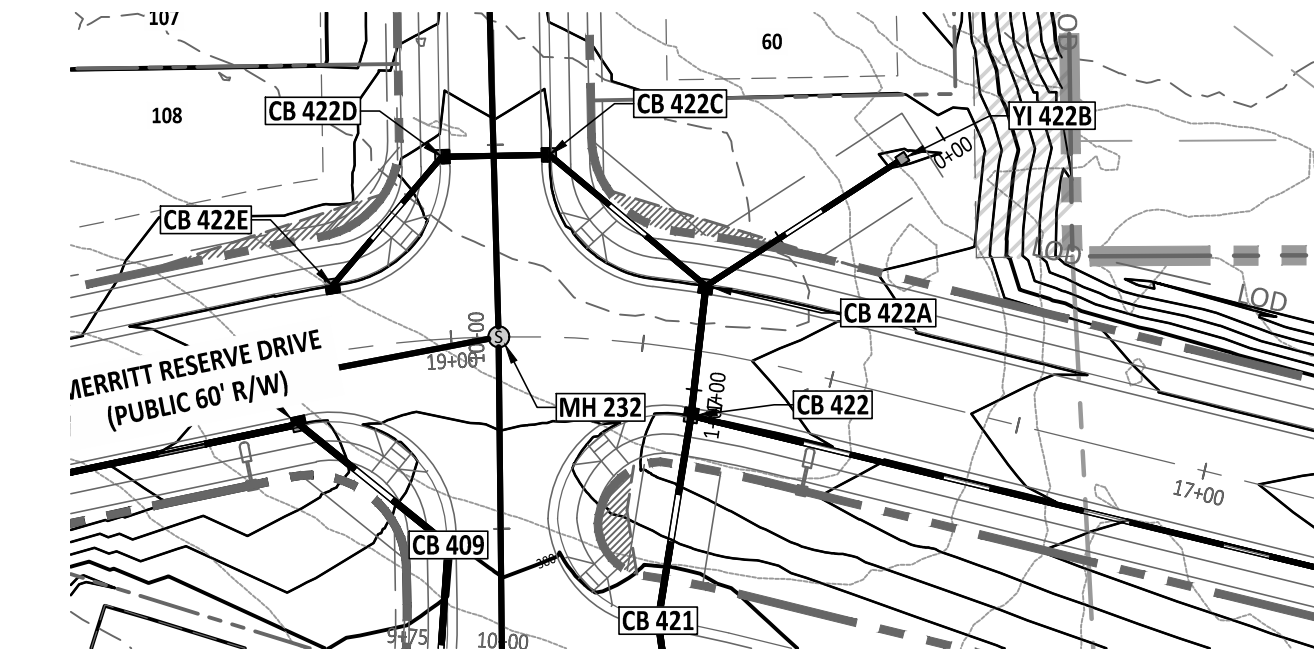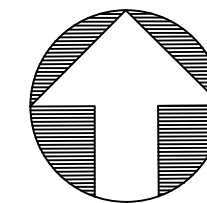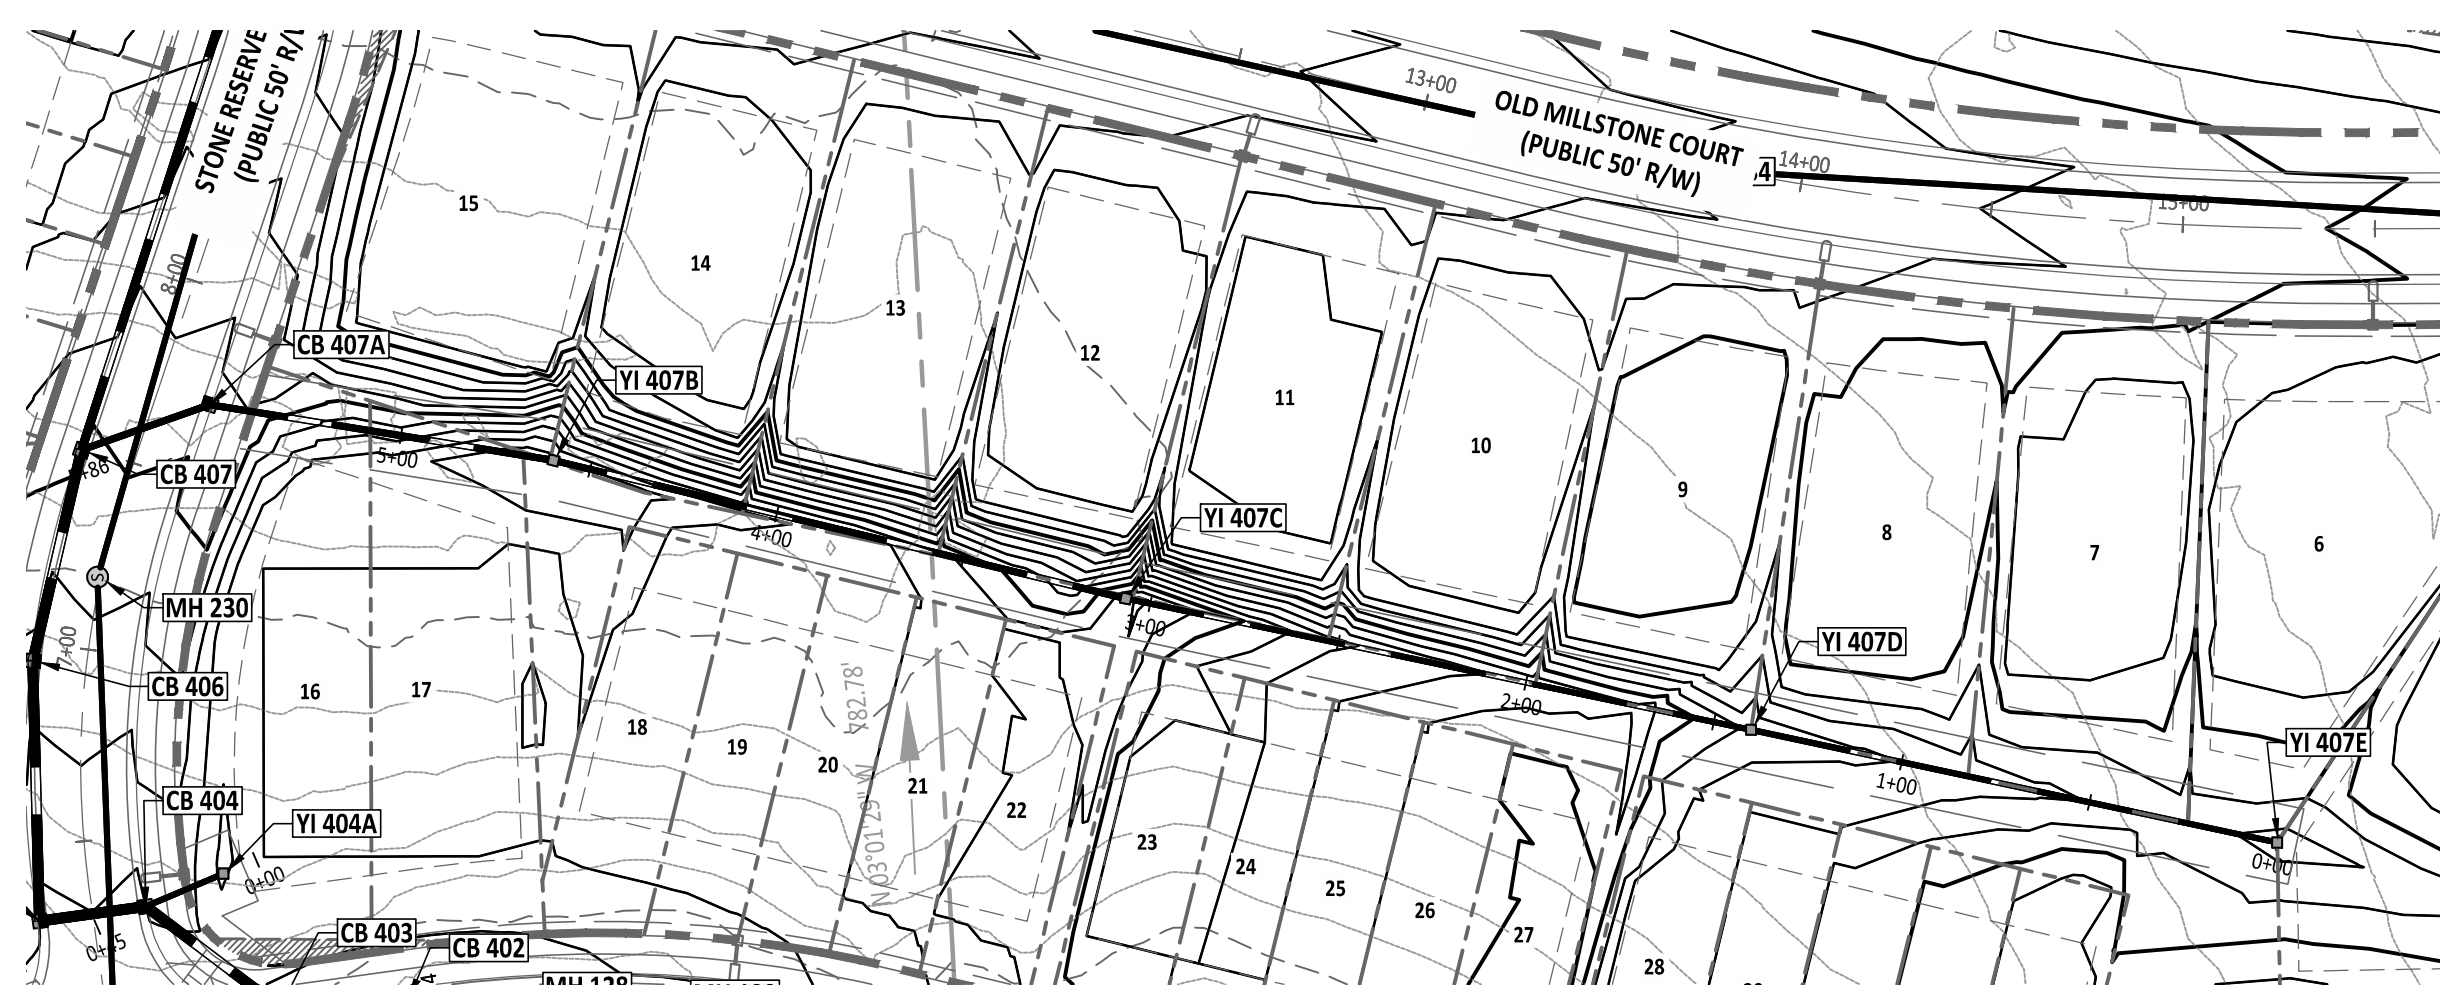

North Carolina 811
www.nc811.org
*** 3 Days Before Digging ***
North Carolina 811
811 or 1-800-632-4949
Remote Ticket Entry
<http://nc811.org/remoteticketentry.htm>

NORTH CAROLINA
 AMERICAN
 ENGINEERING
 ASSOCIATES
 SOUTHEAST
 C-3881
 CERTIFICATE OF AUTHORIZATION

PRELIMINARY
 NORTH CAROLINA
 ENGINEERING BOARD
 DO NOT USE FOR
 CONSTRUCTION
 JACOB P. KLEIN

FOR INFORMATION, ONLY

[illegible]




STIPULATION FOR REUSE
THIS DRAWING WAS PREPARED FOR USE ON THE SPECIFIC SITE, NAMED HEREON, CONTEMPORANEOUSLY WITH ITS ISSUE DATE AS LISTED, HEREON, AND IT IS NOT SUITABLE FOR USE ON A DIFFERENT PROJECT SITE OR AT A LATER TIME. USE OF THIS DRAWING FOR REFERENCE OR EXAMPLE ON ANOTHER PROJECT REQUIRES THE SERVICES OF PROPERLY LICENSED ARCHITECTS AND ENGINEERS. REPRODUCTION OF THIS DRAWING FOR REUSE ON ANOTHER PROJECT IS NOT AUTHORIZED AND MAY BE CONTRARY TO THE LAW.

MERRITT RESERVE
STORM OUTFALL PLAN & PROFILE
ROLESVILLE RD
WAKE COUNTY NC 27312

JOB NUMBER:	23-000
CHECKED BY:	BR
DRAWN BY:	DH/RC/SM/GE/MA/LL/JL
DATE:	05/01/2023

STORM OUFALL PLAN & PROFILE

SHEET NO.: **CU-304**

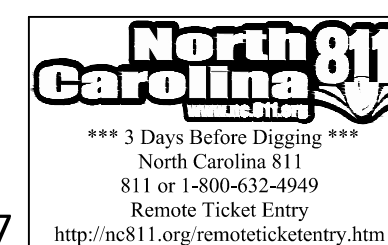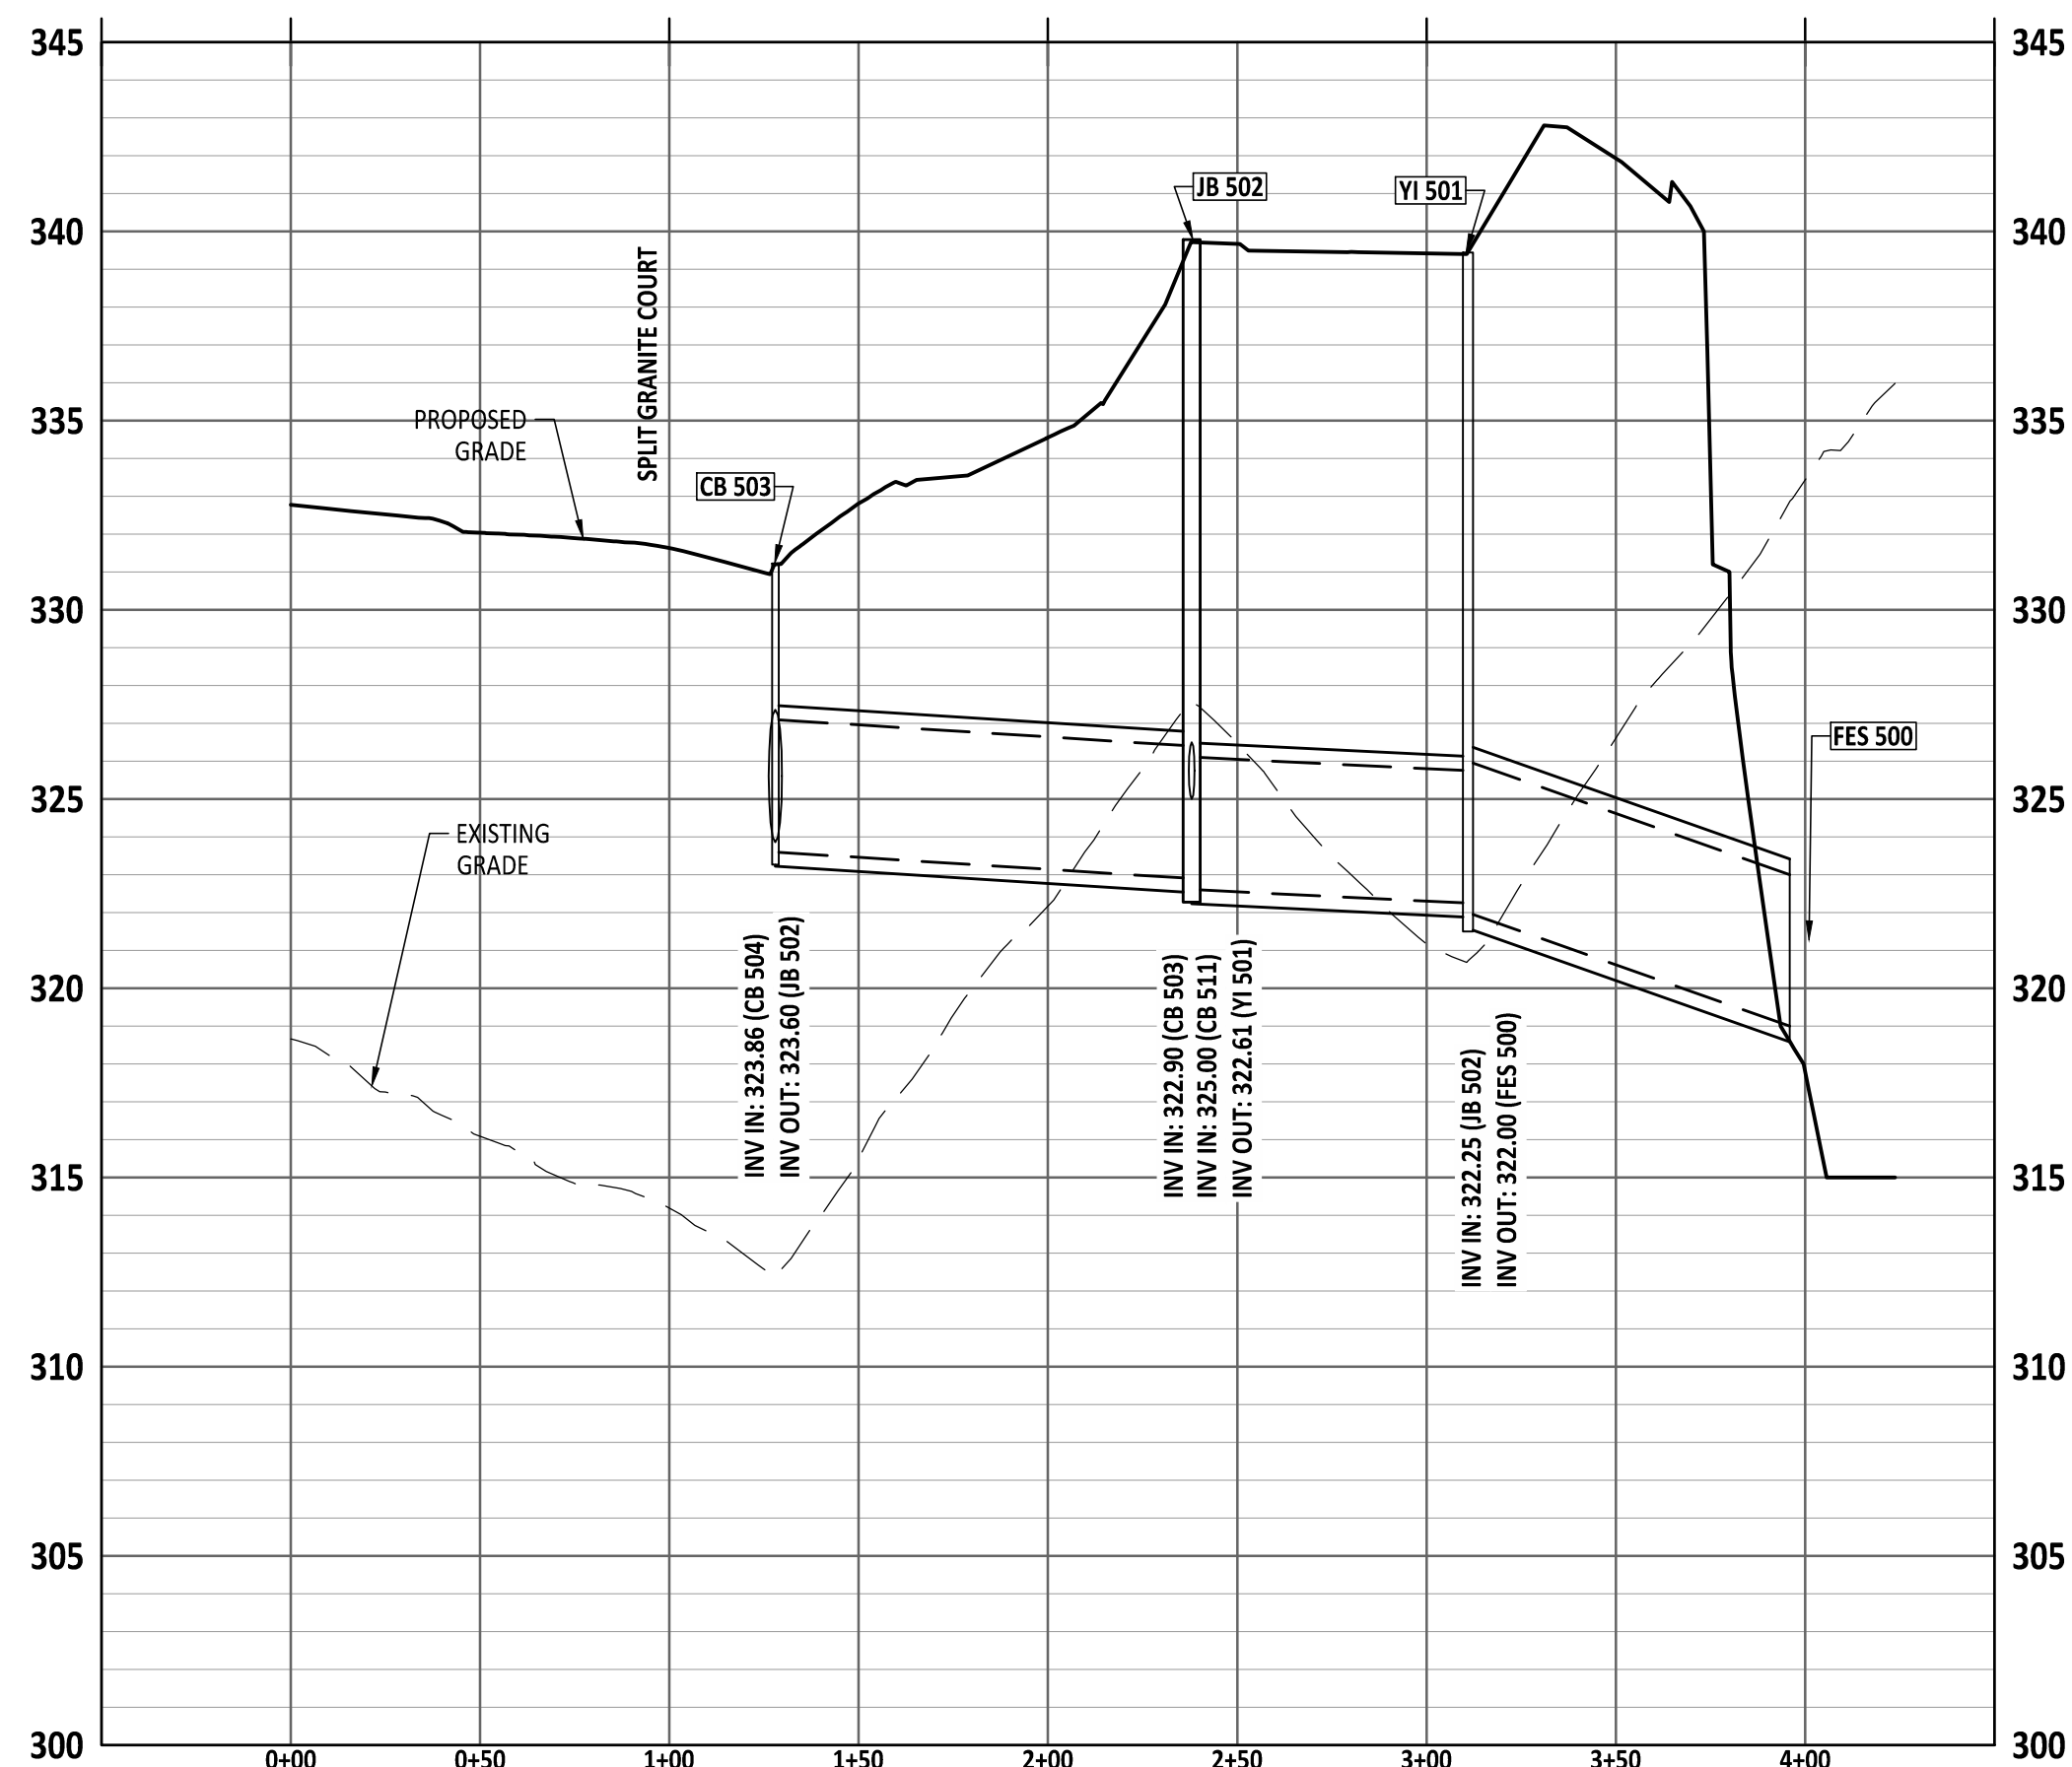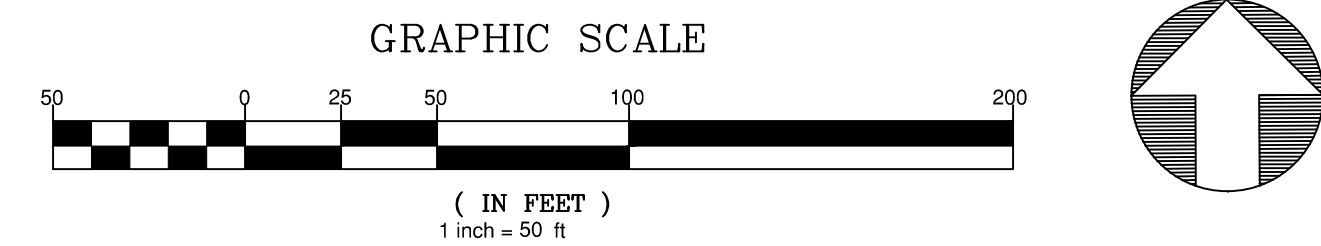

PROJECT NUMBER = PSP-24-07



AMERICAN
Engineering

American Engineering Associates - Southeast, P.A.
4020 Westchase Boulevard, Suite 450
Raleigh, NC 27607
919-469-1101



PRELIMINARY



FOR INFORMATION, ONLY

[illegible]

STIPULATION FOR REUSE

THIS DRAWING WAS PREPARED FOR USE ON THE SPECIFIC SITE, NAMED HEREON, CONTEMPORANEOUSLY WITH ITS ISSUE DATE AS LISTED, HEREON, AND IT IS NOT SUITABLE FOR USE ON A DIFFERENT PROJECT SITE OR AT A LATER TIME. USE OF THIS DRAWING FOR REFERENCE OR EXAMPLE ON ANOTHER PROJECT REQUIRES THE SERVICES OF PROPERLY LICENSED ARCHITECTS AND ENGINEERS. REPRODUCTION OF THIS DRAWING FOR REUSE ON ANOTHER PROJECT IS NOT AUTHORIZED AND MAY BE CONTRARY TO THE LAW.

MERRITT RESERVE
STORM OUTFALL PLAN & PROFILE
ROLESVILLE RD
WAKE COUNTY NC 27312

JOB NUMBER: 23-0004

CHECKED BY: _____

DRAWN BY: DH/RC/SM/GE/MA/LL/JL

DATE: 05/01/2021

SHEET TITLE:

 





**STORM
OUFALL PLAN
& PROFILE**

SHEET NO.: _____

CU-305


Z:\Jobs\123-0004 Merritt Property ARD.dwg Working Drawn\Sheets\Construction Set\CI-300-309 PLAN & PROFILE.dwg

2025-05-0

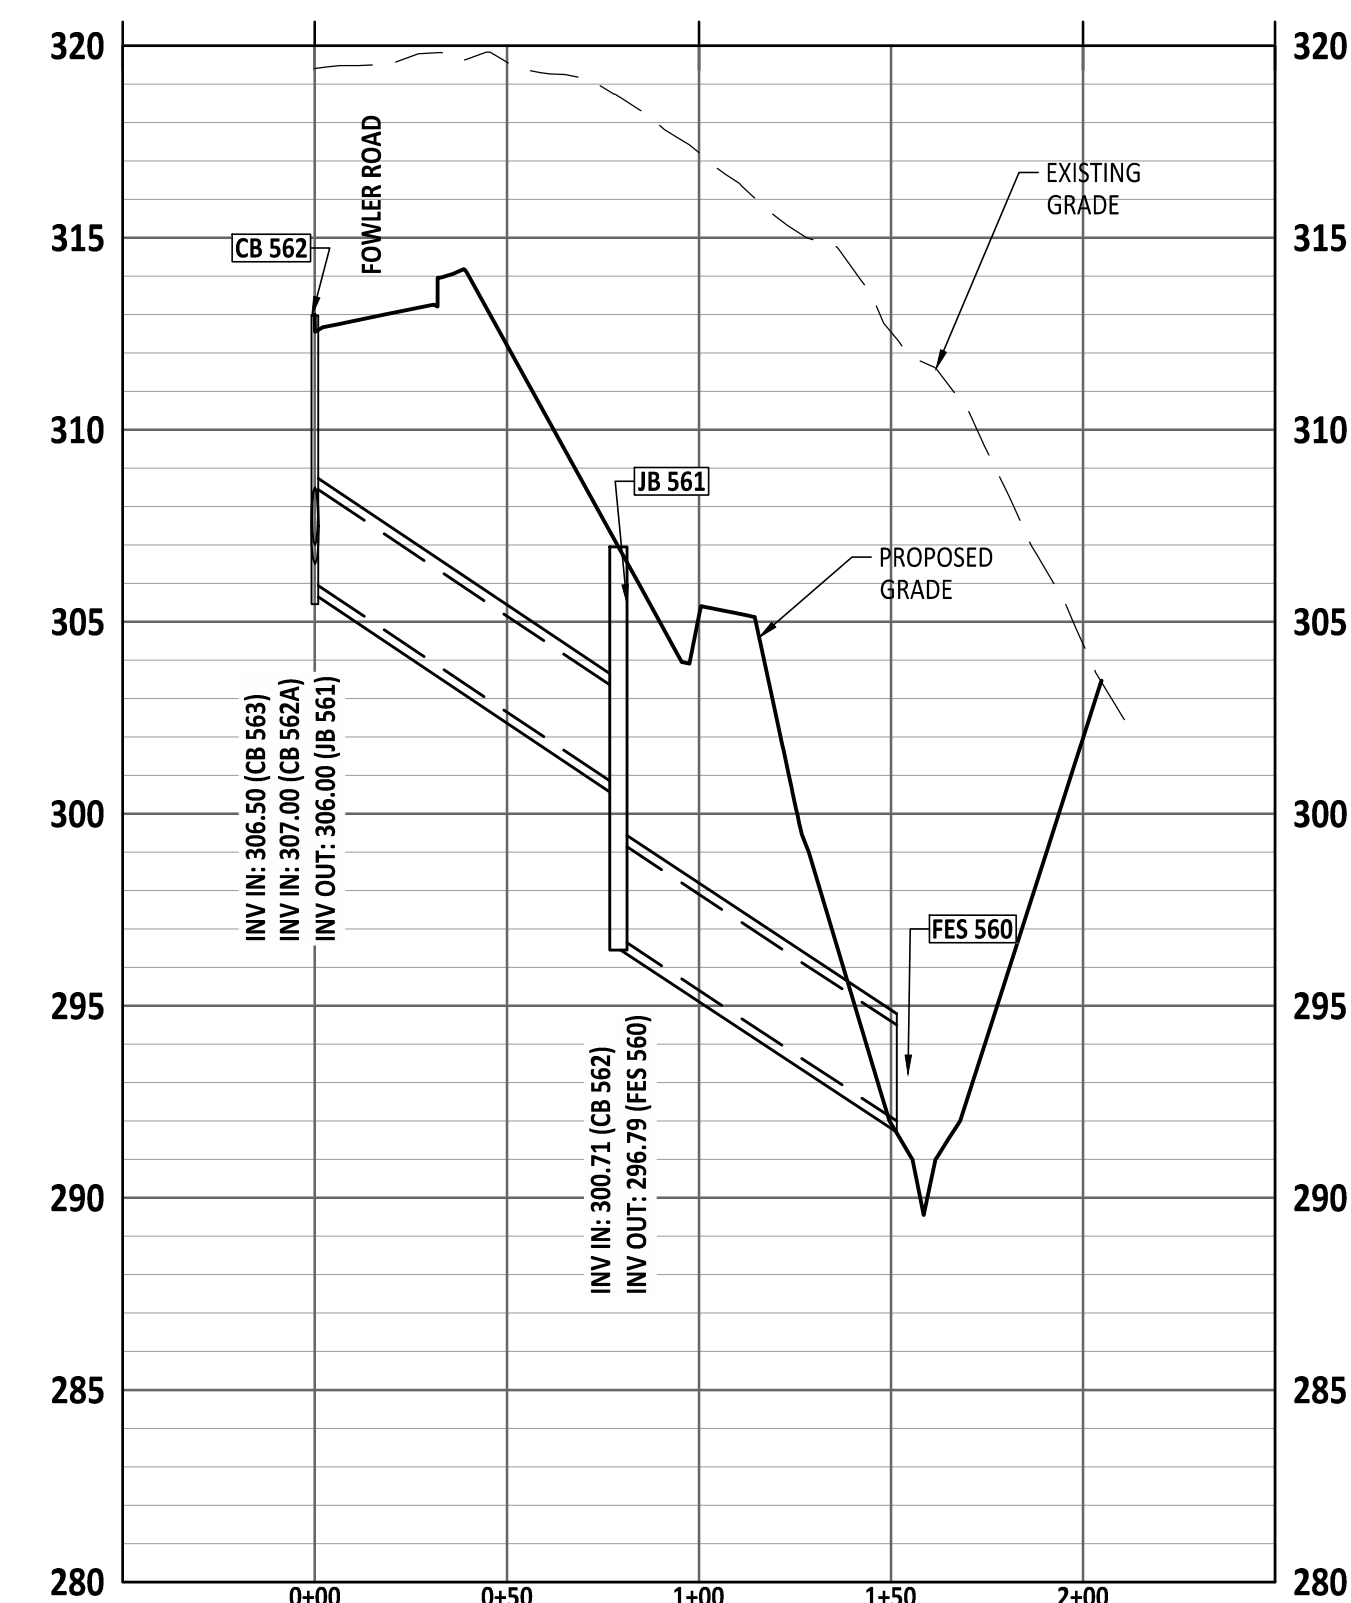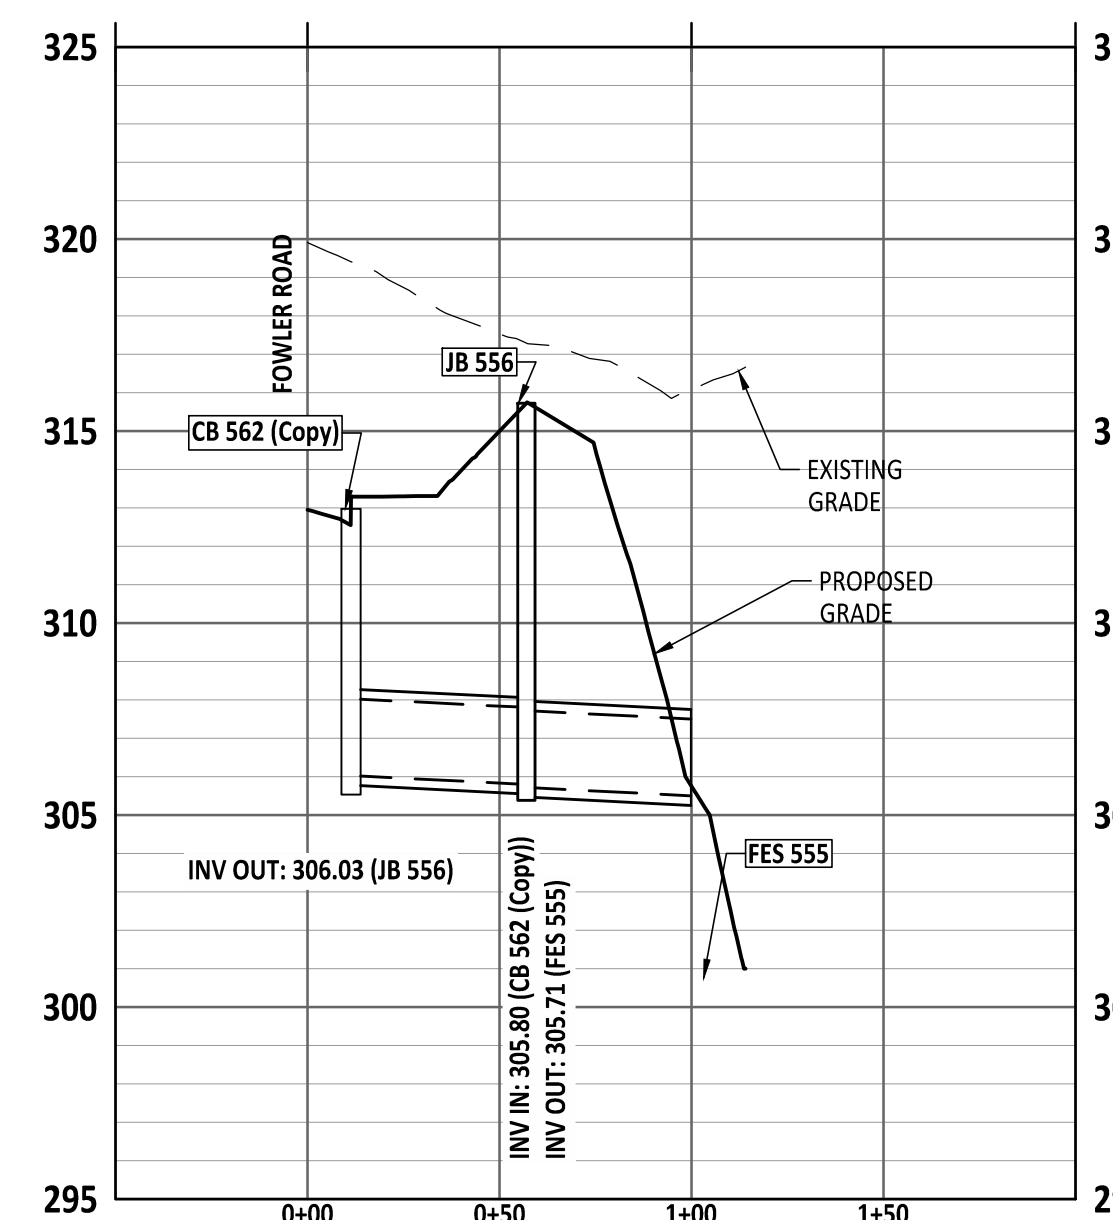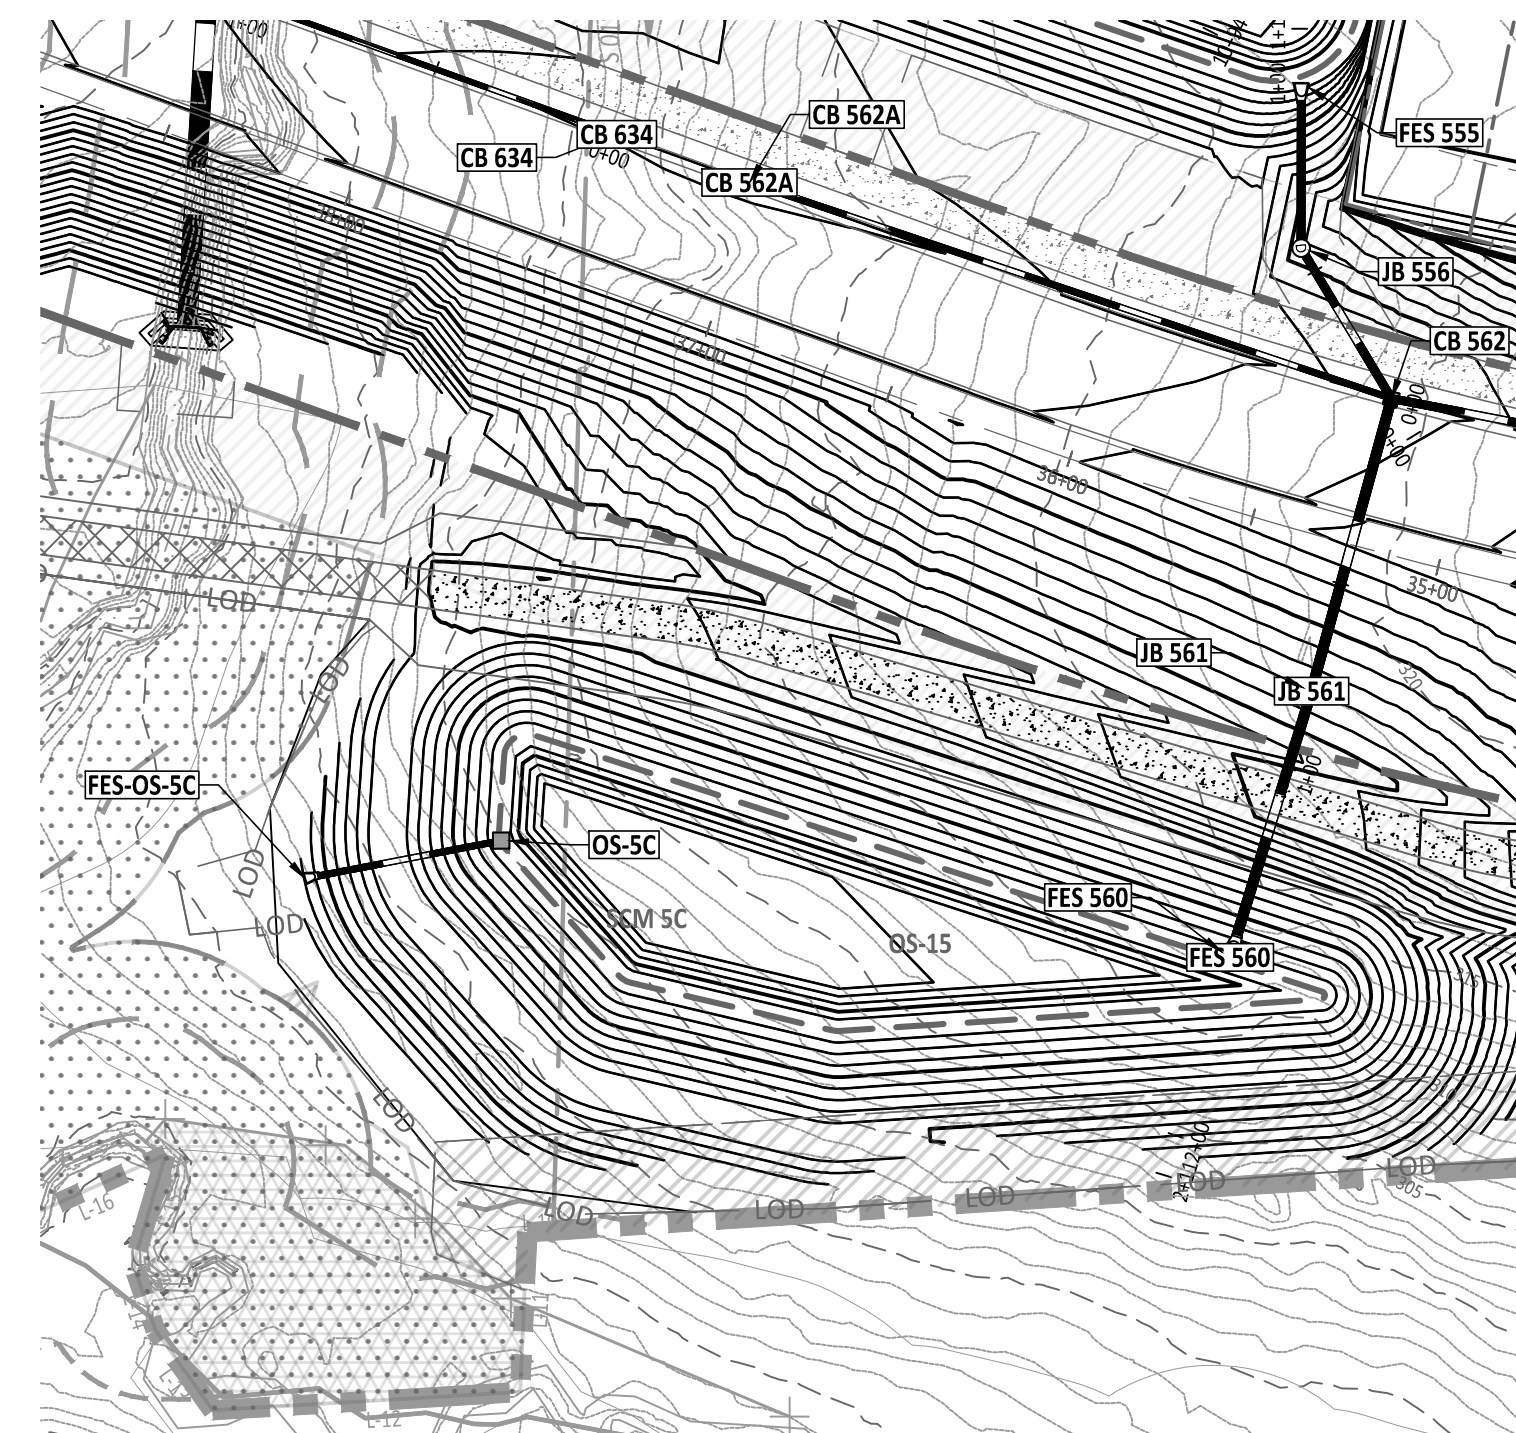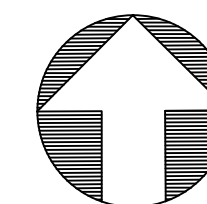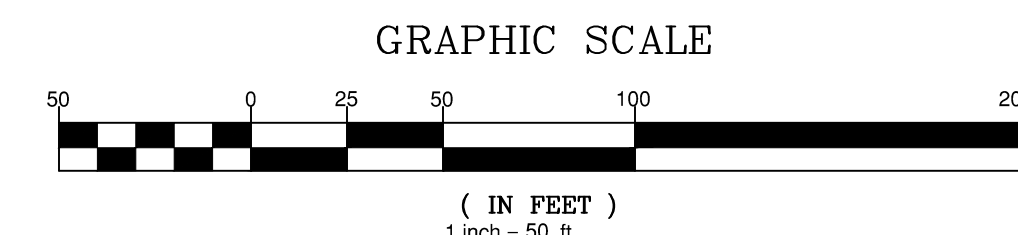

AMERICAN
Engineering

American Engineering Associates - Southeast, P.A.
4020 Westchase Boulevard, Suite 450
Raleigh, NC 27607
919-468-1101

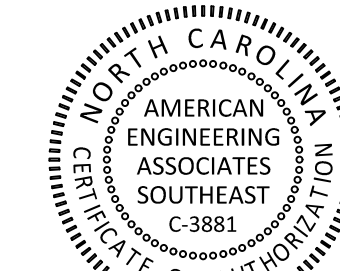

PRELIMINARY

PRELIMINARY

DO NOT USE FOR

FOR INFORMATION, ONLY

[illegible]

STIPULATION FOR REUSE

THIS DRAWING WAS PREPARED FOR USE ON THE SPECIFIC SITE, NAMED HERECIN, CONTEMPORANEOUSLY WITH ITS ISSUANCE DATE AS LISTED, HEREON. AND IT IS NOT SUITABLE FOR USE ON A DIFFERENT PROJECT SITE OR AT A LATER TIME. USE OF THIS DRAWING FOR REFERENCE OR EXAMINATION ON ANOTHER PROJECT REQUIRES THE SERVICES OF PROPERLY LICENSED ARCHITECTS AND ENGINEERS. REPRODUCTION OF THIS DRAWING FOR REUSE ON ANOTHER PROJECT IS NOT AUTHORIZED AND MAY BE CONTRARY TO THE LAW.

MERRITT RESERVE
STORM OUTFALL PLAN & PROFILE
ROLESVILLE RD
WAKE COUNTY NC 27312

JOB NUMBER: 23-0

CHECKED BY: _____

DRAWN BY: DH/RC/SM/GE/MA/LL

DATE: 05/01/2018

SHEET TITLE:

STORM OUFALL PLAN & PROFILE

SHEET NO.: _____

CU-30

66 50

North Carolina 811
www.nc811.org




*** 3 Days Before Digging ***

North Carolina 811
811 or 1-800-632-4949

Remote Ticket Entry

<http://nc811.org/remoteticketentry.htm>

PROJECT NUMBER = PSP-24-07

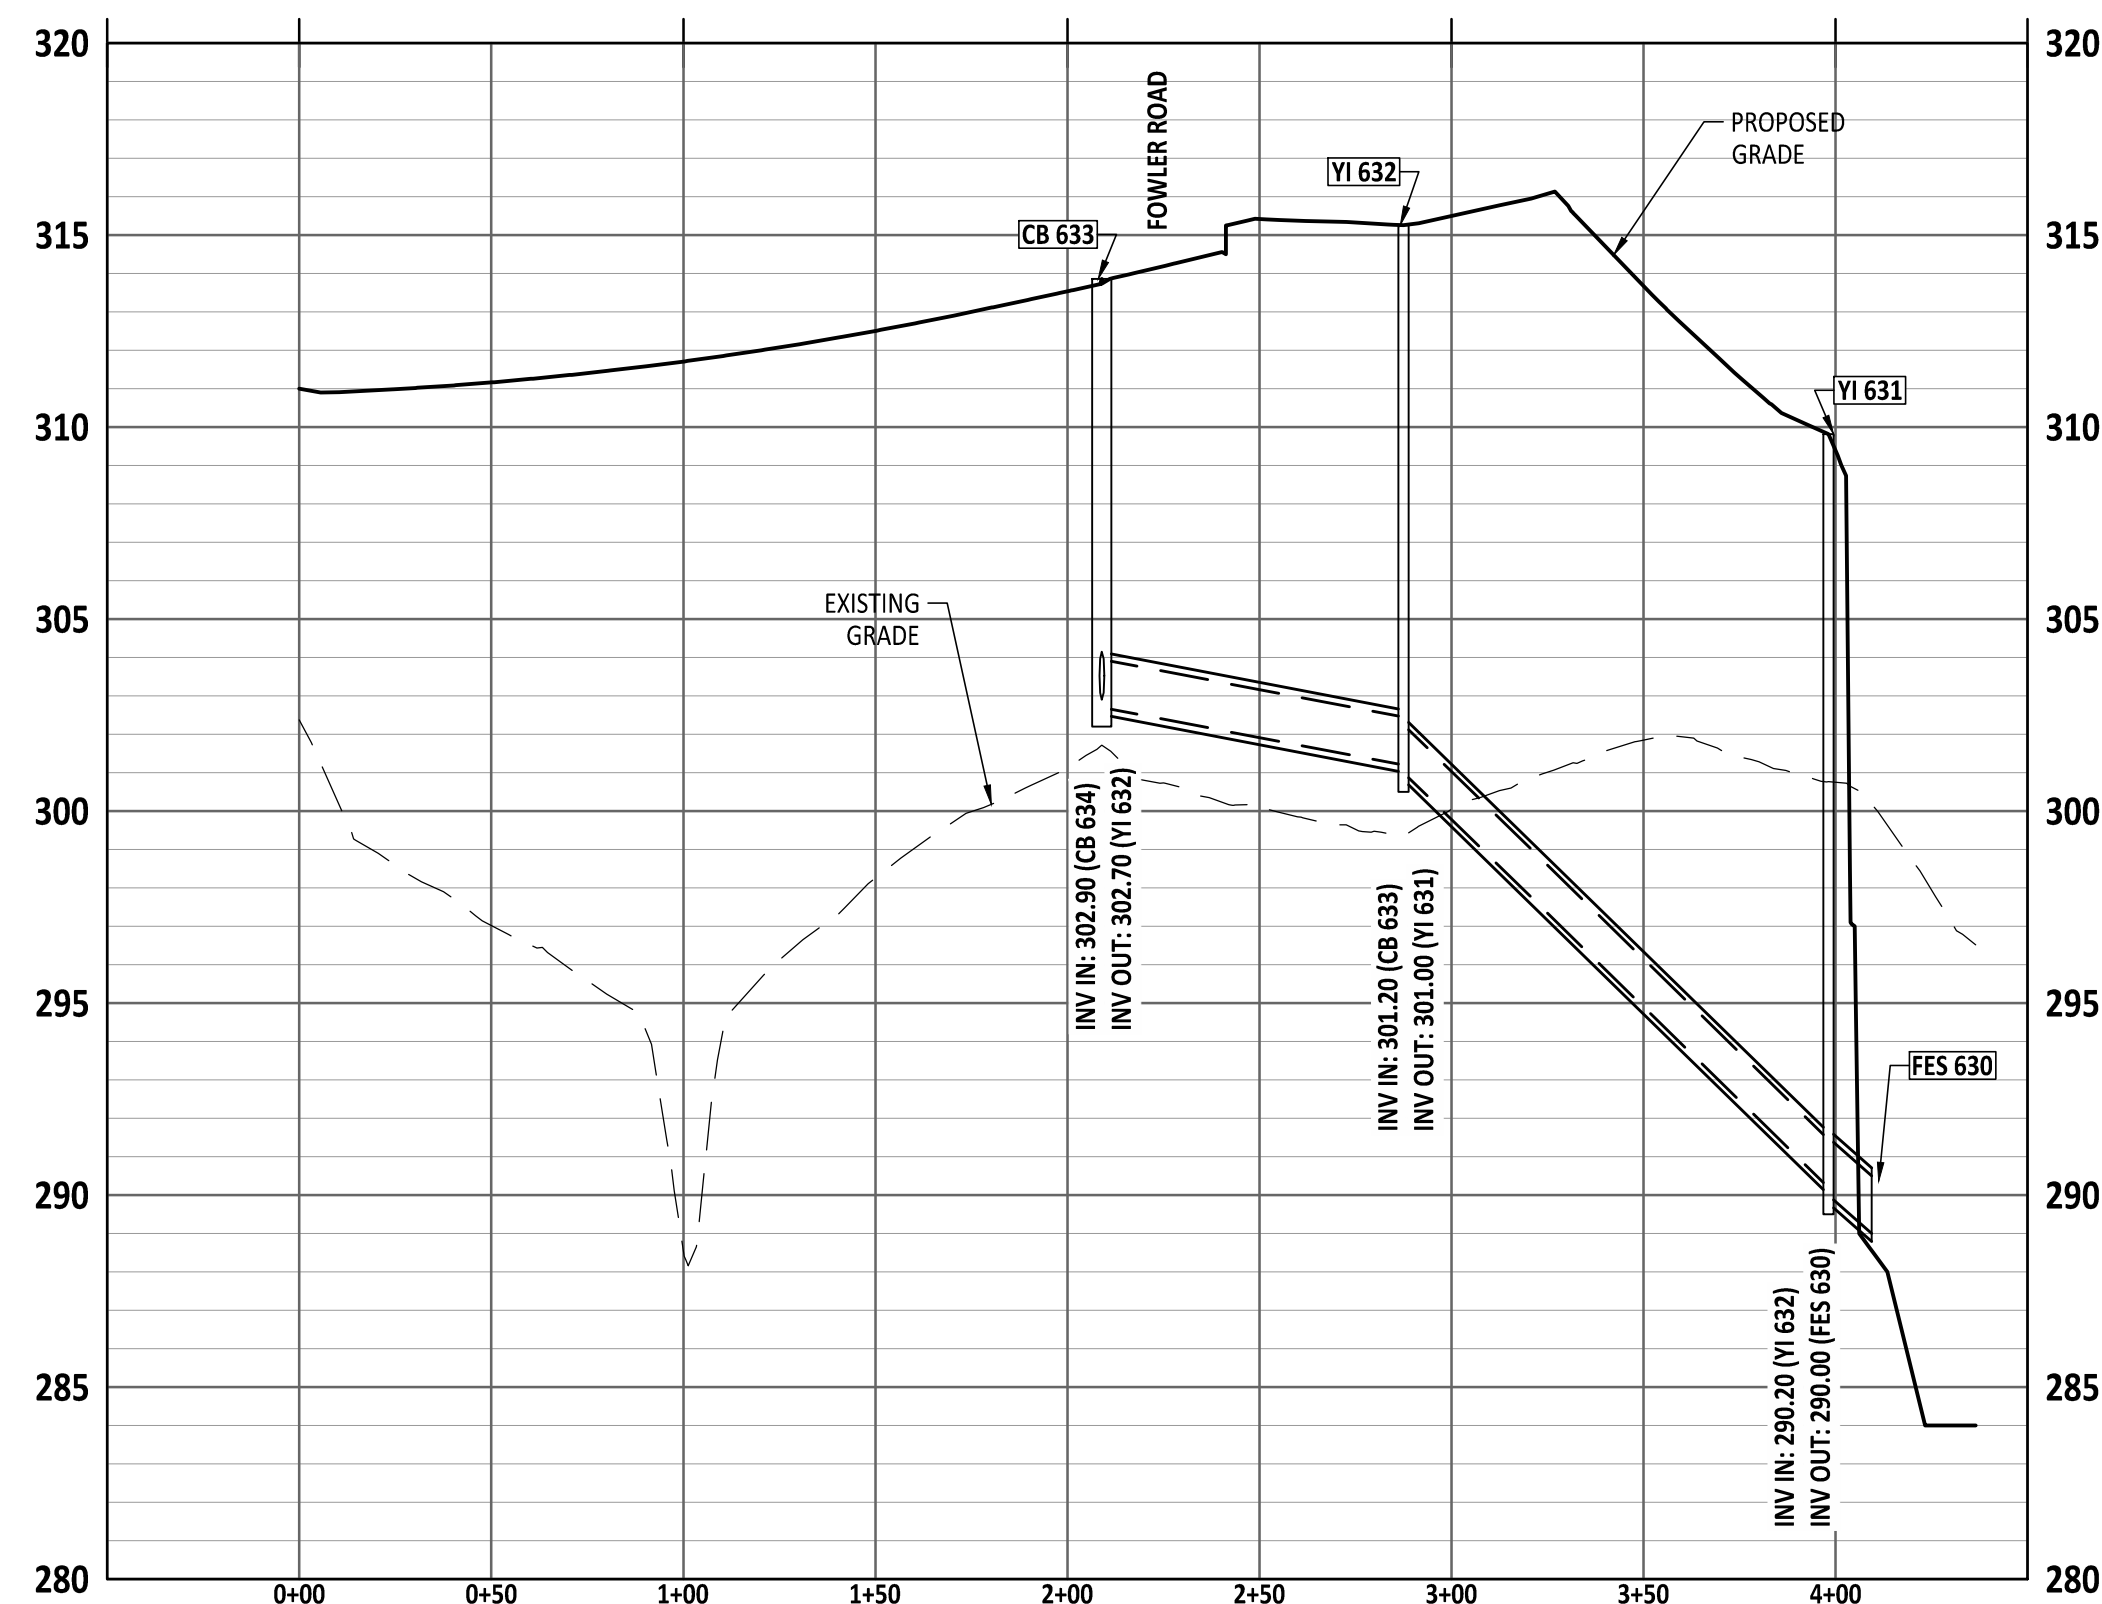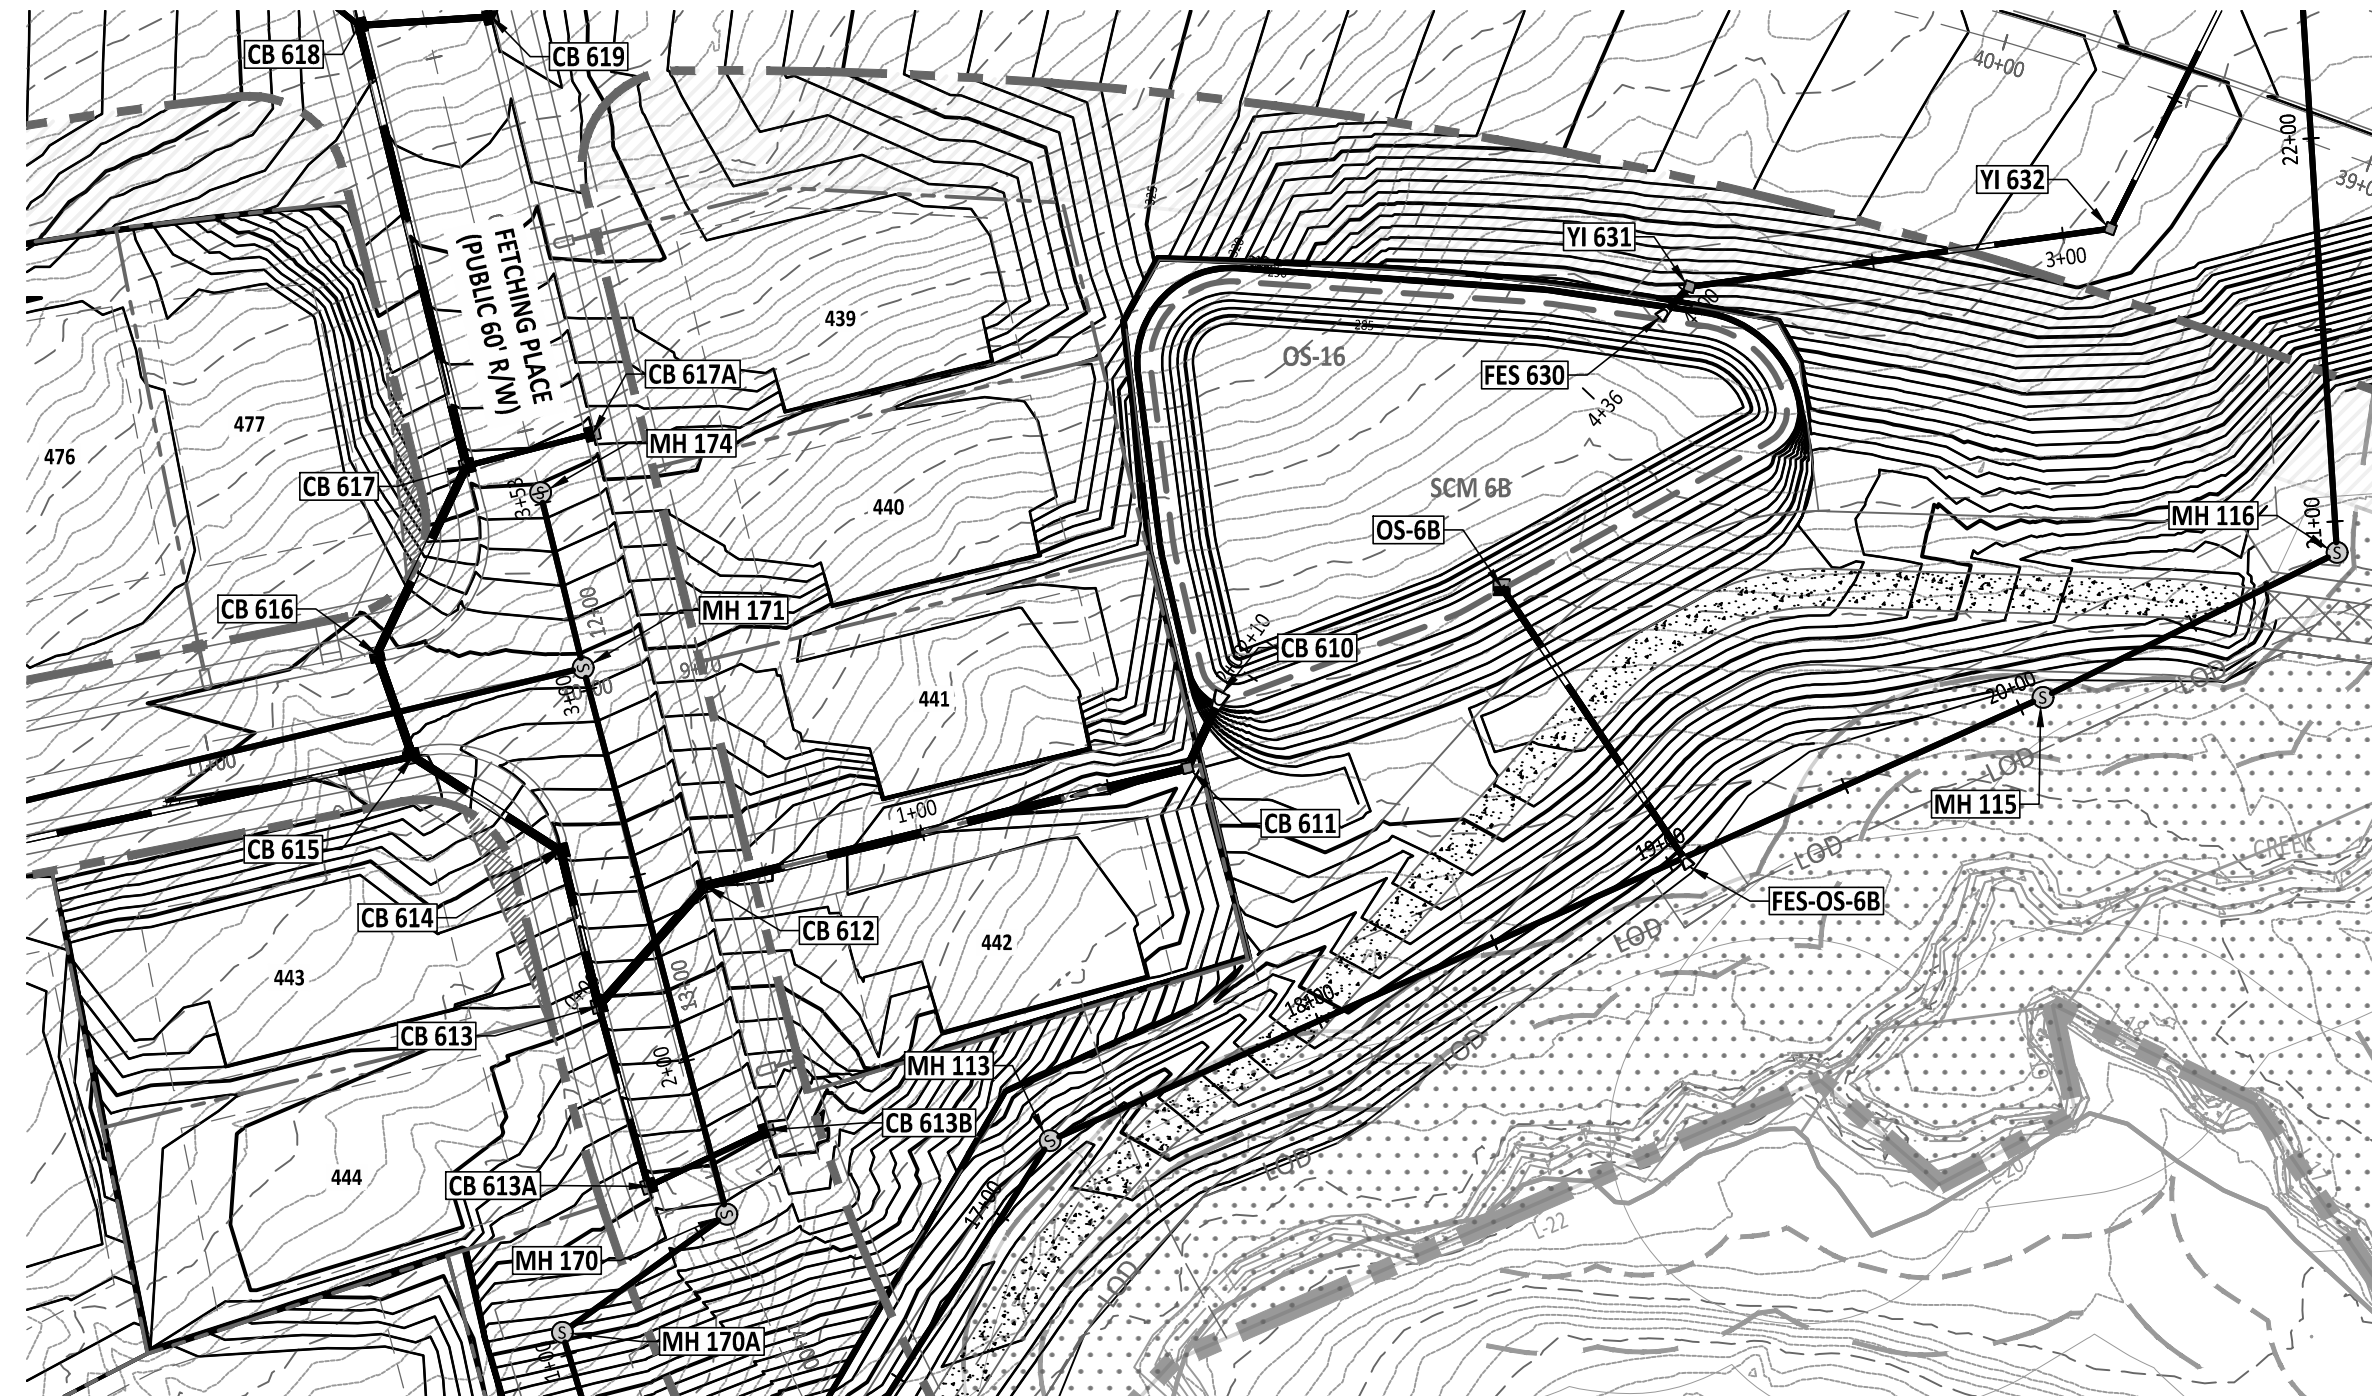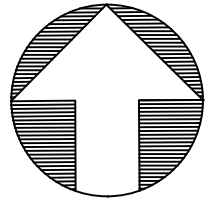

North Carolina 811
www.nc.811.org
*** 3 Days Before Digging ***
North Carolina 811
811 or 1-800-632-4949
Remote Ticket Entry
<http://nc811.org/remoteticketentry.htm>



AMERICAN
Engineering

American Engineering Associates - Southeast, P.A.
4020 Westchase Boulevard, Suite 450
Raleigh, NC 27607
919-469-1101



PRELIMINARY
~~PROFESSIONAL~~
 - DO NOT USE FOR
 CONSTRUCTION



FOR INFORMATION, ONLY

[illegible]




THIS DRAWING WAS PREPARED FOR USE ON THE SPECIFIC SITE, NAMED HEREON, CONTEMPORANEOUSLY WITH ITS ISSUE DATE AS LISTED, HEREON, AND IT IS NOT SUITABLE FOR USE ON A DIFFERENT PROJECT SITE OR AT A LATER TIME. USE OF THIS DRAWING FOR REFERENCE OR EXAMPLE ON ANOTHER PROJECT REQUIRES THE SERVICES OF PROPERLY LICENSED ARCHITECTS AND ENGINEERS. REPRODUCTION OF THIS DRAWING FOR REUSE ON ANOTHER PROJECT IS NOT AUTHORIZED AND MAY BE CONTRARY TO THE LAW.

MERRITT RESERVE
STORM OUTFALL PLAN & PROFILE
ROLESVILLE RD
WAKE COUNTY NC 27312

DB NUMBER:	23-0004
CHECKED BY:	BH
DRAWN BY:	DH/RC/SM/GE/MA/LL/JB
DATE:	05/01/2025

STORM OUFALL PLAN & PROFILE

 SHEET NO.:
CU-308

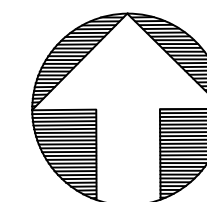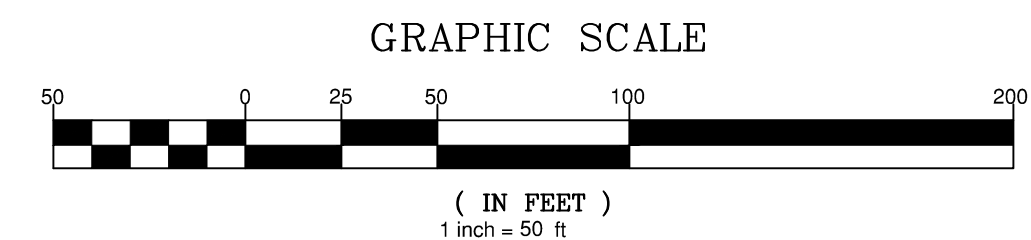

AMERICAN
Engineering

American Engineering Associates • Southeast, P.A.
4020 Westchase Boulevard, Suite 450
Raleigh, NC 27607
919-469-1101



FOR INFORMATION, ONLY

[illegible]

STIPULATION FOR REUSE

THIS DRAWING WAS PREPARED FOR USE ON THE SPECIFIC SITE, NAMED HEREON, CONTEMPORANEOUSLY WITH ITS ISSUE DATE AS LISTED, HEREON, AND IT IS NOT SUITABLE FOR USE ON A DIFFERENT PROJECT SITE OR AT A LATER TIME. USE OF THIS DRAWING FOR REFERENCE OR EXAMPLE ON ANOTHER PROJECT REQUIRES THE SERVICES OF PROPERLY LICENSED ARCHITECTS AND ENGINEERS. REPRODUCTION OF THIS DRAWING FOR REUSE ON ANOTHER PROJECT IS NOT AUTHORIZED AND MAY BE CONTRARY TO THE LAW.

MERRITT RESERVE
STORM OUTFALL PLAN & PROFILE
ROLESVILLE RD
WAKE COUNTY NC 27312

JOB NUMBER: 23-0004

CHECKED BY: BH

DRAWN BY: DH/BC/SM/GE/MA/II/IR

DATE: 05/01/2025


SHEET TITLE:

SHEET TITLE:

STORM OUFALL PLAN & PROFILE

SHEET NO.: _____












CU-309

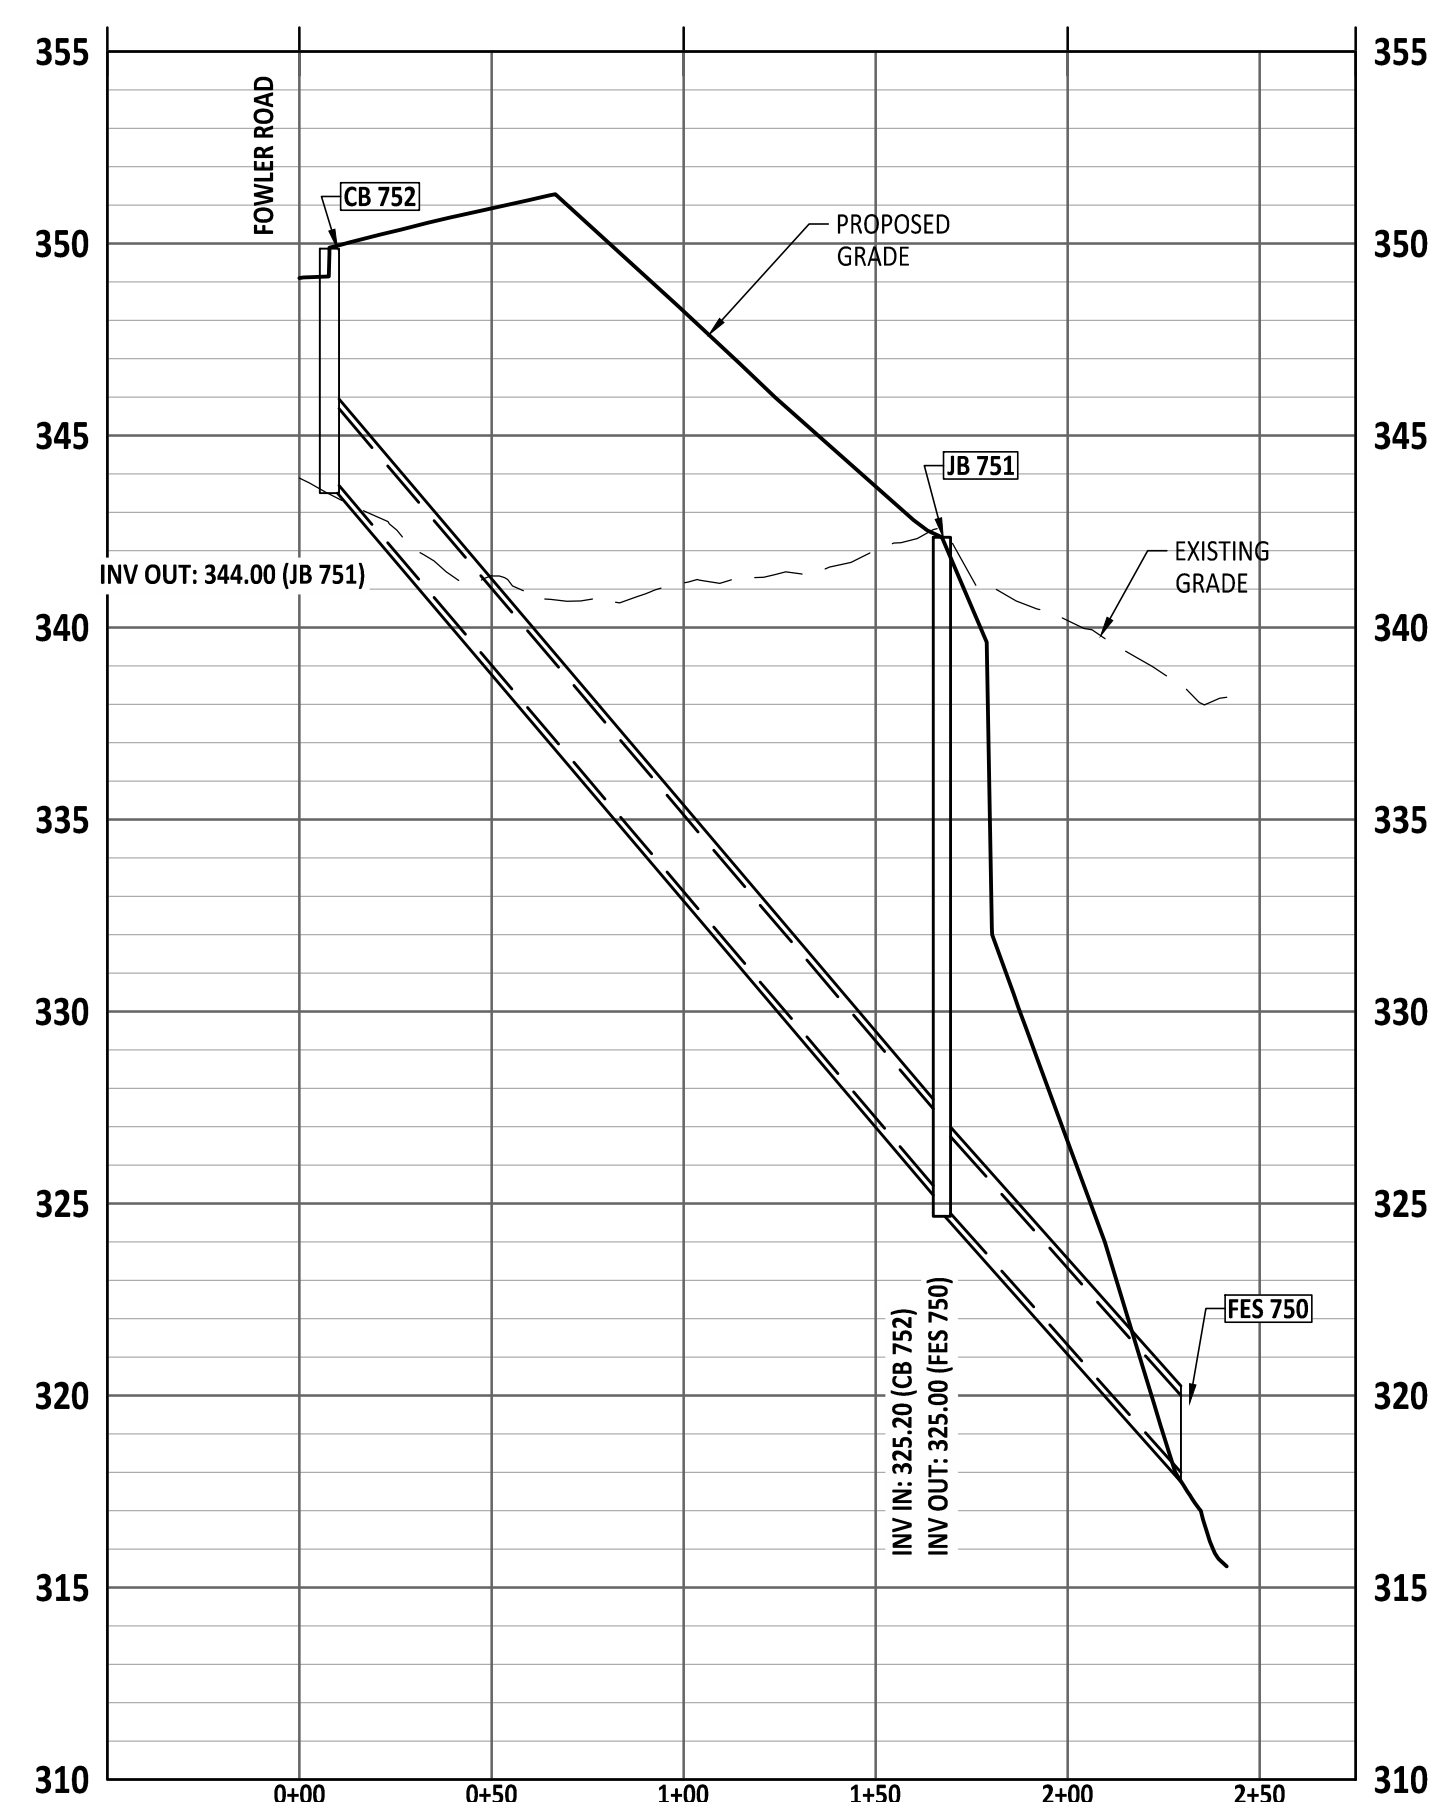

North Carolina 811
www.nc.811.org


*** 3 Days Before Digging ***
North Carolina 811
811 or 1-800-632-4949
Remote Ticket Entry
<http://nc811.org/remoteticketentry.htm>

PROJECT NUMBER = PSP-24-07

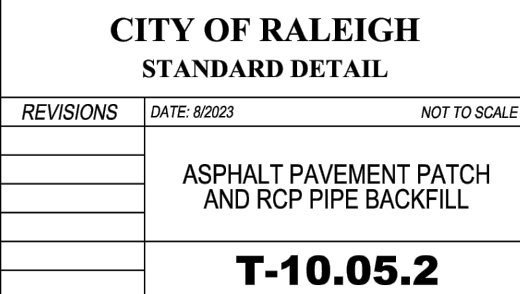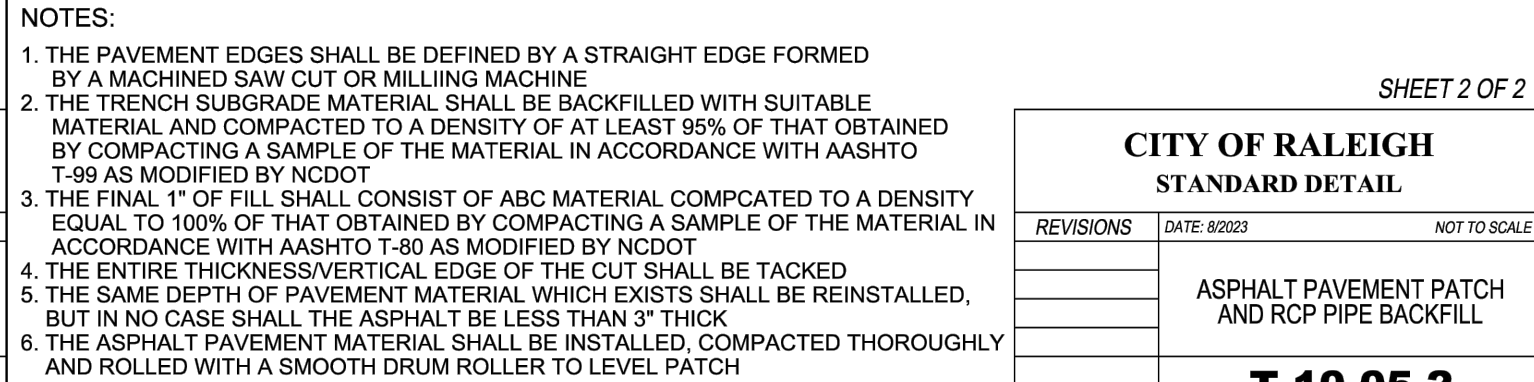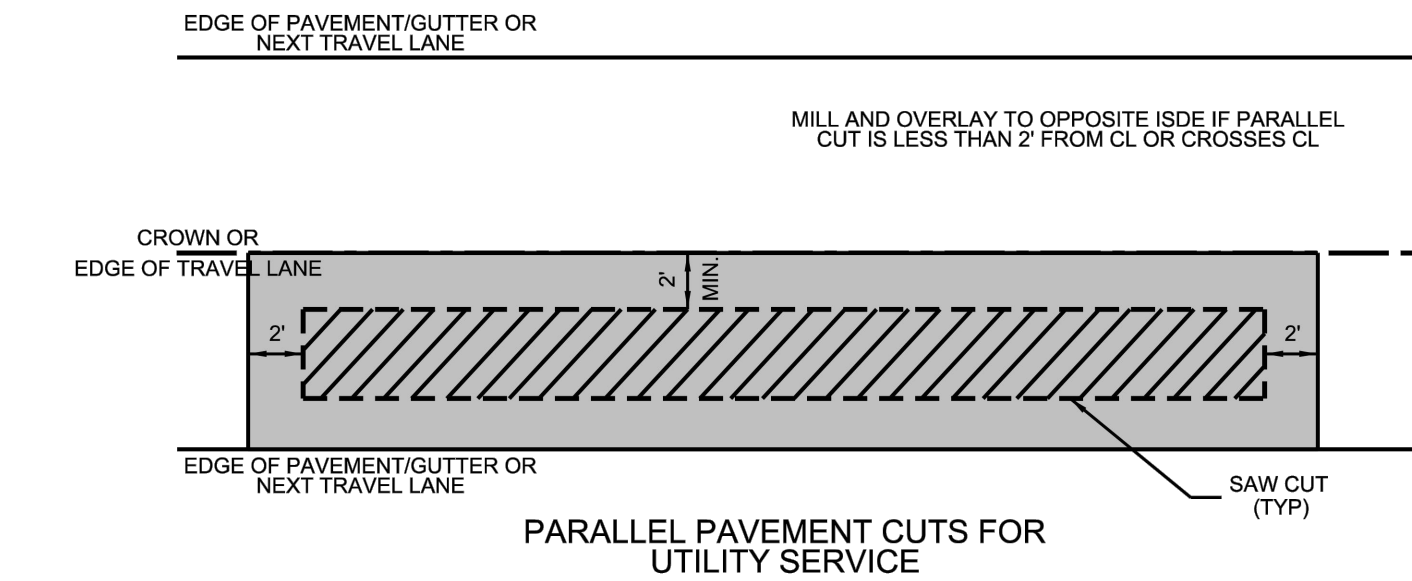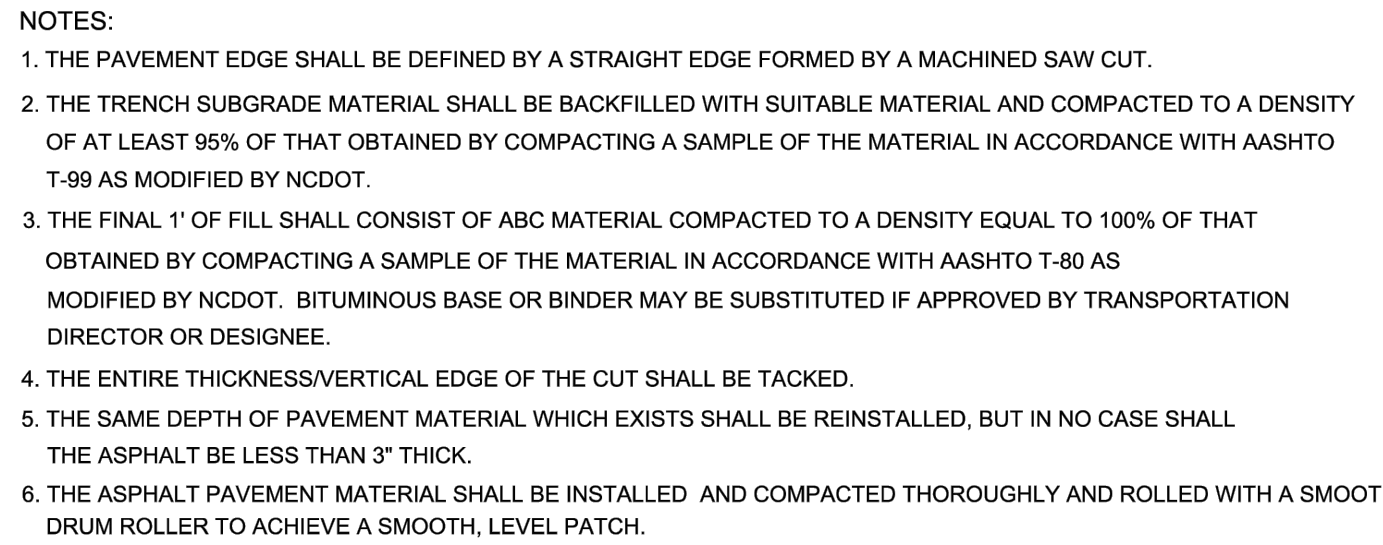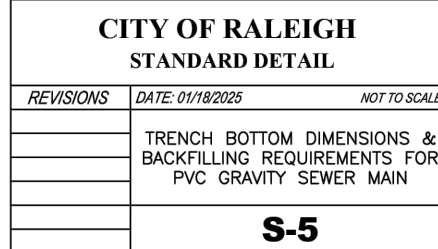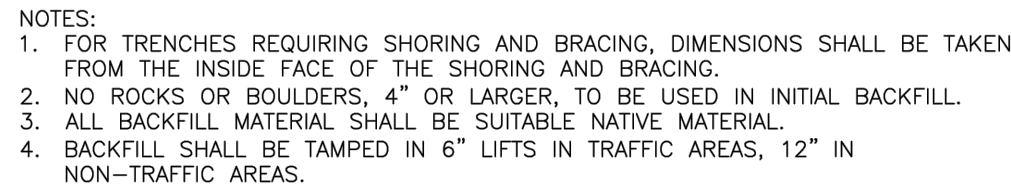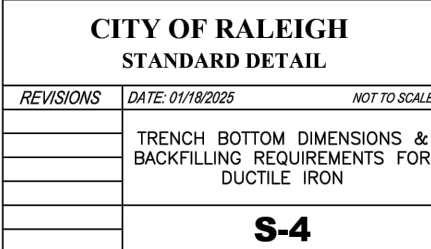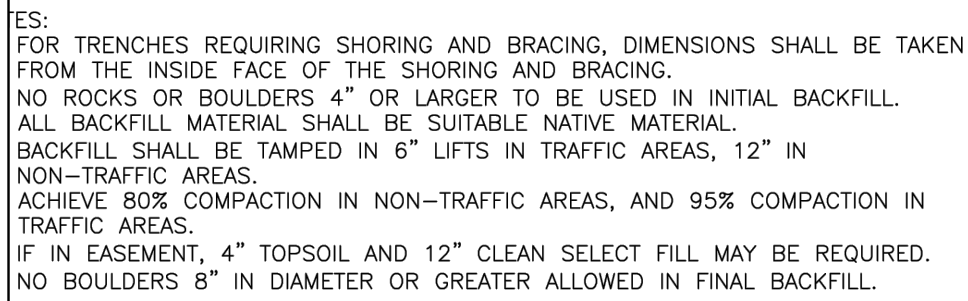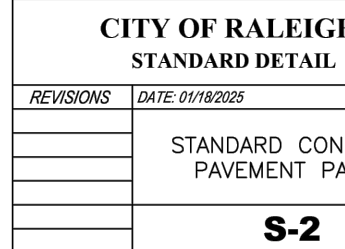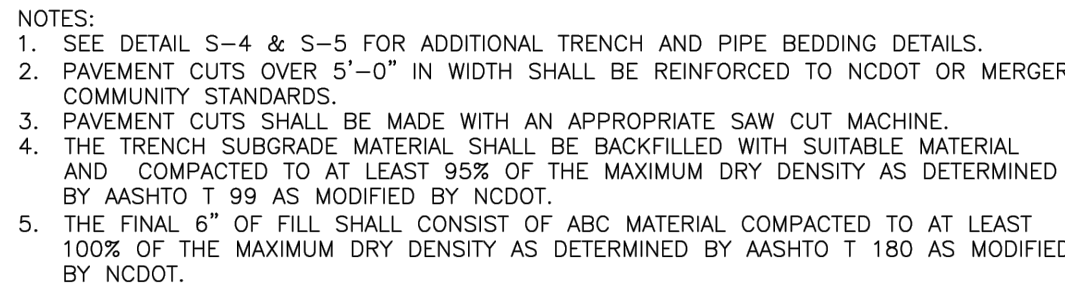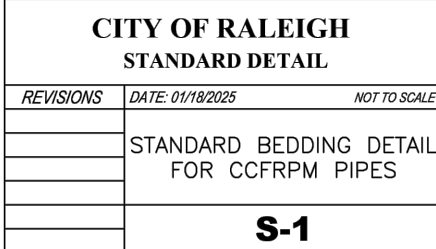




N/F
OPTIMAL DEVELOPMENT, LLC
D.B. 18224 PAGE 1209
B.M. 1985 PAGE 1807
PIN# 1768.03-33-7689
LAND USE: VACANT
ZONING: RL

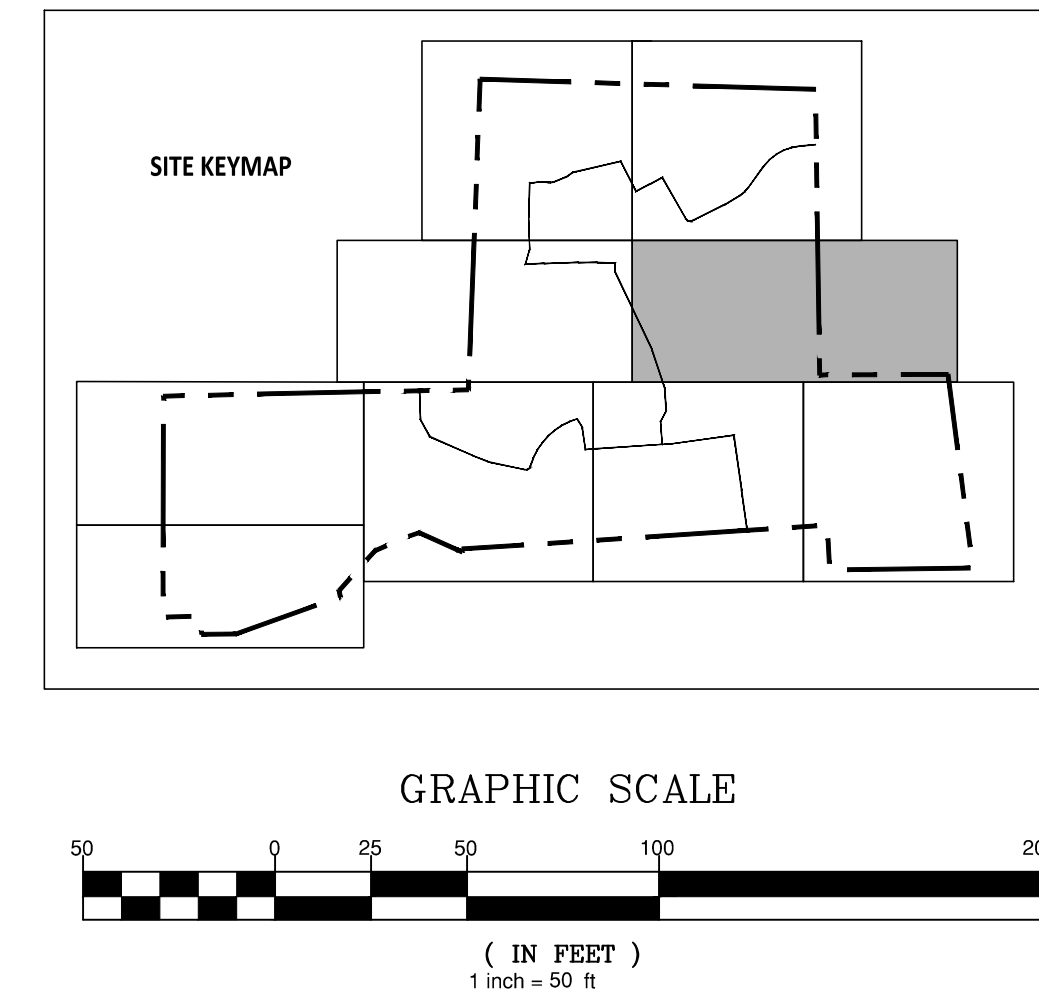


GRAPHIC SCALE

(IN FEET)
1 inch = 50 ft

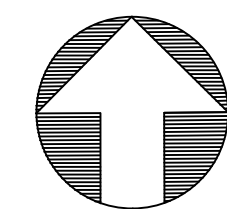

AMERICAN
Engineering

American Engineering Associates - Southeast, P.A.
4020 Westchase Boulevard, Suite 450
Raleigh, NC 27607
919-469-1101

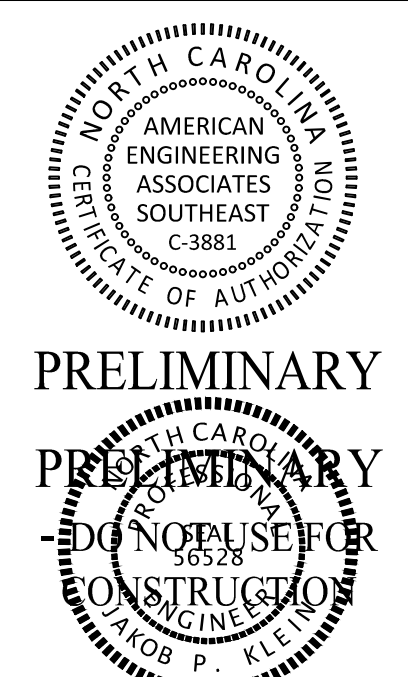

PRELIMINARY

PRELIMINARY
-DO NOT USE FOR
56528

FOR INFORMATION, ONLY

[illegible]

STIPULATION FOR REUSE

THIS DRAWING WAS PREPARED FOR USE ON THE SPECIFIC SITE, NAMED HEREON, CONTEMPORANEOUSLY WITH ITS ISSUE DATE AS LISTED, HEREON. AND IT IS NOT SUITABLE FOR USE ON A DIFFERENT PROJECT SITE OR AT A LATER TIME. USE OF THIS DRAWING FOR REFERENCE OR EXAMPLE ON ANOTHER PROJECT REQUIRES THE SERVICES OF PROPERLY LICENSED ARCHITECTS AND ENGINEERS. REPRODUCTION OF THIS DRAWING FOR REUSE ON ANOTHER PROJECT IS NOT AUTHORIZED AND MAY BE CONTRARY TO THE LAW.

MERRITT RESERVE
GRADING AND DRAINAGE
ROLESVILLE RD
WAKE COUNTY NC 27312

JOB NUMBER:	23-0004
CHECKED BY:	BH
DRAWN BY:	DH/RC/SM/GE/MA/LL/JB
DATE:	05/01/2025
SHEET TITLE:	


 
GRADING AND DRAINAGE

SHEET NO.: **CG-102**



PROJECT NUMBER = PSP-24-07

2:065.123-0004 Interim Property and Working Drawings (Construction Set) 55. Co-101-103 Grading and Drainage (50 Scale).dwg

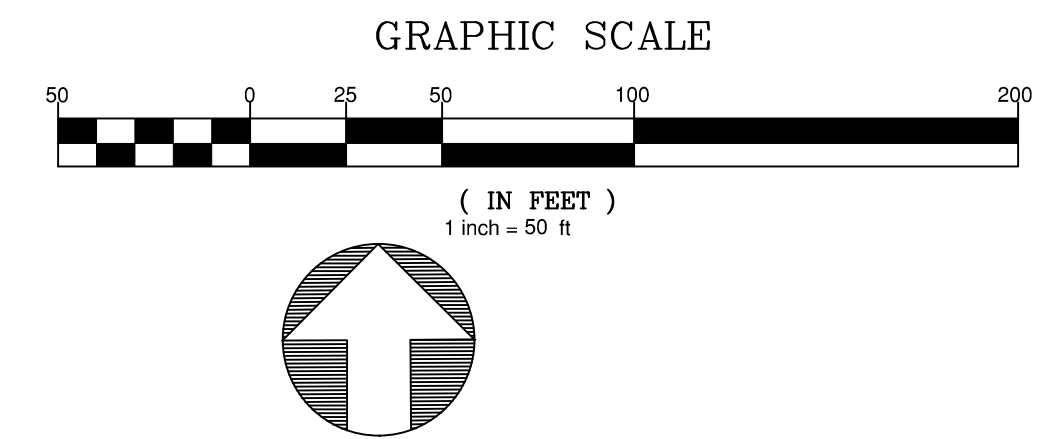


North 811
Carolina
www.nc811.org

*** 3 Days Before Digging ***
North Carolina 811
811 or 1-800-632-4949
Remote Ticket Entry
<http://nc811.org/remoteticketentry.htm>



**AMERICAN
Engineering**

American Engineering Associates - Southeast, P. A.
4020 Westchase Boulevard, Suite 450
Raleigh, NC 27607 919-469-1101

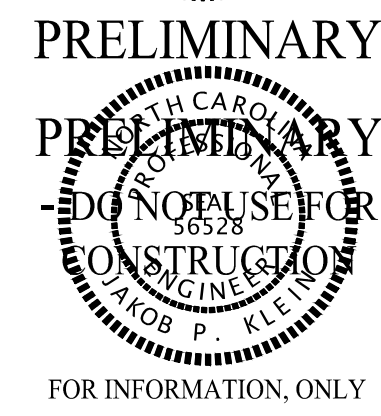

STIPULATION FOR REUSE


THIS DRAWING WAS PREPARED FOR USE ON THE SPECIFIC SITE, NAMED HEREON, CONTEMPORANEOUSLY WITH ITS ISSUE DATE AS LISTED, HEREON, AND IT IS NOT SUITABLE FOR USE ON A DIFFERENT PROJECT SITE OR AT A LATER TIME. USE OF THIS DRAWING FOR REFERENCE OR EXAMPLE ON ANOTHER PROJECT REQUIRES THE SERVICES OF PROPERLY LICENSED ARCHITECTS AND ENGINEERS. REPRODUCTION OF THIS DRAWING FOR REUSE ON ANOTHER PROJECT IS NOT AUTHORIZED AND MAY BE CONTRARY TO THE LAW.

JOB NUMBER:	23-0004
CHECKED BY:	BH
DRAWN BY:	DH/RC/SM/GE/MA/LL/JB
DATE:	05/01/2025

SHEET NO.: **CG-103**




SEE SHEET CG-106

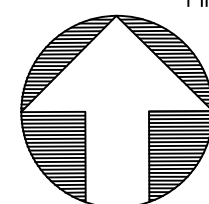

PROJECT NUMBER = PSP-24-07

SHEET NO.: **CG-105**

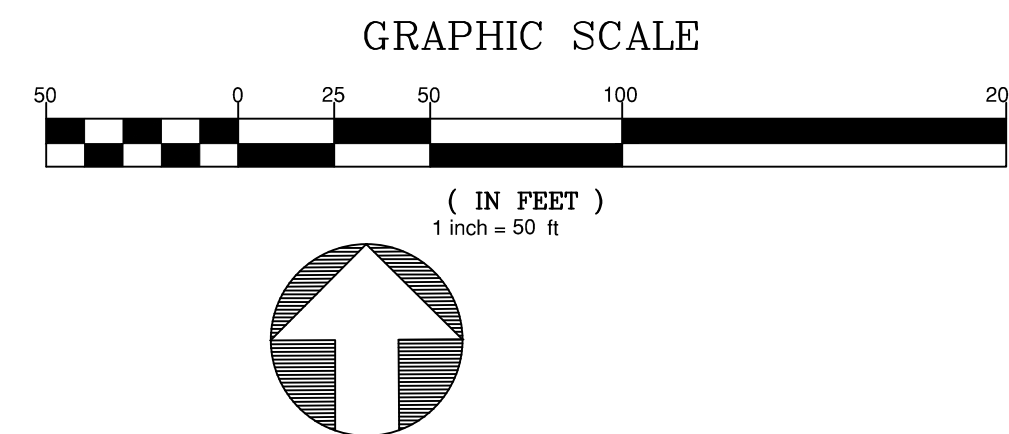

PROJECT NUMBER = PSP-24-07

North Carolina 811
www.nc811.org
*** 3 Days Before Digging ***
North Carolina 811
811 or 1-800-632-4949
Remote Ticket Entry
<http://nc811.org/remoteticketentry.h>

SHEET NO.: **CG-107**

MERRITT RESERVE
GRADING AND DRAINAGE
ROLESVILLE RD
WAKE COUNTY NC 27312

JOB NUMBER:	23-0004
CHECKED BY:	BI
DRAWN BY:	DH/RC/SM/GE/MA/LL/JH
DATE:	05/01/2023
SHEET TITLE:	

GRADING AND DRAINAGE

SHEET NO.: **CG-107**


STIPULATION FOR REUSE

THIS DRAWING WAS PREPARED FOR USE ON THE SPECIFIC SITE, NAMED HEREON, CONTEMPORANEOUSLY WITH ITS ISSUANCE AS LISTED, HEREON, AND IT IS NOT SUITABLE FOR USE ON A DIFFERENT PROJECT SITE OR AT A LATER TIME. USE OF THIS DRAWING FOR REFERENCE OR EXAMPLE ON ANOTHER PROJECT REQUIRES THE SERVICES OF PROPERLY LICENSED ARCHITECTS AND ENGINEERS. REPRODUCTION OF THIS DRAWING FOR REUSE ON ANOTHER PROJECT IS NOT AUTHORIZED AND MAY BE CONTRARY TO THE LAW.

Nº	DATE	REVISION:
----	------	-----------

FOR INFORMATION, ONLY




 
PRELIMINARY
NORTH CAROLINA
PRELIMINARY
-DO NOT USE FOR
56528
CONSTRUCTION





AMERICAN
Engineering

American Engineering Associates • Southeast, P.A.
1020 Westchase Boulevard, Suite 450
919-469-1101
Raleigh, NC 27607

Z:\shh\23-0004 Merritt Property\8807.dwg, Working Draw Sheet Construction Set\US, CG-401 SCM 1A-2 Detail.dwg
23-05-01

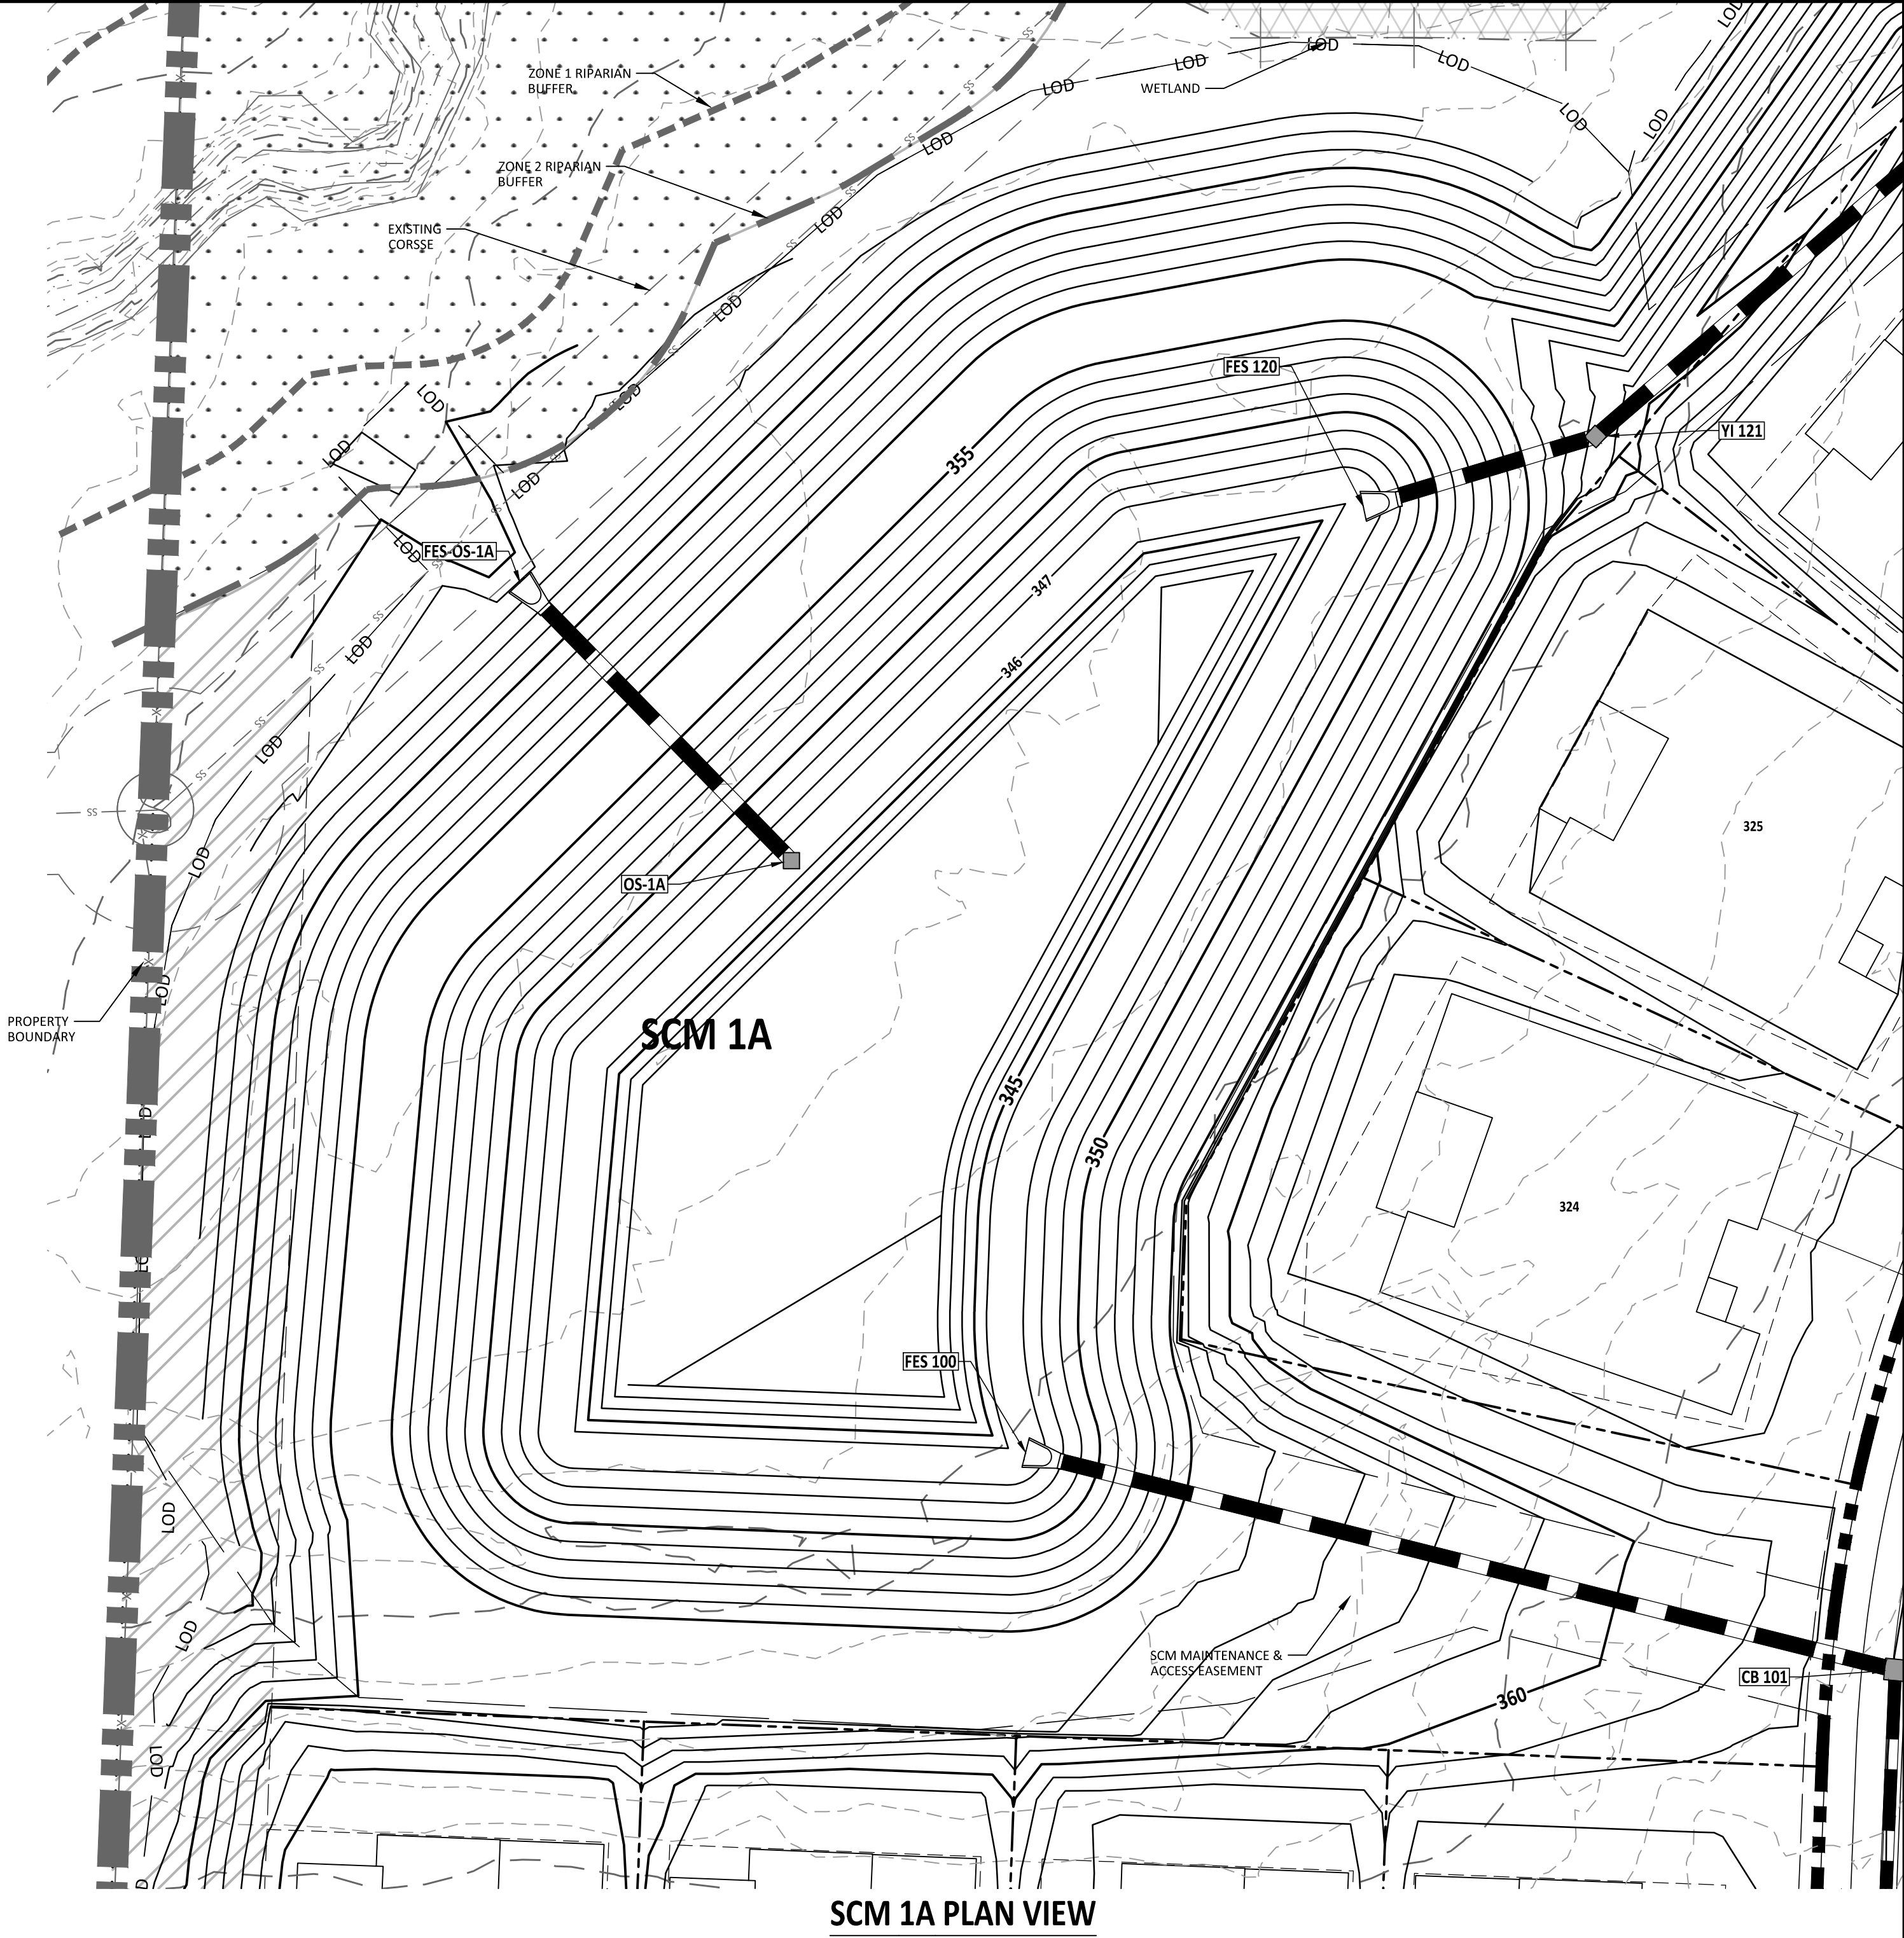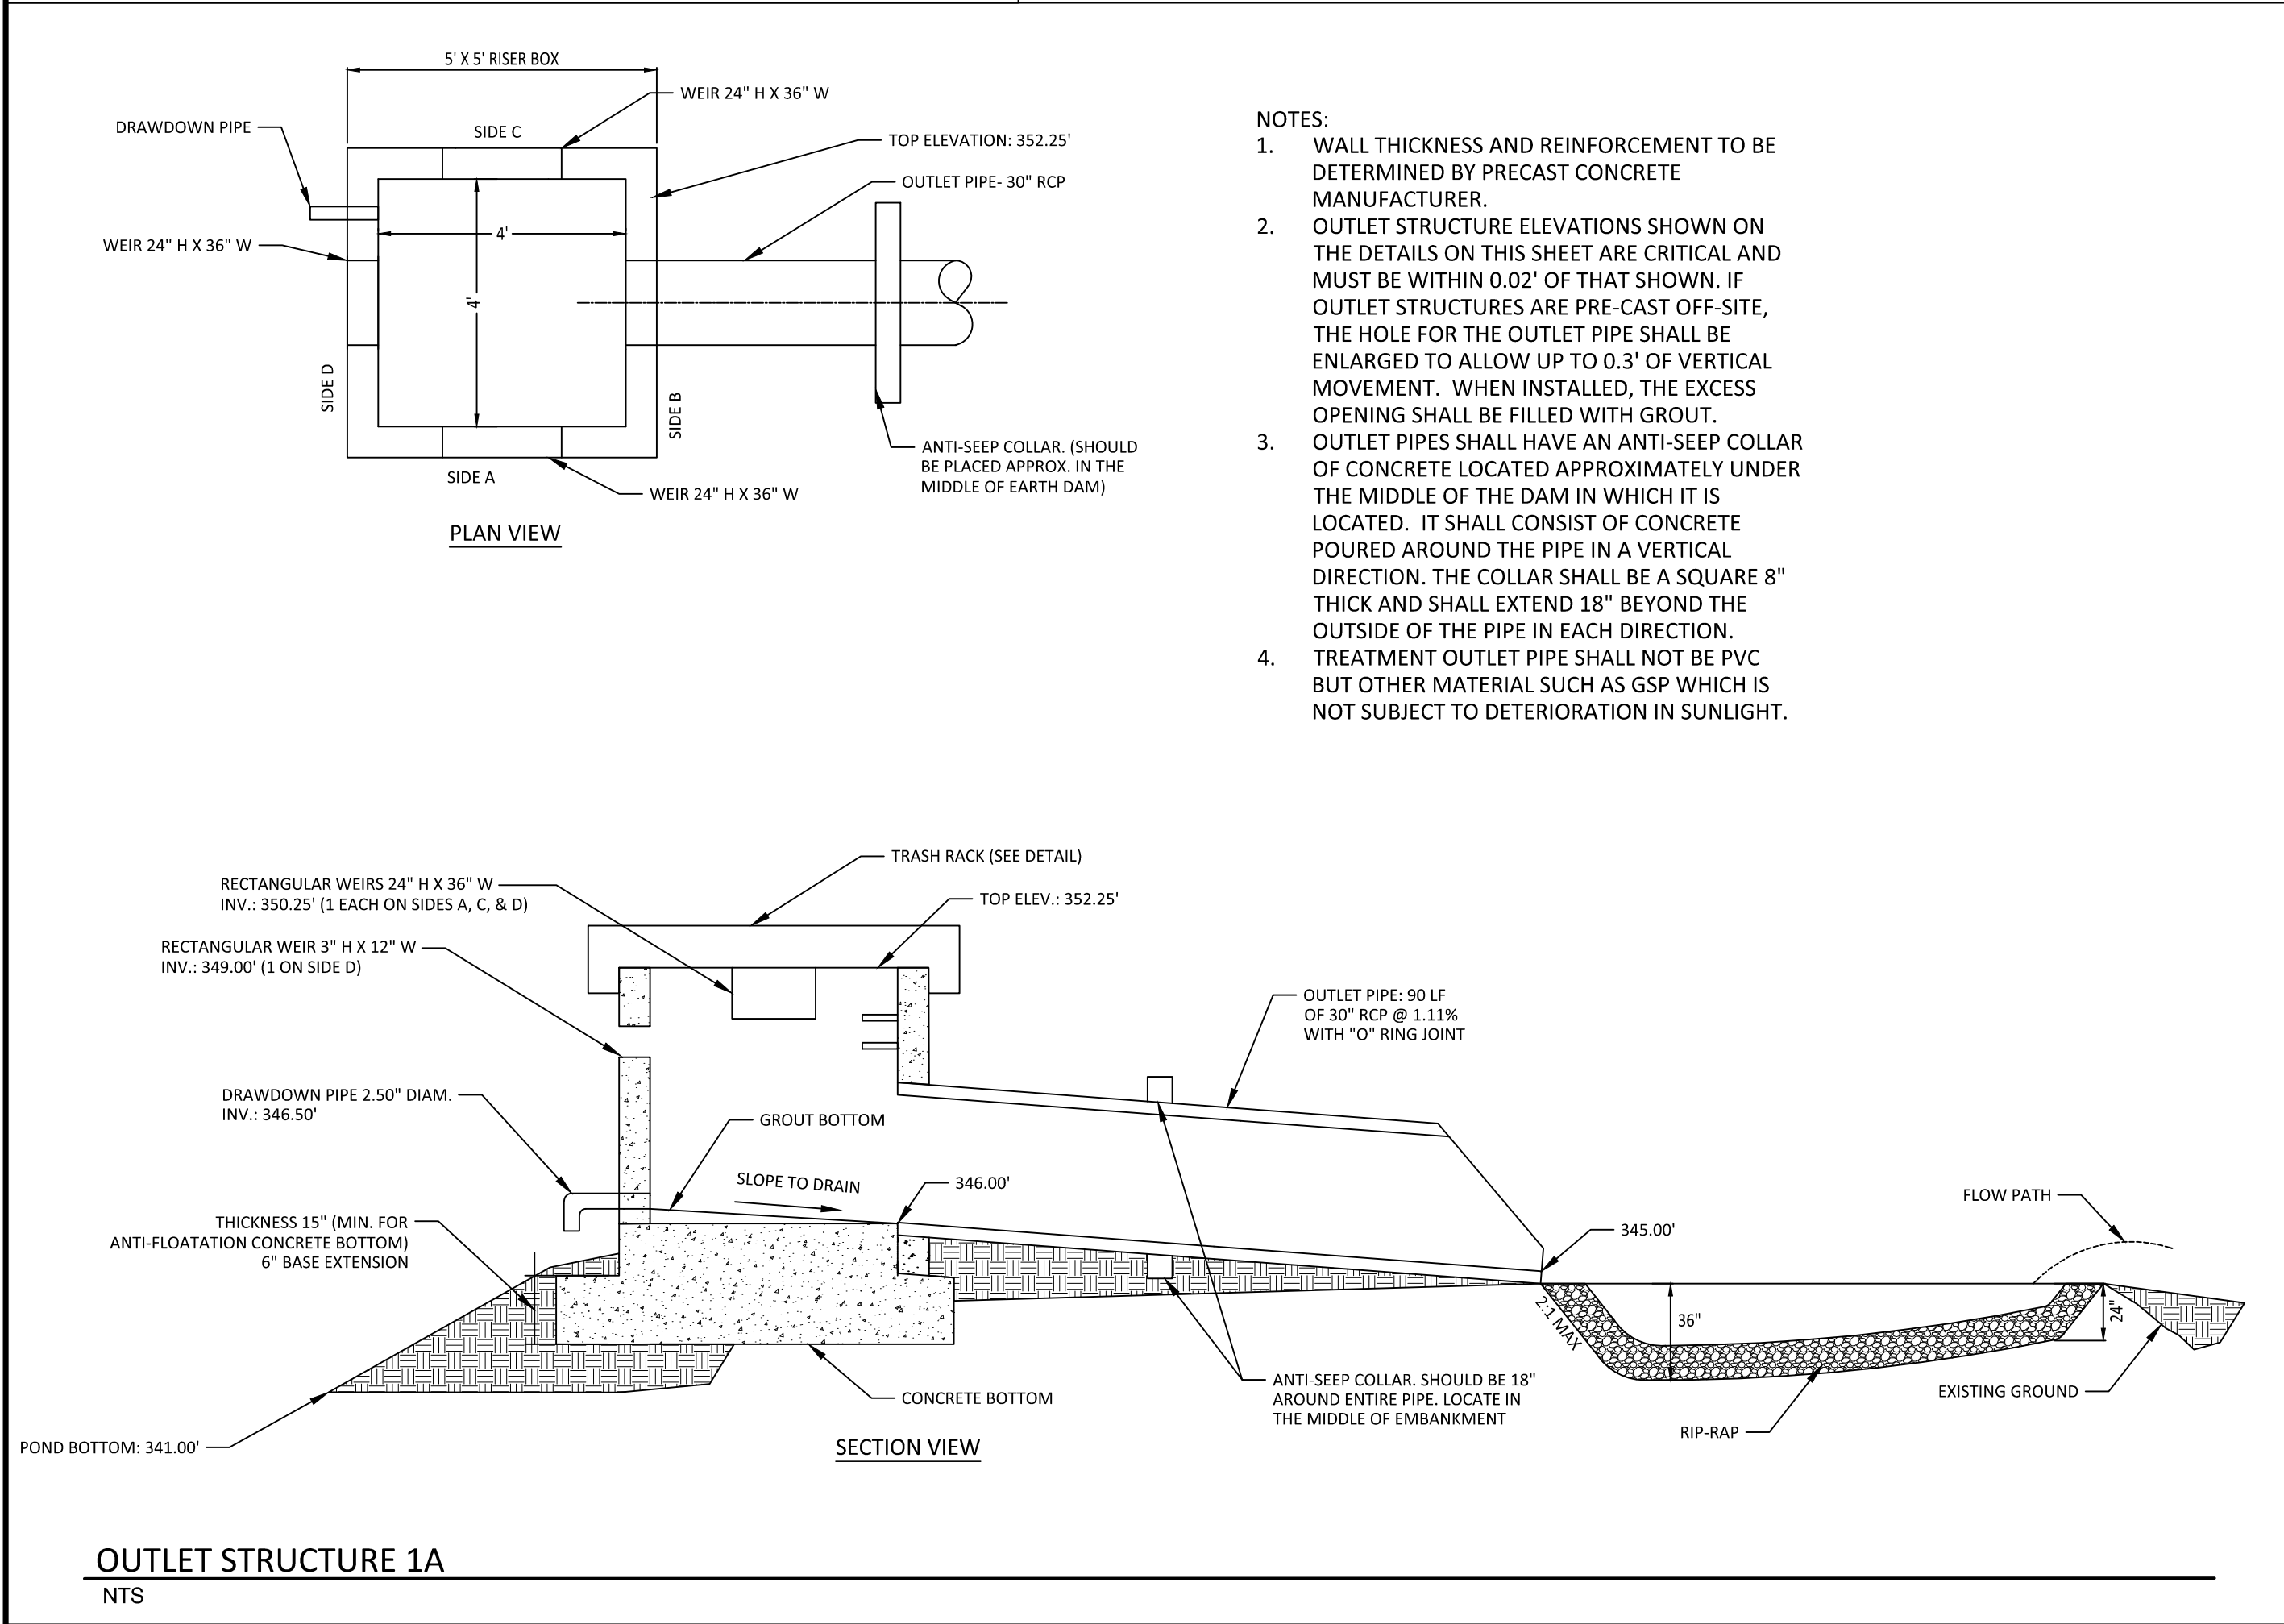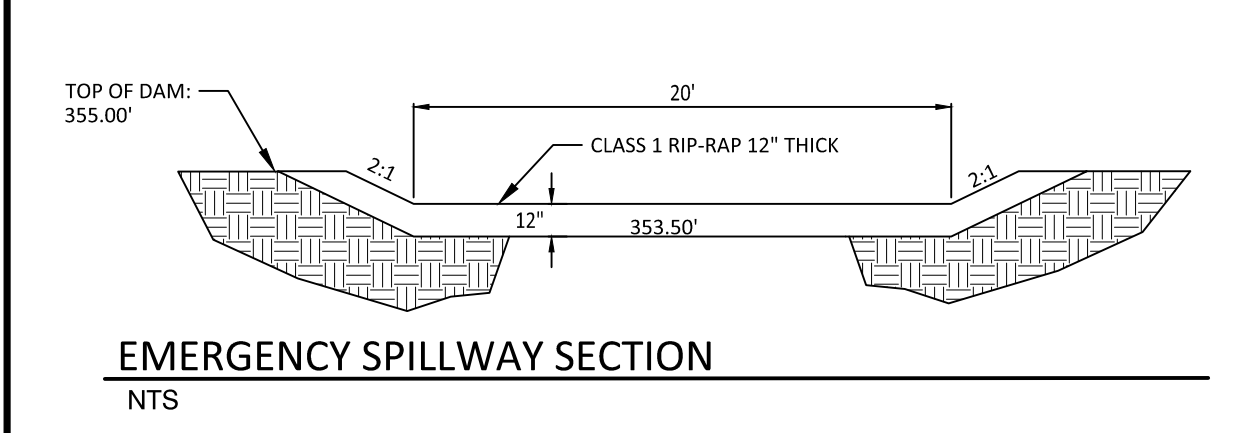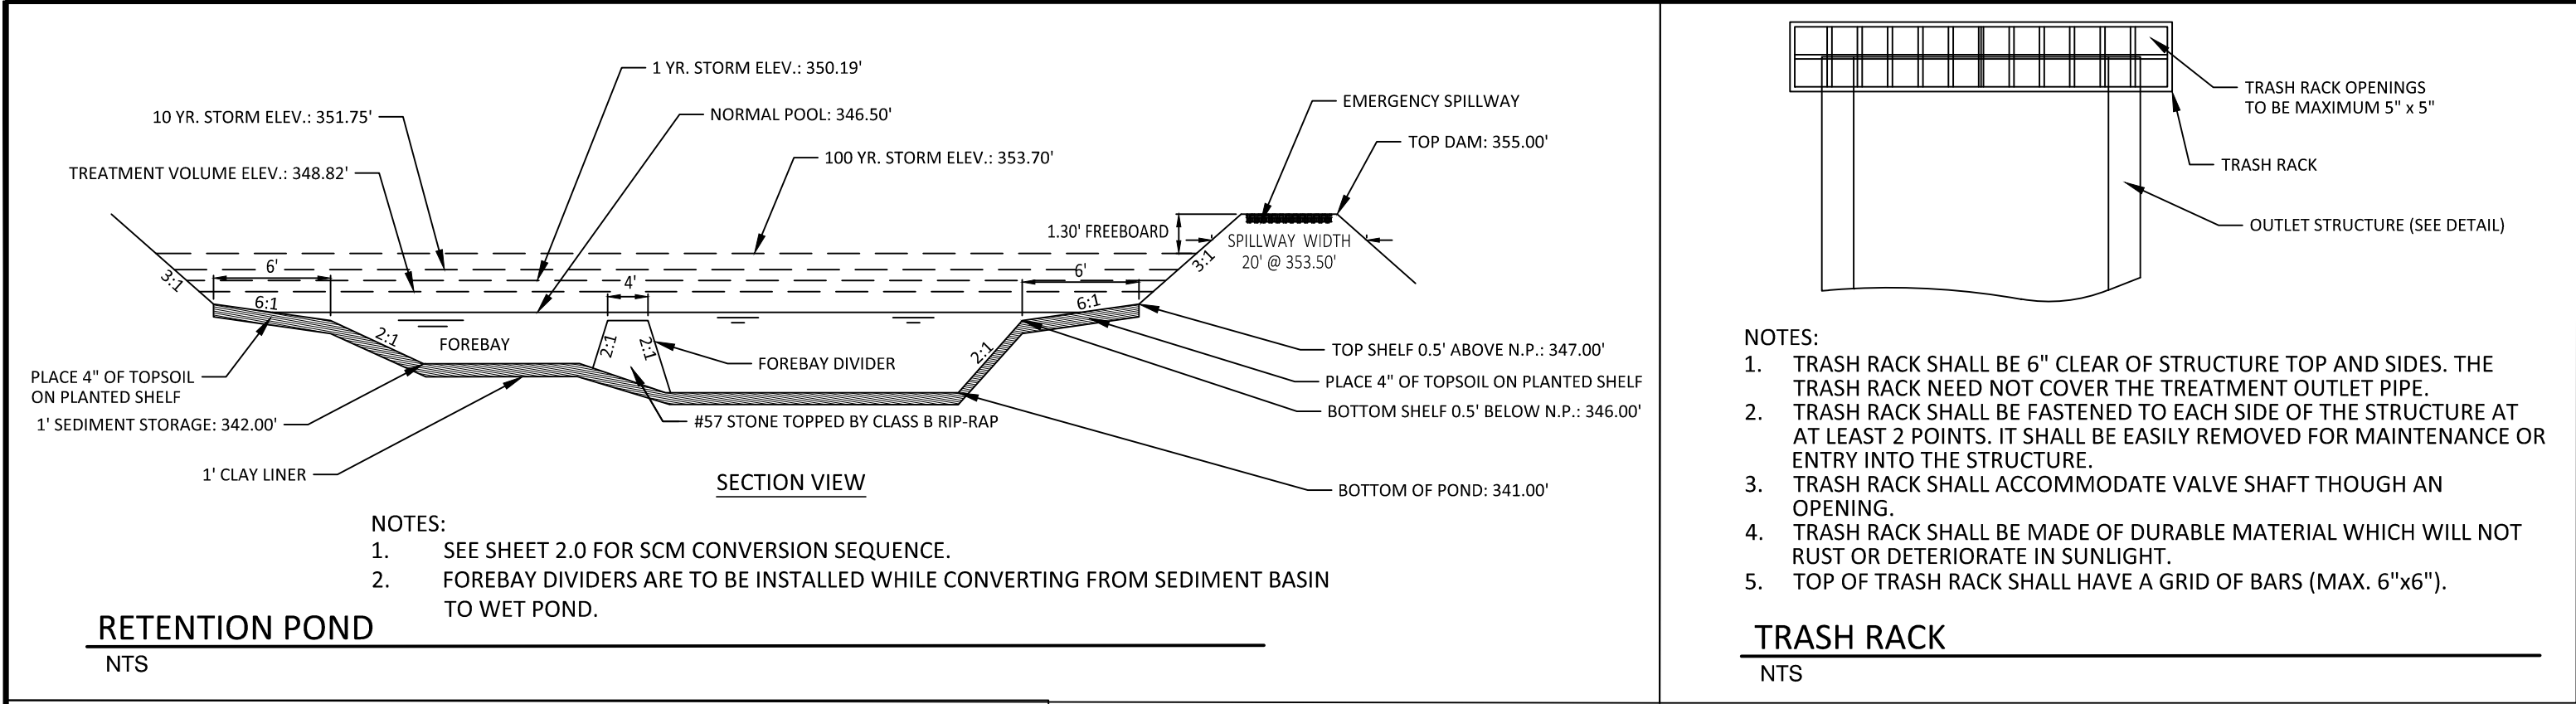

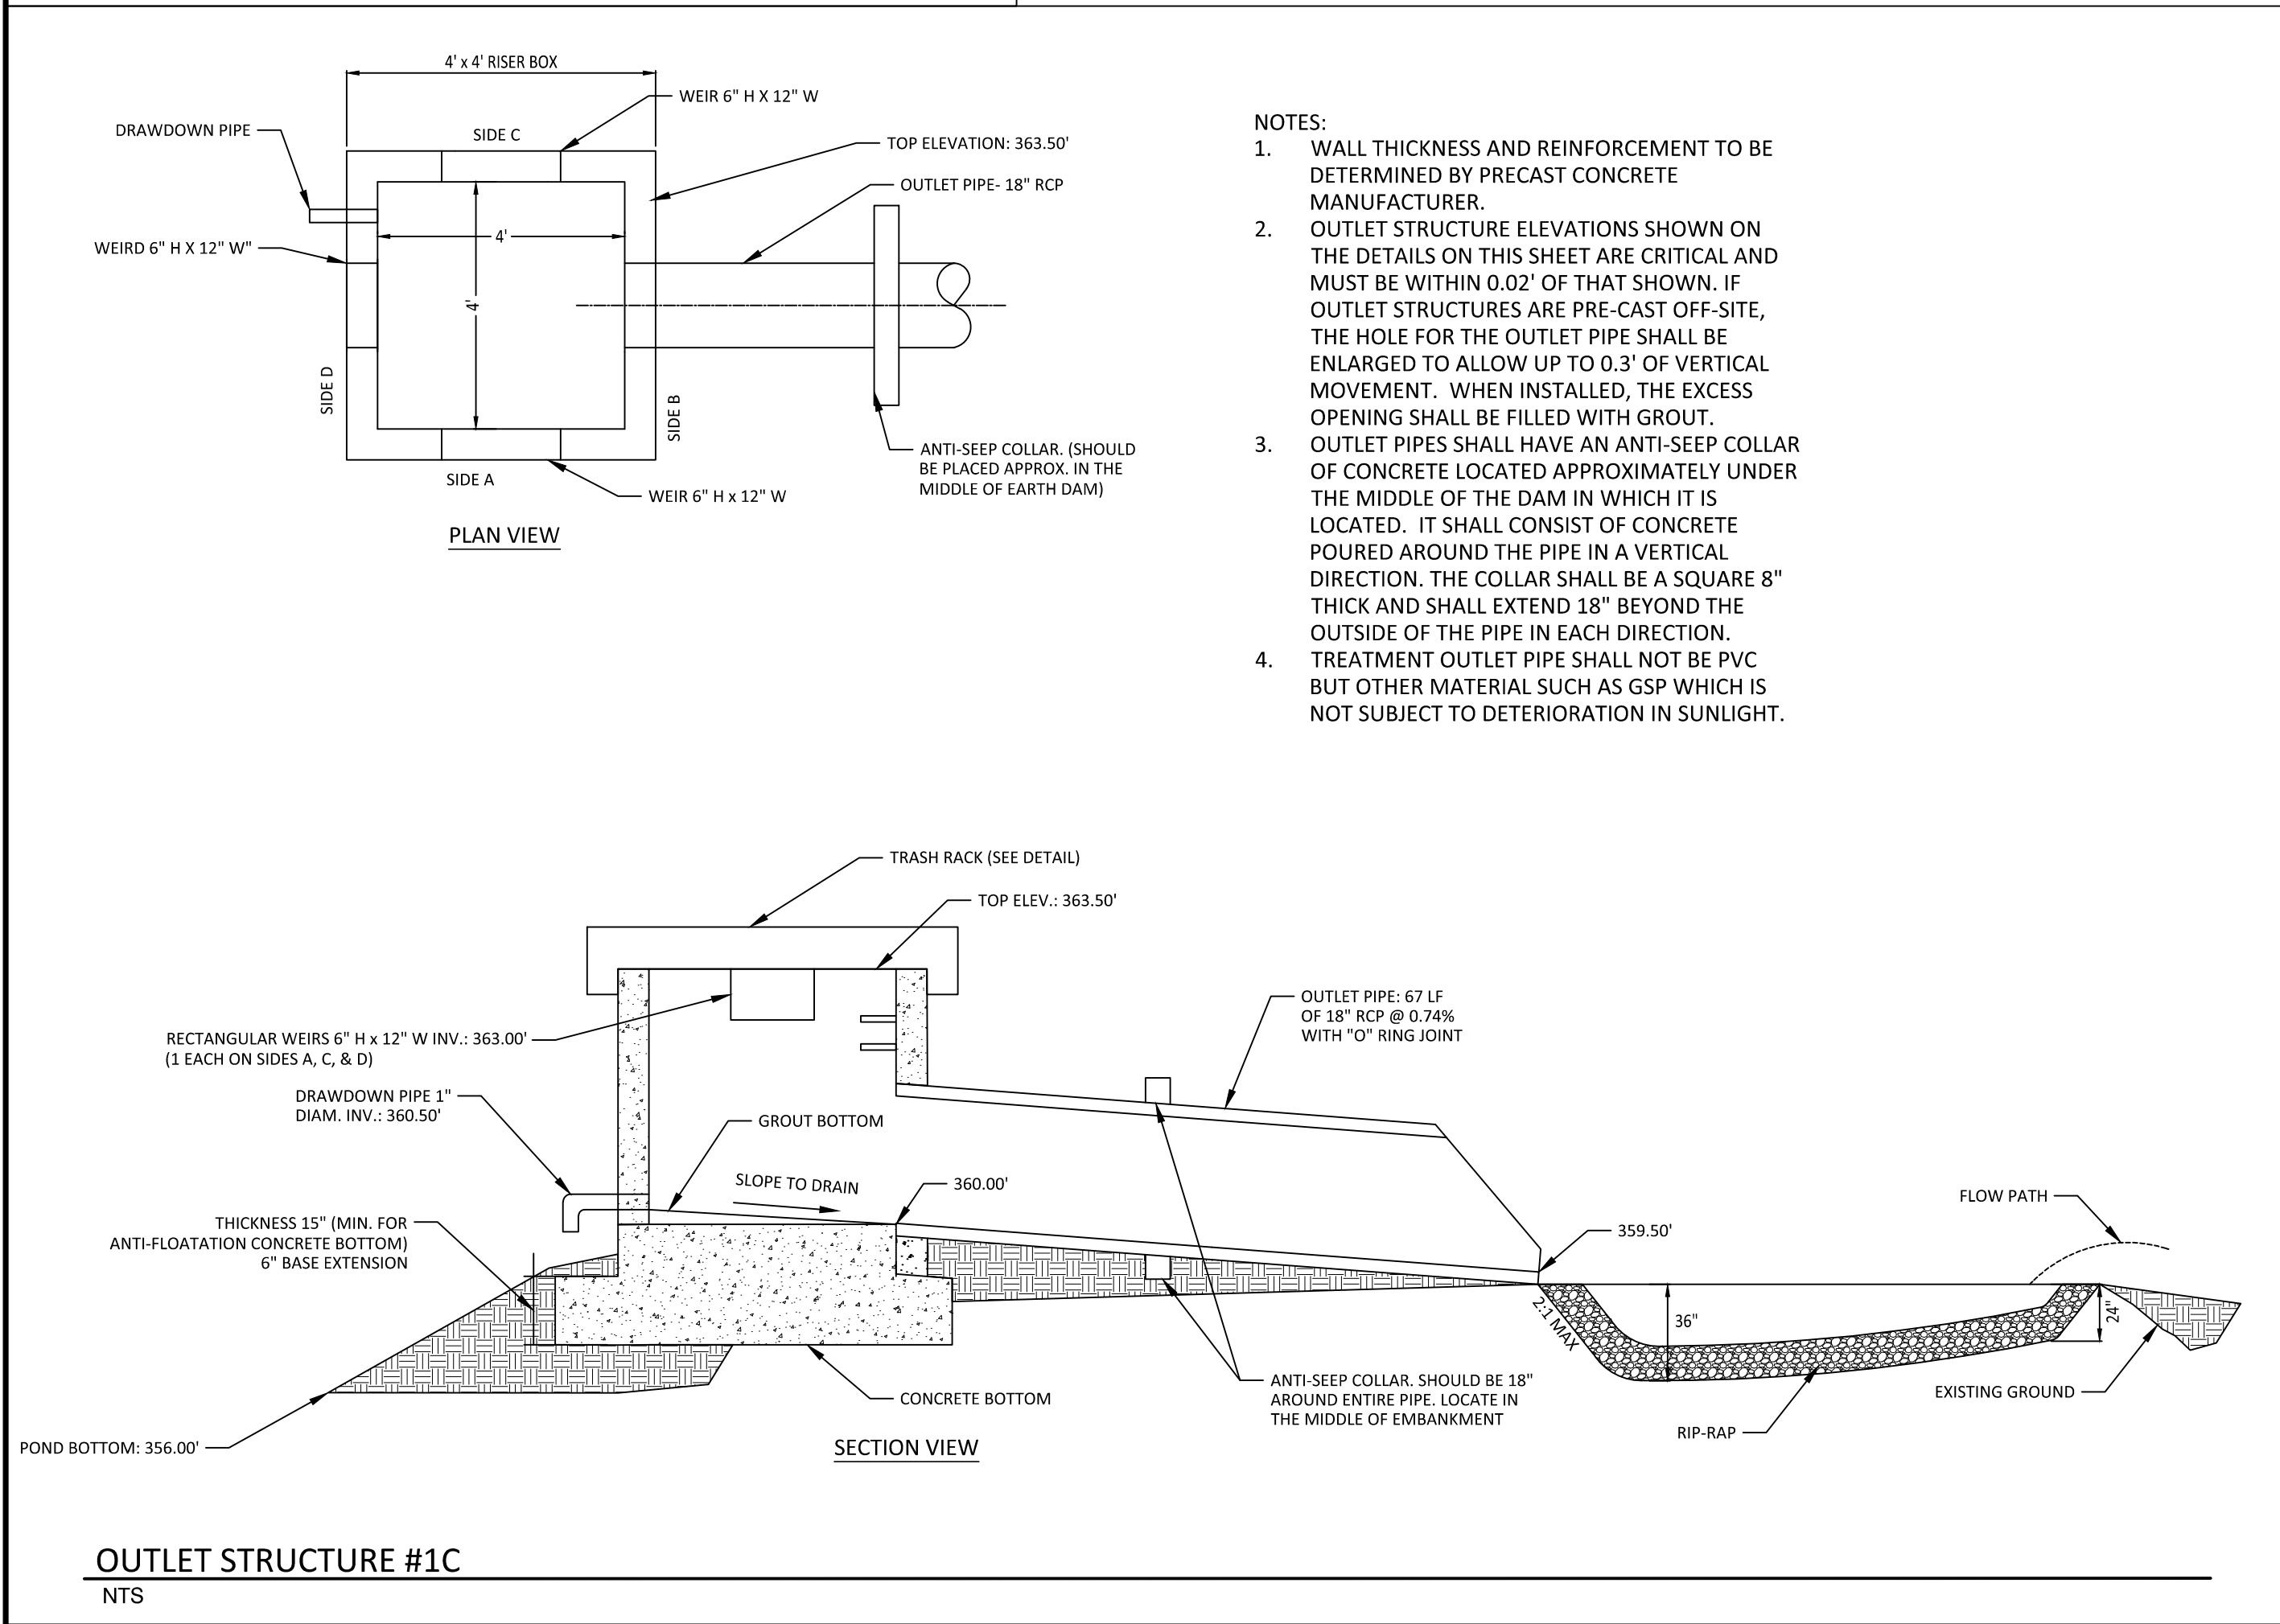
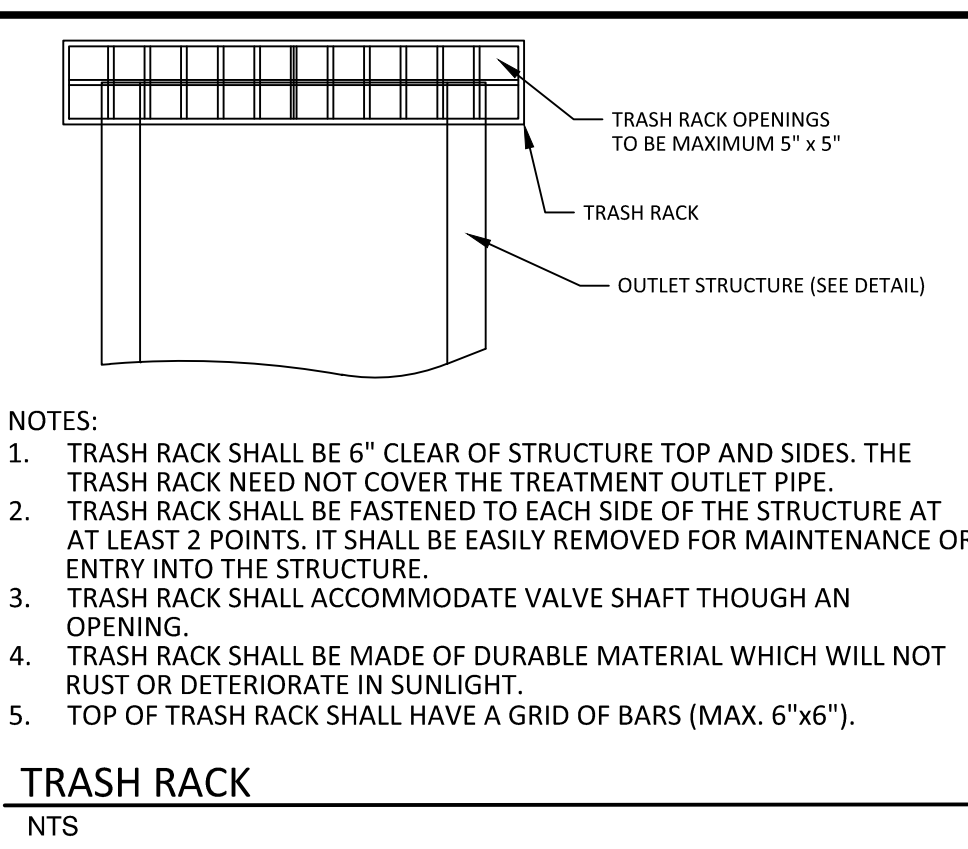


PLANT LIST VEGETATED SHELF PLANT SCHEDULE:			
VEGETATED SHELF (HERB.)			
EF	EUPATORIUM FISTULOSUM	JOE PYE WEED	4-6" POT @ 3' SPACING
HC	HIBISCUS COCCINEA	SCARLET ROSE MALLOW	4-6" POT @ 3' SPACING
CG	CHELONE GLABRA	WHITE TURTLEHEAD	4-6" POT @ 3' SPACING
LC	LOBELIA CARDINALIS	CARDINAL FLOWER	4-6" POT @ 3' SPACING

LANDSCAPE PLAN:
VEGETATED SHELF= 3172 sf (USE 793 PLANTS FROM LIST ABOVE)
USE EQUAL NUMBER OF PLANTS FROM LIST ABOVE

CALCULATION: 50 PLANTS PER 200 SF

[illegible]

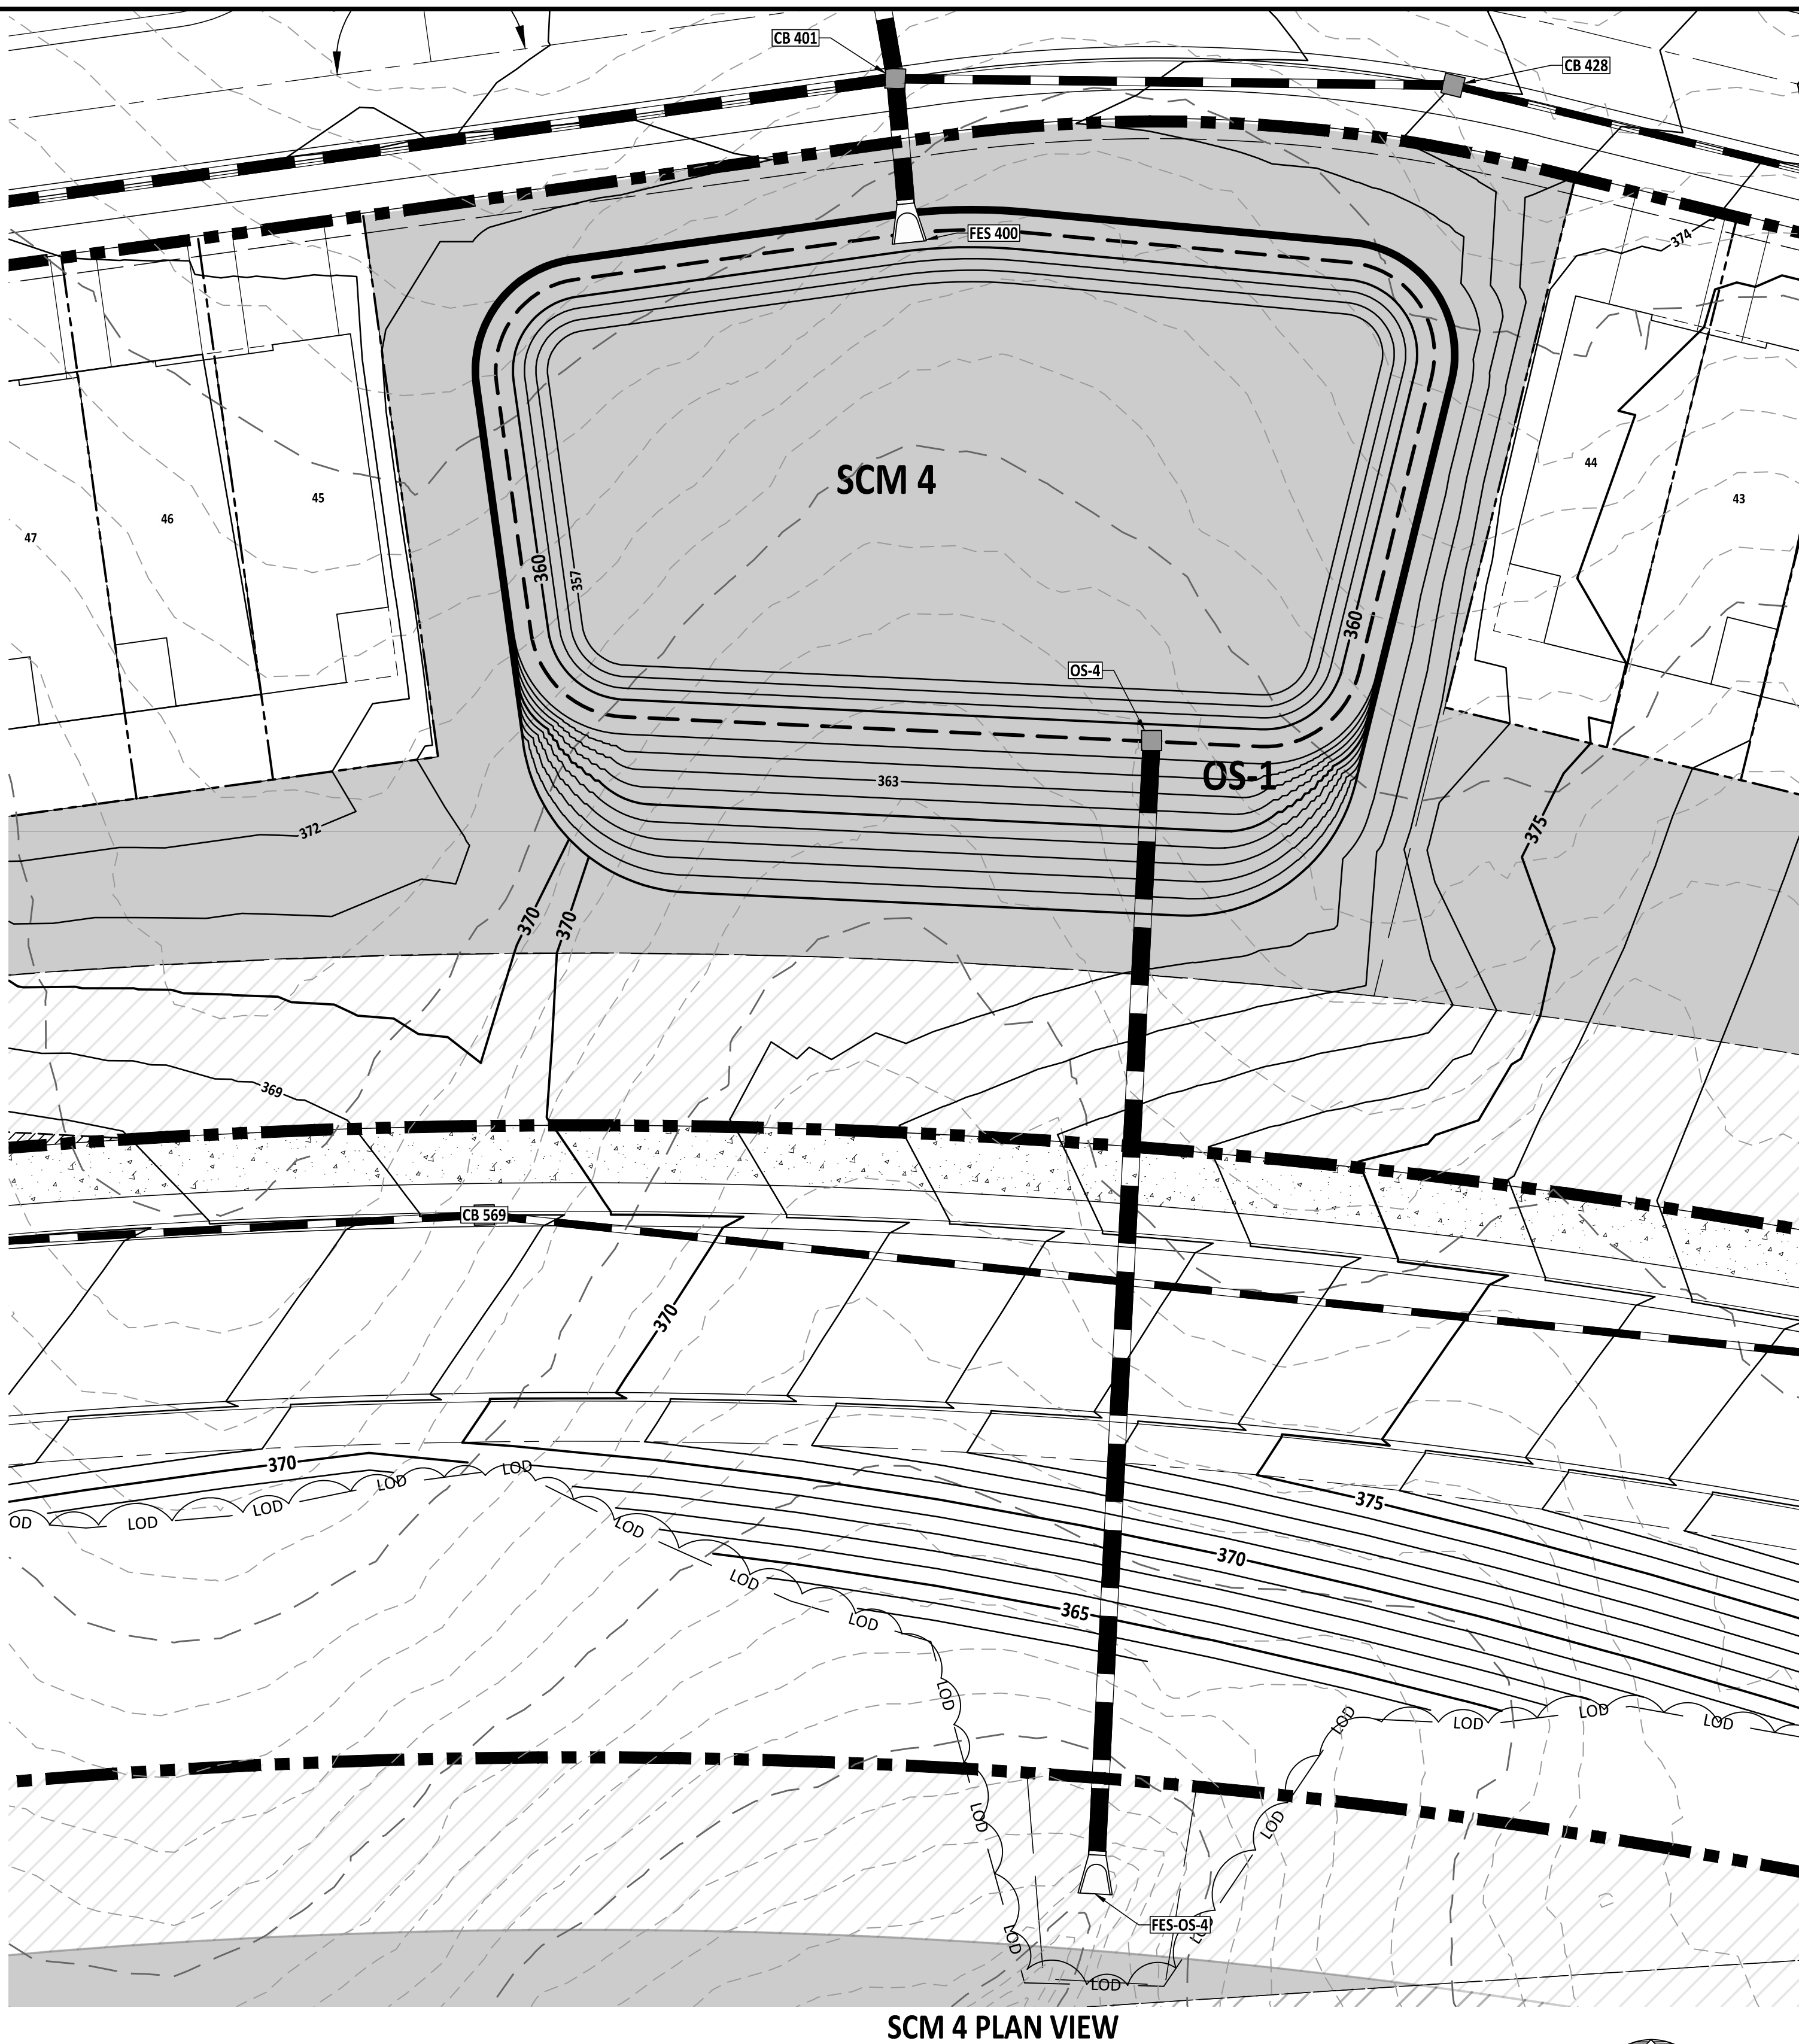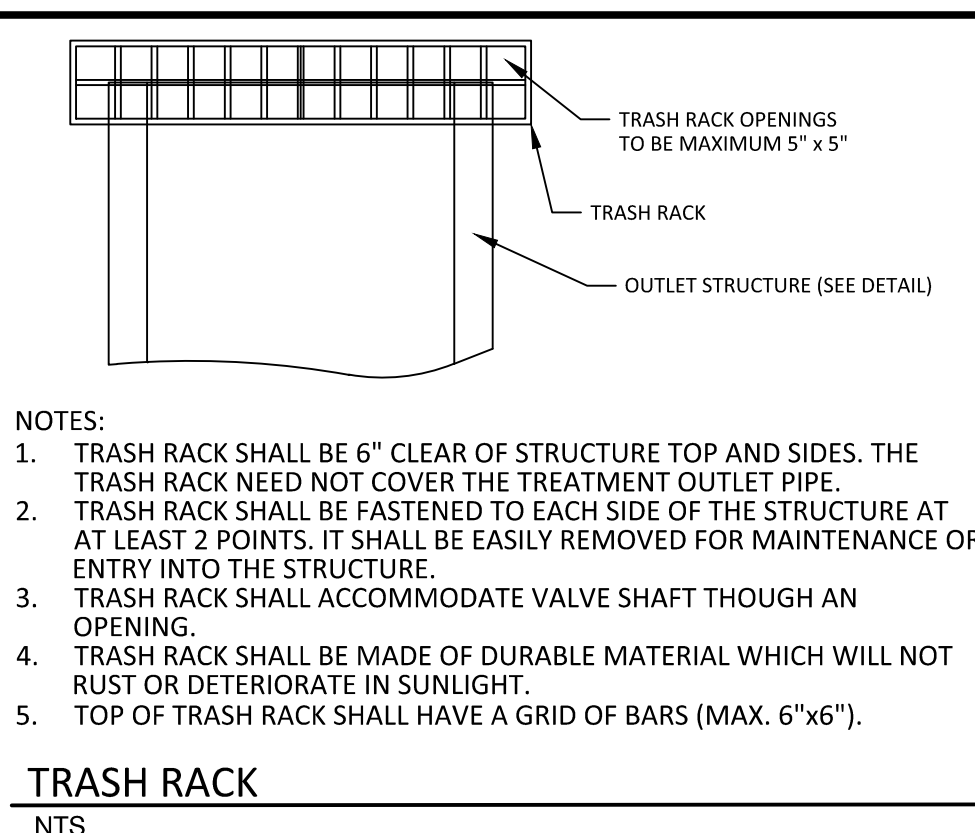

CALCULATION: 50 PLANTS PER 200 SF



NORTH CAROLINA
 AMERICAN
 ENGINEERING
 ASSOCIATES
 SOUTHEAST
 C-3881
 CERTIFICATE OF AUTHORIZATION
 STATE NO. 56528
 PRELIMINARY
 DO NOT USE FOR
 CONSTRUCTION
 JAKOB P. KLEIN
 CIVIL ENGINEER
 FOR INFORMATION, ONLY

[illegible]



STIPULATION FOR REUSE
THIS DRAWING WAS PREPARED FOR USE ON THE SPECIFIC SITE, NAMED HEREON, CONTEMPORANEOUSLY WITH ITS ISSUE DATE AS LISTED, HEREON, AND IT IS NOT SUITABLE FOR USE ON A DIFFERENT PROJECT SITE OR AT A LATER TIME. USE OF THIS DRAWING FOR REFERENCE OR EXAMPLE ON ANOTHER PROJECT REQUIRES THE SERVICES OF PROPERLY LICENSED ARCHITECTS AND ENGINEERS. REPRODUCTION OF THIS DRAWING FOR REUSE ON ANOTHER PROJECT IS NOT AUTHORIZED AND MAY BE CONTRARY TO THE LAW.



SCM 4 DETAIL
ROLESVILLE RD
WAKE COUNTY NC 27312

BOOK NUMBER:	23-0004
CHECKED BY:	BR
DRAWN BY:	DH/RC/SM/GE/MA/LL/JH
DATE:	05/01/2023
SHEET TITLE:	


SCM 4 DETAIL

SHEET NO.:
CG-405

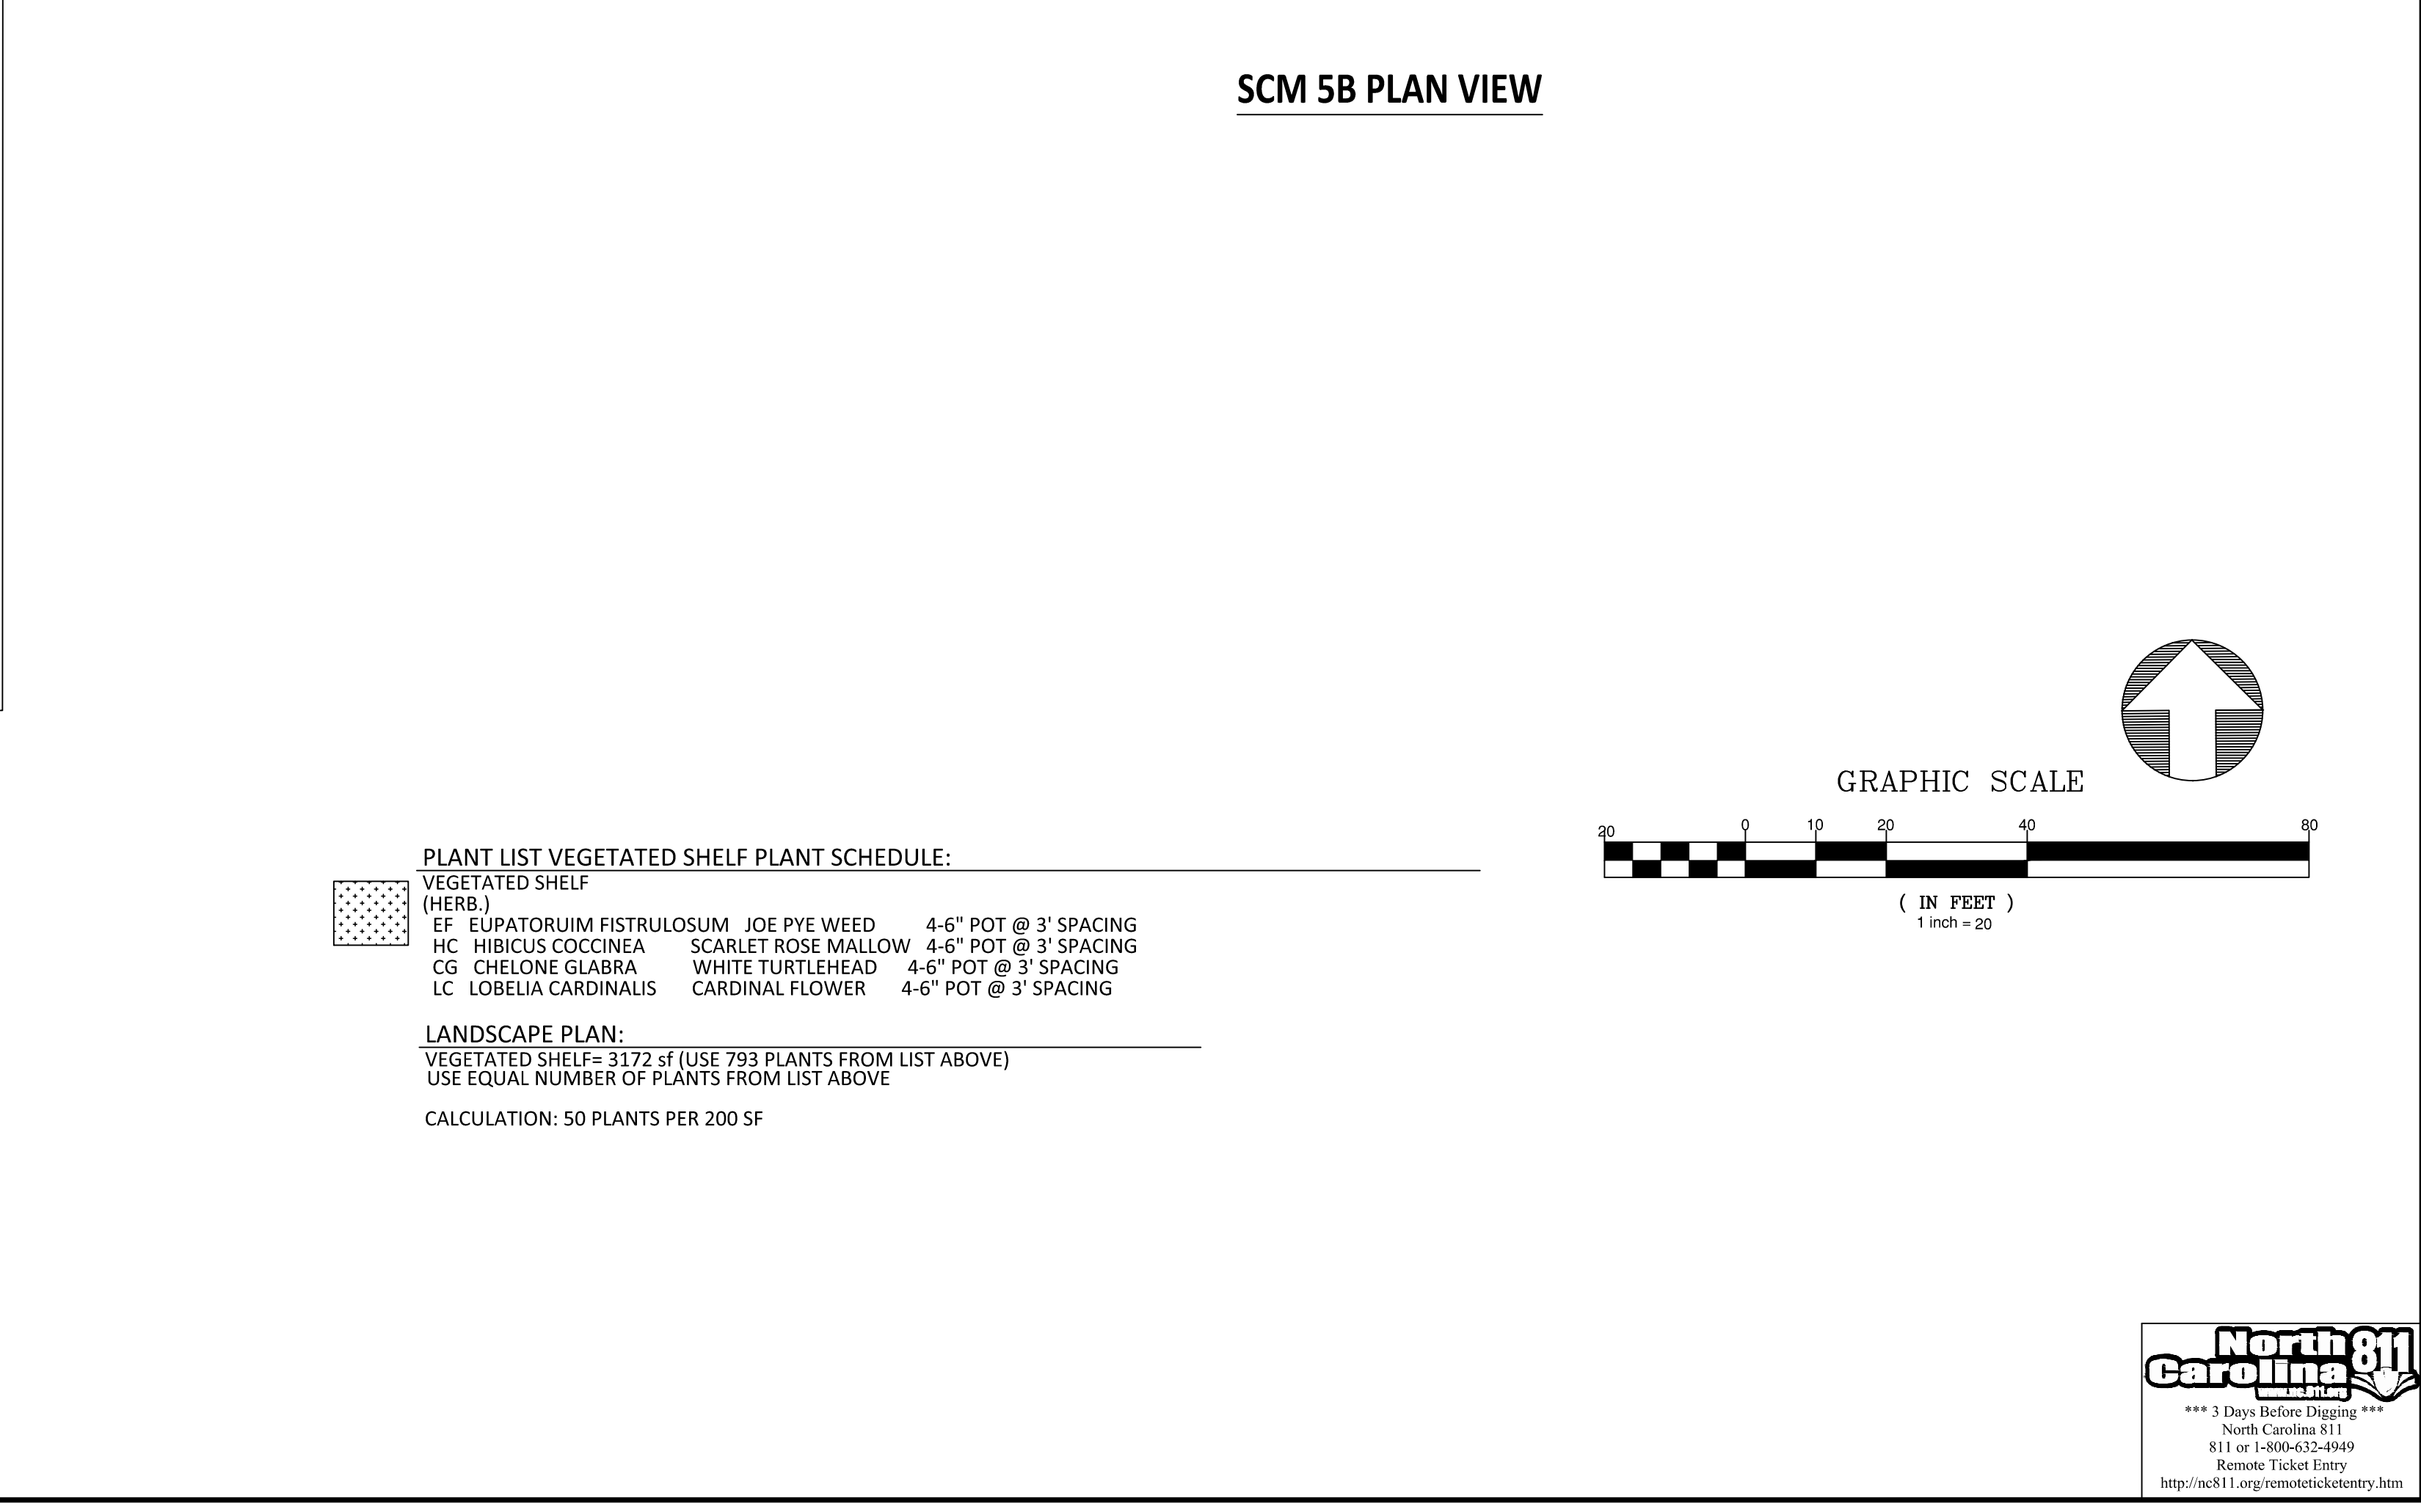
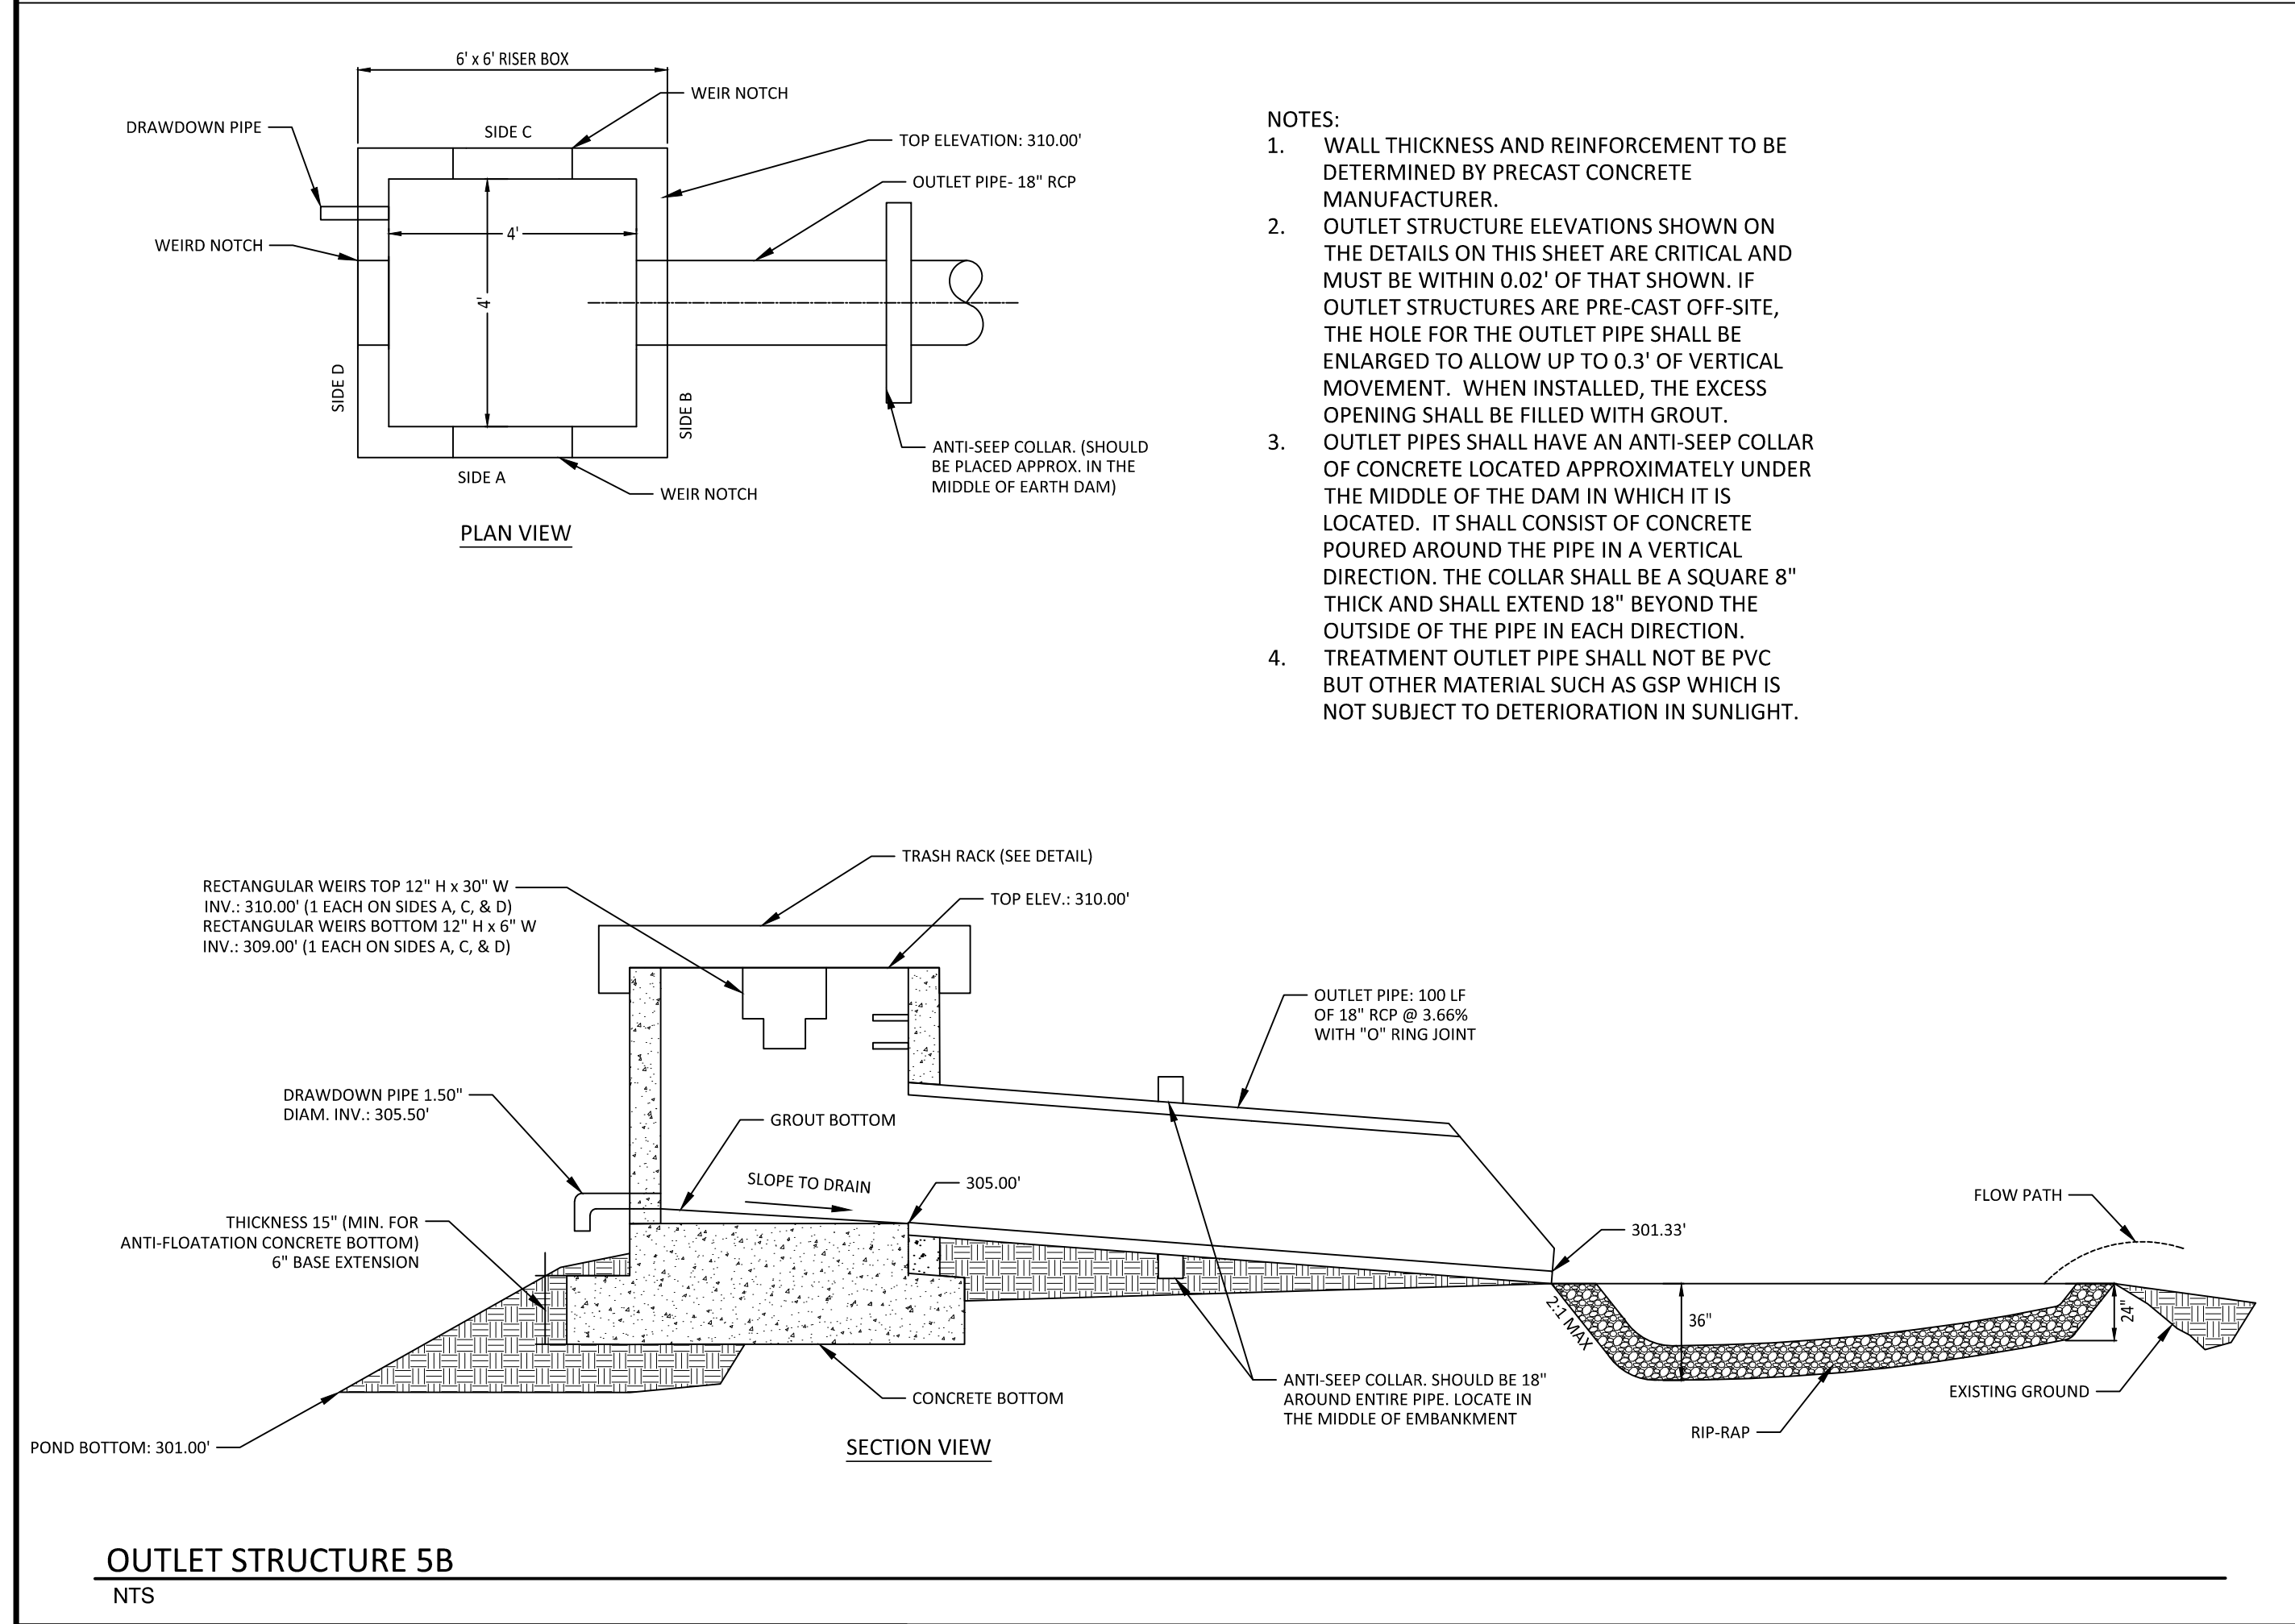


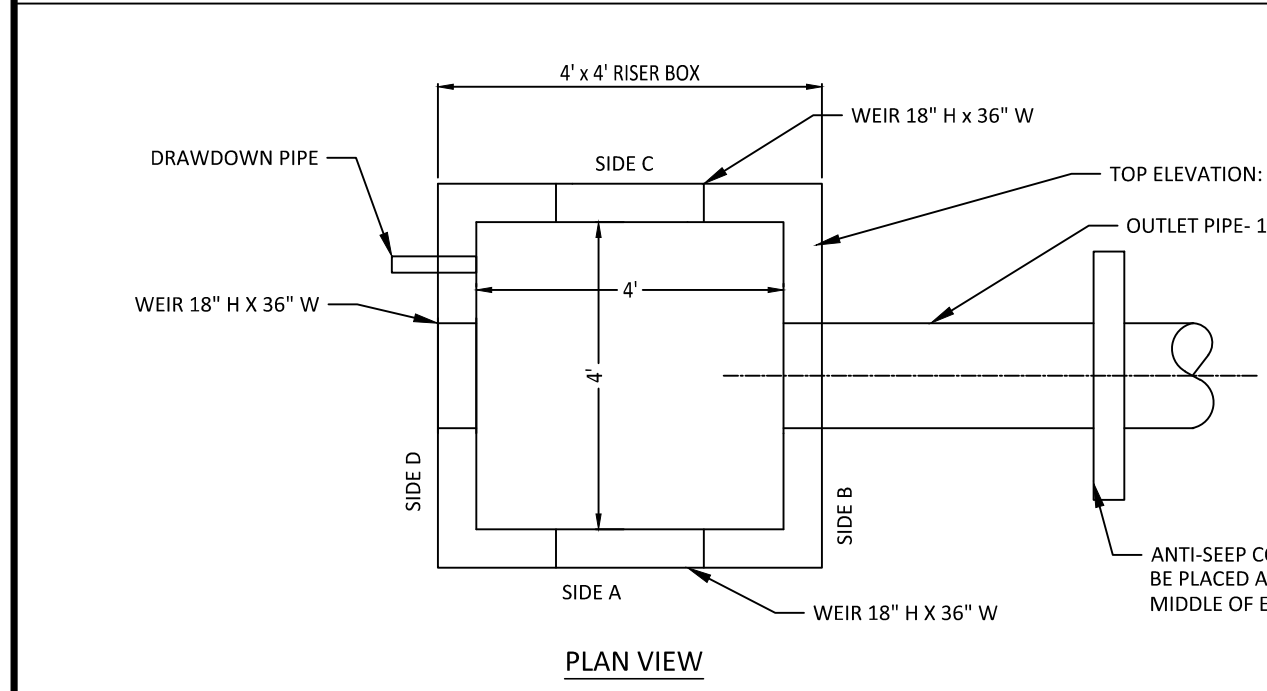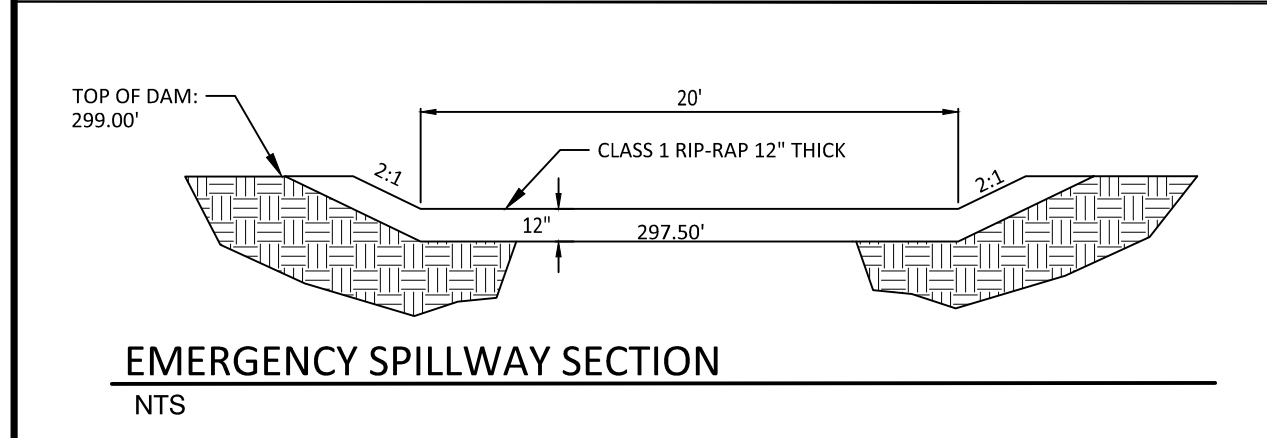


1. WALL THICKNESS AND REINFORCEMENT TO BE DETERMINED BY PRECAST CONCRETE MANUFACTURER.
2. OUTLET STRUCTURE ELEVATIONS SHOWN ON THE DETAILS ON THIS SHEET ARE CRITICAL AND MUST BE WITHIN 0.02' OF THAT SHOWN. IF OUTLET STRUCTURES ARE PRE-CAST OFF-SITE, THE HOLE FOR THE OUTLET PIPE SHALL BE ENLARGED TO ALLOW UP TO 0.3' OF VERTICAL MOVEMENT. WHEN INSTALLED, THE EXCESS CONCRETE SHALL BE FILLED WITH GSP.
3. OUTLET PIPES SHALL HAVE AN ANTI-SEEP COLLAR OF CONCRETE LOCATED APPROXIMATELY UNDER THE MIDDLE OF THE DAM IN WHICH IT IS LOCATED. IT SHALL CONSIST OF CONCRETE POURED AROUND THE PIPE IN A VERTICAL DIRECTION. THE COLLAR SHALL BE A SQUARE 8" ON EACH SIDE AND SHALL BE 12" BY 12" ON THE OUTSIDE OF THE PIPE IN EACH DIRECTION.
4. TREATMENT OUTLET PIPE SHALL NOT BE PVC BUT OTHER MATERIAL SUCH AS GSP WHICH IS NOT SUBJECT TO DETERIORATION IN SUNLIGHT.

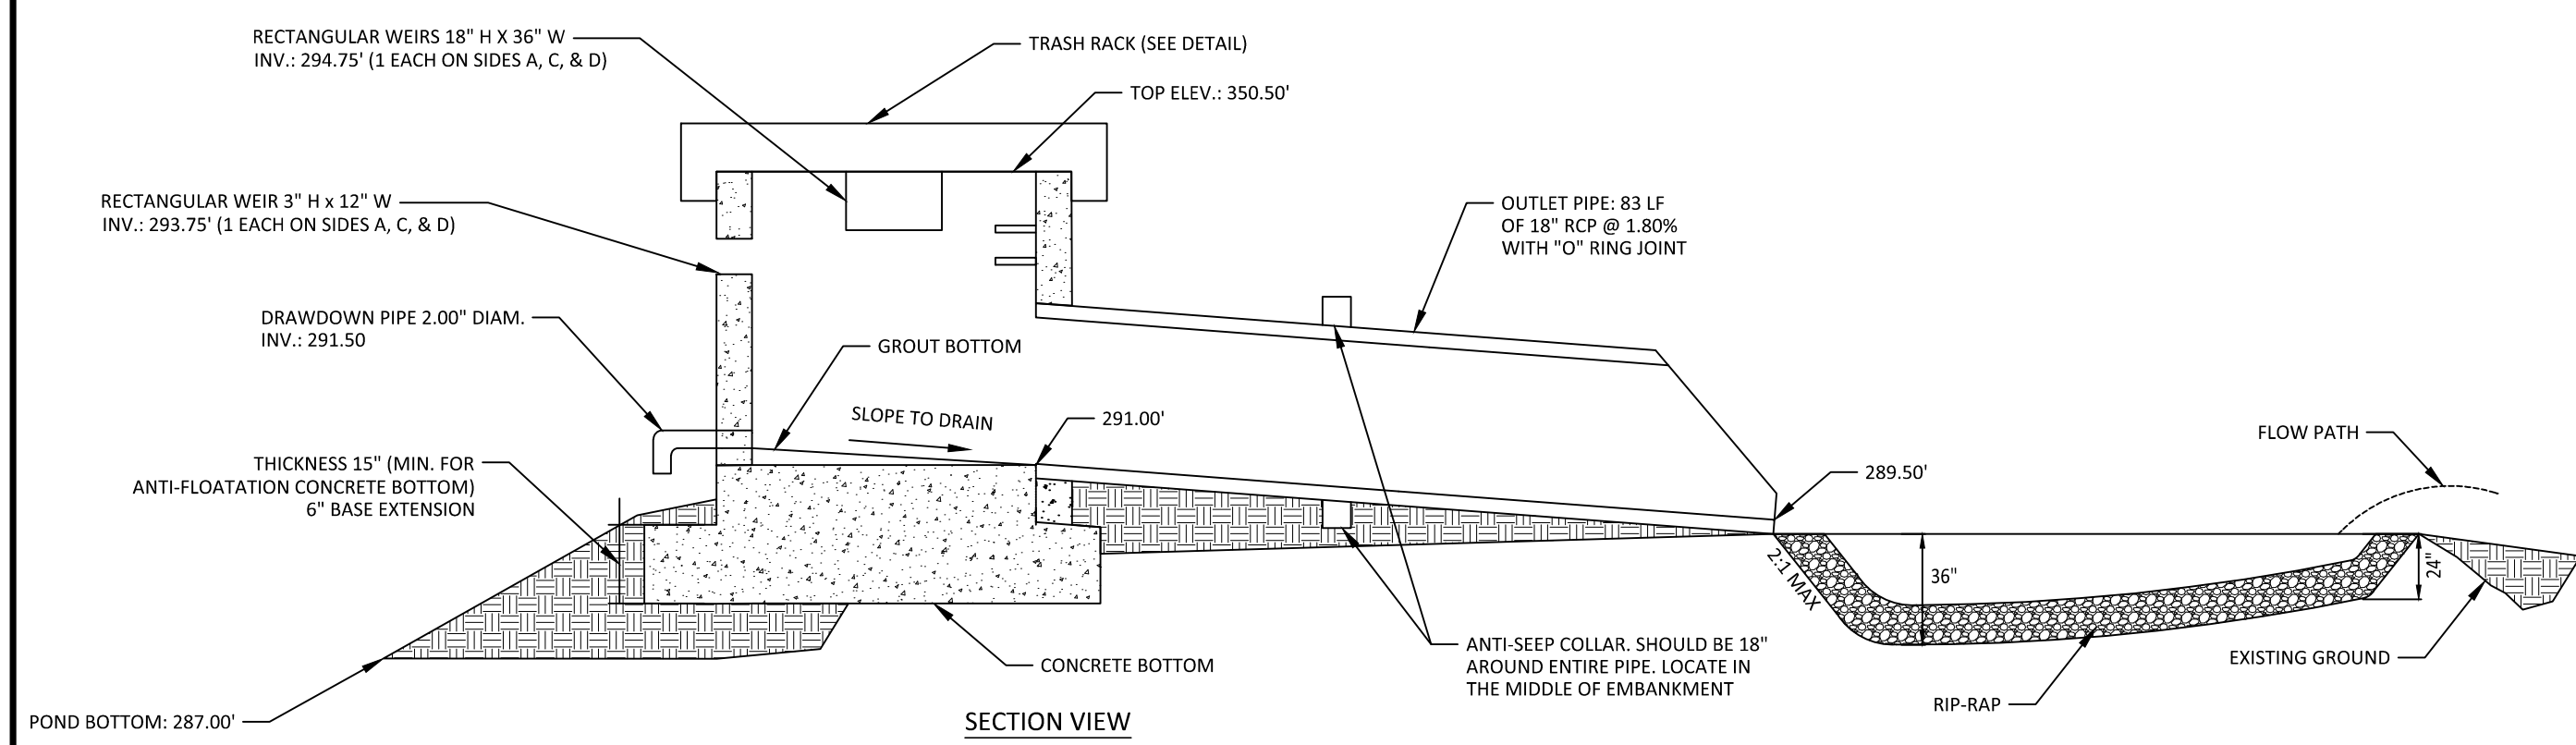

OUTLET STRUCTURE 50
NTS

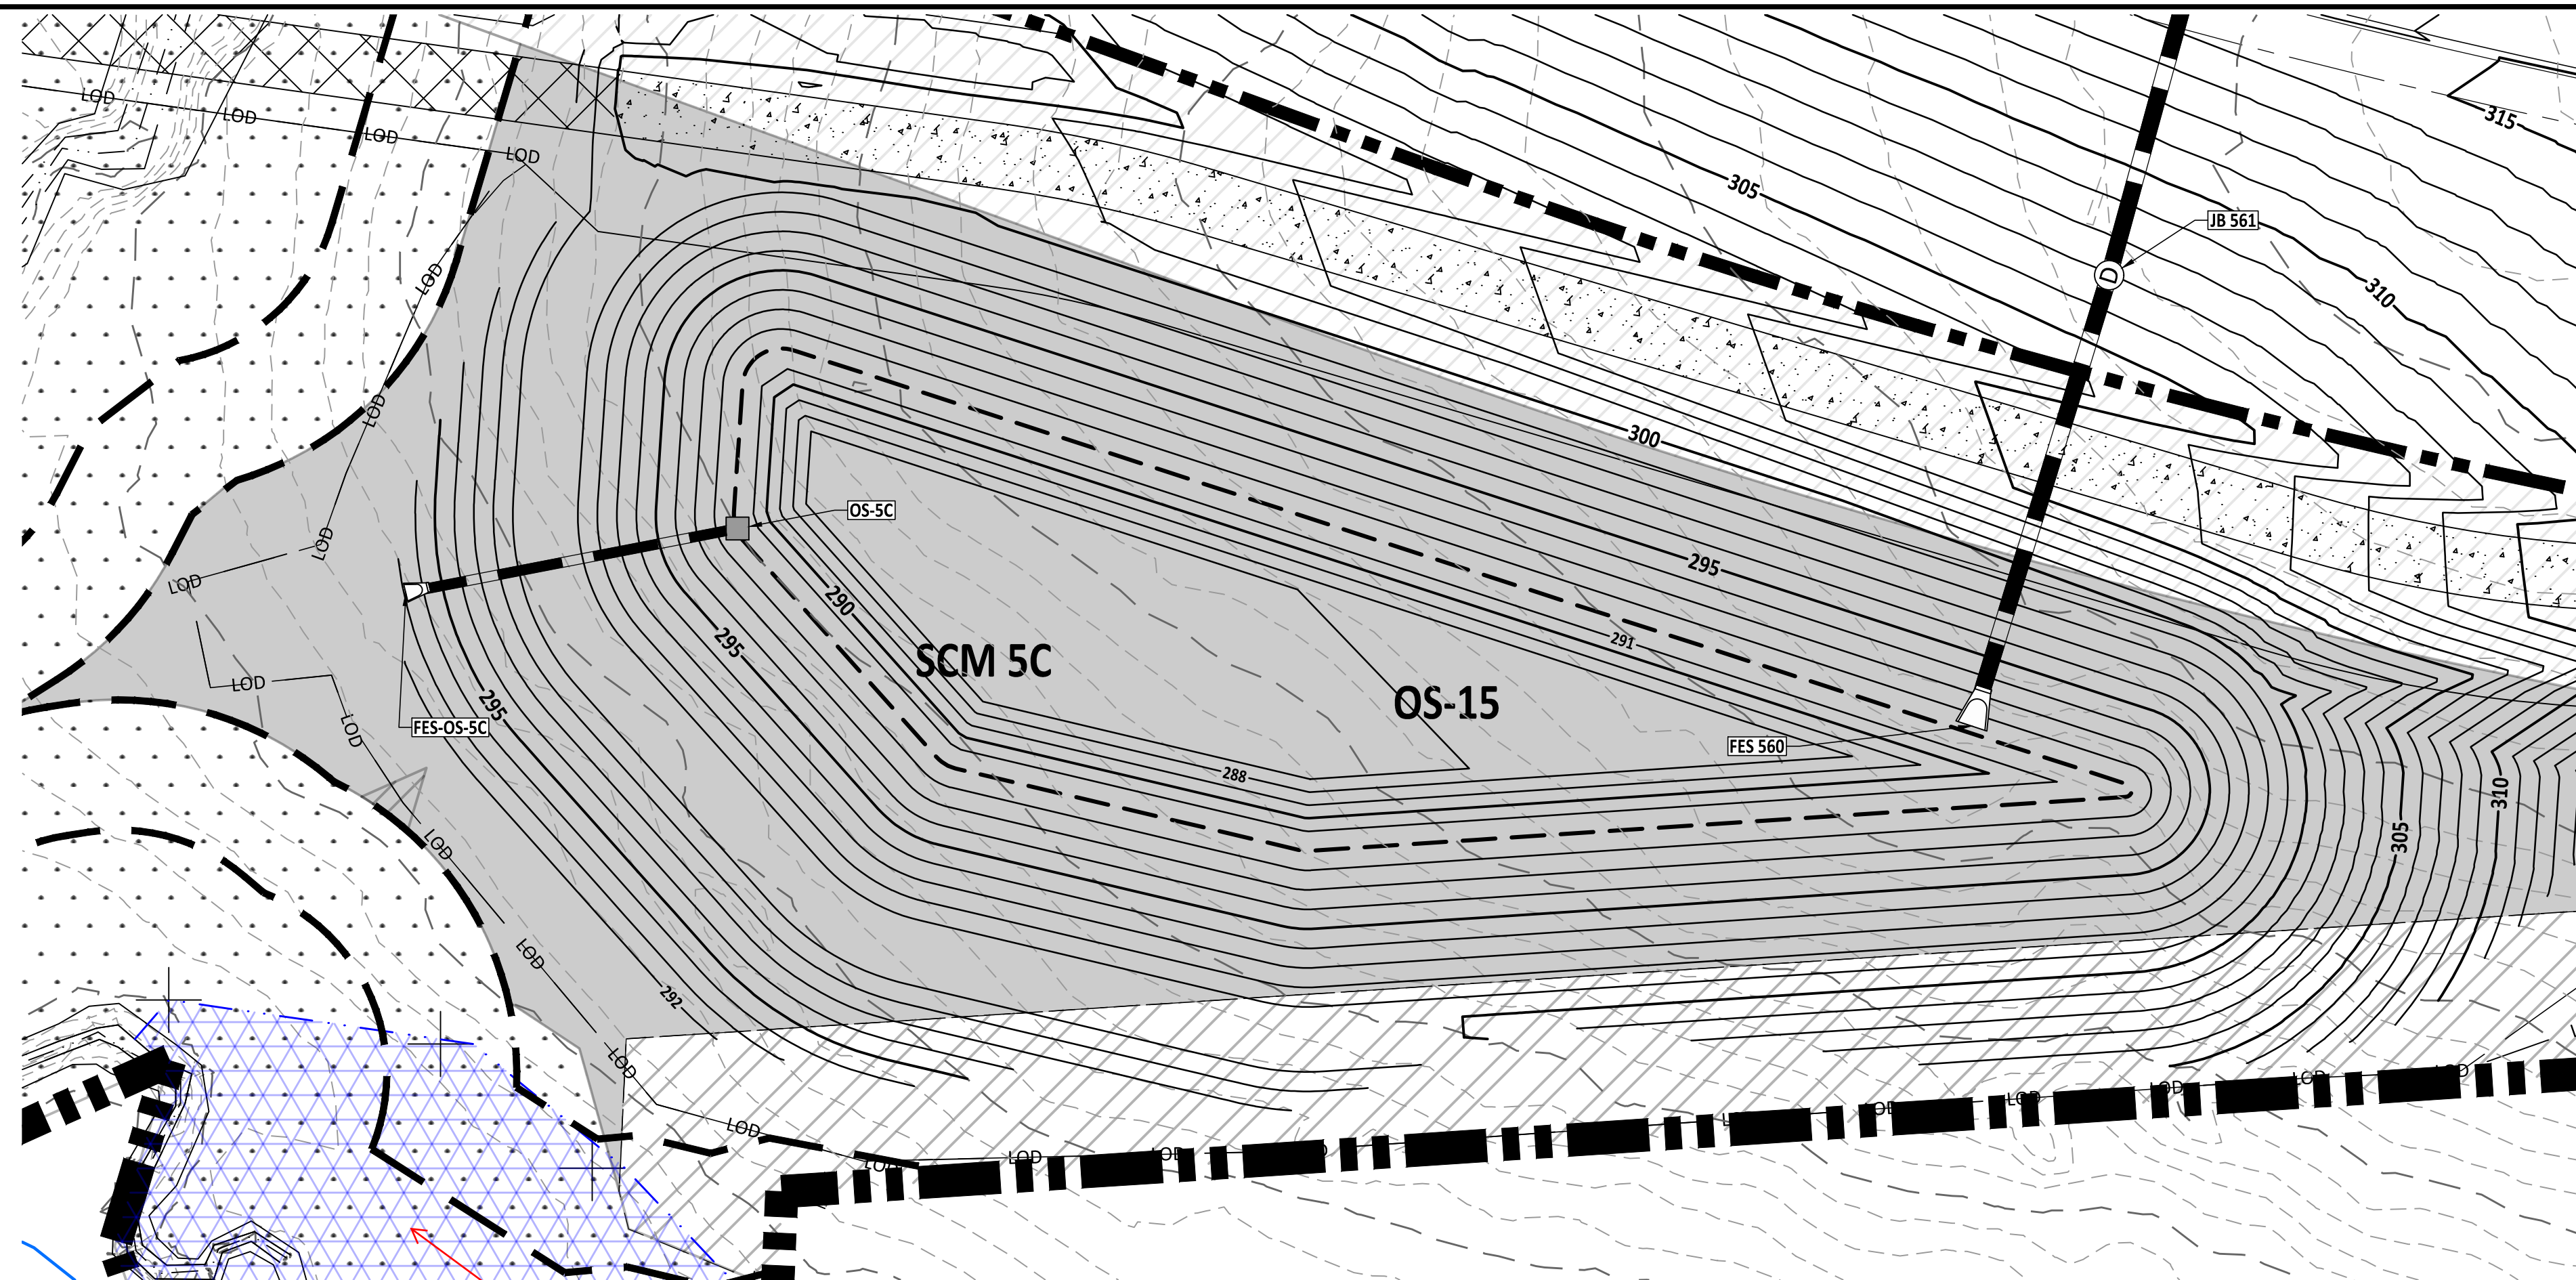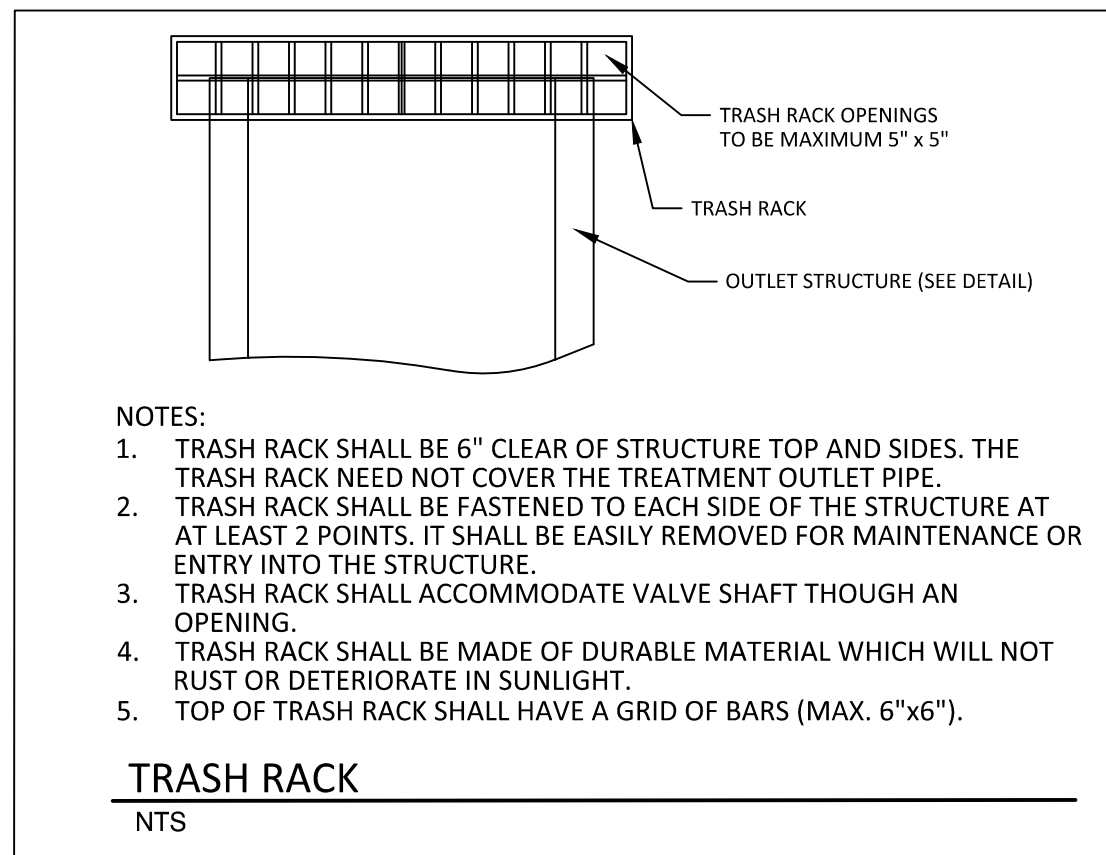

SCM 5C PLAN VIEW

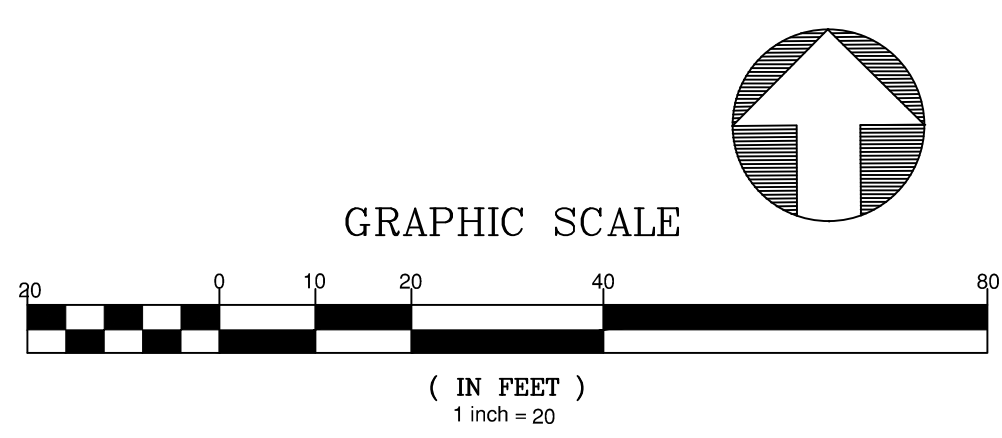


- | PLANT LIST VEGETATED SHELF PLANT SCHEDULE: | | | |
|---|-------------------------|---------------------------------------|-----------------------|
|  | VEGETATED SHELF (HERB.) | | |
| | HF | EUPATORIUM FISTULOSUM JOE PYE WEED | 4-6" POT @ 3' SPACING |
| | HC | HIBISCUS COCCINEA SCARLET ROSE MALLOW | 4-6" POT @ 3' SPACING |
| | CG | CELEBRINE GLABRA WHITE TURTLEHEAD | 4-6" POT @ 3' SPACING |
| | LC | LOBELIA CARDINALIS CARDINAL FLOWER | 4-6" POT @ 3' SPACING |

LANDSCAPE PLAN:

VEGETATED SHELF= 3172 sf (USE 793 PLANTS FROM LIST ABOVE,
USE EQUAL NUMBER OF PLANTS FROM LIST ABOVE

CALCULATION: 50 PLANTS PER 200 SF

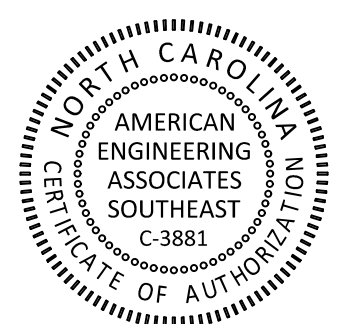

PRELIMINARY

PRELIMINARY

DO NOT USE FOR PROFESSIONAL PURPOSES



FOR INFORMATION, ONLY

[illegible]

STIPULATION FOR REUSE

THIS DRAWING WAS PREPARED FOR USE ON THE SPECIFIC SITE, NAMED HEREIN CONTEMPORANEOUSLY WITH ITS ISSUANCE DATE AS LISTED, HEREON, AND IT IS NOT SUITABLE FOR USE ON A DIFFERENT PROJECT SITE OR AT A LATER TIME. USE OF THIS DRAWING FOR REFERENCE OR EXAMINATION ON ANOTHER PROJECT REQUIRES THE SERVICES OF PROPERLY LICENSED ARCHITECTS AND ENGINEERS. REPRODUCTION OF THIS DRAWING FOR REUSE ON ANOTHER PROJECT IS NOT AUTHORIZED AND MAY BE CONTRARY TO THE LAW.

MERRITT RESERVE

CG408_SCM 5C
DETAIL
ROLESVILLE RD
WAKE COUNTY NC 27312

JOB NUMBER: 23-00

CHECKED BY:

DRAWN BY: DH/RC/SM/GE/MA/LL

DATE: 05/01/20

SHEET TITLE:

CG408 SCM EA

CG408_SCM 30

DETAIL

10. *Journal of the American Medical Association*, 2000; 283: 2689-2694.

SHEET NO. :

SHEET NO.:

■■■■

North Carolina 811
www.nc811.org
*** 3 Days Before Digging ***
North Carolina 811
811 or 1-800-632-4949
Remote Ticket Entry
<http://nc811.org/remoteticketentry.htm>