


\\nas0900\work\projects\11111\phase 5\townhomes\CAD\DWG\sewer\construction\document\CG400-103.dwg 2/25/2025 05:01


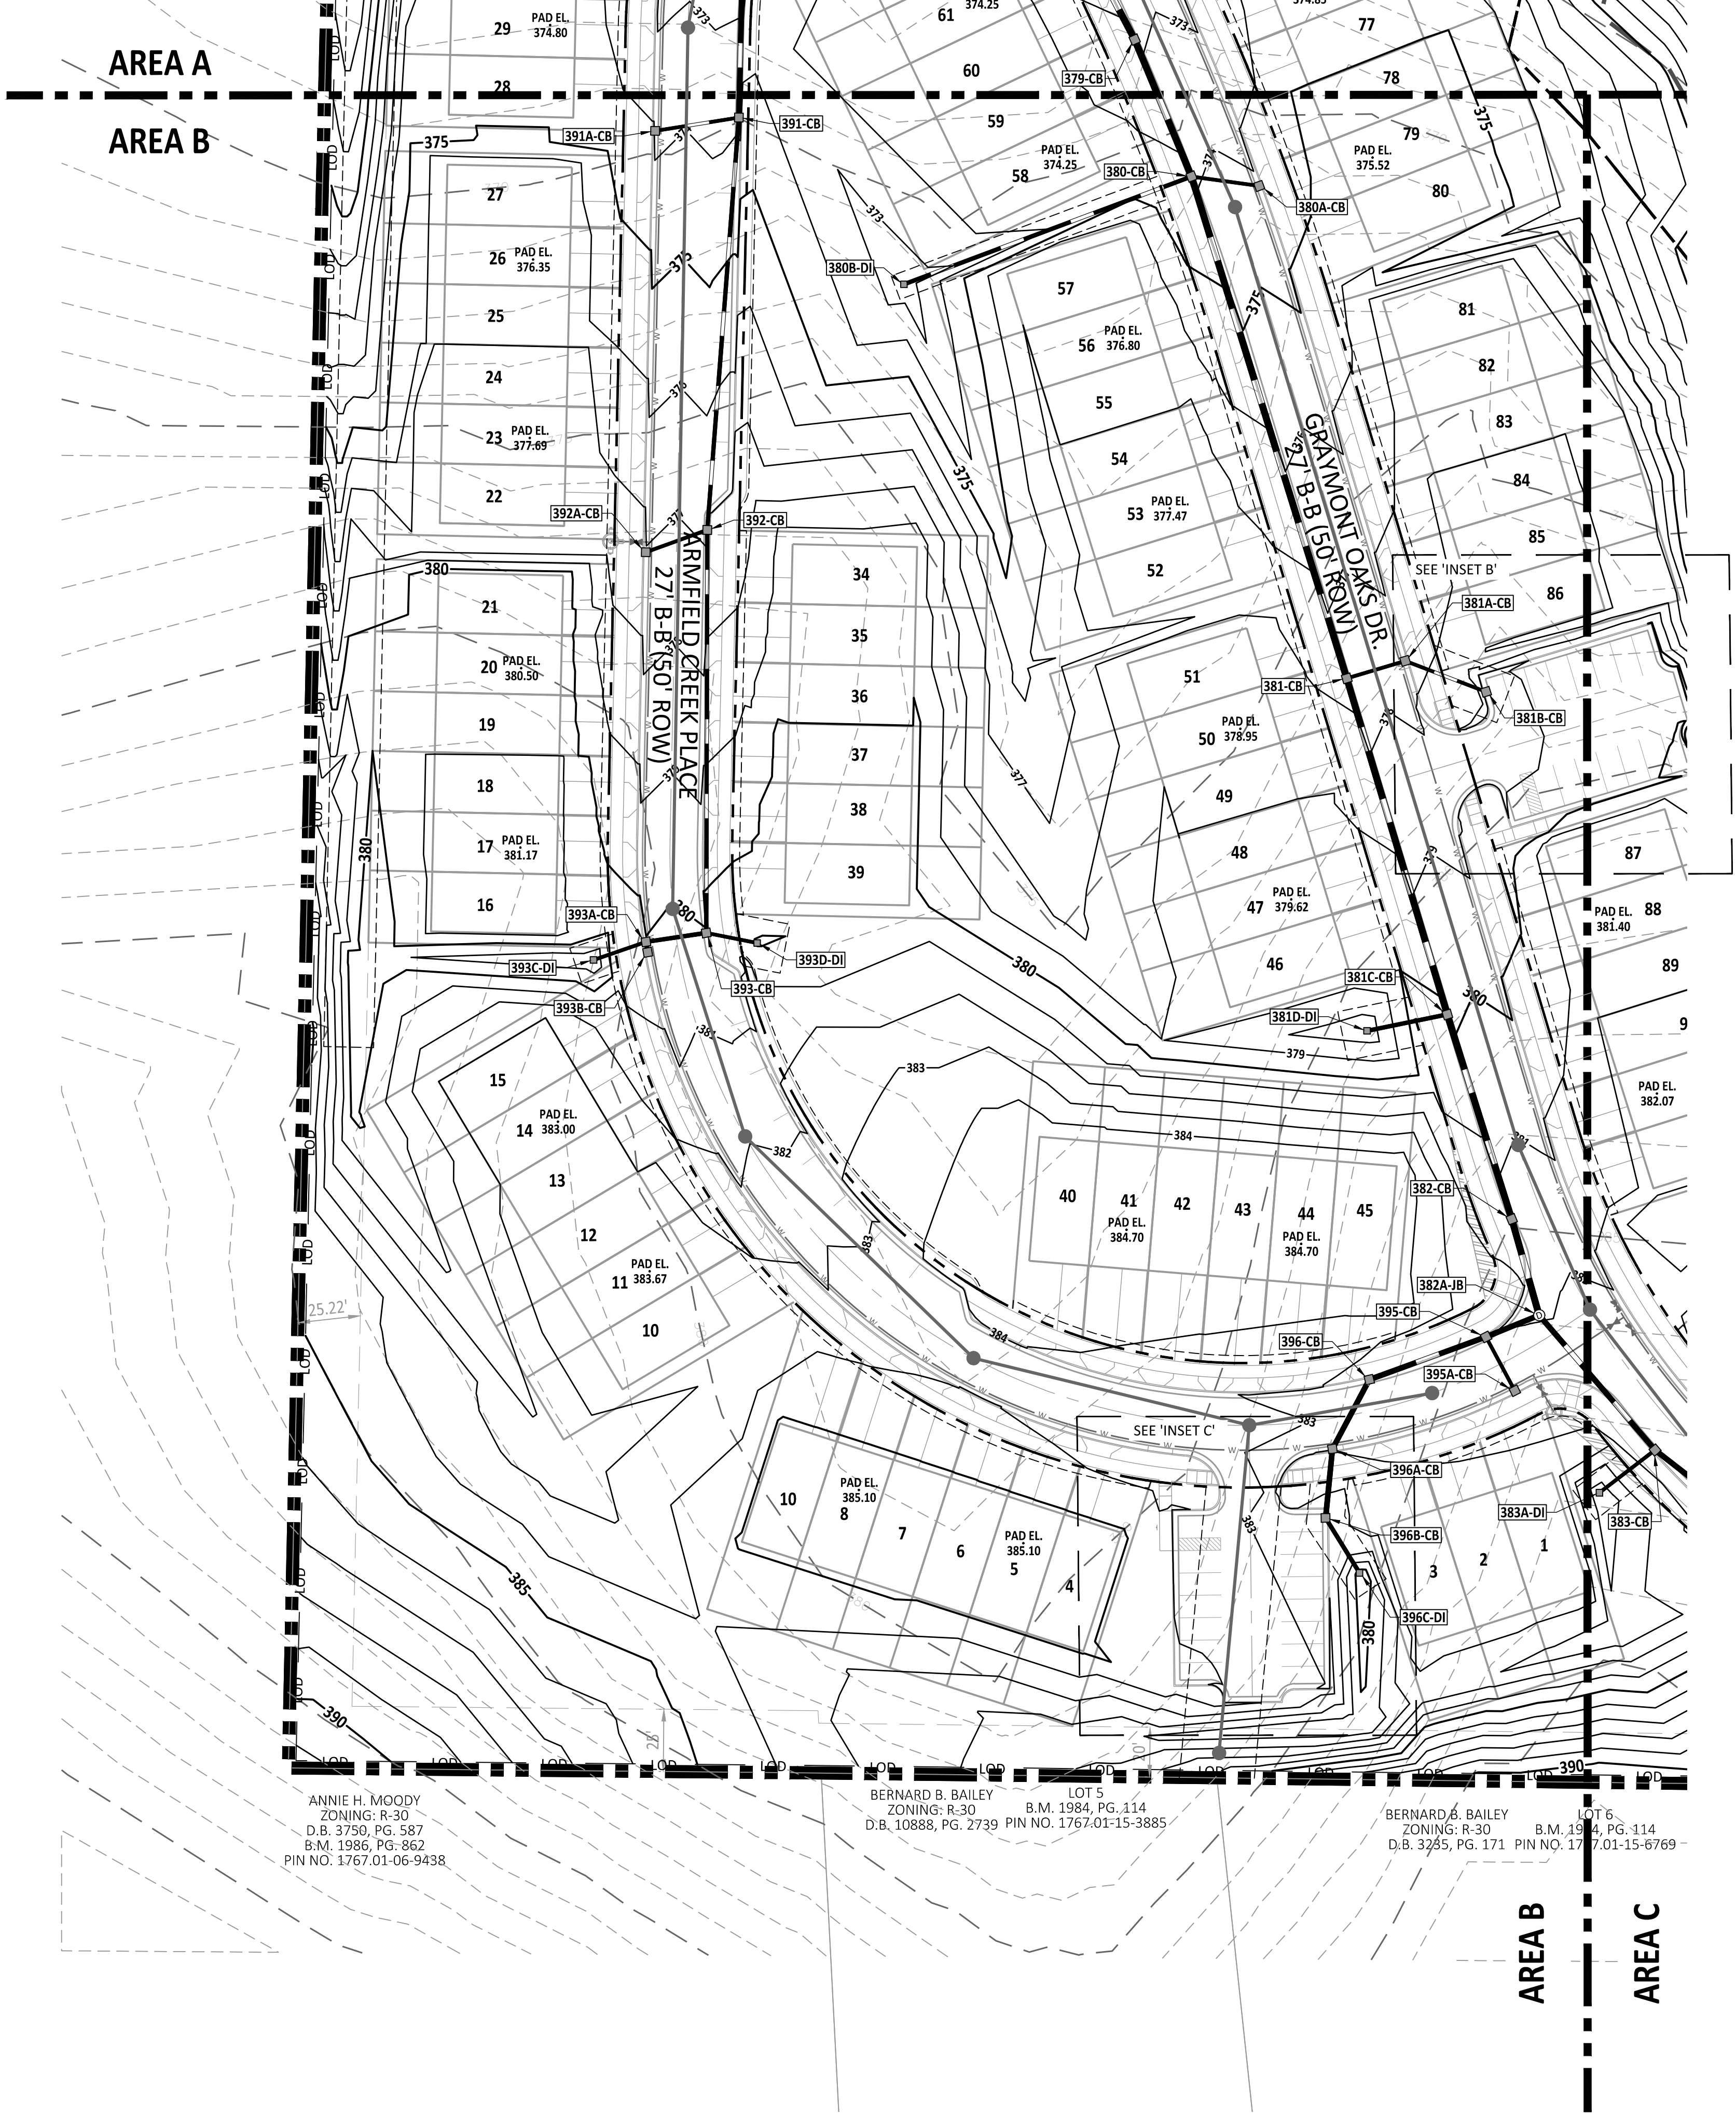


Public
Sewer Collection / Extension System
The City of Raleigh consents to the connection and extension of the City's public sewer system as shown on this plan. The material and construction methods used for this project shall conform to the standards and specifications of the City's Public Utilities Handbook.

City of Raleigh
Public Utilities Department Permit # 5-5618

Public
Water Distribution / Extension System
The City of Raleigh consents to the connection and extension of the City's public water system as shown on this plan. The material and construction methods used for this project shall conform to the standards and specifications of the City's Public Utilities Handbook.

City of Raleigh
Public Utilities Department Permit # W-4214

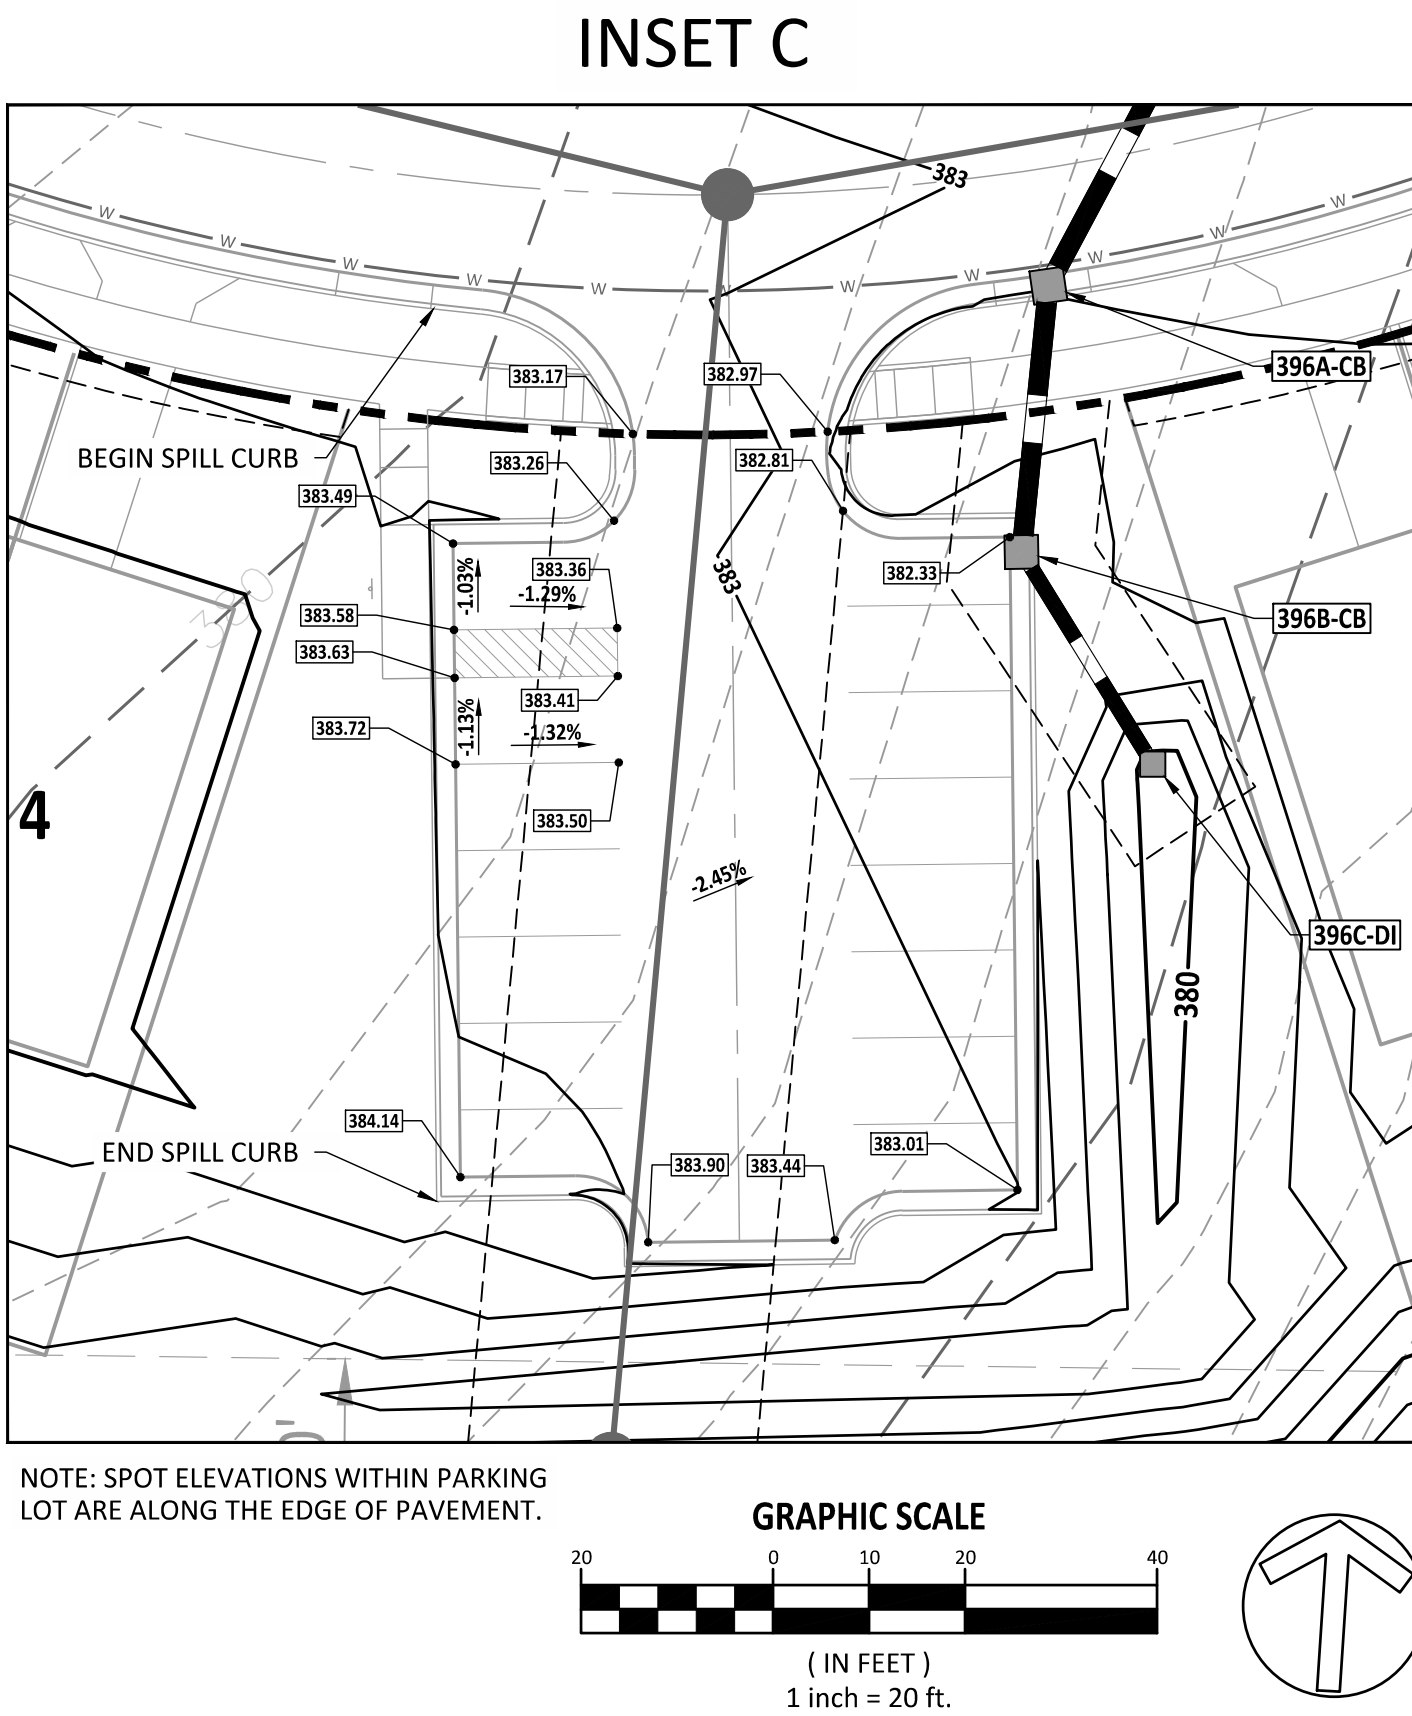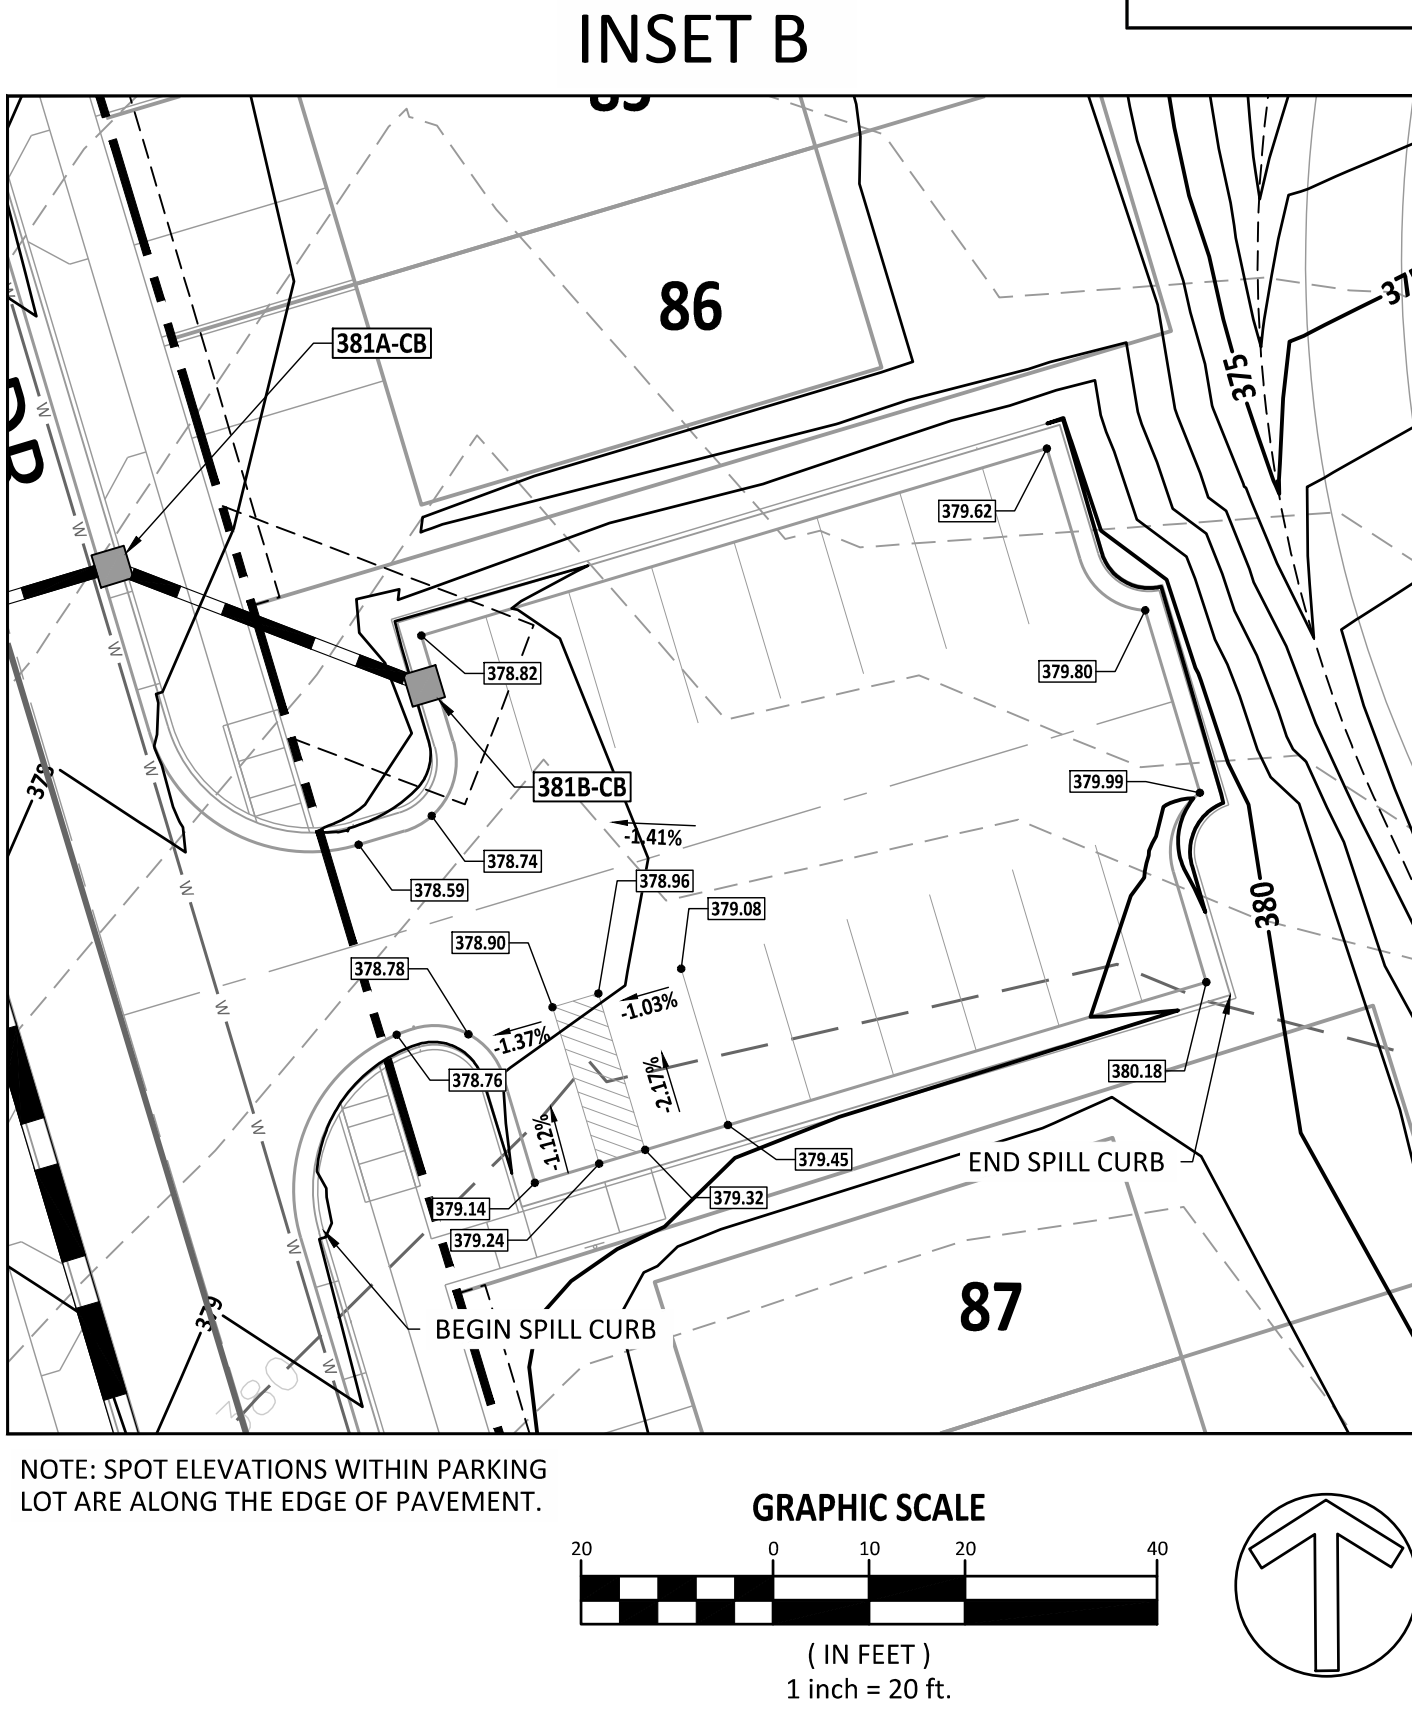

SITE LEGEND	
	100 YR FLOODLINE
	PROPERTY BOUNDARY/PHASE LINE
	2' BUILDING RESTRICTION LINE
	50' NEUSE RIVER BUFFER
	PROPOSED SURFACE WATER LEVEL
	RIGHT-OF-WAY
	LIMITS OF DISTURBANCE
	LOT LINE
	WETLANDS
	AMENITY AREA
	CONCRETE
	10' CURB TRANSITION

AMERICAN
Engineering
American Engineering Associates - Southeast, P.A.
4020 Westchase Boulevard, Suite 450
Raleigh, NC 27607
919-469-1101

Digitally signed by
Jacob Klein
Date: 2025.05.01
12:25:04-0400

PROFESSIONAL ENGINEER
NORTH CAROLINA
LICENSE NO. 36528
JACOB P. KLEIN

FOR INFORMATION, ONLY

NO.	DATE	REVISION:
1	12/23/2024	CID SUBMITTAL #1

STIPULATION FOR REUSE

THIS DRAWING WAS PREPARED FOR USE ON THE SPECIFIC SITE, NAMED HEREON, CONTEMPORANEOUSLY WITH ITS ISSUE DATE AS LISTED, HEREON, AND IT IS NOT SUITABLE FOR USE ON A DIFFERENT PROJECT SITE OR AT A LATER TIME. USE OF THIS DRAWING FOR REFERENCE OR EXAMPLE ON ANOTHER PROJECT REQUIRES THE SERVICES OF PROPERLY LICENSED ARCHITECTS AND ENGINEERS. REPRODUCTION OF THIS DRAWING FOR REUSE ON ANOTHER PROJECT IS NOT AUTHORIZED AND MAY BE CONTRARY TO THE LAW.


KALAS FALLS
PHASE 5
CONSTRUCTION INFRASTRUCTURE
DOCUMENTS
CID-25-01
TOWN OF ROLESVILLE,
WAKE COUNTY, NC

JOB NUMBER:	R180115
CHECKED BY:	JK
DRAWN BY:	GE, RC
DATE:	05-01-2025

SHEET TITLE:
GRADING & DRAINAGE
AREA B

SHEET NO.:
CG401

North Carolina 811
*** 3 Days Before Digging ***
North Carolina 811
811 or 1-800-632-4949
Remote Ticket Entry
<http://nc811.org/remoteticketentry.htm>

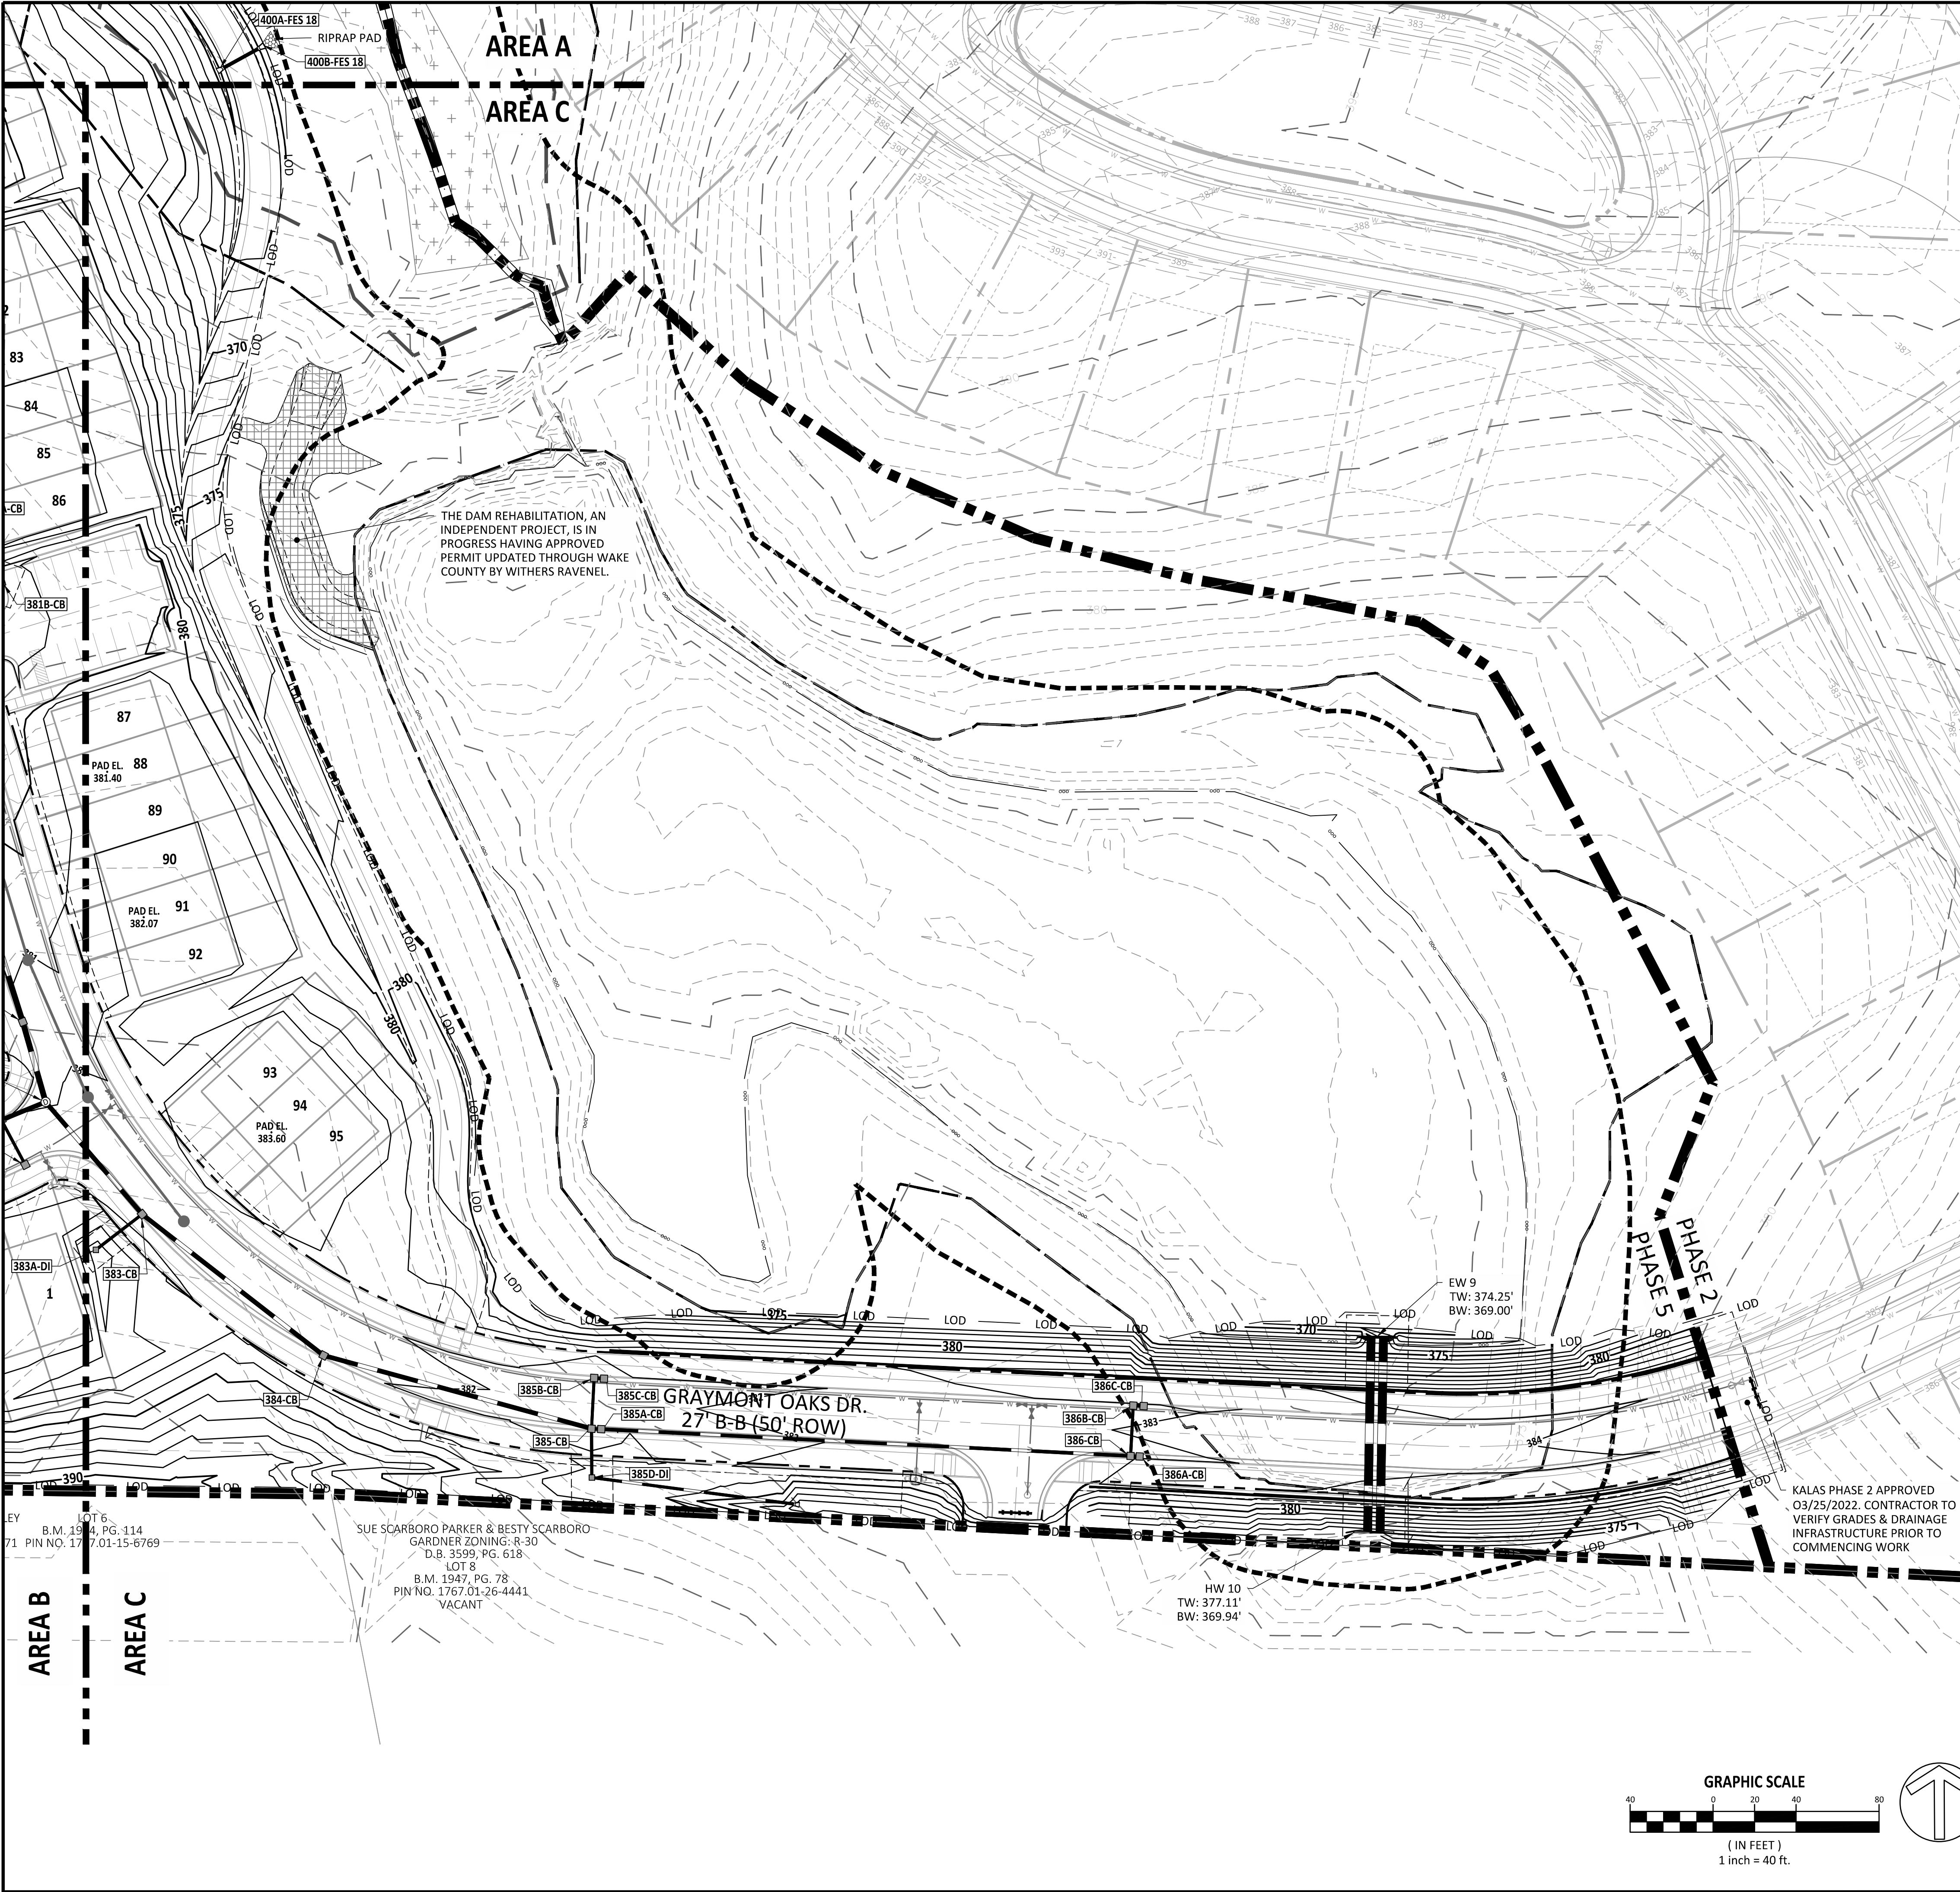



Public
Sewer Collection / Extension System
The City of Raleigh consents to the connection and extension of the City's public sewer system as shown on this plan. The material and Construction methods used for this project shall conform to the standards and specifications of the City's Public Utilities Handbook.

City of Raleigh
Public Utilities Department Permit # 5-5618

Public
Water Distribution / Extension System
The City of Raleigh consents to the connection and extension of the City's public water system as shown on this plan. The material and Construction methods used for this project shall conform to the standards and specifications of the City's Public Utilities Handbook.

City of Raleigh
Public Utilities Department Permit # W-4214

SITE LEGEND	
	100 YR FLOODLINE
	PROPERTY BOUNDARY/PHASE LINE
	2' BUILDING RESTRICTION LINE
	50' NEUSE RIVER BUFFER
	PROPOSED SURFACE WATER LEVEL
	RIGHT-OF-WAY
	LIMITS OF DISTURBANCE
	LOT LINE
	WETLANDS
	AMENITY AREA
	CONCRETE
	10' CURB TRANSITION

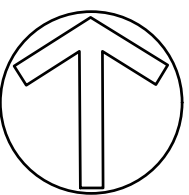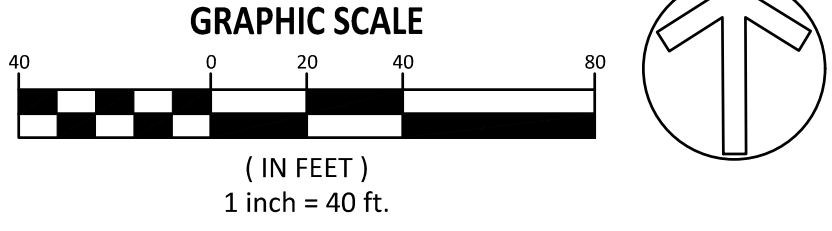

AMERICAN
Engineering
American Engineering Associates - Southeast, P.A.
4020 Westchase Boulevard, Suite 450
Raleigh, NC 27607
919-469-1101

PROFESSIONAL SEAL
NORTH CAROLINA
AMERICAN ENGINEERING ASSOCIATES SOUTHEAST
C-3881
JAKOB KLEIN
P.E.
10/25/2022
12/23/2024
FOR INFORMATION, ONLY


NO.	DATE	REVISION:
1	12/23/2024	CID-SUBMITTAL #1

STIPULATION FOR REUSE
THIS DRAWING WAS PREPARED FOR USE ON THE SPECIFIC SITE, NAMED HEREON, CONTEMPORANEOUSLY WITH ITS ISSUE DATE AS LISTED, HEREON, AND IT IS NOT SUITABLE FOR USE ON A DIFFERENT PROJECT SITE OR AT A LATER TIME. USE OF THIS DRAWING FOR REFERENCE OR EXAMPLE ON ANOTHER PROJECT REQUIRES THE SERVICES OF PROPERLY LICENSED ARCHITECTS AND ENGINEERS. REPRODUCTION OF THIS DRAWING FOR REUSE ON ANOTHER PROJECT IS NOT AUTHORIZED AND MAY BE CONTRARY TO THE LAW.

KALAS FALLS
PHASE 5
CONSTRUCTION INFRASTRUCTURE
DOCUMENTS
CID-25-01
TOWN OF ROLESVILLE,
WAKE COUNTY, NC

JOB NUMBER: R180115
CHECKED BY: JK
DRAWN BY: GE, RC
DATE: 05-01-2025
SHEET TITLE:
**GRADING & DRAINAGE
AREA C**
SHEET NO.:
CG402

North 811
*** 3 Days Before Digging ***
North Carolina 811
811 or 1-800-452-4949
Remote Ticket Entry
<http://nc811.org/remoteticketentry.htm>

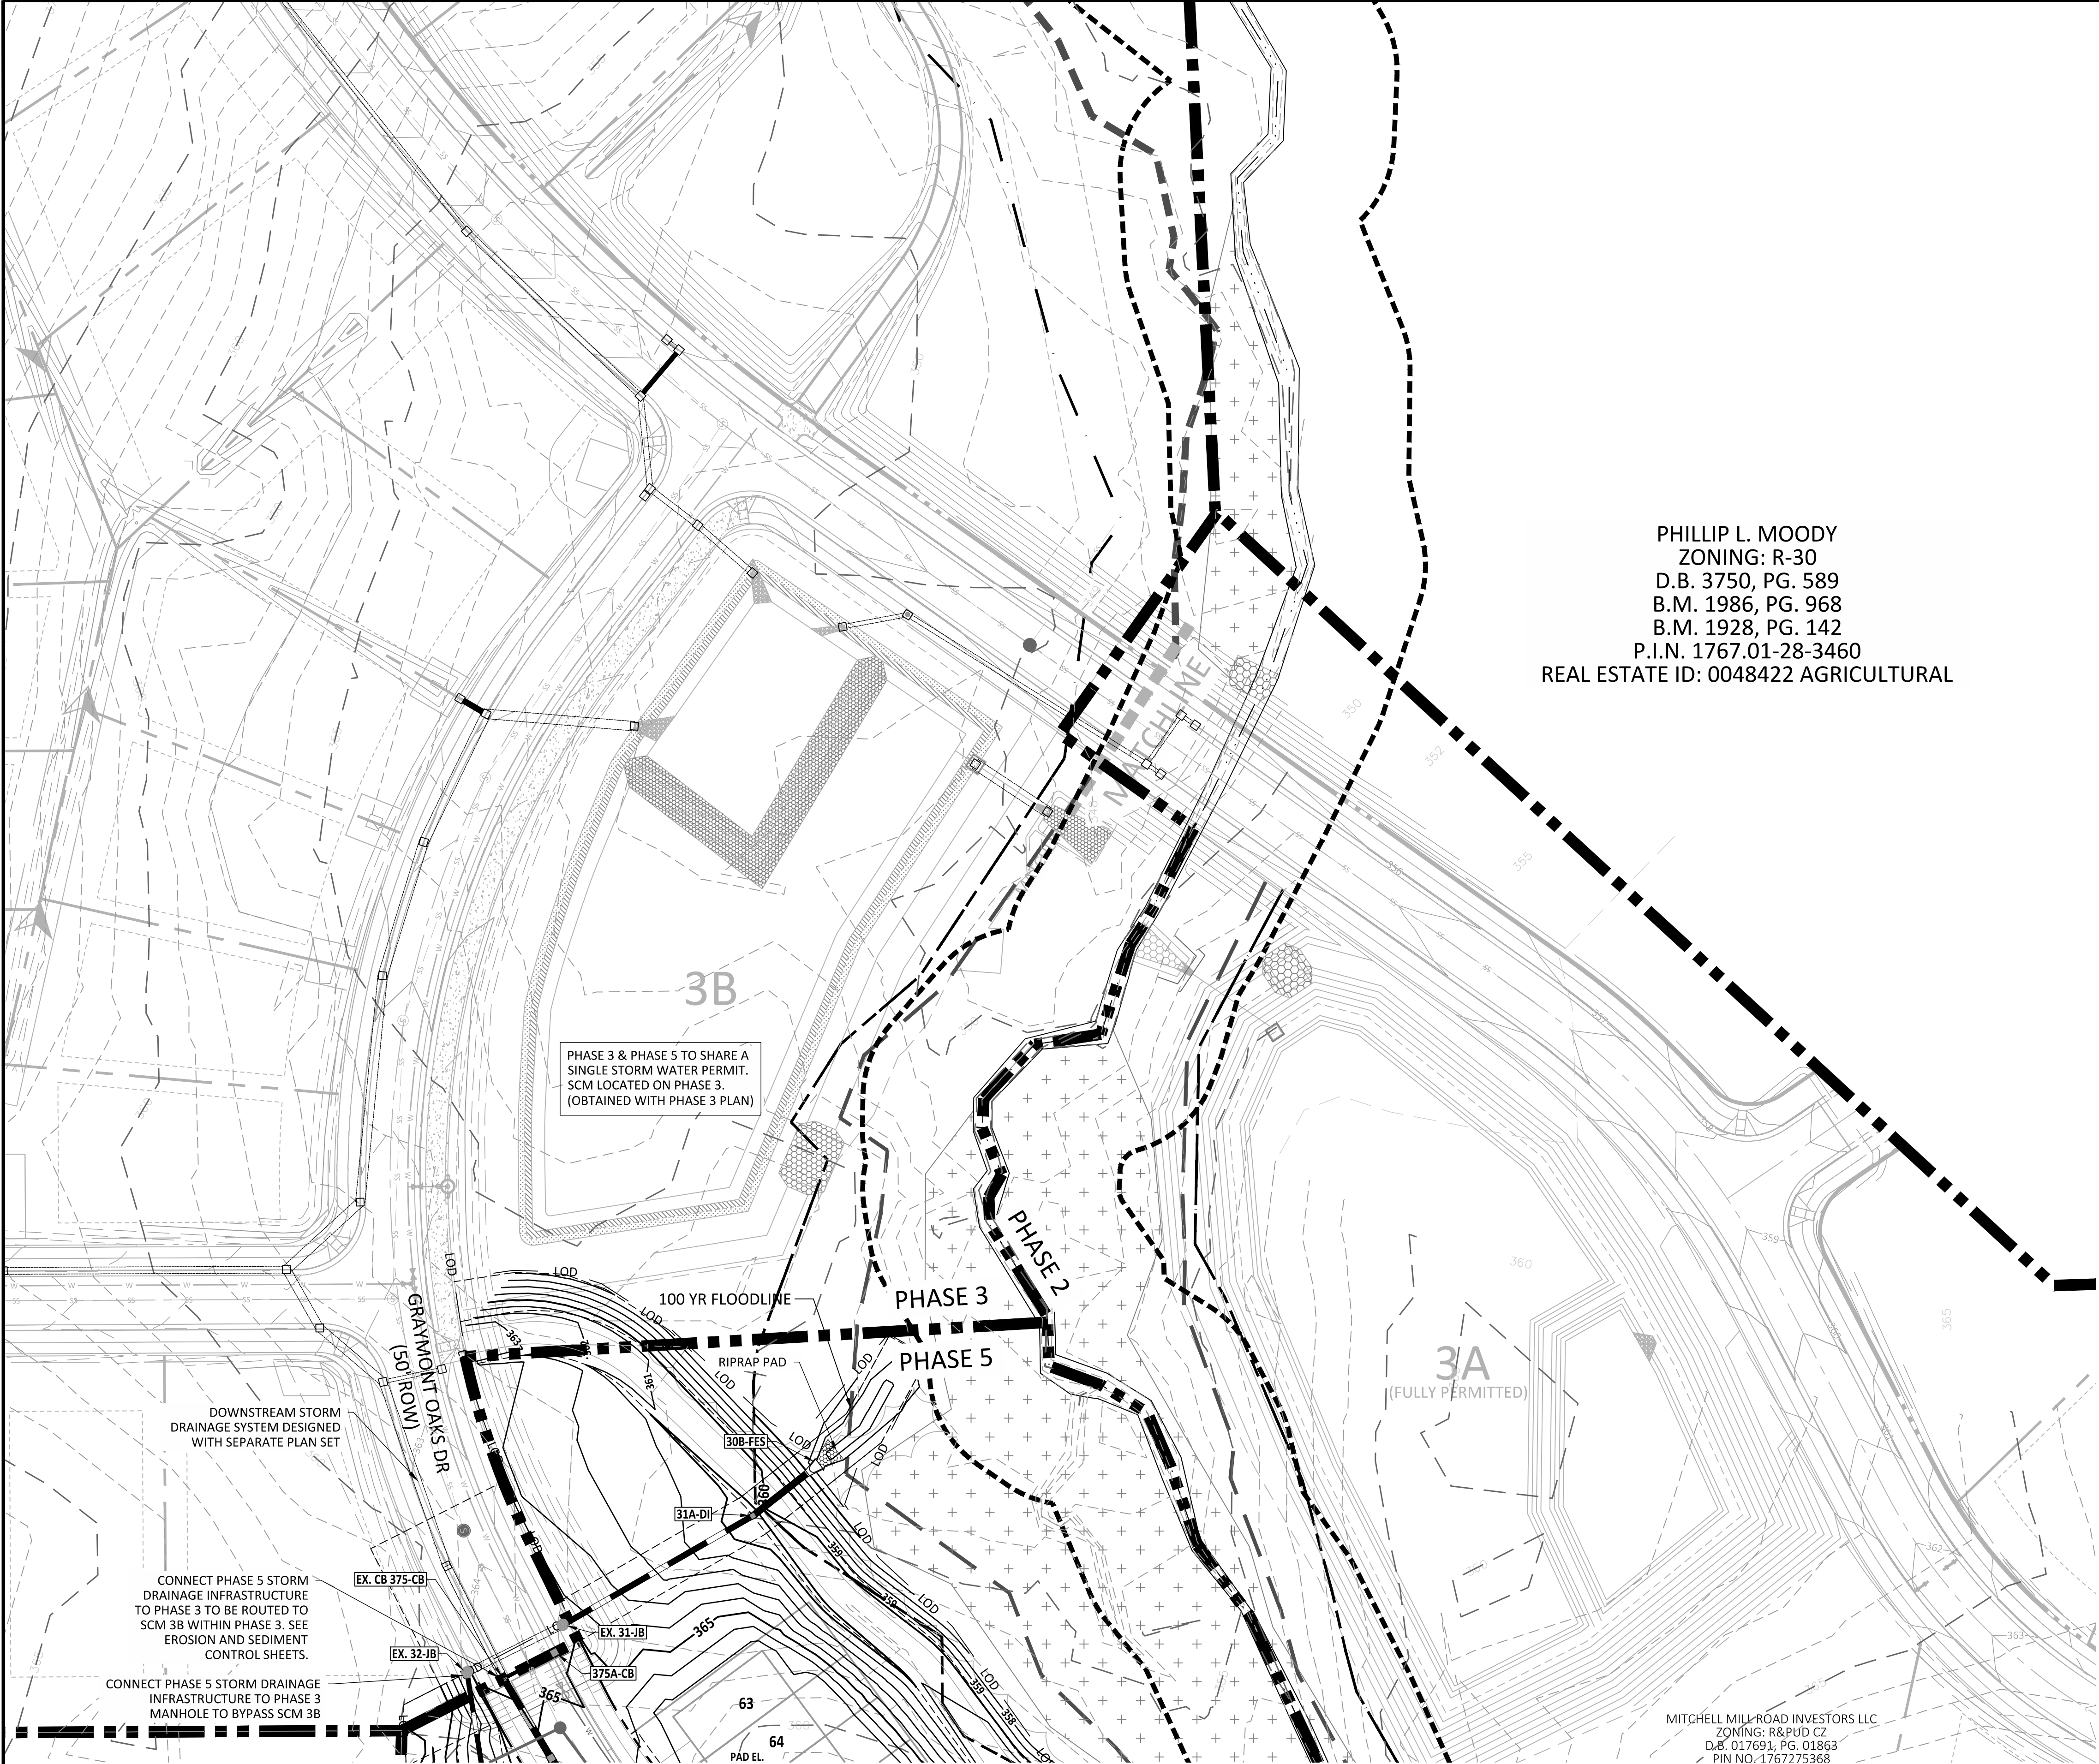


PHILLIP L. MOODY
ZONING: R-30
D.B. 3750, PG. 589
B.M. 1986, PG. 968
B.M. 1928, PG. 142
P.I.N. 1767.01-28-3460
REAL ESTATE ID: 0048422 AGRICULTURAL

Public
Sewer Collection / Extension System
The City of Raleigh consents to the connection and extension of the City's public sewer system as shown on this plan. The material and Construction methods used for this project shall conform to the standards and specifications of the City's Public Utilities Handbook.
City of Raleigh
Public Utilities Department Permit # 5-5618

Public
Water Distribution / Extension System
The City of Raleigh consents to the connection and extension of the City's public water system as shown on this plan. The material and Construction methods used for this project shall conform to the standards and specifications of the City's Public Utilities Handbook.
City of Raleigh
Public Utilities Department Permit # W-4214

SITE LEGEND	
	100 YR FLOODLINE
	PROPERTY BOUNDARY/PHASE LINE
	2' BUILDING RESTRICTION LINE
	50' NEUSE RIVER BUFFER
	PROPOSED SURFACE WATER LEVEL
	RIGHT-OF-WAY
	LIMITS OF DISTURBANCE
	LOT LINE
	WETLANDS
	AMENITY AREA
	CONCRETE
	10' CURB TRANSITION

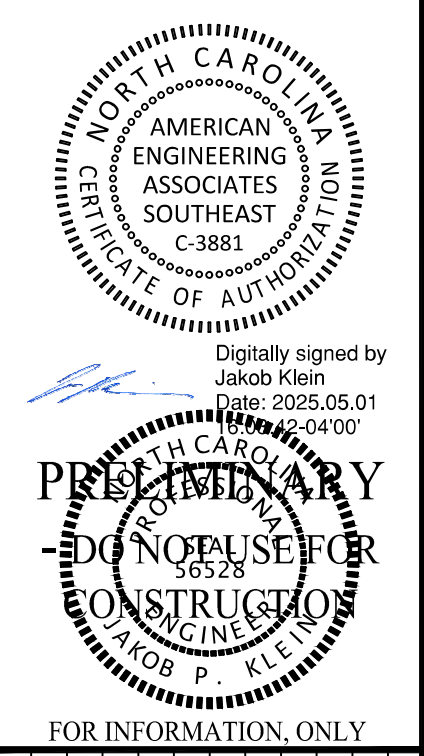

NO.	DATE	REVISION	CID SUBMITTAL #1
1	12/23/2024		



STIPULATION FOR REUSE
THIS DRAWING WAS PREPARED FOR USE ON THE SPECIFIC SITE, NAMED HEREON, CONTEMPORANEOUSLY WITH ITS ISSUE DATE AS LISTED, HEREON, AND IT IS NOT SUITABLE FOR USE ON A DIFFERENT PROJECT SITE OR AT A LATER TIME. USE OF THIS DRAWING FOR REFERENCE OR EXAMPLE ON ANOTHER PROJECT REQUIRES THE SERVICES OF PROPERLY LICENSED ARCHITECTS AND ENGINEERS. REPRODUCTION OF THIS DRAWING FOR REUSE ON ANOTHER PROJECT IS NOT AUTHORIZED AND MAY BE CONTRARY TO THE LAW.


KALAS FALLS
PHASE 5
CONSTRUCTION INFRASTRUCTURE
DOCUMENTS
CID-25-01
TOWN OF ROLESVILLE,
WAKE COUNTY, NC

JOB NUMBER: R180115
CHECKED BY: JK
DRAWN BY: GE, RC
DATE: 05-01-2025


SHEET TITLE:
**GRADING &
DRAINAGE
OFFSITE**

SHEET NO.:
CG403

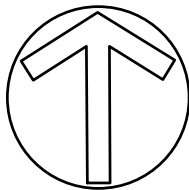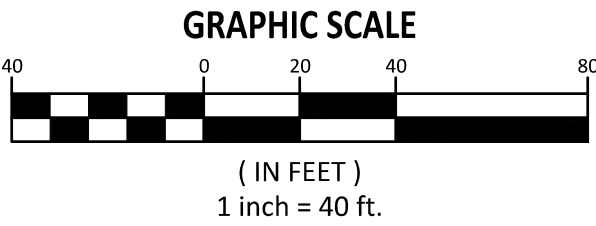


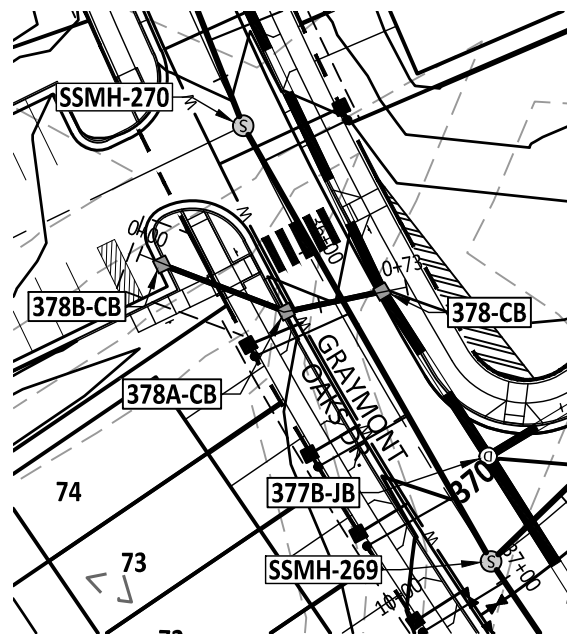


378B-CB TO 378-CB PLAN

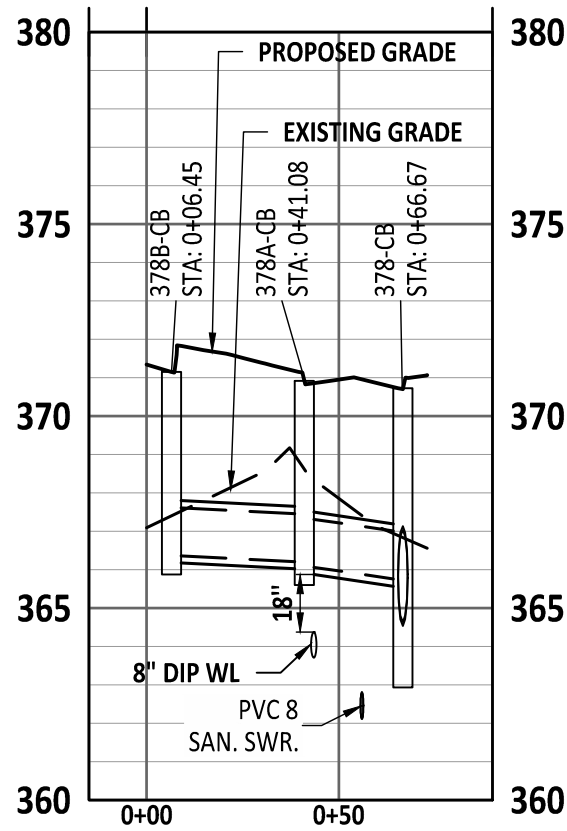


378B-CB TO 378-CB PROFILE

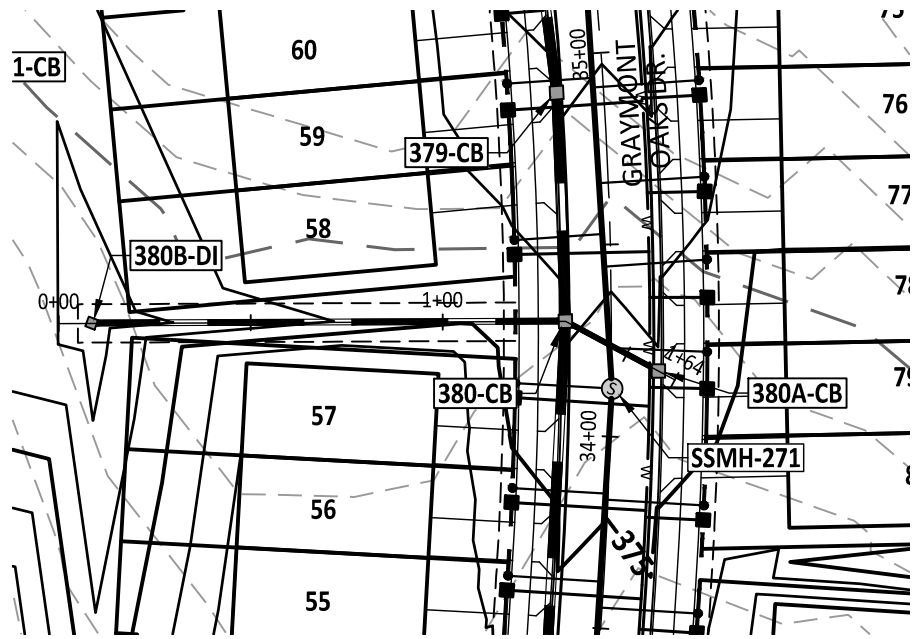


380B-DI TO 380A-CB PLAN

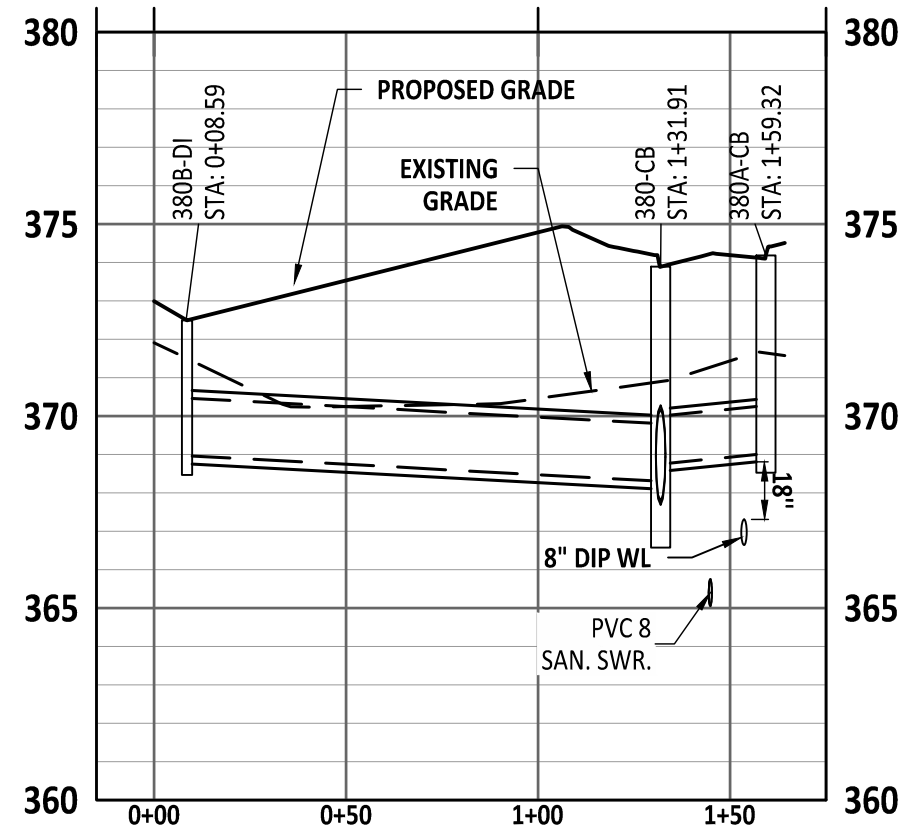


380B-DI TO 380A-CB PROFILE

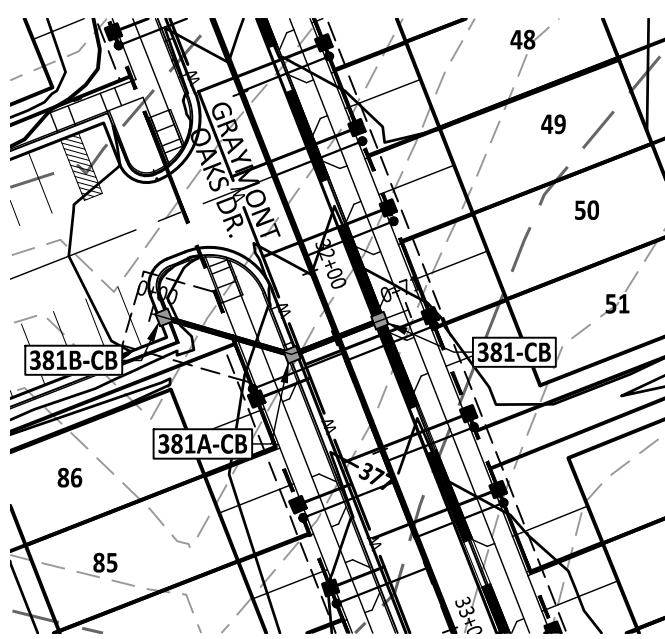


381B-CB TO 381-CB PLAN

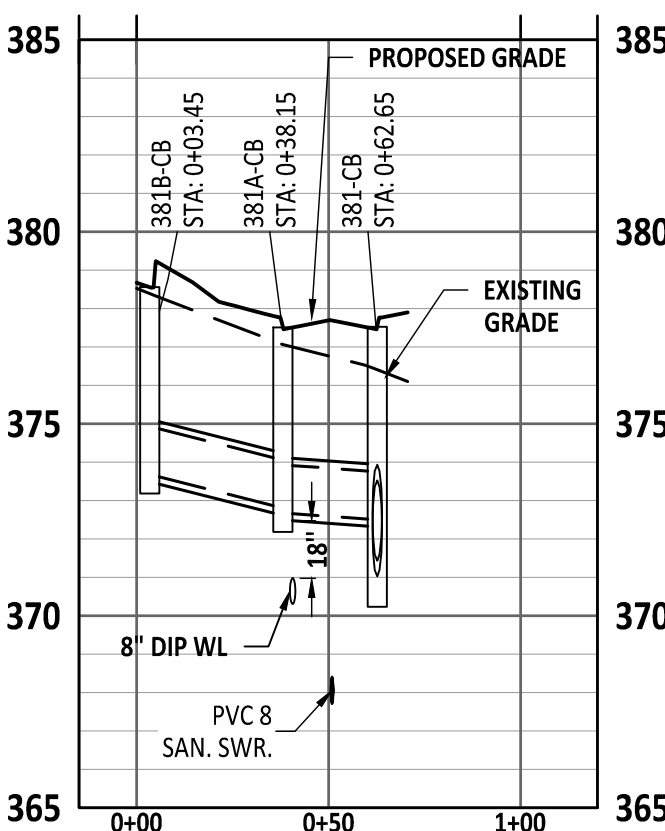

381B-CB TO 381-CB PROFILE

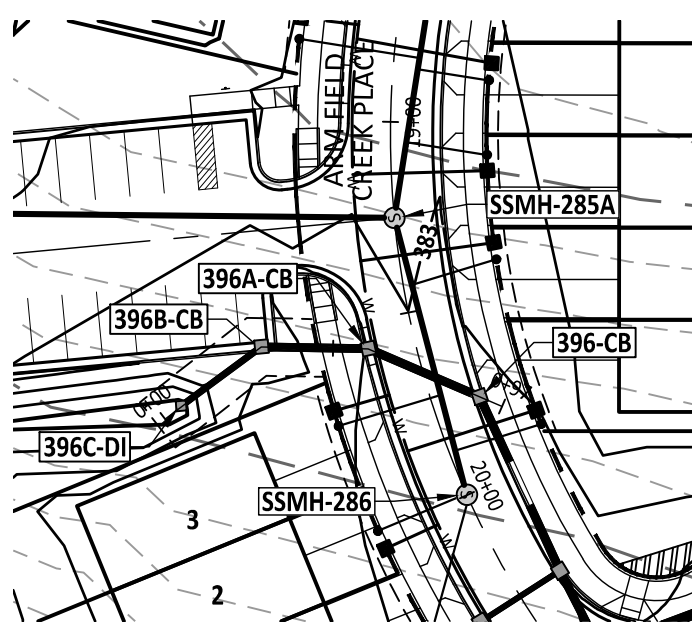


396C-DI TO 396-CB PLAN

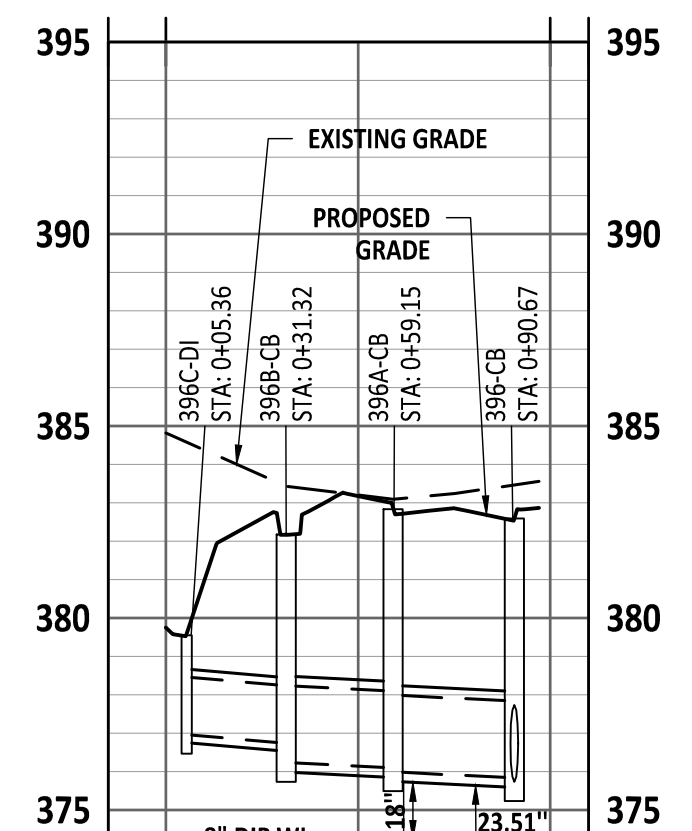


396C-DI TO 396-CB PROFILE




383A-DI TO 383-CB PLAN

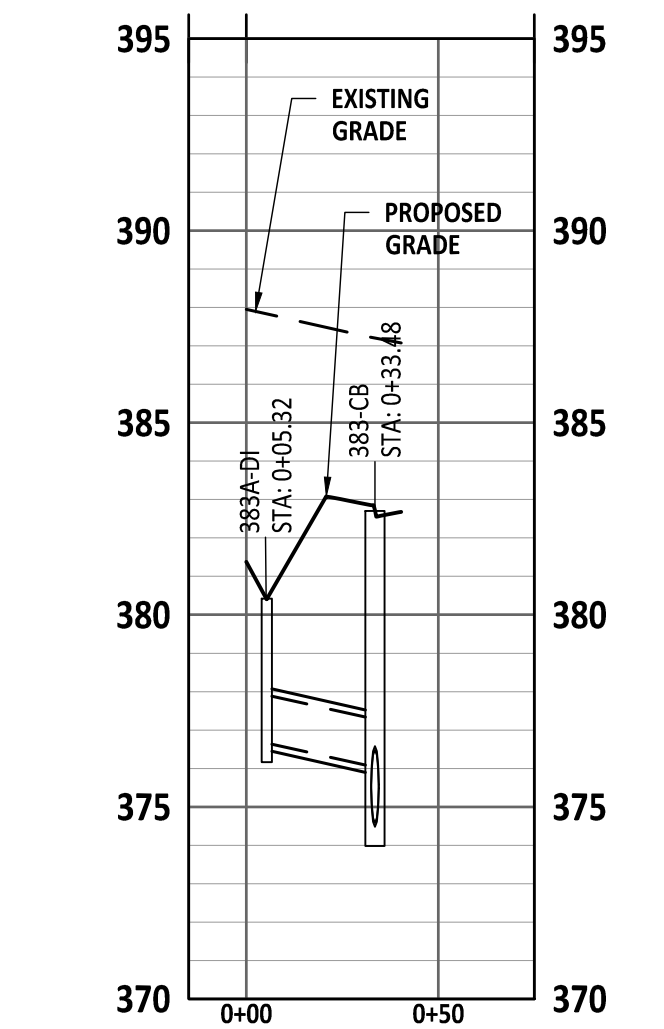


383A-DI TO 383-CB PROFILE

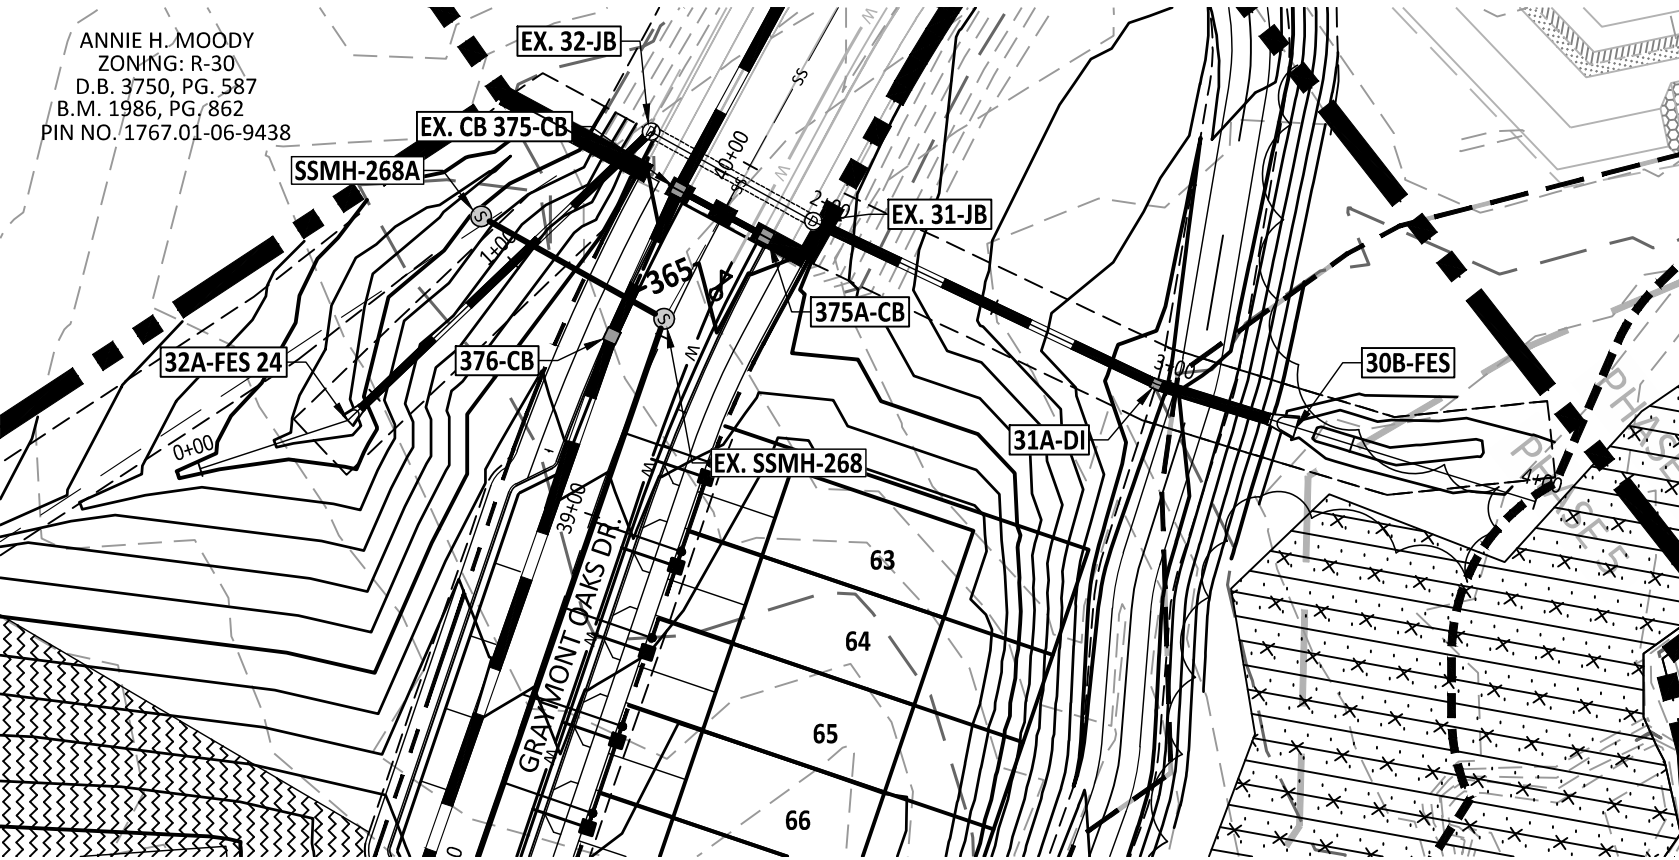


32A-FES 18 TO 30B-FES 30 PLAN

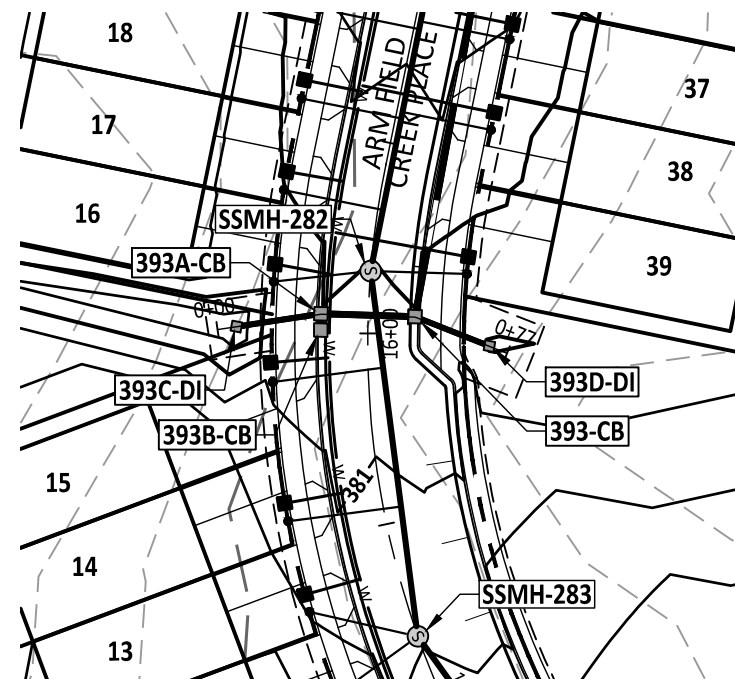


393C-DI TO 393D-DI PLAN

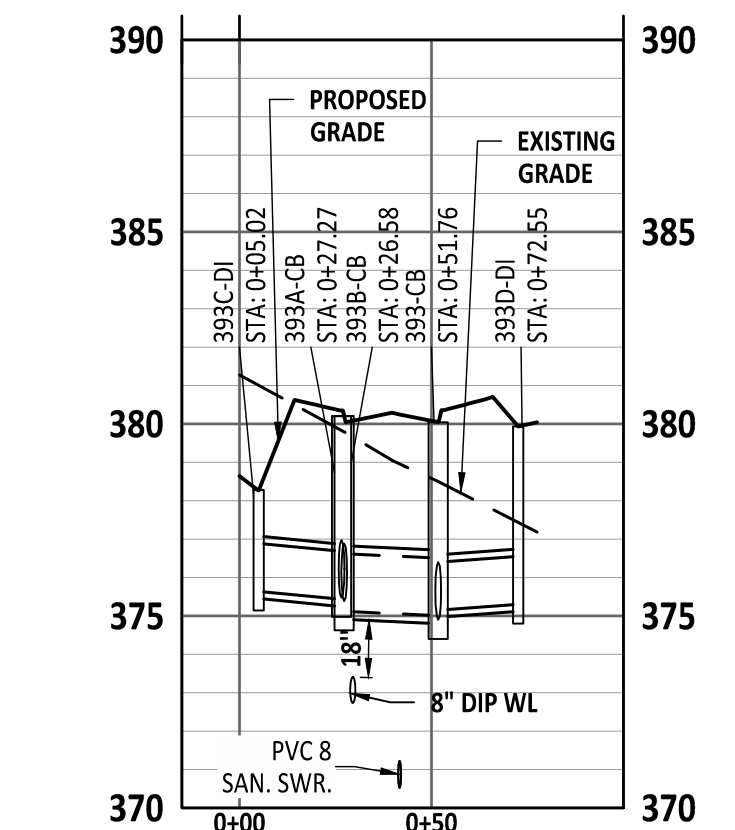


393C-DI TO 393D-DI PROFILE

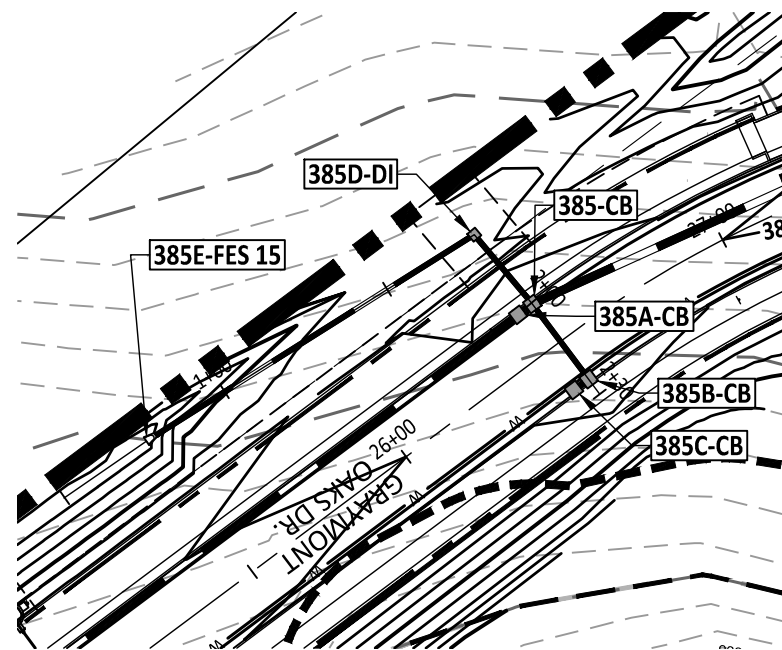


385B-DI TO 385A-CB PLAN

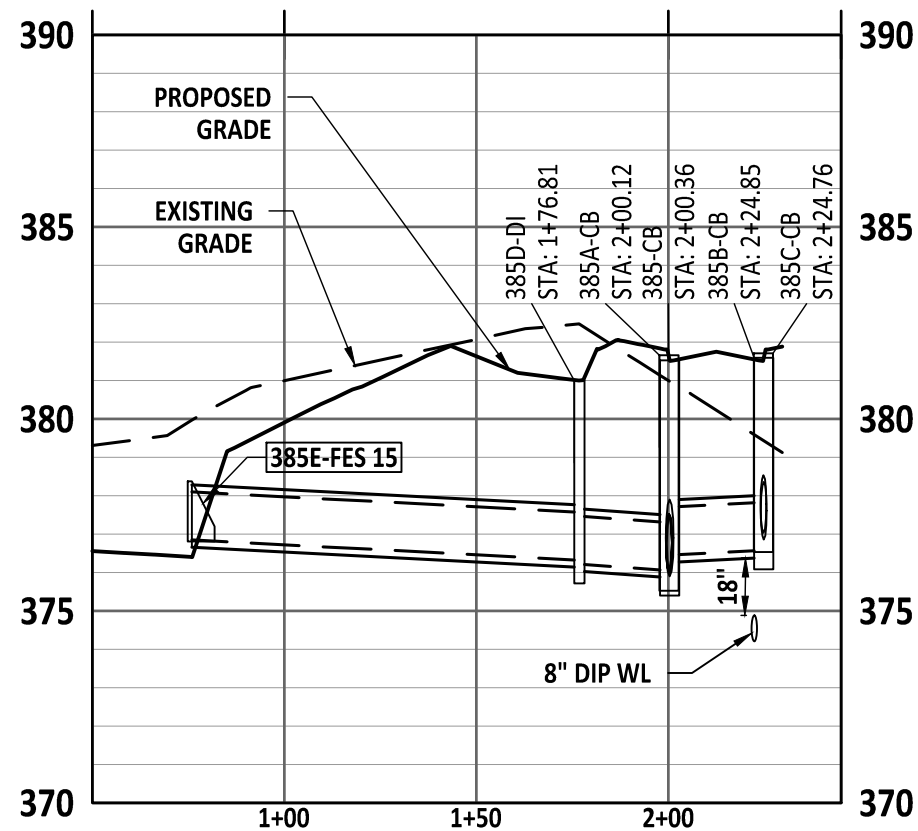


385E-FES 15 TO 385C-CB PROFILE

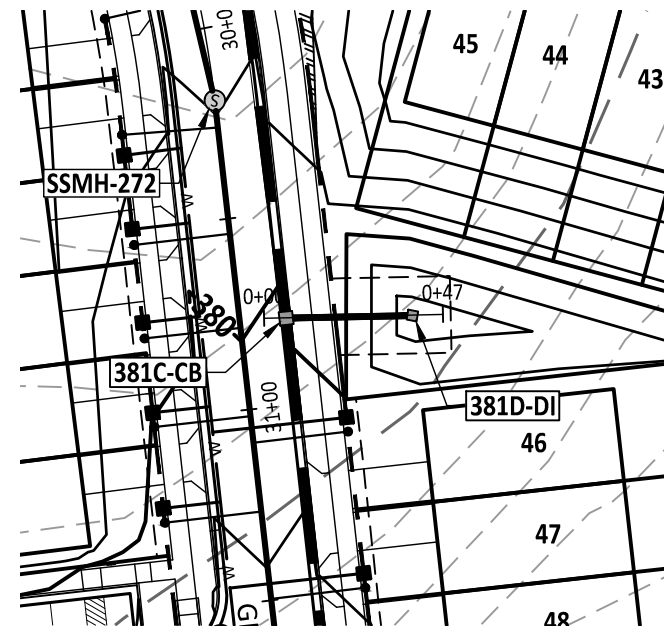



381C-CB TO 381D-DI PLAN

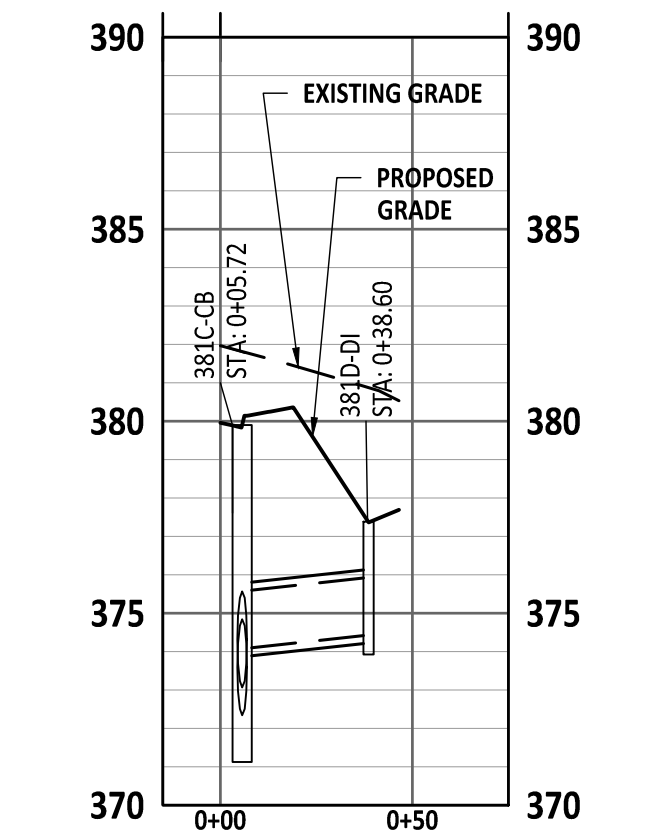

381C-CB TO 381D-DI PROFILE

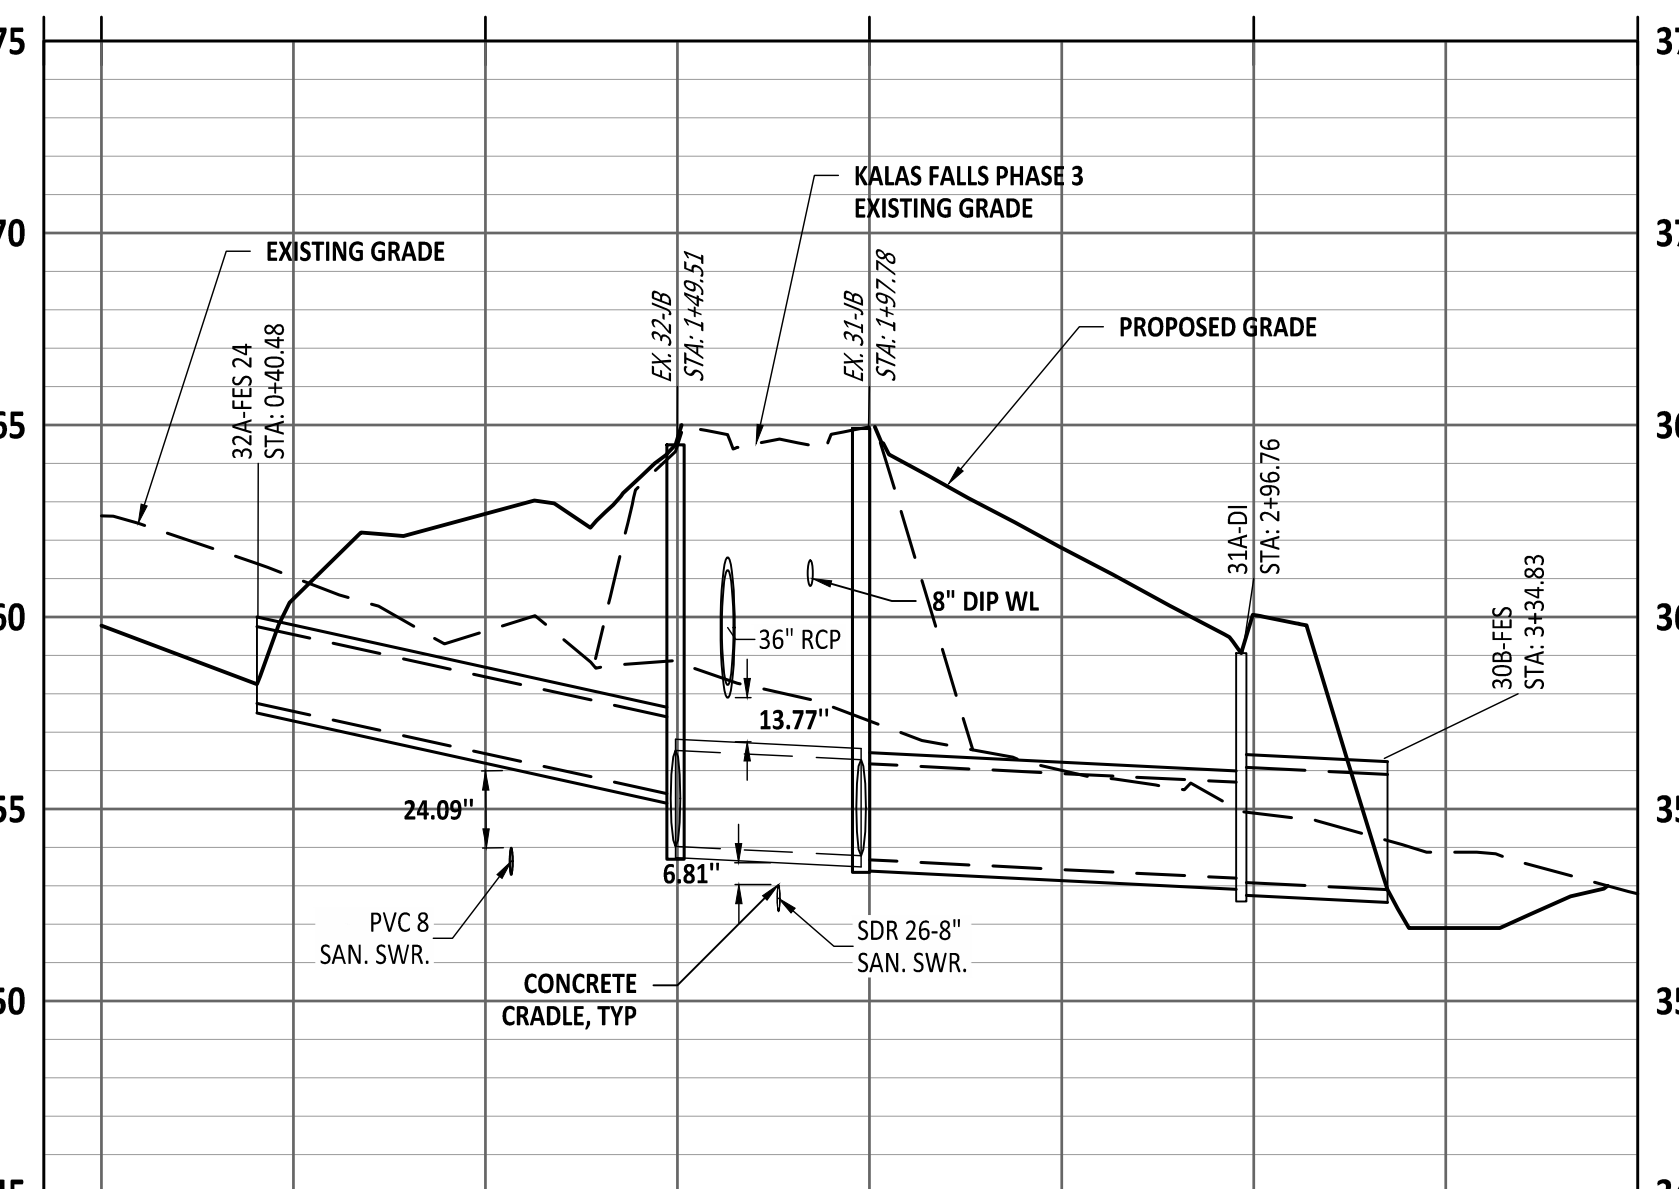

32A-FES 18 TO 30B-FES 30 PROFILE

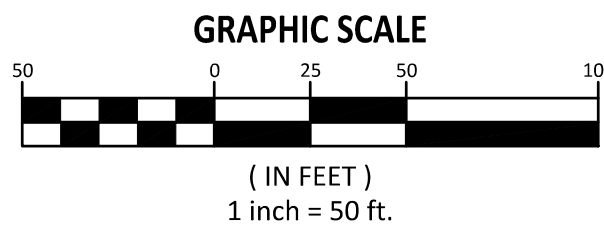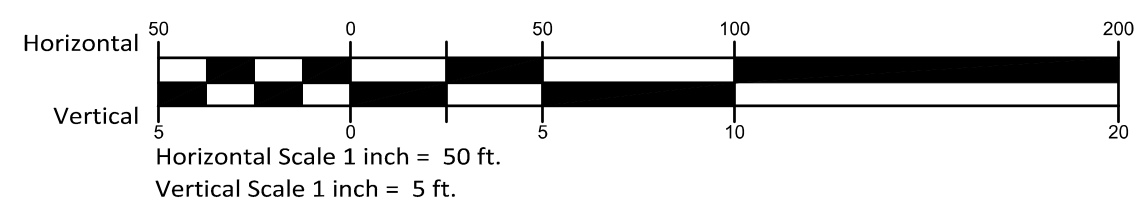

Public
Sewer Collection / Extension System
The City of Raleigh consents to the connection and extension of the City's public sewer system as shown on this plan. The material and Construction methods used for this project shall conform to the standards and specifications of the City's Public Utilities Handbook.
City of Raleigh
Public Utilities Department Permit # 5-5618

Public
Water Distribution / Extension System
The City of Raleigh consents to the connection and extension of the City's public water system as shown on this plan. The material and Construction methods used for this project shall conform to the standards and specifications of the City's Public Utilities Handbook.
City of Raleigh
Public Utilities Department Permit # W-4214

AMERICAN
Engineering
American Engineering Associates - Southeast, P.A.
4020 Westchase Boulevard, Suite 450
Raleigh, NC 27607
919-469-1101

AMERICAN
ENGINEERING
ASSOCIATES
SOUTHEAST
C-3881
DIGITALLY SIGNED BY
JAKOB KLEIN
DATE: 2025.05.01
TIME: 20:55:05
100% USE FOR
CONSTRUCTION
FOR INFORMATION, ONLY

NO.	DATE	REVISION	CID	SUBMITTAL #1
1	12/23/2024			

STIPULATION FOR REUSE
THIS DRAWING WAS PREPARED FOR USE ON THE SPECIFIC SITE, NAMED HEREIN, CONTEMPORANEOUSLY WITH ITS ISSUE DATE AS LISTED, HEREON, AND IT IS NOT SUITABLE FOR USE ON A DIFFERENT PROJECT SITE OR AT A LATER TIME. USE OF THIS DRAWING FOR REFERENCE OR EXAMPLE ON ANOTHER PROJECT REQUIRES THE SERVICES OF PROPERLY LICENSED ARCHITECTS AND ENGINEERS. REPRODUCTION OF THIS DRAWING FOR REUSE ON ANOTHER PROJECT IS NOT AUTHORIZED AND MAY BE CONTRARY TO THE LAW.

KALAS FALLS
PHASE 5
CONSTRUCTION INFRASTRUCTURE
DOCUMENTS
CID-25-01
TOWN OF ROLESVILLE,
WAKE COUNTY, NC


JOB NUMBER: R180115
CHECKED BY: JK
DRAWN BY: GE, RC
DATE: 05-01-2025

SHEET TITLE:
STORM
DRAINAGE
PLAN &
PROFILES
SHEET NO.:
CD200




North Carolina 811
*** 3 Days Before Digging ***
North Carolina 811
811 or 1-800-632-6469
Remote Ticket Entry
<http://nc811.org/remoteticketentry.htm>

\\nas001\projects\water\phase5\townhomes\CD201\sheet\construction\document\CD201.dwg
2/16/2025 09:00\water\phase5\townhomes\CD201\sheet\construction\document\CD201.dwg


2025-05-01

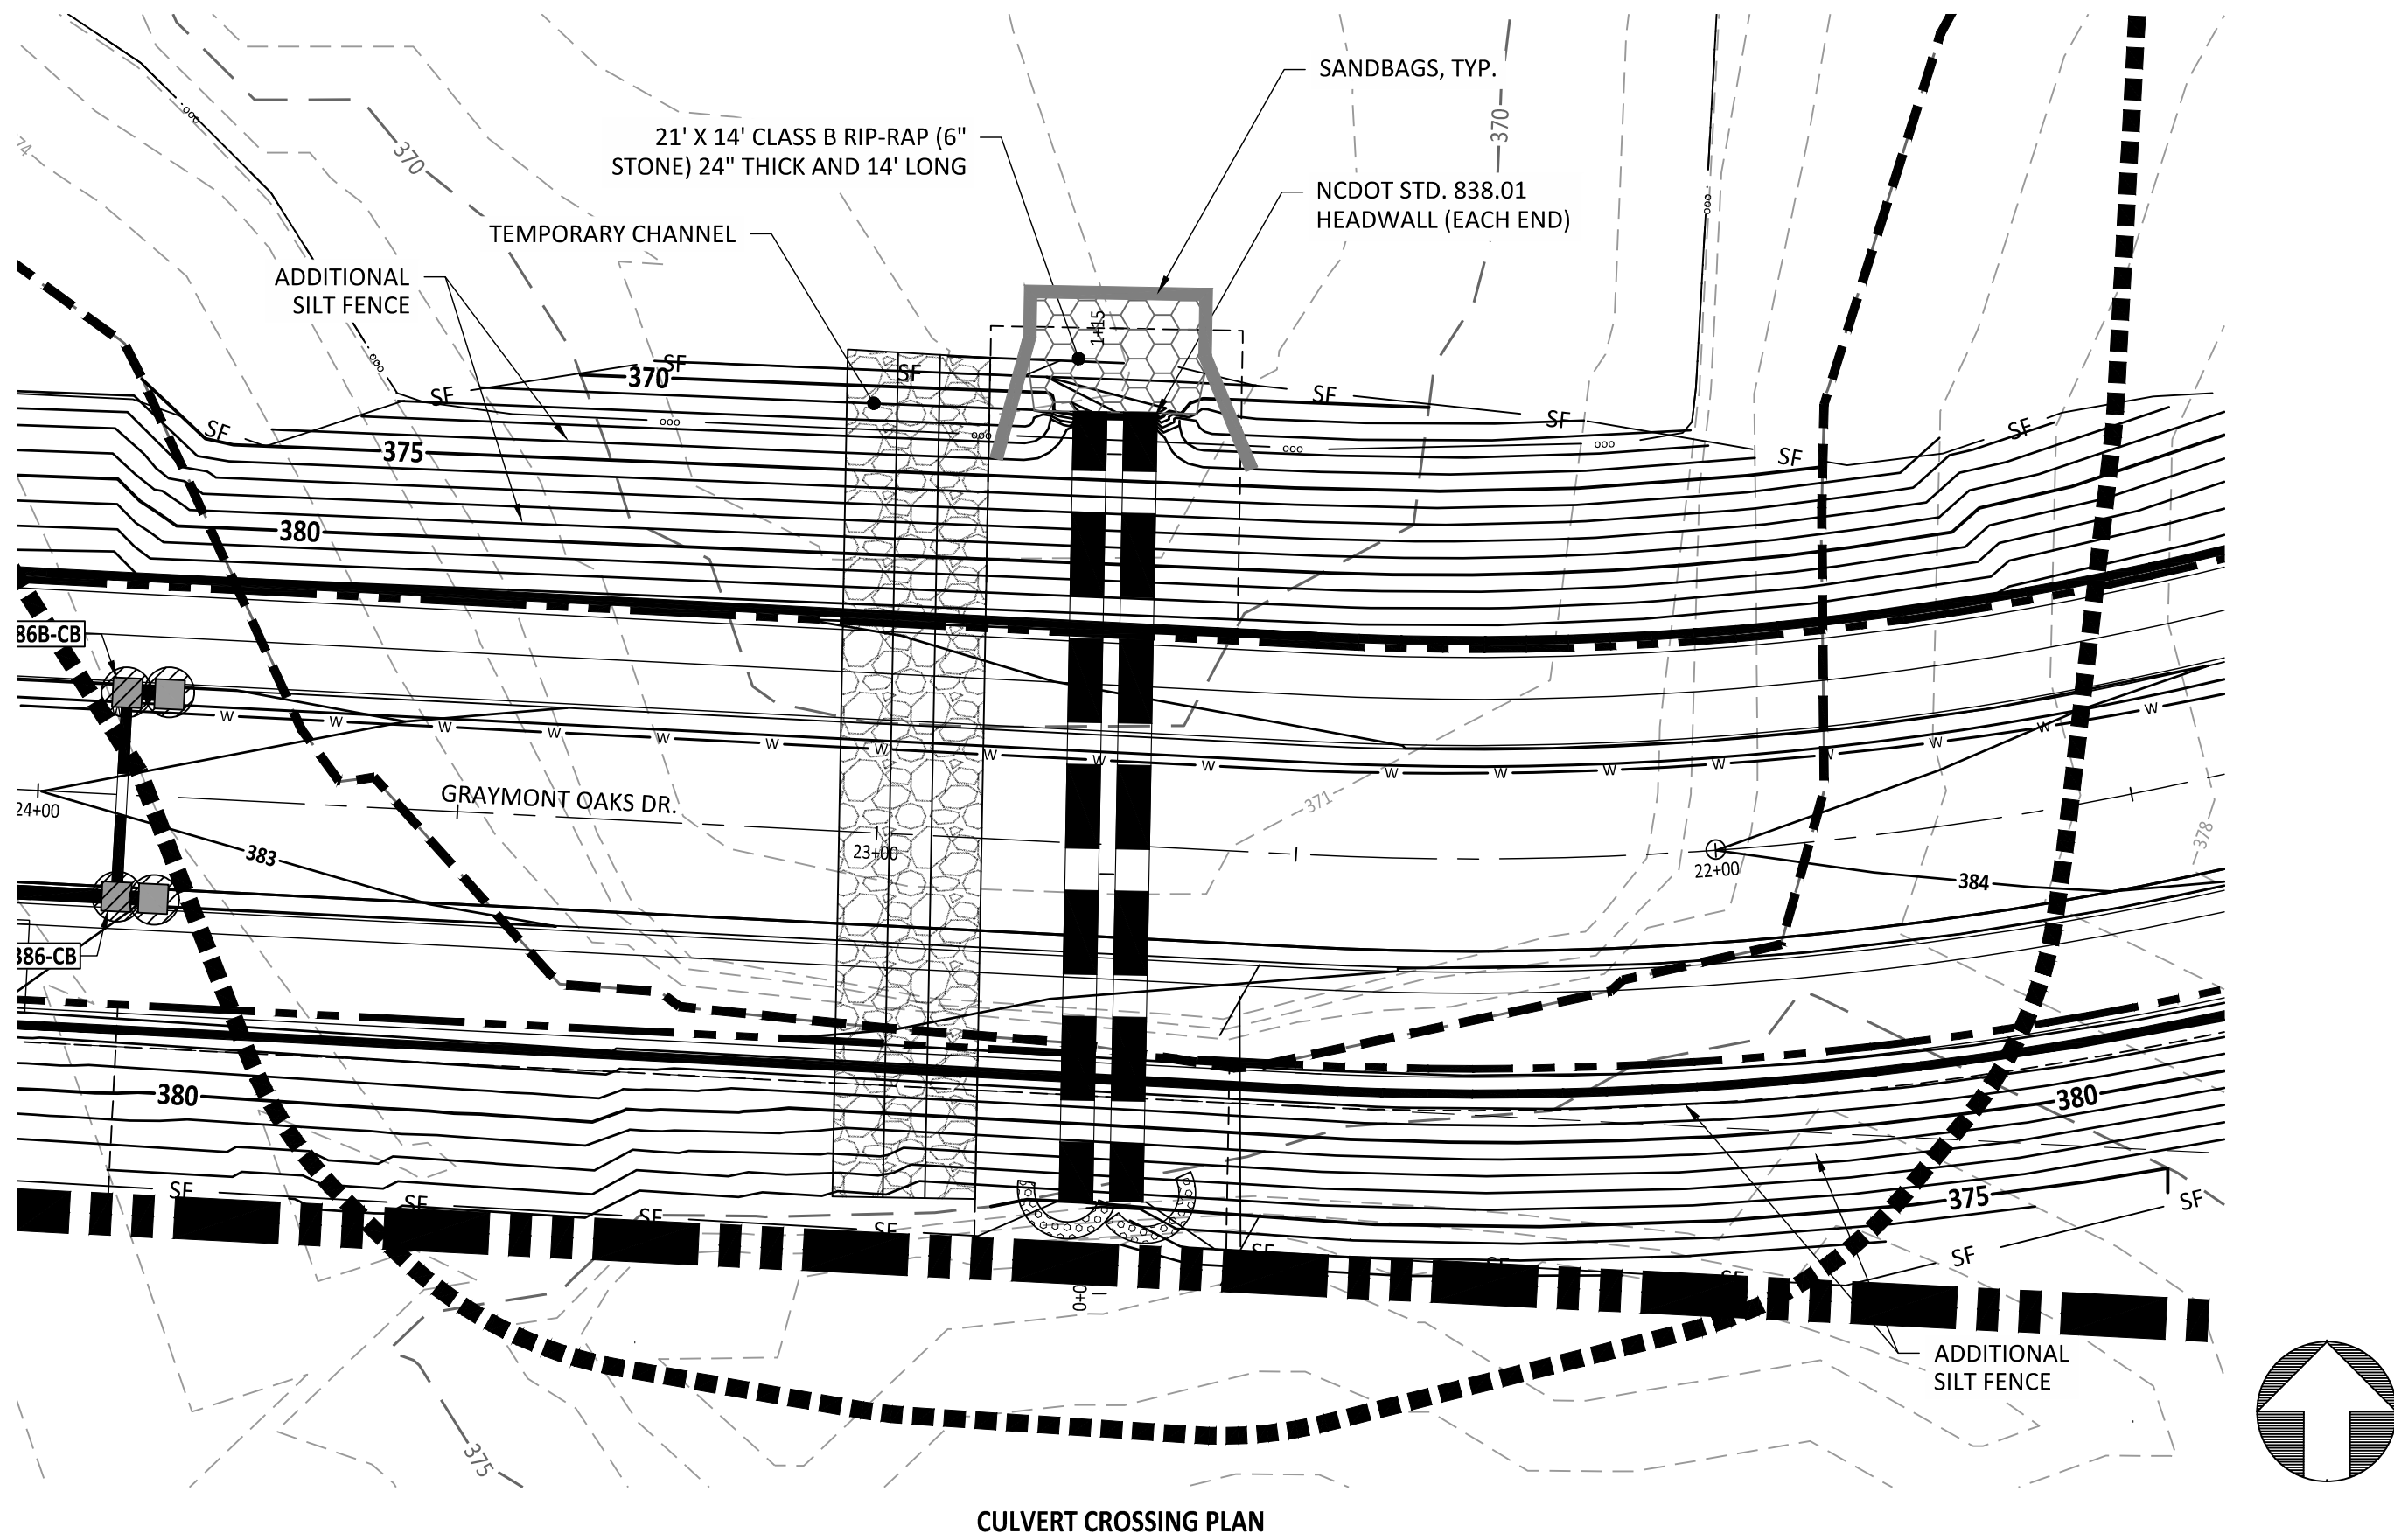


CULVERT CROSSING PLAN

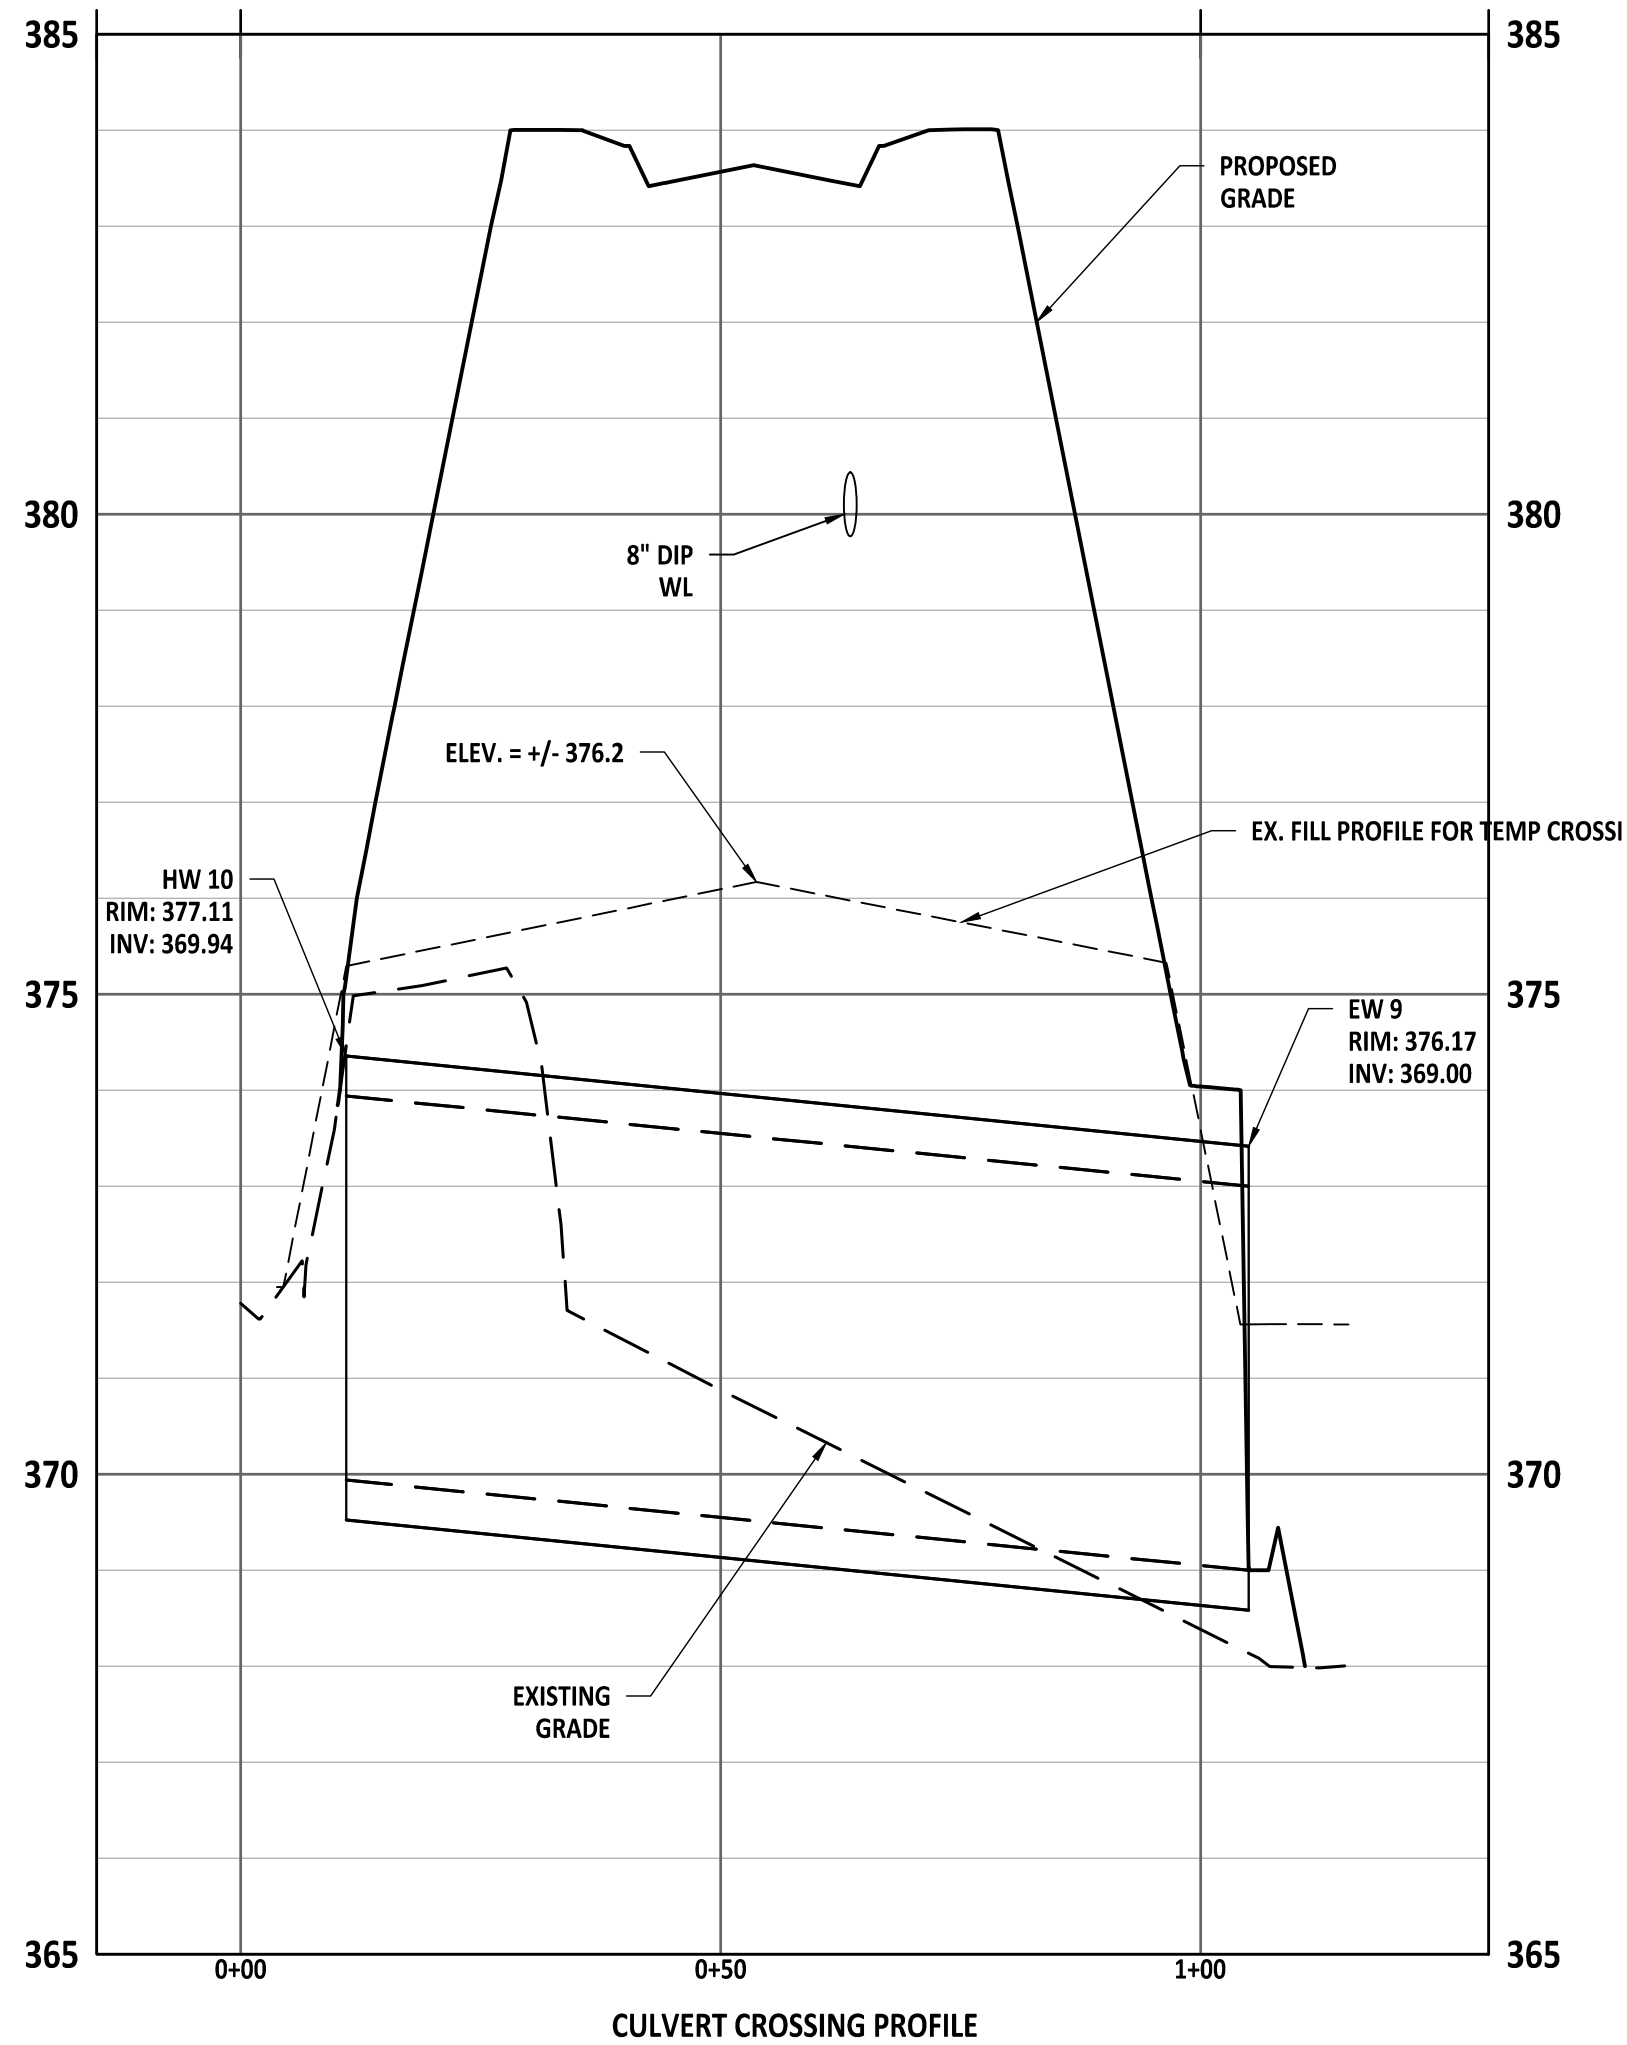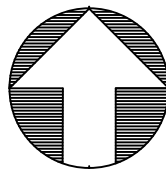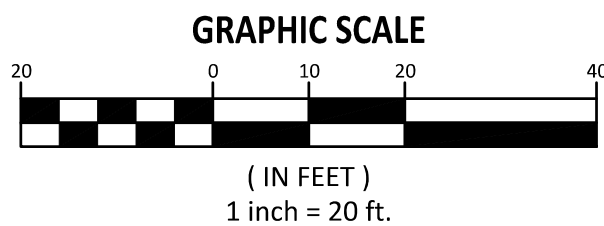

CULVERT CROSSING PROFILE

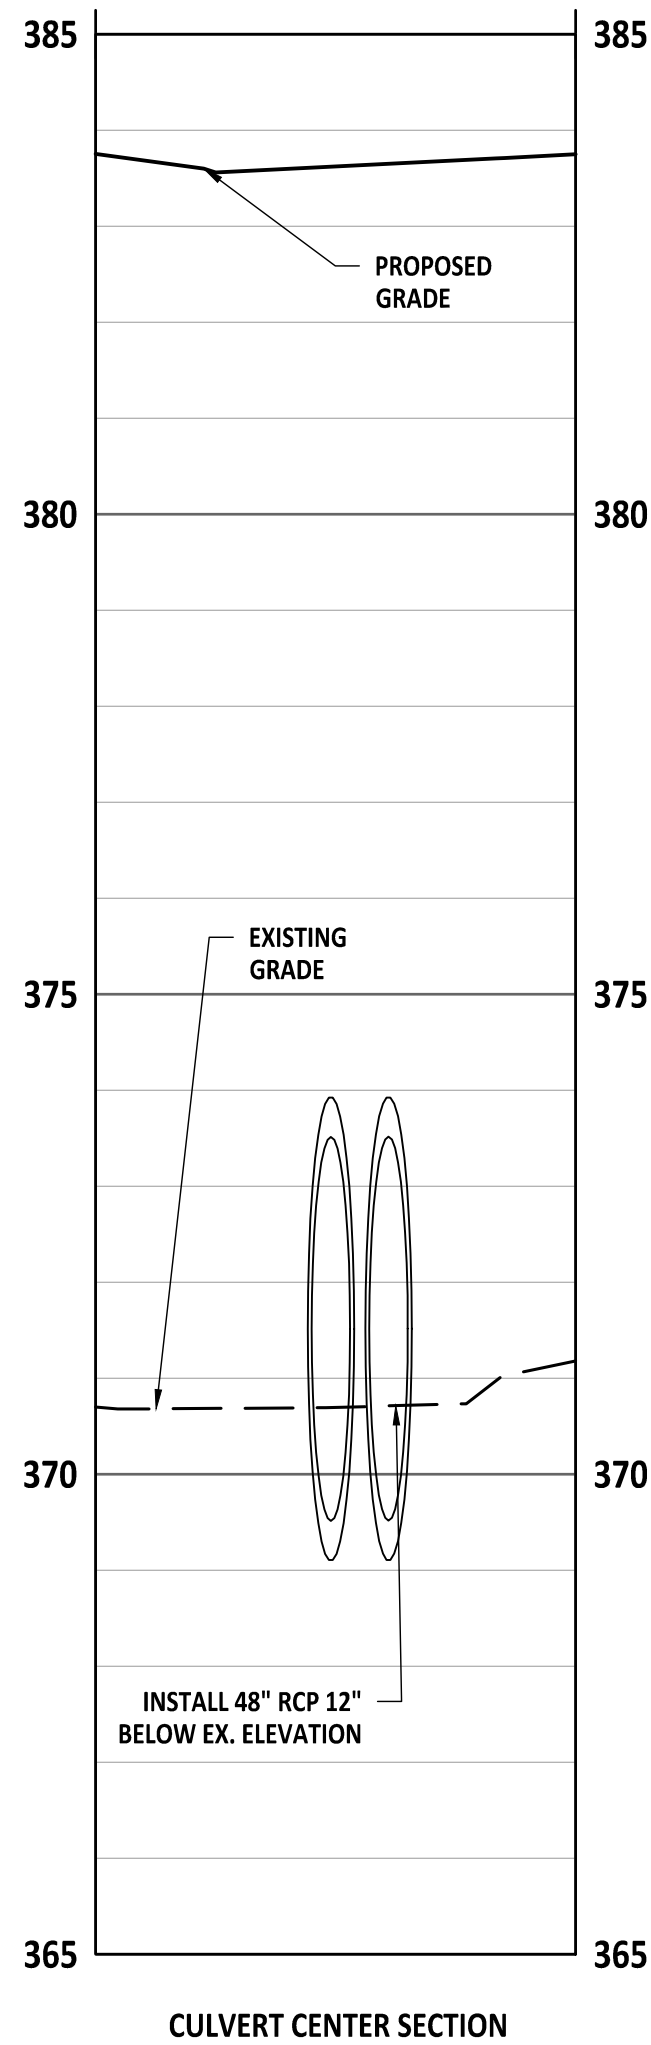

CULVERT CENTER SECTION

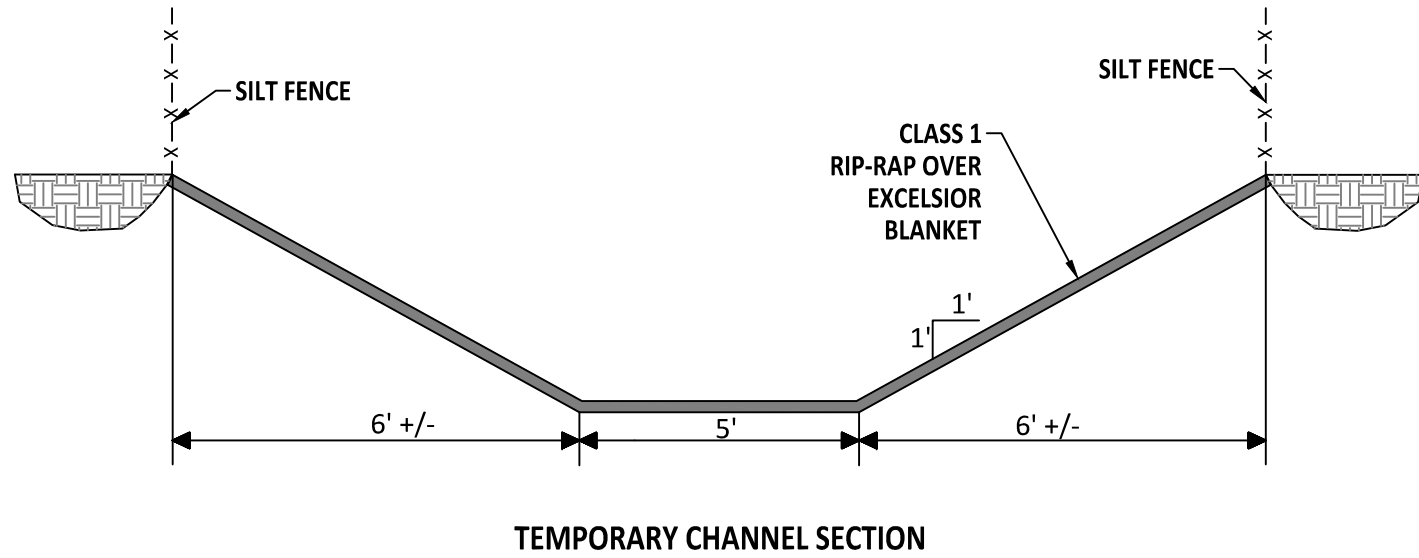

TEMPORARY CHANNEL SECTION

CONSTRUCTION SEQUENCE FOR THE GRAYMONT OAKS CROSSING OF THE EXISTING POND NEAR THE SOUTHERN BORDER OF KALAS FALLS SUBDIVISION SHALL BE AS FOLLOWS:

STAGE 1A CULVERT CROSSING INSTALLATION:

1. CONDUCT A MEETING WITH THE WAKE COUNTY INSPECTOR PRIOR TO PROCEEDING WITH THE CONSTRUCTION OF THE CULVERT CROSSING.
2. PUMP THE EXISTING POND DOWN SO IT IS BELOW THE PROPOSED PIPE INVERTS.
3. INSTALL THE BYPASS CHANNEL AS SHOWN WITH LINING LEAVING A PORTION OF THE BANK ON EACH END TO ACT AS A DAM TO PREVENT WATER FLOW DURING CONSTRUCTION OF THE CHANNEL. (STEPS 4 - 8 SHOULD BE ACCOMPLISHED DURING ONE WORKDAY).
4. DURING A PERIOD OF DRY WEATHER AND WHEN THE WATER LEVEL OF THE POND IS BELOW THE CHANNEL INVERT, REMOVE THE DOWNSTREAM DAM FIRST AND CONSTRUCT THE REMAINDER OF THE CHANNEL TO THE EXISTING POND.
5. REMOVE THE UPSTREAM DAM AND CONSTRUCT THE REMAINDER OF THE CHANNEL TO TIE TO THE LOW AREA INCLUDING LINING.
6. ADD SANDBAGS ACROSS THE LOW POINT AT THE UPSTREAM END TO FORCE THE WATER FLOW INTO THE BY-PASS CHANNEL.
7. ADD SANDBAGS ACROSS THE DOWNSTREAM END OF THE LOW POINT JUST ABOVE THE POINT WHERE THE BY-PASS CHANNEL RE-ENTERS THE POND TO PREVENT FLOW INTO THE LOCATION OF THE PIPE TO BE INSTALLED.
8. SEED/SOD AND STABILIZE ALL DENUDED AREAS ONCE THE CHANNEL IS IN PLACE.
9. THE PUMP IS TO REMAIN ON SITE AND TO KEEP POND ELEVATION AT OR BELOW THE CHANNEL AND PIPE INVERTS.

STAGE 1B CULVERT CROSSING INSTALLATION:

1. OBTAIN PERMISSION FROM THE WAKE COUNTY INSPECTOR TO PROCEED WITH THIS STEP.
2. EXCAVATE AREA AS SHOWN AND INSTALL PIPE WITH HEADWALLS AND DOWNSTREAM RIP-RAP AS SHOWN IN RIP-RAP CROSS-SECTION WITHIN THE WORKABLE AREA.
3. OBTAIN WAKE COUNTY APPROVAL OF THE PIPE INSTALLATION.


STAGE 1C CULVERT CROSSING INSTALLATION

1. WITHIN ONE ACTIVE WORKDAY, REMOVE THE TEMPORARY DAM ON DOWNSTREAM AND UPSTREAM ENDS.
2. REMOVE LINING ON UPSTREAM END OF BY-PASS CHANNEL AND INSTALL EARTHEN DAM ACROSS THE UPSTREAM END OF THE BY-PASS CHANNEL. REUSE SANDBAGS TO FORCE WATER FLOW THROUGH THE PIPE.
3. INSTALL EARTHEN DAM ACROSS THE DOWNSTREAM OF THE BY-PASS CHANNEL AFTER REMOVING THE LINING.
4. REMOVE REMAINDER OF THE BY-PASS CHANNEL LINING AND FILL THE CHANNEL COMPACTING THOROUGHLY IN LAYERS.
5. INSTALL SILT FENCE AT THE TOE OF SLOPES AND TIE TO ENDWALLS AS SHOWN ON THIS PLAN.
6. INSTALL ADDITIONAL SILT FENCE ALONG THE SLOPE AS SHOWN AND AS NEEDED.
7. COMPLETE FILL AROUND THE PIPE TO A LEVEL AT LEAST TWO (2) FEET ABOVE THE TOP OF THE PIPE TO ALLOW CONSTRUCTION EQUIPMENT TO PASS OVER IT.
8. COMPLETE FILL BRINGING THE AREA TO FINISHED GRADE.
9. INSTALL PAVEMENT AND FOLLOW THE SEEDING SCHEDULE FOR ALL BARE AREAS.
10. REFER TO MAIN CONSTRUCTION SEQUENCE FOR OTHER DETAILS.

GENERAL NOTES

1. ALL CONSTRUCTION SHALL BE IN ACCORDANCE WITH WAKE COUNTY STANDARDS AND REGULATIONS.
2. THERE SHALL BE NO DISTURBANCE OUTSIDE THE LIMITS SHOWN ON THIS PLAN WITHOUT AN APPROVED PLAN AMENDMENT BY WAKE COUNTY.
3. ALL DISTURBED AREAS SHALL BE SEEDED PER THE SEEDING SCHEDULE.
4. PERMANENT GROUND COVER SHALL BE ESTABLISHED PER NPDES SEEDING SCHEDULE AT EITHER 7 DAYS OR 14 DAYS DEPENDING ON MEASURE AND SLOPE.
5. CONTRACTOR IS RESPONSIBLE FOR MAINTAINING SELF-INSPECTION LOG.
6. CUT AND FILL SLOPES THAT ARE 2:1 OR GREATER SHALL BE STABILIZED WITH PERMANENT SLOPE RETENTION DEVICES OR A SUITABLE COMBINATION OF PLANTING AND RETENTION DEVICES. SLOPES GREATER THAN 3:1 SHALL NOT BE STABILIZED WITH TURF GRASS BUT MUST BE STABILIZED WITH VEGETATION THAT REQUIRES MINIMAL MAINTENANCE SUCH AS WEEPING LOVE GRASS, RED FESCUE, OR OTHER APPROVED VARIETY.

Public Sewer Collection / Extension System The City of Raleigh consents to the connection and extension of the City's public sewer system as shown on this plan. The material and Construction methods used for this project shall conform to the standards and specifications of the City's Public Utilities Handbook. City of Raleigh Public Utilities Department Permit # 5-5618	Public Water Distribution / Extension System The City of Raleigh consents to the connection and extension of the City's public water system as shown on this plan. The material and Construction methods used for this project shall conform to the standards and specifications of the City's Public Utilities Handbook. City of Raleigh Public Utilities Department Permit # W-4214
---	---

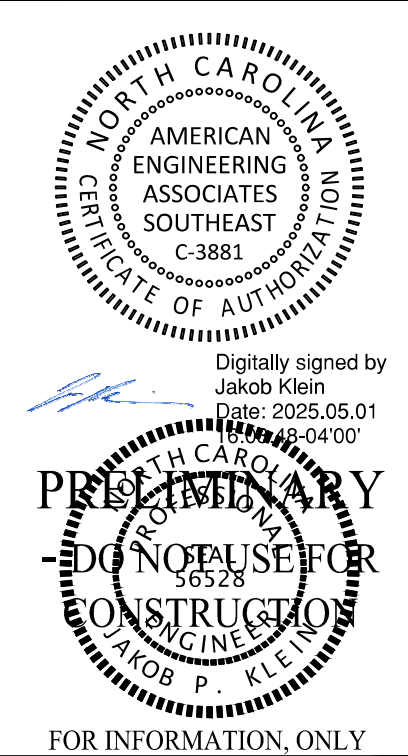

FOR INFORMATION, ONLY

NO.	DATE	REVISION:	CID SUBMITTAL #1
1	12/23/2024		

STIPULATION FOR REUSE



THIS DRAWING WAS PREPARED FOR USE ON THE SPECIFIC SITE, NAMED HEREON, CONTEMPORANEOUSLY WITH ITS ISSUE DATE AS LISTED, HEREON, AND IT IS NOT SUITABLE FOR USE ON A DIFFERENT PROJECT SITE OR AT A LATER TIME. USE OF THIS DRAWING FOR REFERENCE OR EXAMPLE ON ANOTHER PROJECT REQUIRES THE SERVICES OF PROPERLY LICENSED ARCHITECTS AND ENGINEERS. REPRODUCTION OF THIS DRAWING FOR REUSE ON ANOTHER PROJECT IS NOT AUTHORIZED AND MAY BE CONTRARY TO THE LAW.

KALAS FALLS
PHASE 5
CONSTRUCTION INFRASTRUCTURE
DOCUMENTS
CID-25-01
TOWN OF ROLESVILLE,
WAKE COUNTY, NC

JOB NUMBER:	R180115
CHECKED BY:	JK
DRAWN BY:	GE, RC
DATE:	05-01-2025

SHEET TITLE:
**CULVERT
CROSSING
PLAN &
PROFILE**
SHEET NO.:
CD201

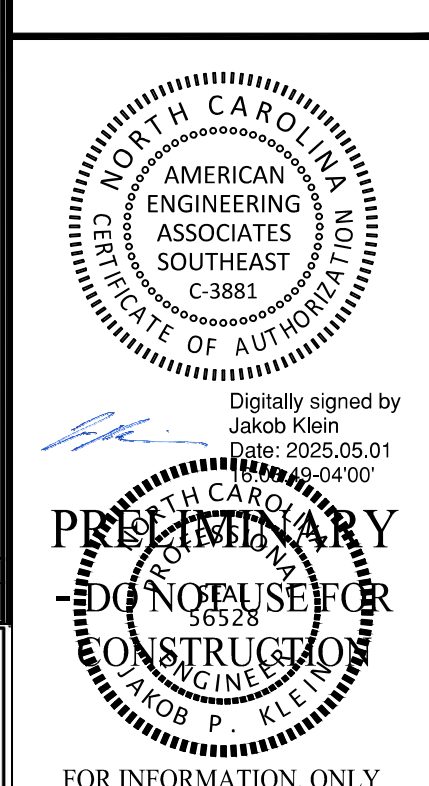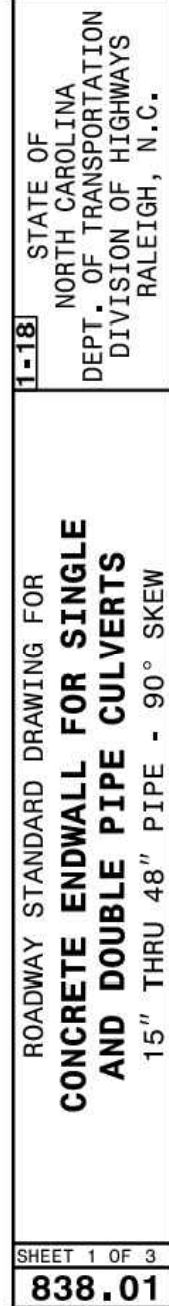

[illegible]

THIS DRAWING WAS PREPARED FOR USE ON THE SPECIFIC SITE, NAMED HEREON, CONTEMPORANEOUSLY WITH ITS ISSUE DATE AS LISTED, HEREON. AND IT IS NOT SUITABLE FOR USE ON A DIFFERENT PROJECT SITE OR AT A LATER TIME. USE OF THIS DRAWING FOR REFERENCE OR EXAMPLE ON ANOTHER PROJECT REQUIRES THE SERVICES OF PROPERLY LICENSED ARCHITECTS AND ENGINEERS. REPRODUCTION OF THIS DRAWING FOR REUSE ON ANOTHER PROJECT IS NOT AUTHORIZED AND MAY BE CONTRARY TO THE LAW.

KALAS FALLS
PHASE 5
INFRASTRUCTURE
DOCUMENTS
CID-25-01
TOWN OF ROLESVILLE,
WAKE COUNTY, NC








CON'S	
JOB NUMBER:	R180115
CHECKED BY:	JK
DRAWN BY:	GE, RC
DATE:	05-01-2025

SHEET TITLE:

**DRAINAGE
DETAILS**

SHEET NO.:

CD500

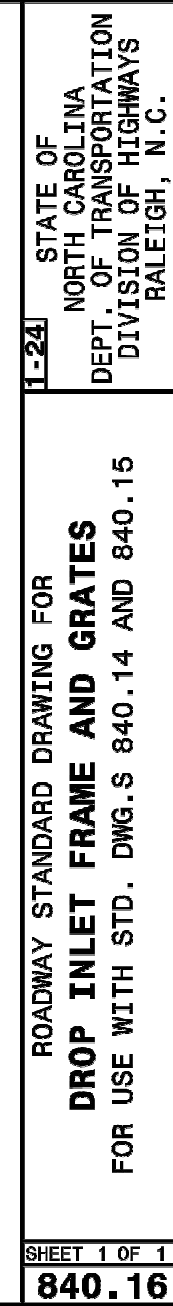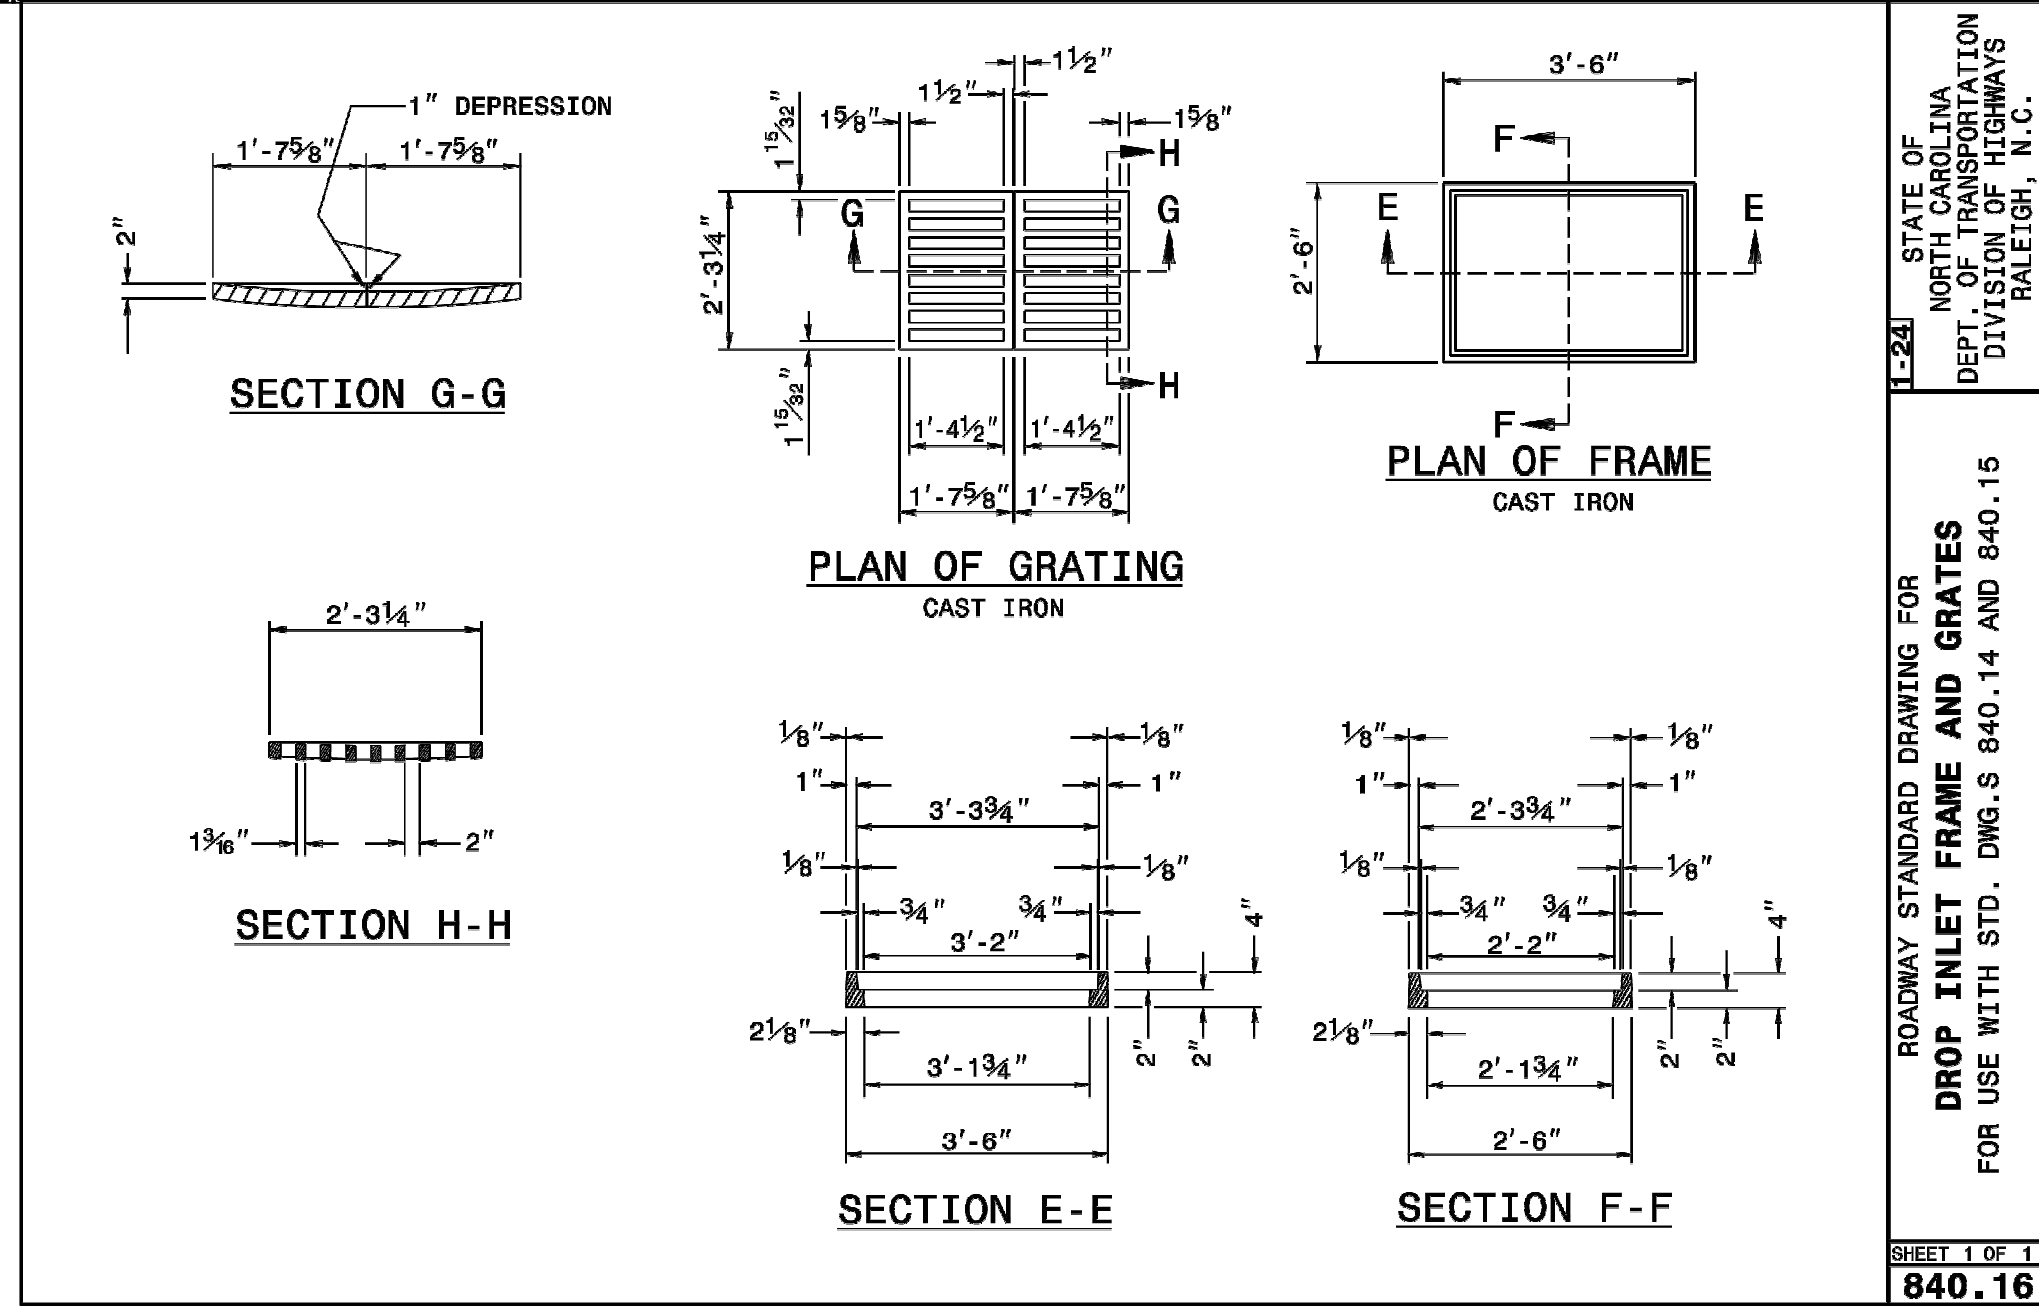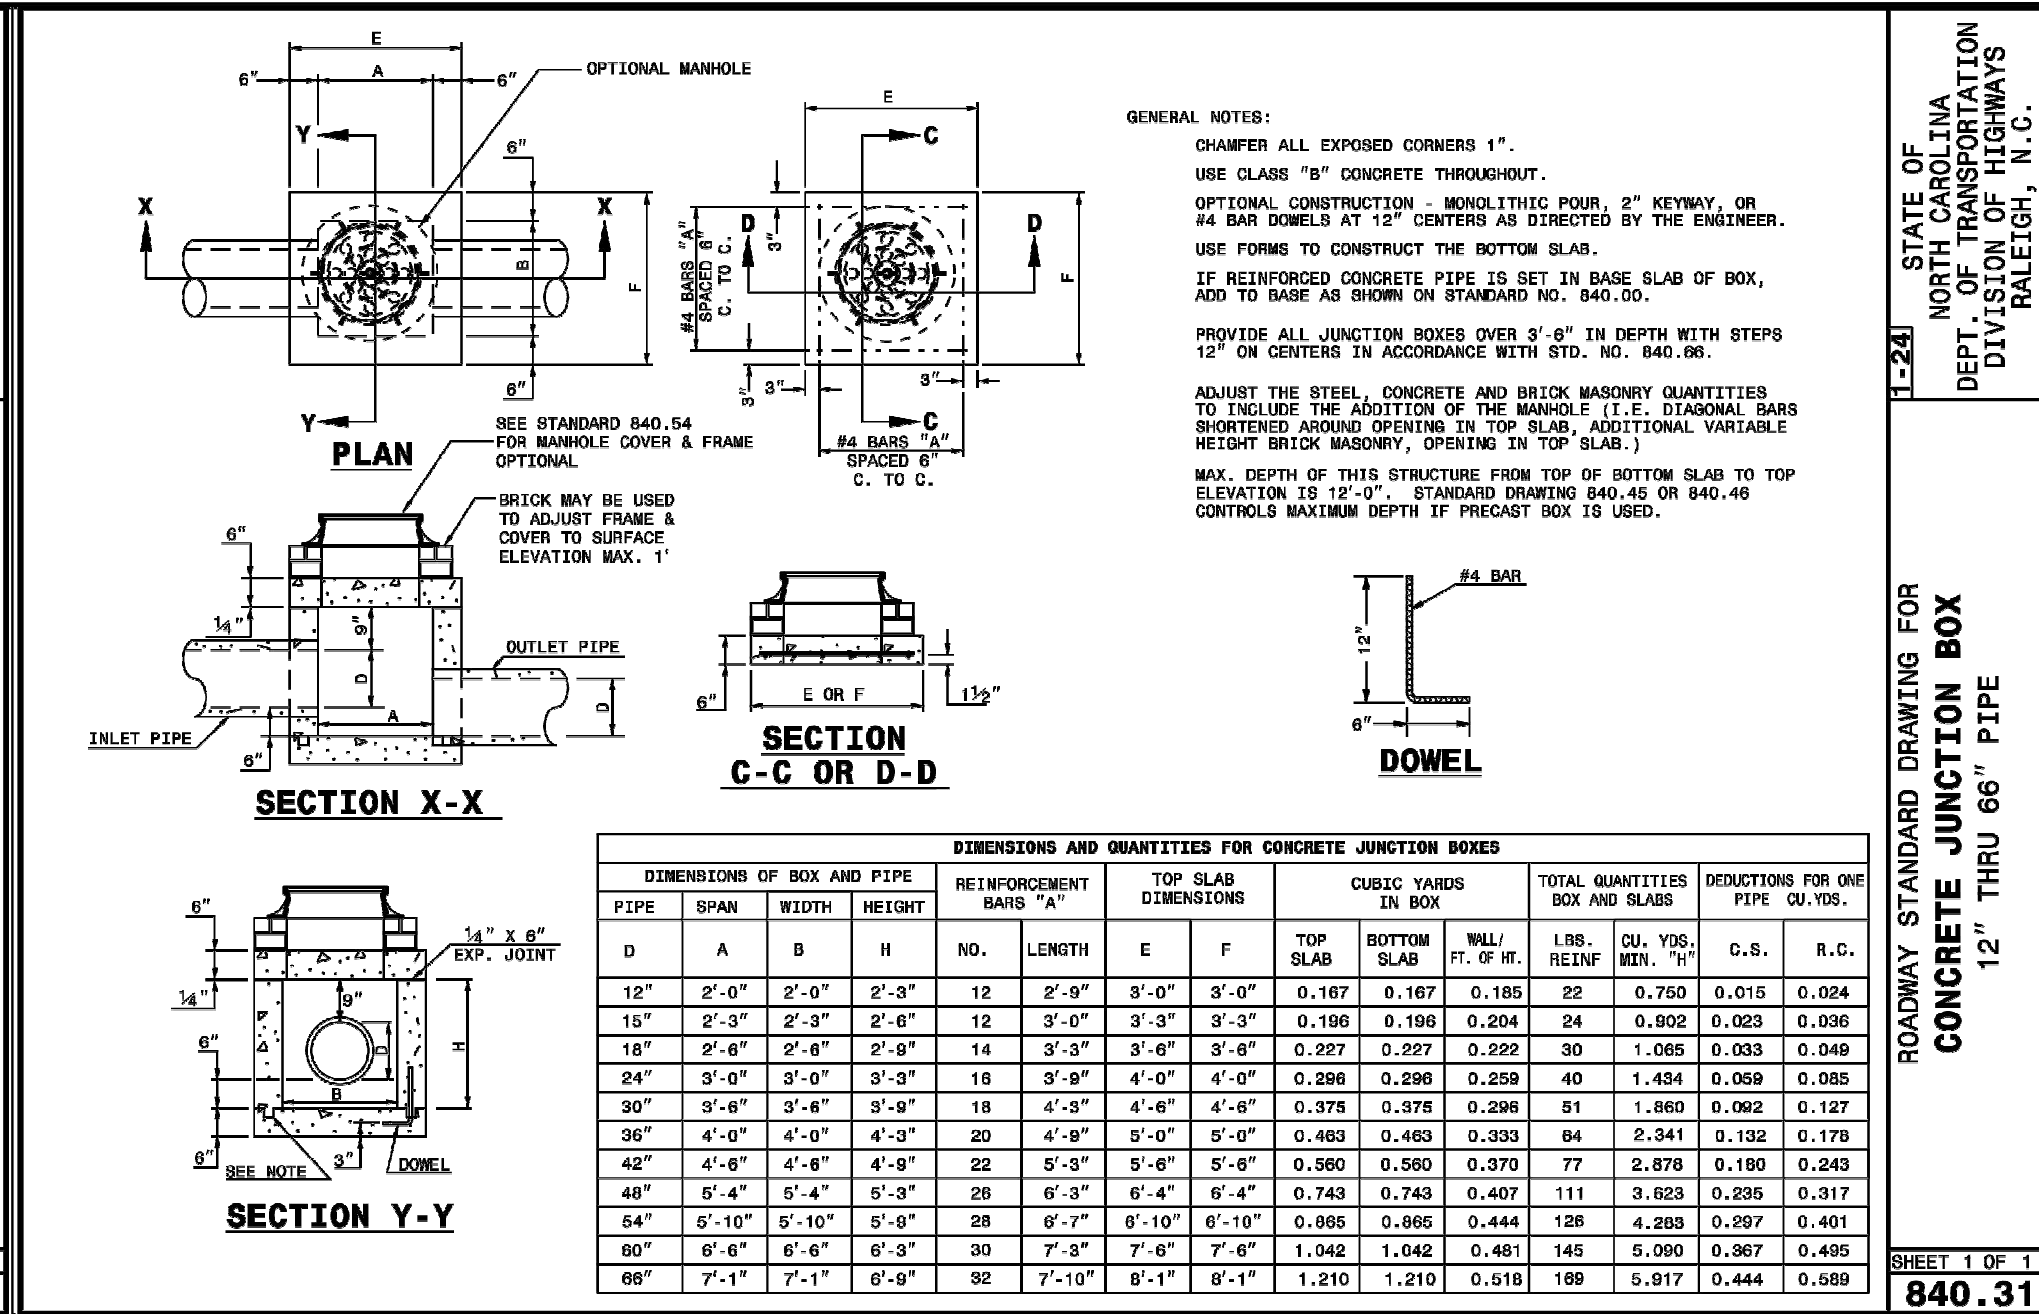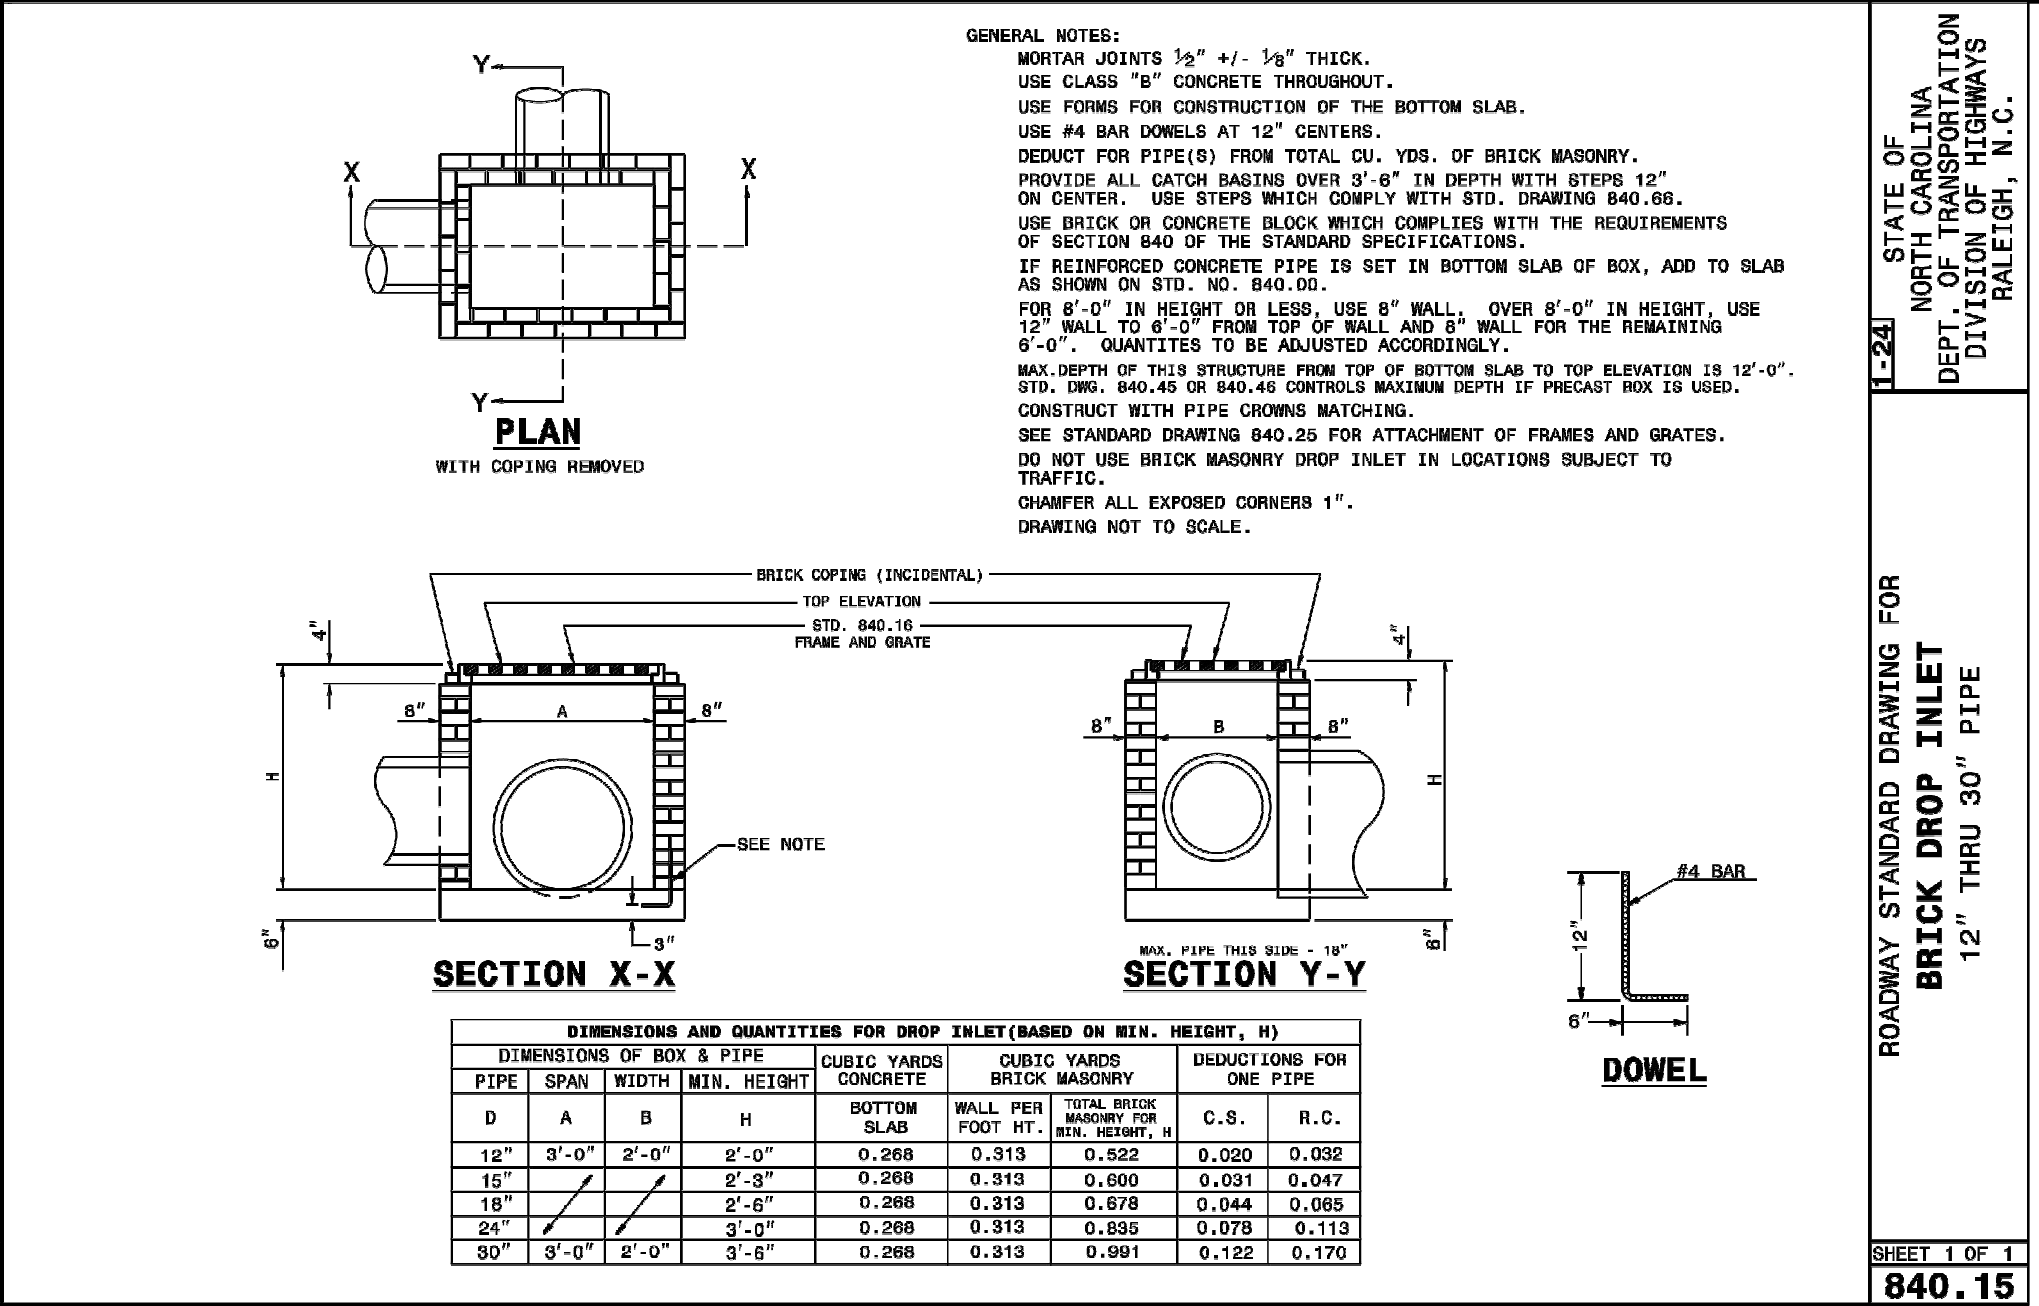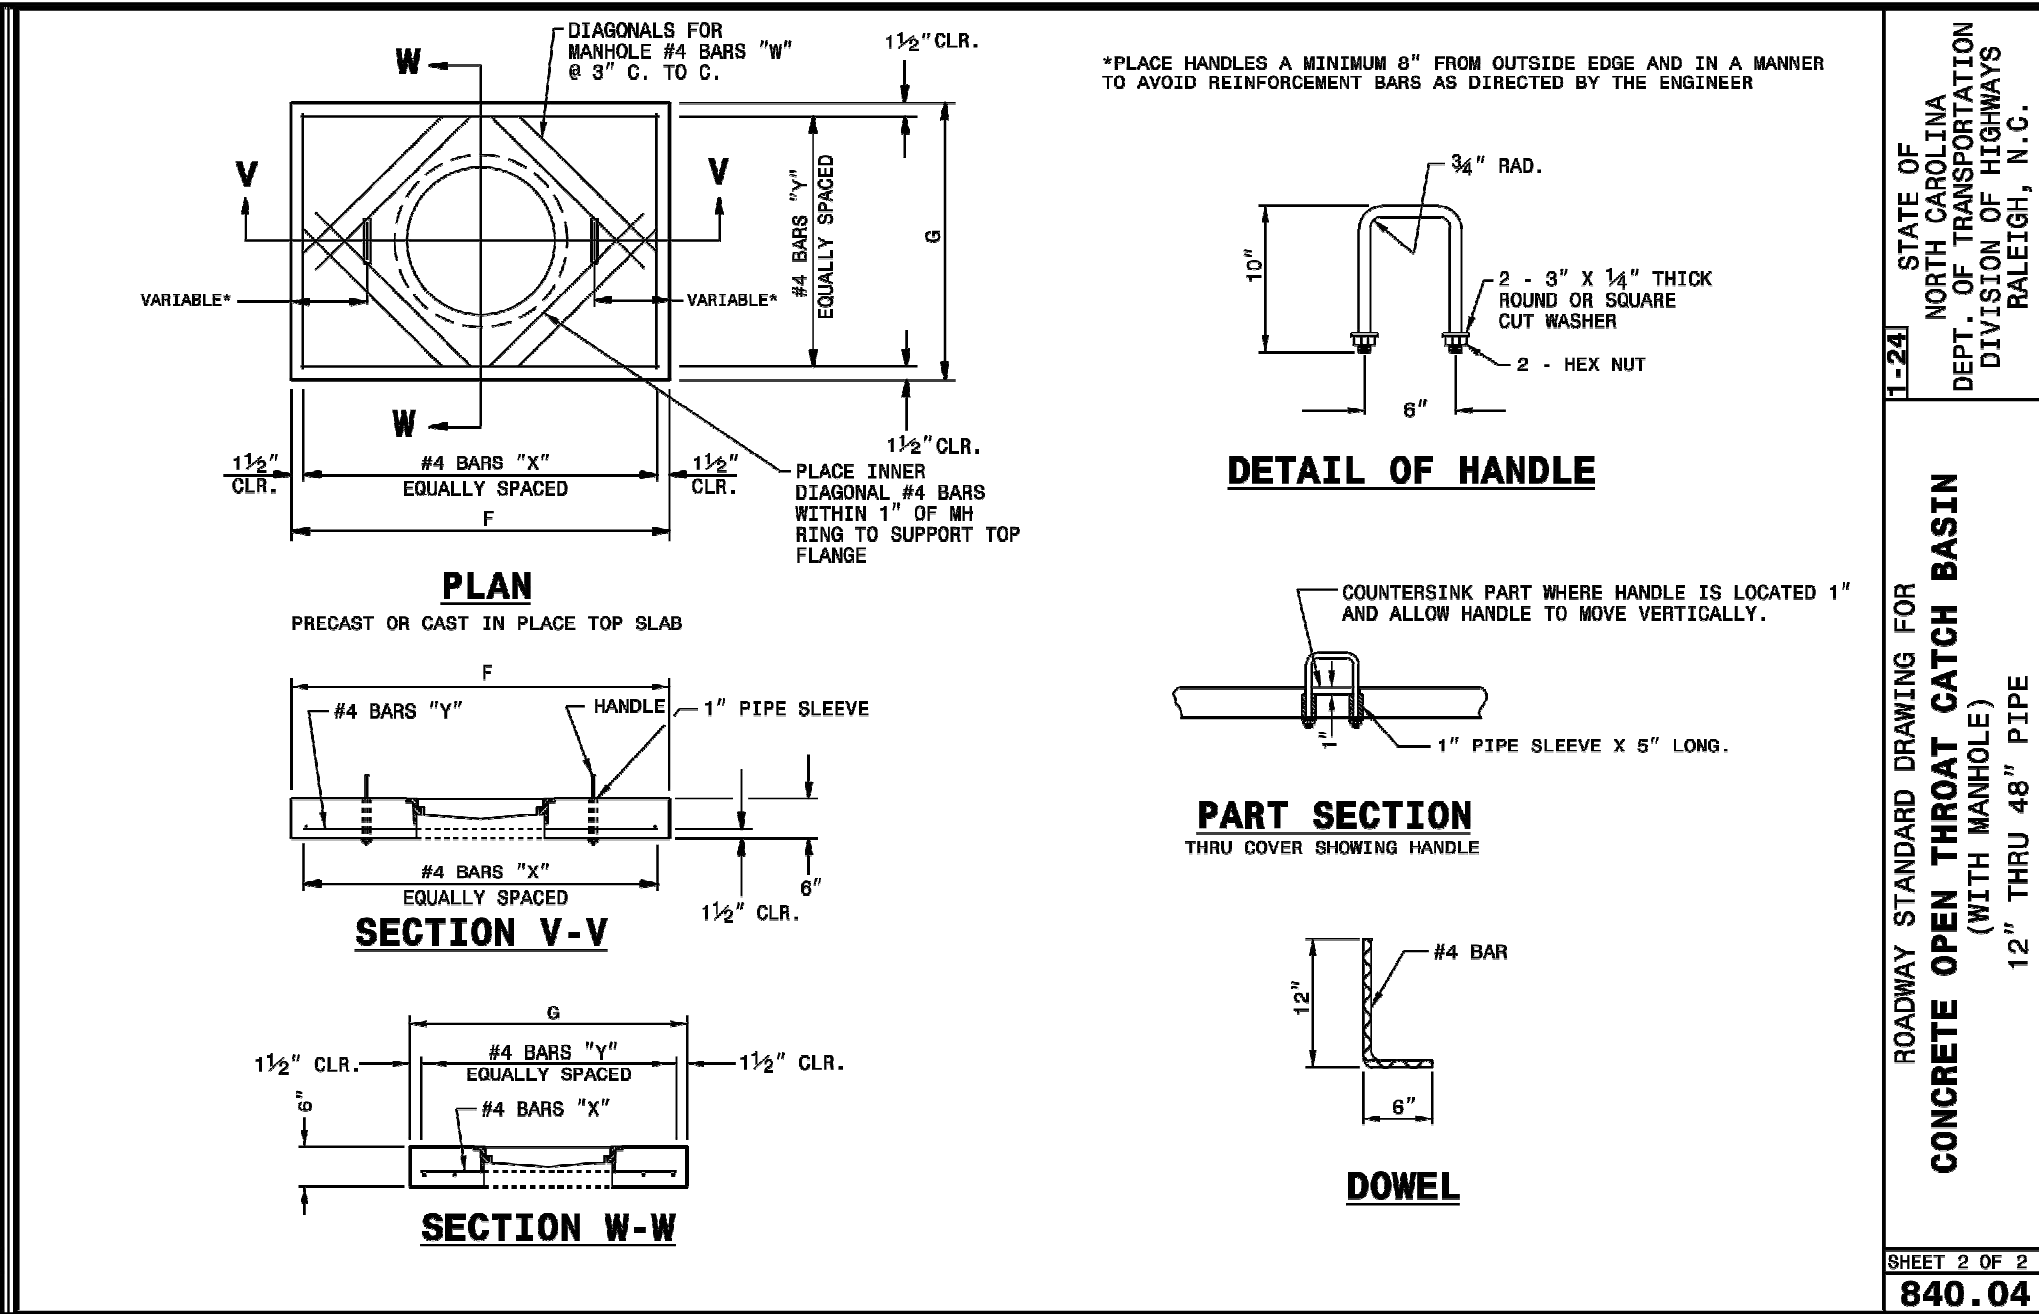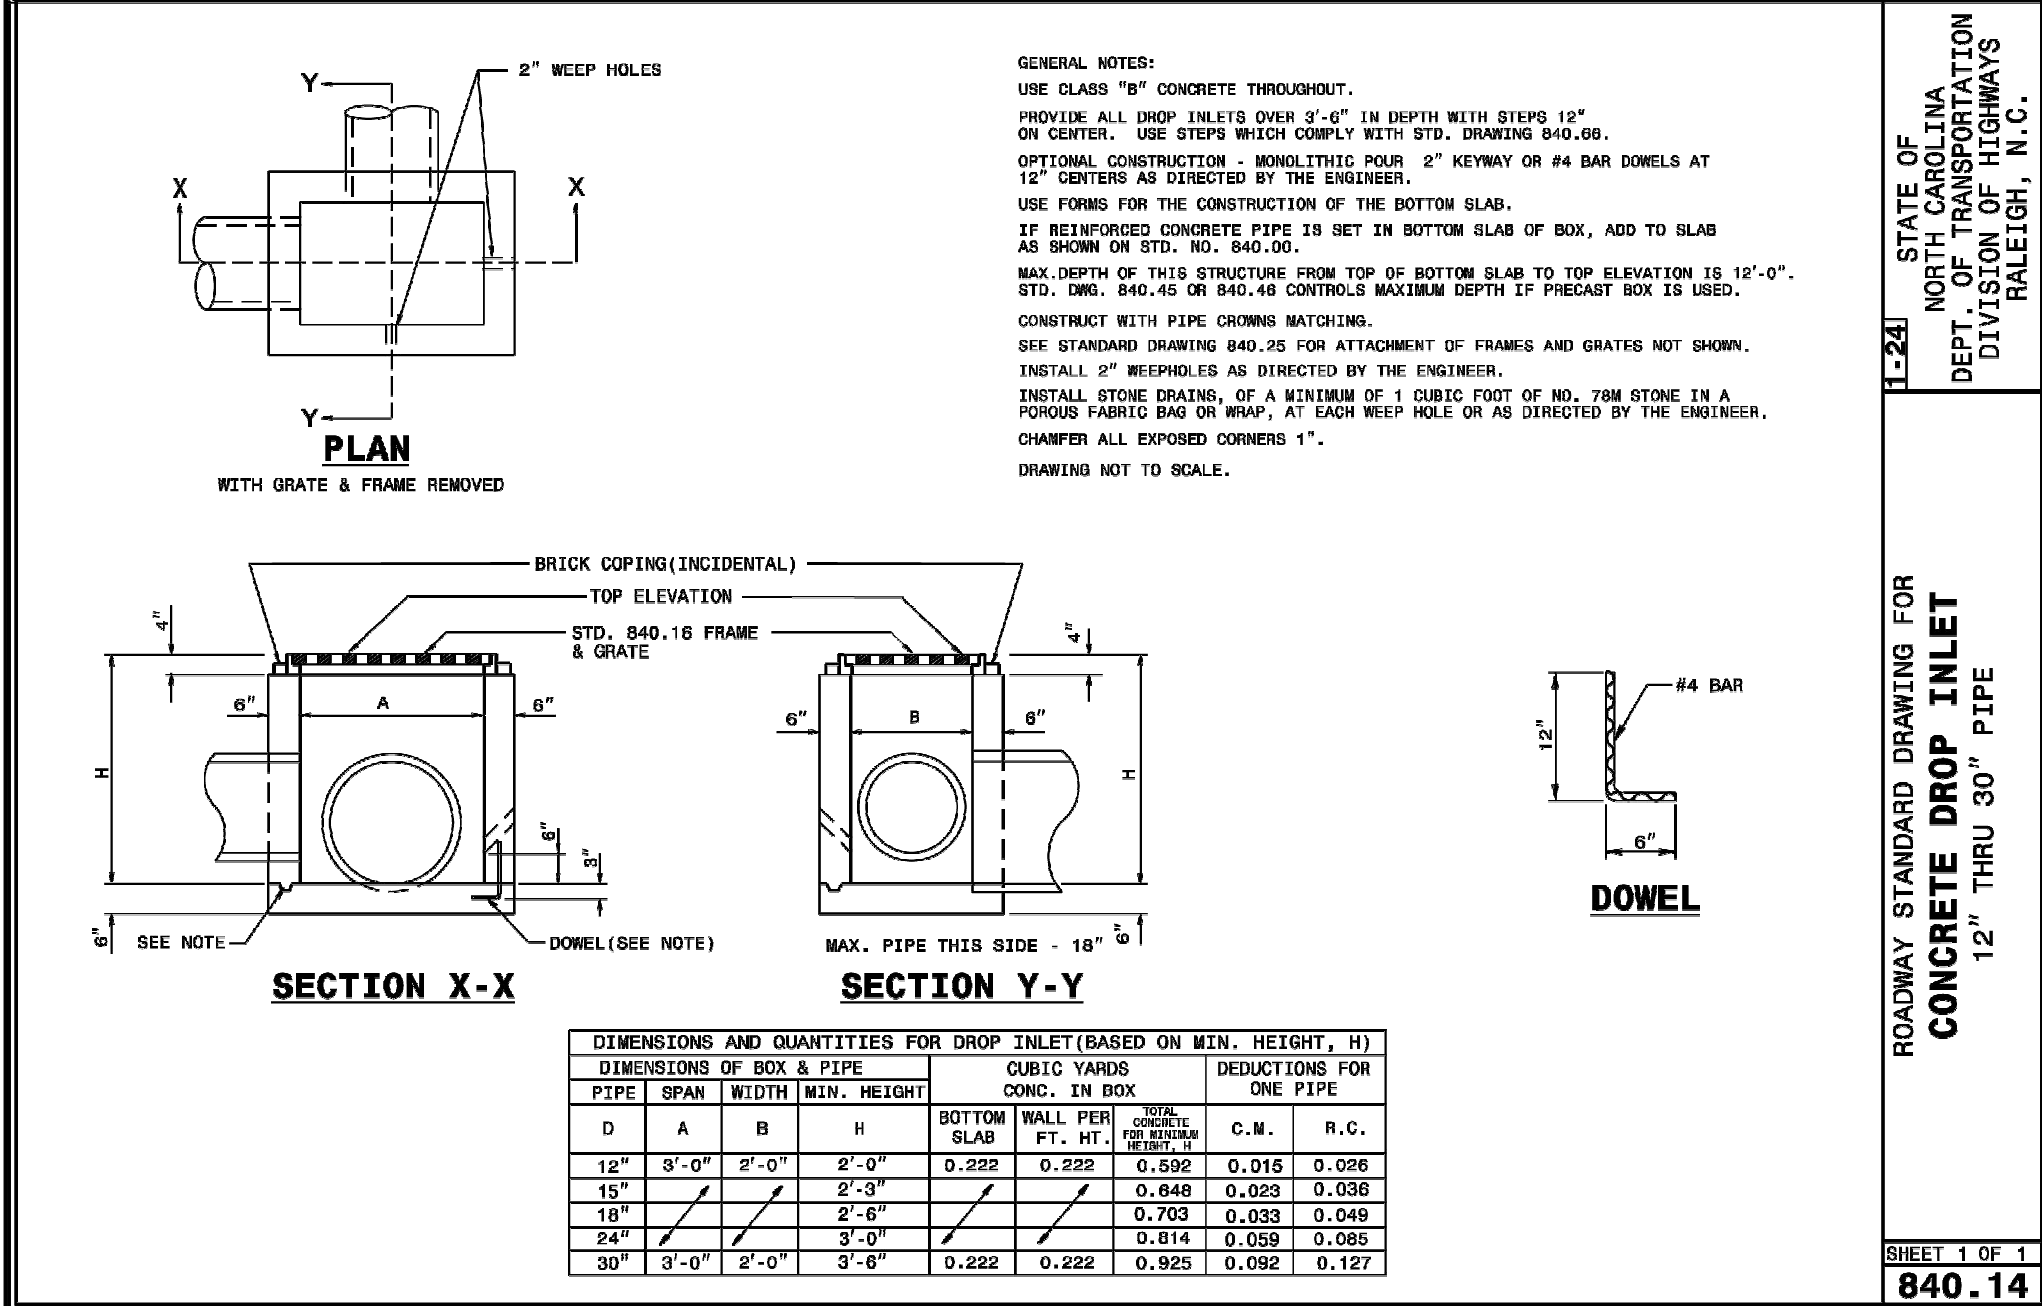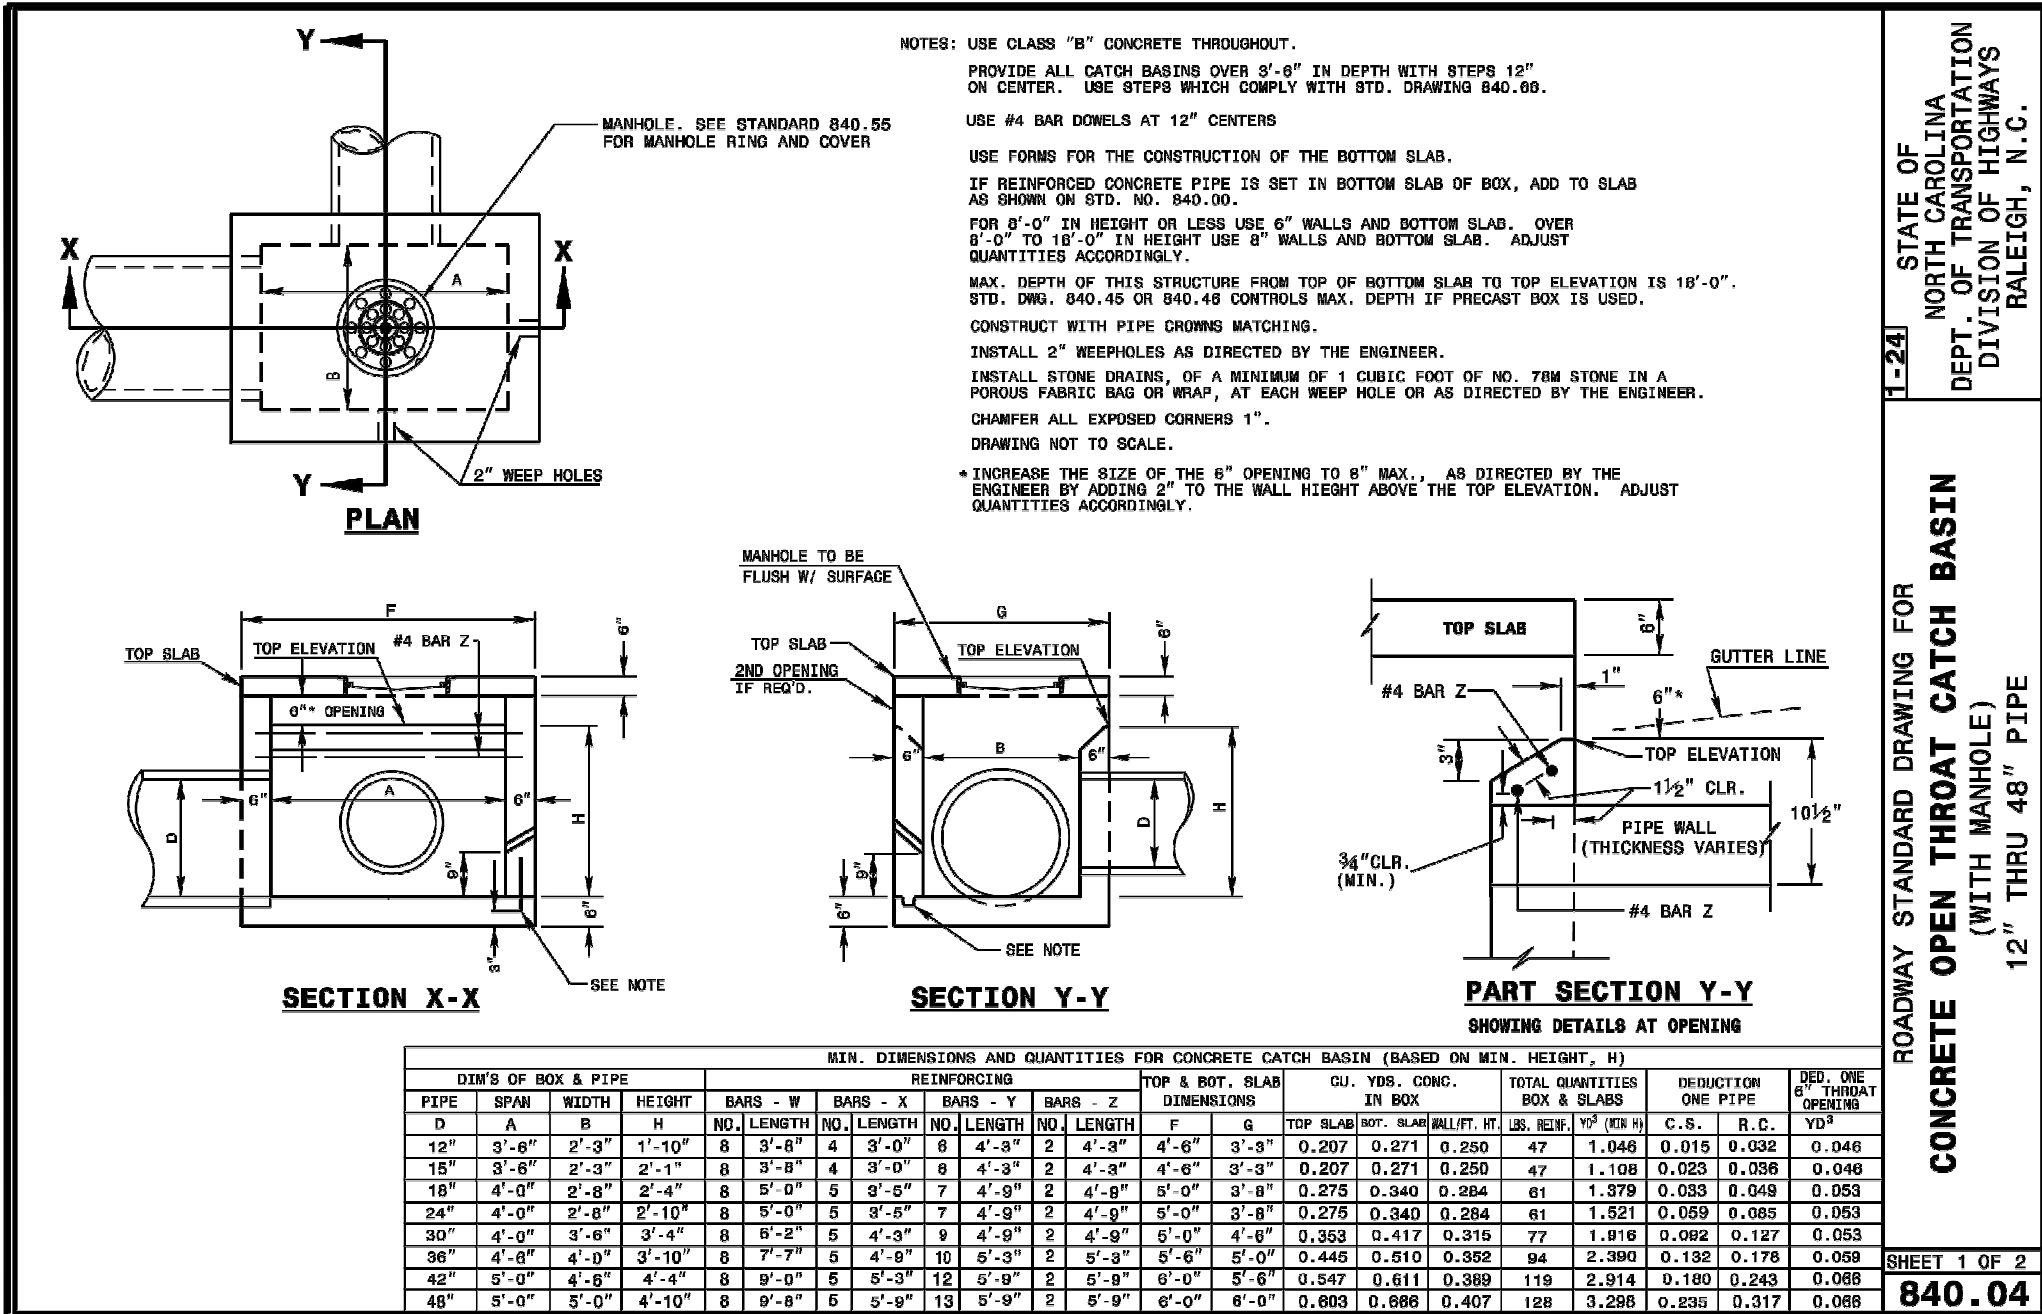

AMERICAN Engineering
American Engineering Associates - Southeast, P.A.
4020 Westchase Boulevard, Suite 450
Raleigh, NC 27607

Digitally signed by Jakob Klein
DN: cn=Jakob Klein, o=American Engineering Associates, ou=Southeast, c=US
Date: 2025.05.01 10:00:00 -0400

NOT FOR USE FOR CONSTRUCTION
KOB, P. KLEIN

FOR INFORMATION, ONLY


NO.	DATE	REVISION	CID	SUBMITTAL #1
1	12/23/2024			

STIPULATION FOR REUSE

THIS DRAWING WAS PREPARED FOR USE ON THE SPECIFIC SITE, NAMED HEREIN, CONTAINED HEREIN, AND IT IS NOT SUITABLE FOR USE ON A DIFFERENT PROJECT SITE OR AT A LATER TIME. USE OF THIS DRAWING FOR REFERENCE OR EXAMPLE ON ANOTHER PROJECT REQUIRES THE SERVICES OF PROPERLY LICENSED ARCHITECTS AND ENGINEERS. REPRODUCTION OF THIS DRAWING FOR REUSE ON ANOTHER PROJECT IS NOT AUTHORIZED AND MAY BE CONTRARY TO THE LAW.

KALAS FALLS
PHASE 5
CONSTRUCTION INFRASTRUCTURE DOCUMENTS
CID-25-01
TOWN OF ROLESVILLE,
WAKE COUNTY, NC

JOB NUMBER: R180115
CHECKED BY: JK
DRAWN BY: GE, RC
DATE: 05-01-2025
SHEET TITLE:
DRAINAGE DETAILS
SHEET NO.:
CD502


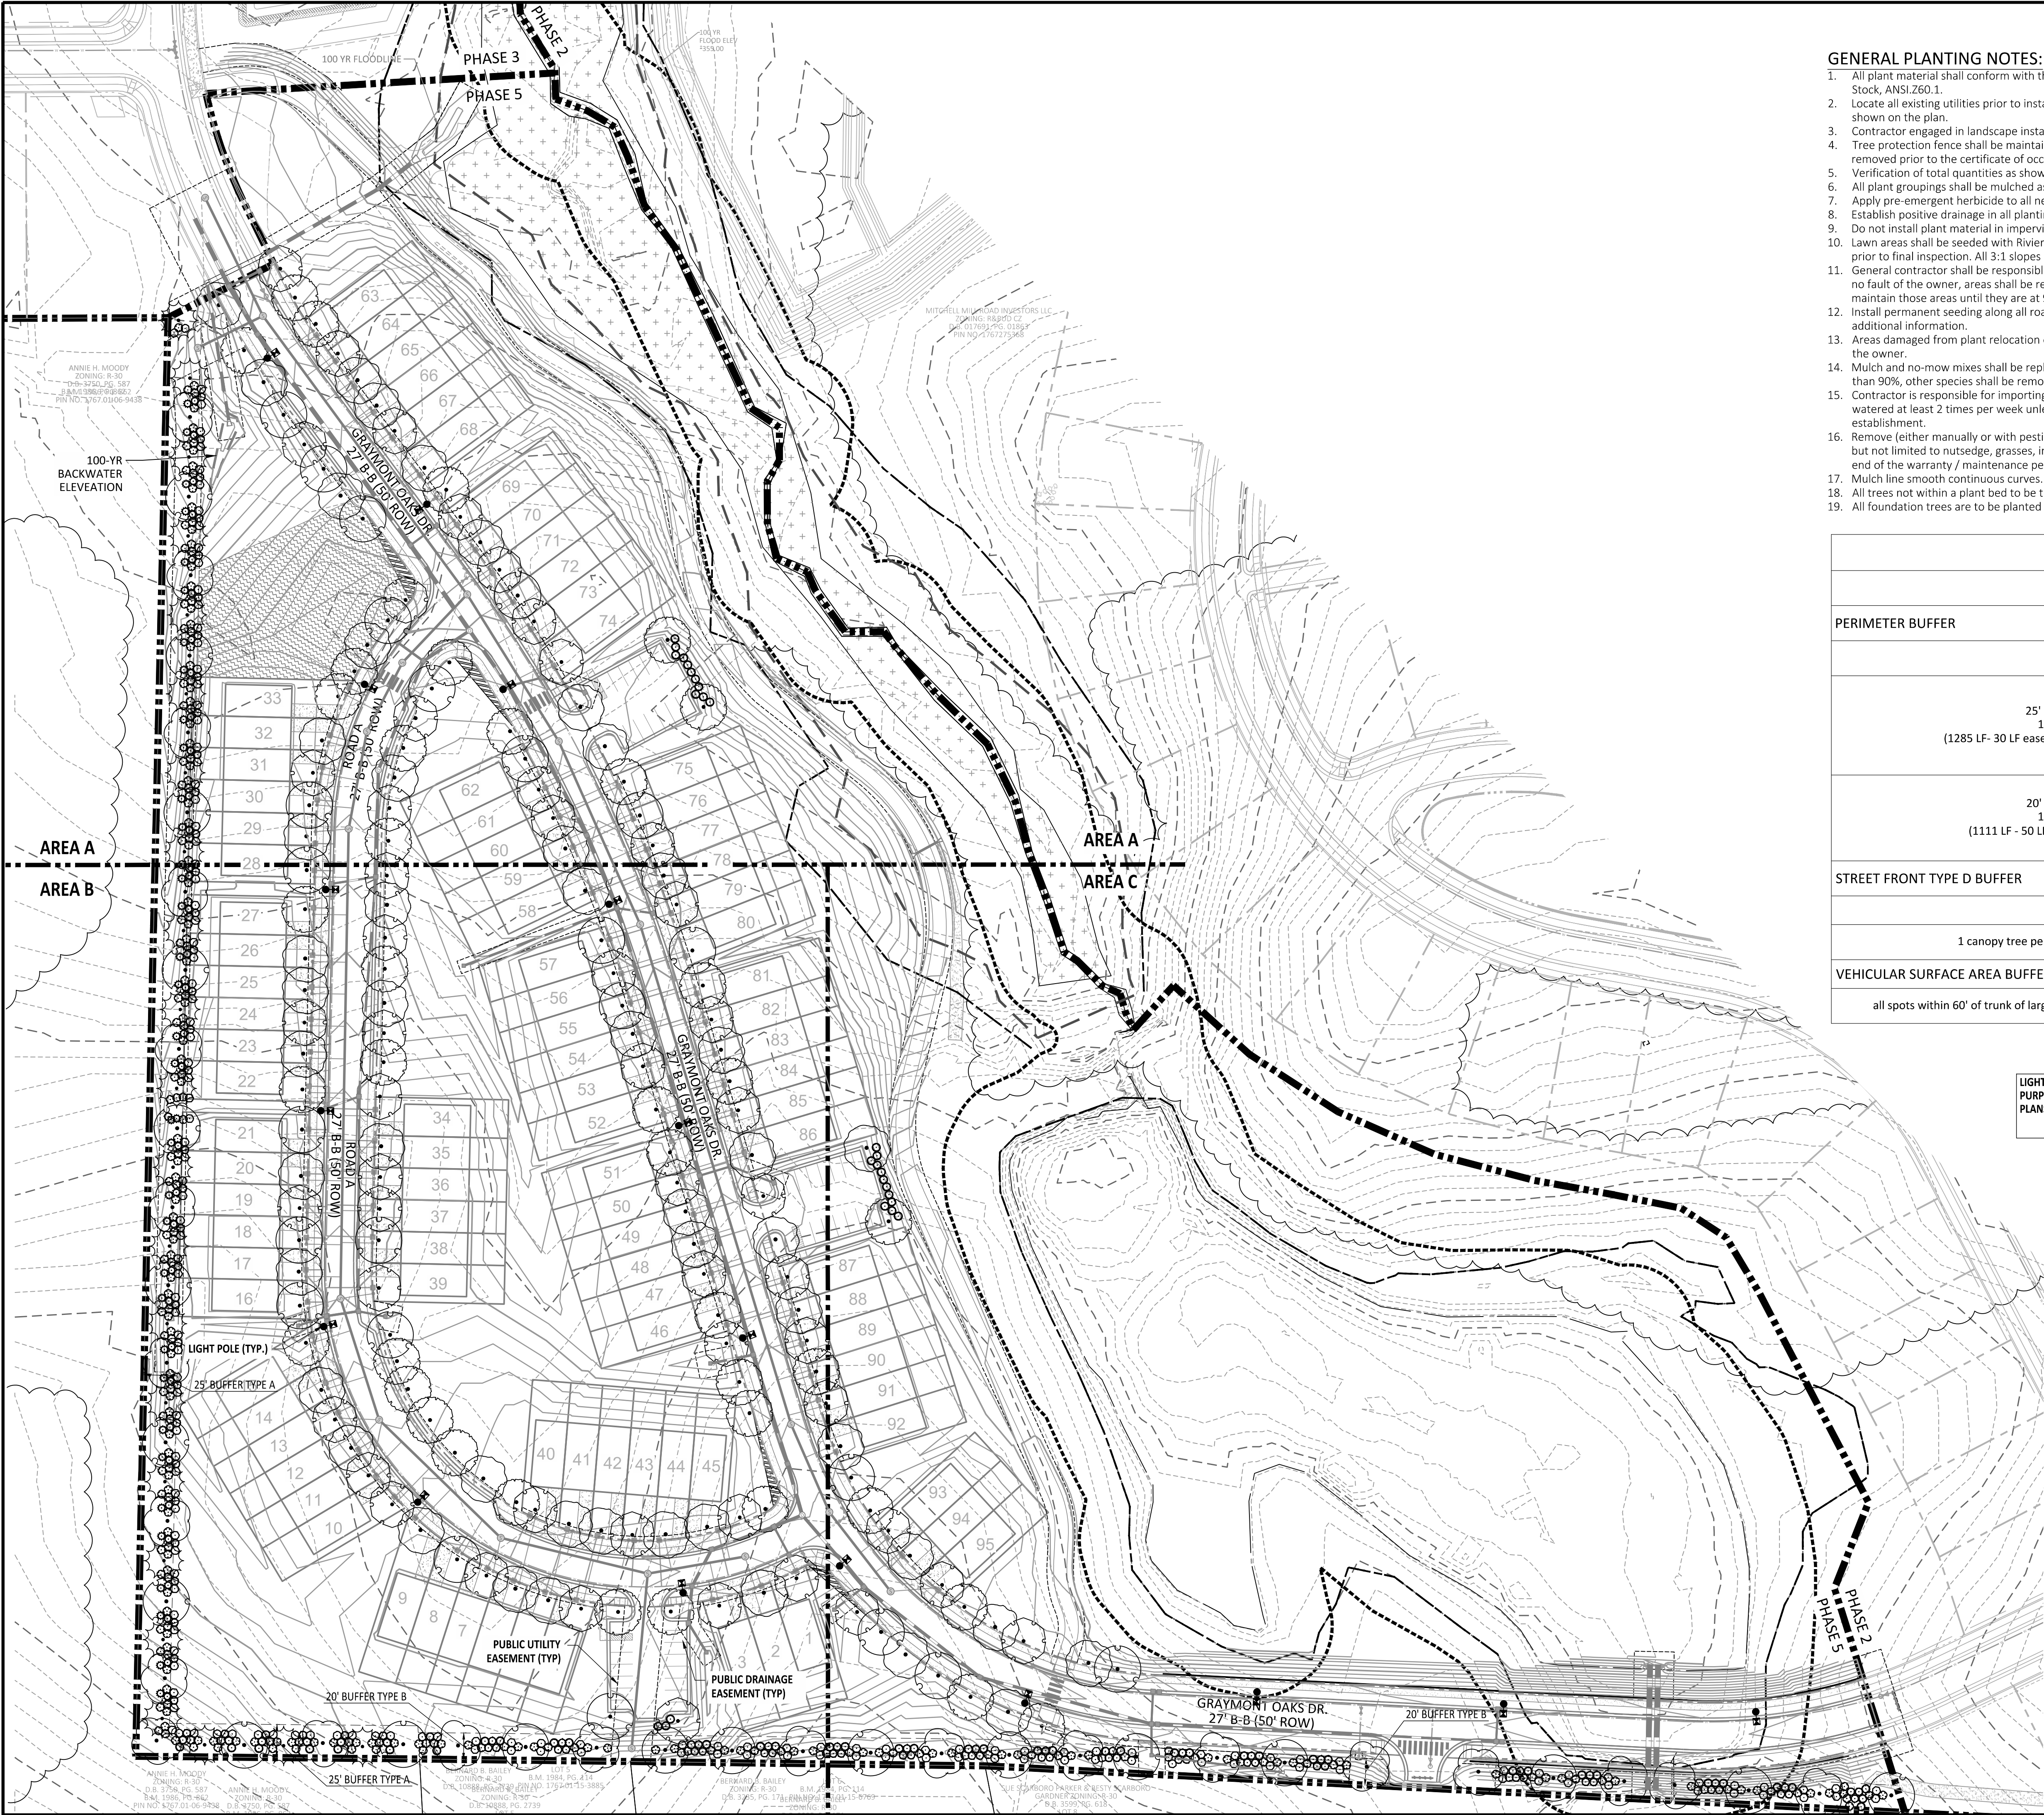


GENERAL PLANTING NOTES:

1. All plant material shall conform with the standards set forth by the American Association of Nurserymen, American Standard for Nursery Stock, ANSI.Z60.1.
2. Locate all existing utilities prior to installation of plant material. Notify owner of any discrepancies between field conditions and those shown on the plan.
3. Contractor engaged in landscape installation shall be a landscape contractor registered in the state of North Carolina.
4. Tree protection fence shall be maintained on site until all site work and the final site inspection is completed. The fencing shall be removed prior to the certificate of occupancy (CO) inspection is scheduled.
5. Verification of total quantities as shown on the plant list shall be the responsibility of the contractor.
6. All plant groupings shall be mulched as one bed. 3" of triple shredded hardwood mulch shall be used around all plantings.
7. Apply pre-emergent herbicide to all new planting beds at manufacturer's recommended rate prior to installation of mulch.
8. Establish positive drainage in all planting beds and away from buildings.
9. Do not install plant material in impervious soils, (i.e. holes which, when filled with water, do not completely drain within two hours.)
10. Lawn areas shall be seeded with Riviera or Sunstar Bermuda grass 95% coverage (based on a per square yard sample) shall be attained prior to final inspection. All 3:1 slopes shall be stabilized with biodegradable erosion control matting. See detail sheet seeding schedule.
11. General contractor shall be responsible for keeping all equipment & subcontractors away from seeded areas. If damage occurs, through no fault of the owner, areas shall be regraded and reseeded immediately at no additional cost to the owner. Contractor shall water and maintain those areas until they are at 95% coverage at final completion.
12. Install permanent seeding along all roadside ditches and channels within construction limits of project. see erosion control plans for additional information.
13. Areas damaged from plant relocation or other activities of landscape contractor to be reseeded and established at no additional cost to the owner.
14. Mulch and no-mow mixes shall be replenished as needed, especially after heavy rain events. If no-mow mix germinates at a rate of less than 90%, other species shall be removed and the area re-seeded.
15. Contractor is responsible for importing, testing, and preparing the soil on site per the recommendations of a soil test. Plants shall be watered at least 2 times per week unless soil is moist based on core sample or moisture meter reading. Water more frequently during establishment.
16. Remove (either manually or with pesticide treatment) all weeds in mulch areas, plant beds, tree rings, and hardscape areas: including but not limited to nutsedge, grasses, invasive plants, and any non-desirable plant material. This treatment shall occur monthly until the end of the warranty / maintenance period.
17. Mulch line smooth continuous curves.
18. All trees not within a plant bed to be treated with a 6-ft diameter mulch ring (typ).
19. All foundation trees are to be planted a minimum of 8' away from building wall. Notify Landscape Architect of any discrepancies.

LANDSCAPE REQUIREMENTS			
TYPE			UDO SECTION
PERIMETER BUFFER			
25' type A 1255 LF (1285 LF- 30 LF easement)	REQUIRED	PROVIDED	14.6.7 (1)
	50% of trees and shrubs evergreen Trees 10' between canopies at maturity	207 Evergreen Shrubs + 169 Deciduous Shrubs 22 Evergreen Trees + 21 Deciduous Trees	
20' type B 1061 LF (1111 LF - 50 LF R/W)	REQUIRED	PROVIDED	14.6.7 (2)
	50% of shrubs evergreen Trees 20' between canopies at maturity	121 Evergreen Shrubs + 104 Deciduous Shrubs 21 Deciduous Trees	
STREET FRONT TYPE D BUFFER			
1 canopy tree per 40 LF	REQUIRED	PROVIDED	14.6.7 (4)
	73	156	
VEHICULAR SURFACE AREA BUFFER			
all spots within 60' of trunk of large tree			14.7

LIGHT POLES SHOWN FOR COORDINATION PURPOSES ONLY. SEE DUKE ENERGY LIGHTING PLANS FOR DETAILS.

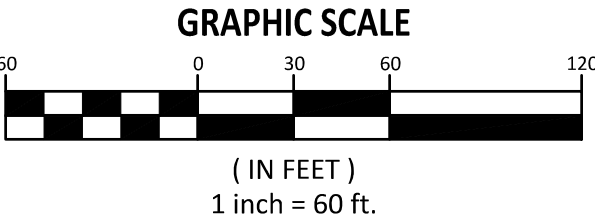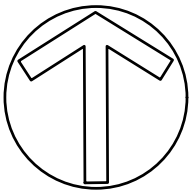

NO.	DATE	REVISION:	CID SUBMITTAL #1
1	12/23/2024		


STIPULATION FOR REUSE
THIS DRAWING WAS PREPARED FOR USE ON THE SPECIFIC SITE, NAMED HEREON, CONTEMPORANEOUSLY WITH ITS ISSUE DATE AS LISTED, HEREON, AND IT IS NOT SUITABLE FOR USE ON A DIFFERENT PROJECT SITE OR AT A LATER TIME. USE OF THIS DRAWING FOR REFERENCE OR EXAMPLE ON ANOTHER PROJECT REQUIRES THE SERVICES OF PROPERLY LICENSED ARCHITECTS AND ENGINEERS. REPRODUCTION OF THIS DRAWING FOR REUSE ON ANOTHER PROJECT IS NOT AUTHORIZED AND MAY BE CONTRARY TO THE LAW.

KALAS FALLS
PHASE 5
CONSTRUCTION INFRASTRUCTURE
DOCUMENTS
CID-25-01
TOWN OF ROLESVILLE,
WAKE COUNTY, NC

JOB NUMBER: R180115
CHECKED BY: JK
DRAWN BY: GE, RC
DATE: 05-01-2025

SHEET TITLE:
**LANDSCAPE
PLAN
OVERALL**

SHEET NO.:
LP100

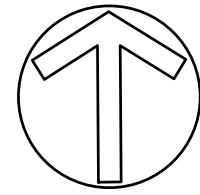


North Carolina 811
www.nc811.org

*** 3 Days Before Digging ***

North Carolina 811
811 or 1-800-632-4949
Remote Ticket Entry
<http://nc811.org/remoteticketentry.htm>



PLANT SCHEDULE AREA B						
CODE	BOTANICAL / COMMON NAME	CAL	CONT	SIZE	QTY	REMARKS
CANOPY TREES						
ACE APL	Acer rubrum 'Built to Last' / Built to Last® Red Maple	2.5" Cal.		8' Height Min.	28	Single straight leader.
CAR CNR	Carpinus caroliniana 'CCMTF1' / Collynair® American Hornbeam	2.5" Cal.		8' Height Min.	11	Single straight leader.
PLA OCC	Platanus occidentalis / American Sycamore	2.5" Cal.		8' Height Min.	21	Single straight leader.
QUE RUB	Quercus rubra / Northern Red Oak	2.5" Cal.		8' Height Min.	32	Single straight leader.
ULM NEW	Ulmus americana 'New Harmony' / New Harmony American Elm	2.5" Cal.		8' Height Min.	21	Single straight leader.
EVERGREEN TREES						
JUN PDC	Juniperus virginiana 'Providence' / Providence Eastern Redcedar	2.5" Cal.		8' Height Min.	14	Single straight leader.
CODE	BOTANICAL / COMMON NAME	SIZE	CONTAINER		QTY	REMARKS
DECIDUOUS SHRUBS						
CAL AME	Callicarpa americana / American Beautyberry	18" Height Min.	3 gal		69	Fully rooted.
CEP SPU	Cephalanthus occidentalis 'Sputnik' / Sputnik Buttonbush	18" Height Min.	3 gal		76	Fully rooted.
EVERGREEN SHRUBS						
GAU PRO	Gaultheria procumbens / Wintergreen	18" Height Min.	3 gal		68	Fully rooted.
ILE GLA	Ilex glabra / Inkberry Holly	18" Height Min.	3 gal		25	Fully rooted.
MOR AEH	Morella cerifera 'Nana' / Dwarf Southern Wax Myrtle	18" Height Min.	3 gal		41	Fully rooted.
RHO NO4	Rhododendron catawbiense 'Nova Zembla' / Catawba Rhododendron	18" Height Min.	3 gal		44	Fully rooted.



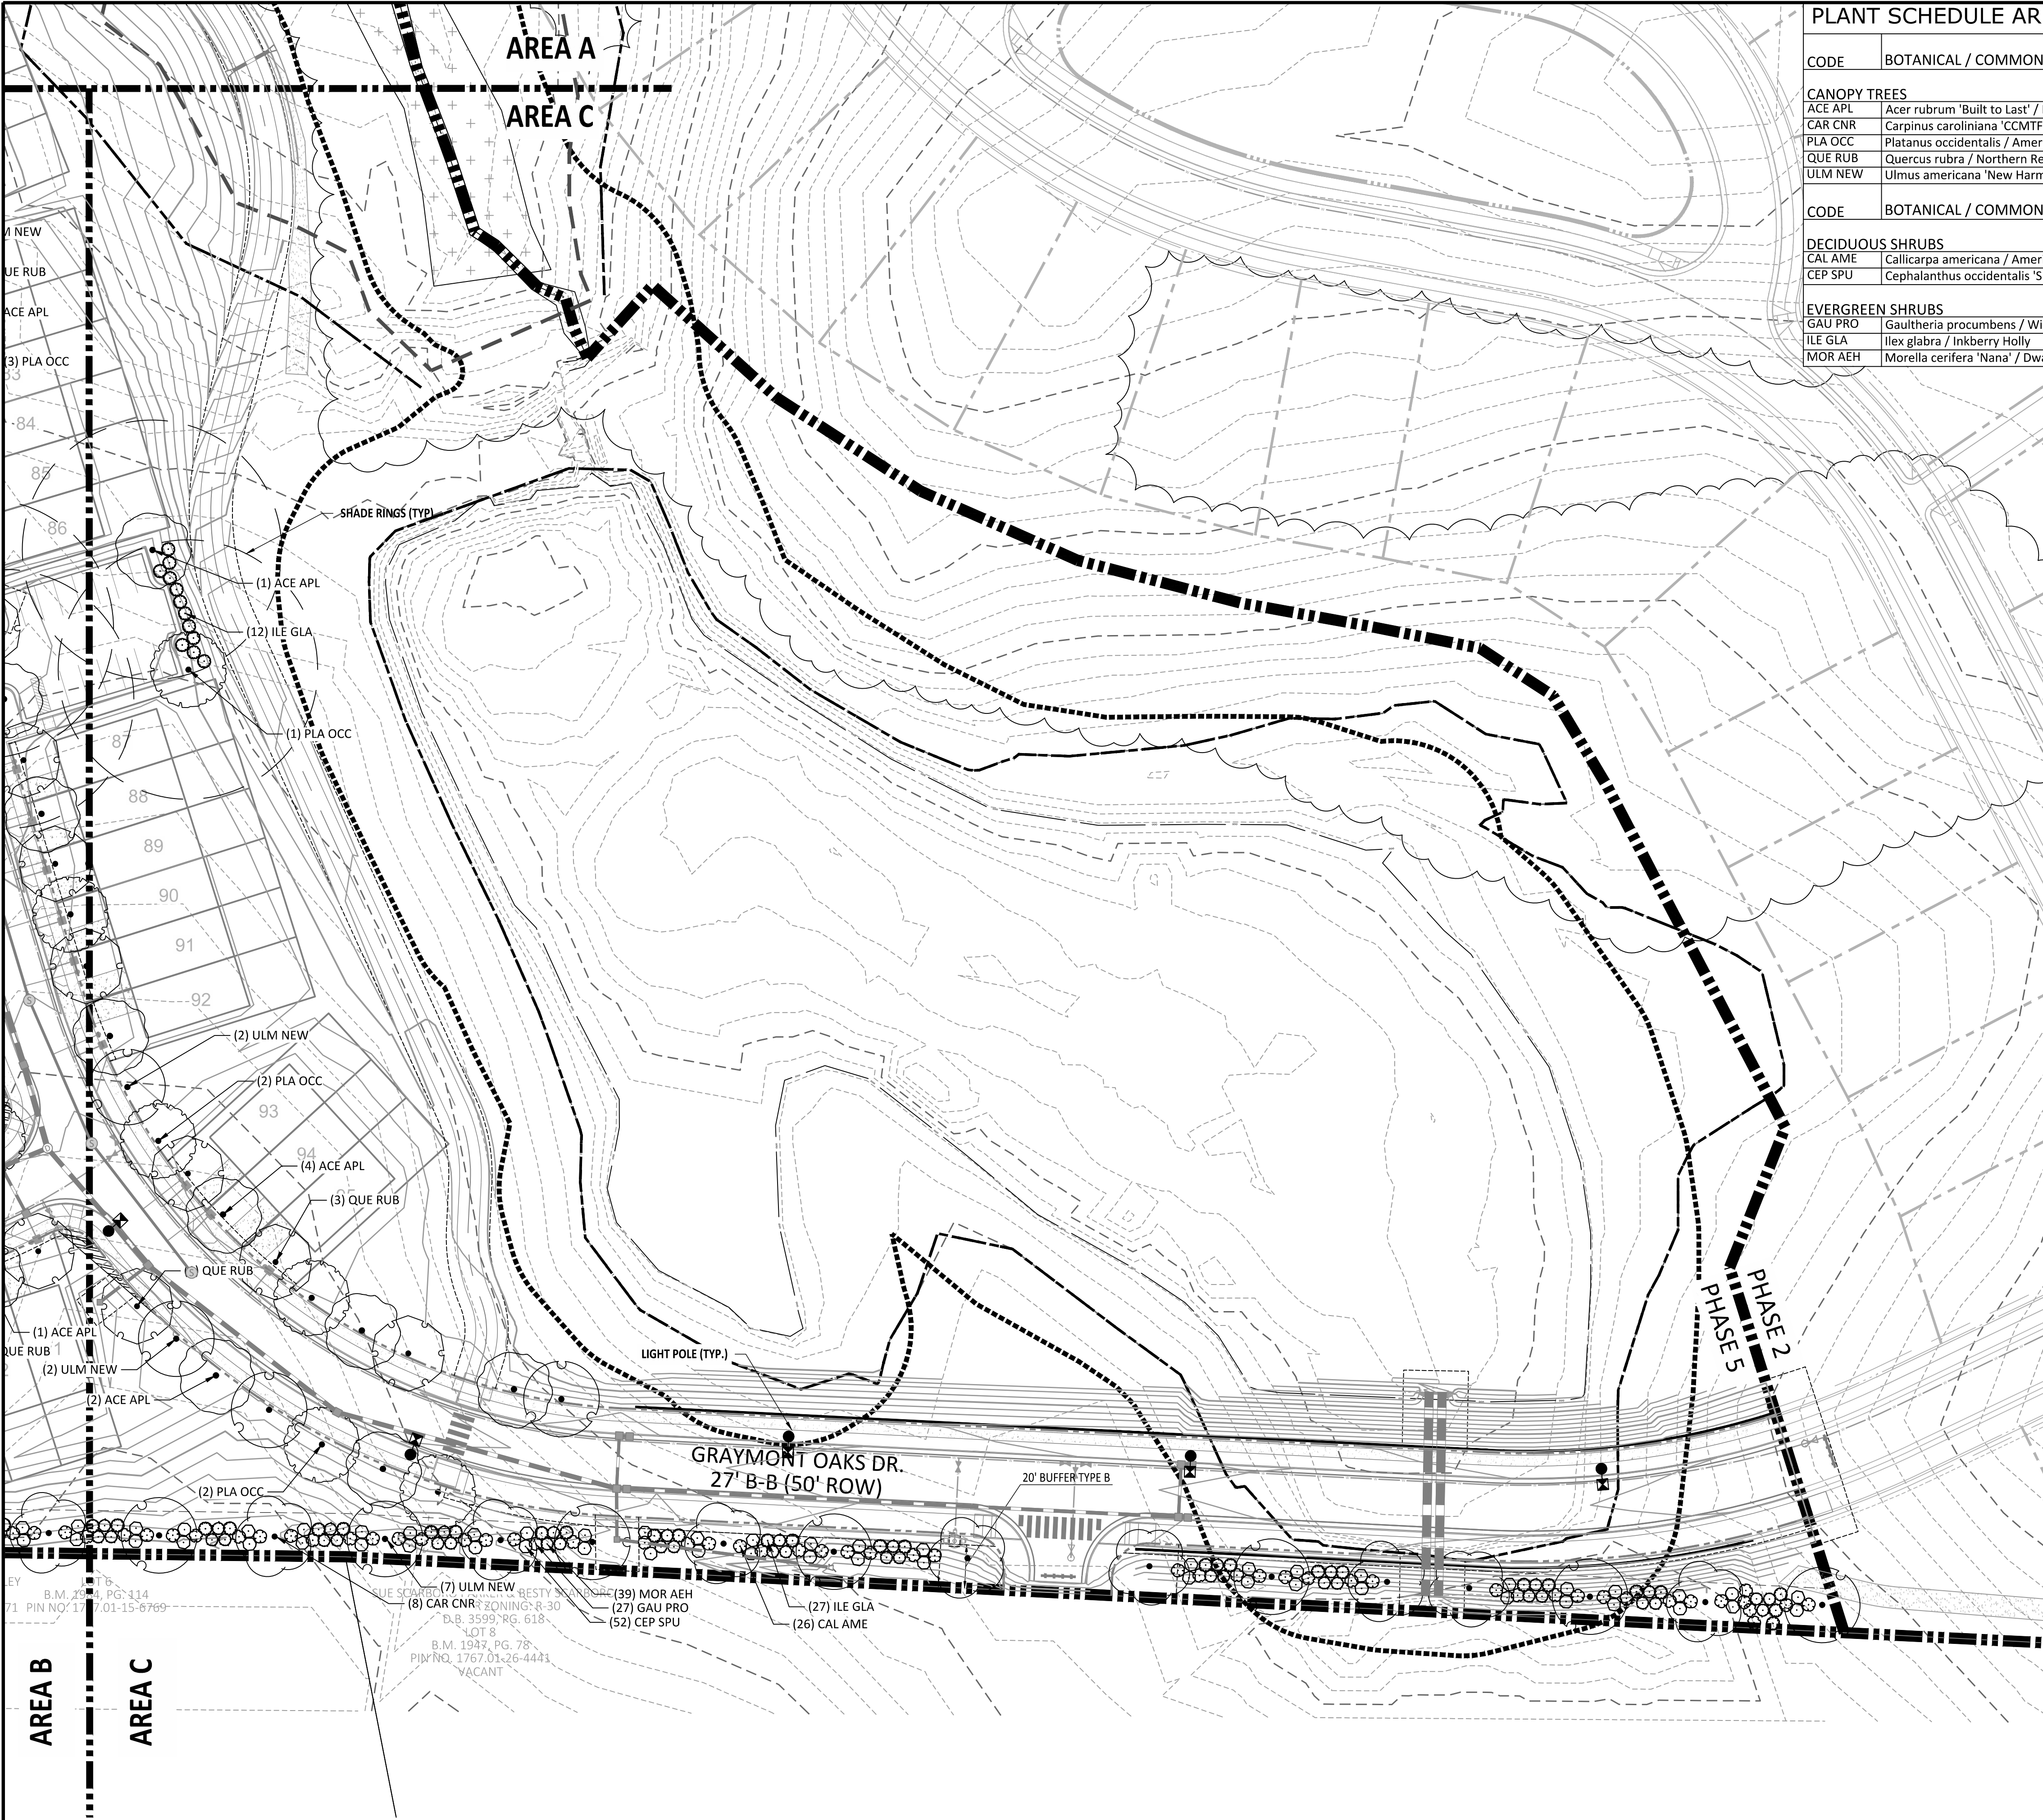

PLANT SCHEDULE AREA C

CODE	BOTANICAL / COMMON NAME	CAL	CONT	SIZE	QTY	REMARKS
CANOPY TREES						
ACE APL	Acer rubrum 'Built to Last' / Built to Last® Red Maple	2.5" Cal.		8' Height Min.	7	Single straight leader.
CAR CNR	Carpinus caroliniana 'CCMTF1' / Collynair® American Hornbeam	2.5" Cal.		8' Height Min.	8	Single straight leader.
PLA OCC	Platanus occidentalis / American Sycamore	2.5" Cal.		8' Height Min.	5	Single straight leader.
QUE RUB	Quercus rubra / Northern Red Oak	2.5" Cal.		8' Height Min.	4	Single straight leader.
ULM NEW	Ulmus americana 'New Harmony' / New Harmony American Elm	2.5" Cal.		8' Height Min.	11	Single straight leader.
CODE	BOTANICAL / COMMON NAME	SIZE	CONTAINER		QTY	REMARKS
DECIDUOUS SHRUBS						
CAL AME	Callicarpa americana / American Beautyberry	18" Height Min.	3 gal		25	Fully rooted.
CEP SPU	Cephalanthus occidentalis 'Sputnik' / Sputnik Buttonbush	18" Height Min.	3 gal		50	Fully rooted.
EVERGREEN SHRUBS						
GAU PRO	Gaultheria procumbens / Wintergreen	18" Height Min.	3 gal		27	Fully rooted.
ILE GLA	Ilex glabra / Inkberry Holly	18" Height Min.	3 gal		39	Fully rooted.
MOR AEH	Morella cerifera 'Nana' / Dwarf Southern Wax Myrtle	18" Height Min.	3 gal		39	Fully rooted.

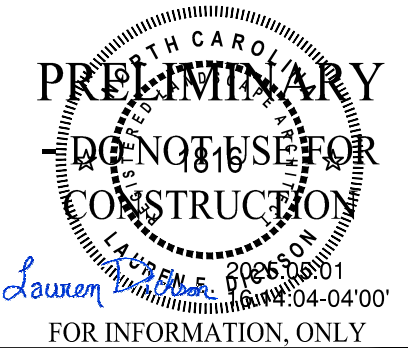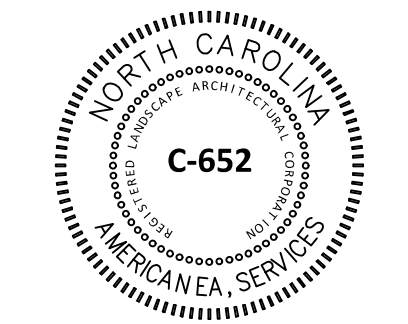



NO.	DATE	REVISION:
1	12/23/2024	CID SUBMITTAL #1


STIPULATION FOR REUSE
THIS DRAWING WAS PREPARED FOR USE ON THE SPECIFIC SITE, NAMED HEREON, CONTEMPORANEOUSLY WITH ITS ISSUE DATE AS LISTED, HEREON, AND IT IS NOT SUITABLE FOR USE ON A DIFFERENT PROJECT SITE OR AT A LATER TIME. USE OF THIS DRAWING FOR REFERENCE OR EXAMPLE ON ANOTHER PROJECT REQUIRES THE SERVICES OF PROPERLY LICENSED ARCHITECTS AND ENGINEERS. REPRODUCTION OF THIS DRAWING FOR REUSE ON ANOTHER PROJECT IS NOT AUTHORIZED AND MAY BE CONTRARY TO THE LAW.

KALAS FALLS
PHASE 5
CONSTRUCTION INFRASTRUCTURE
DOCUMENTS
CID-25-01
TOWN OF ROLESVILLE,
WAKE COUNTY, NC

JOB NUMBER: R180115
CHECKED BY: JK
DRAWN BY: GE, RC
DATE: 05-01-2025

SHEET TITLE:
**LANDSCAPE
PLAN AREA C**
SHEET NO.:
LP403

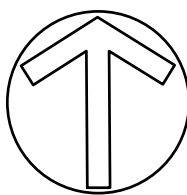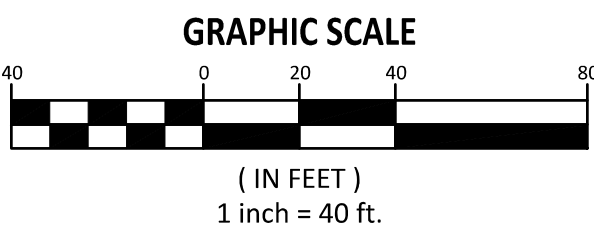

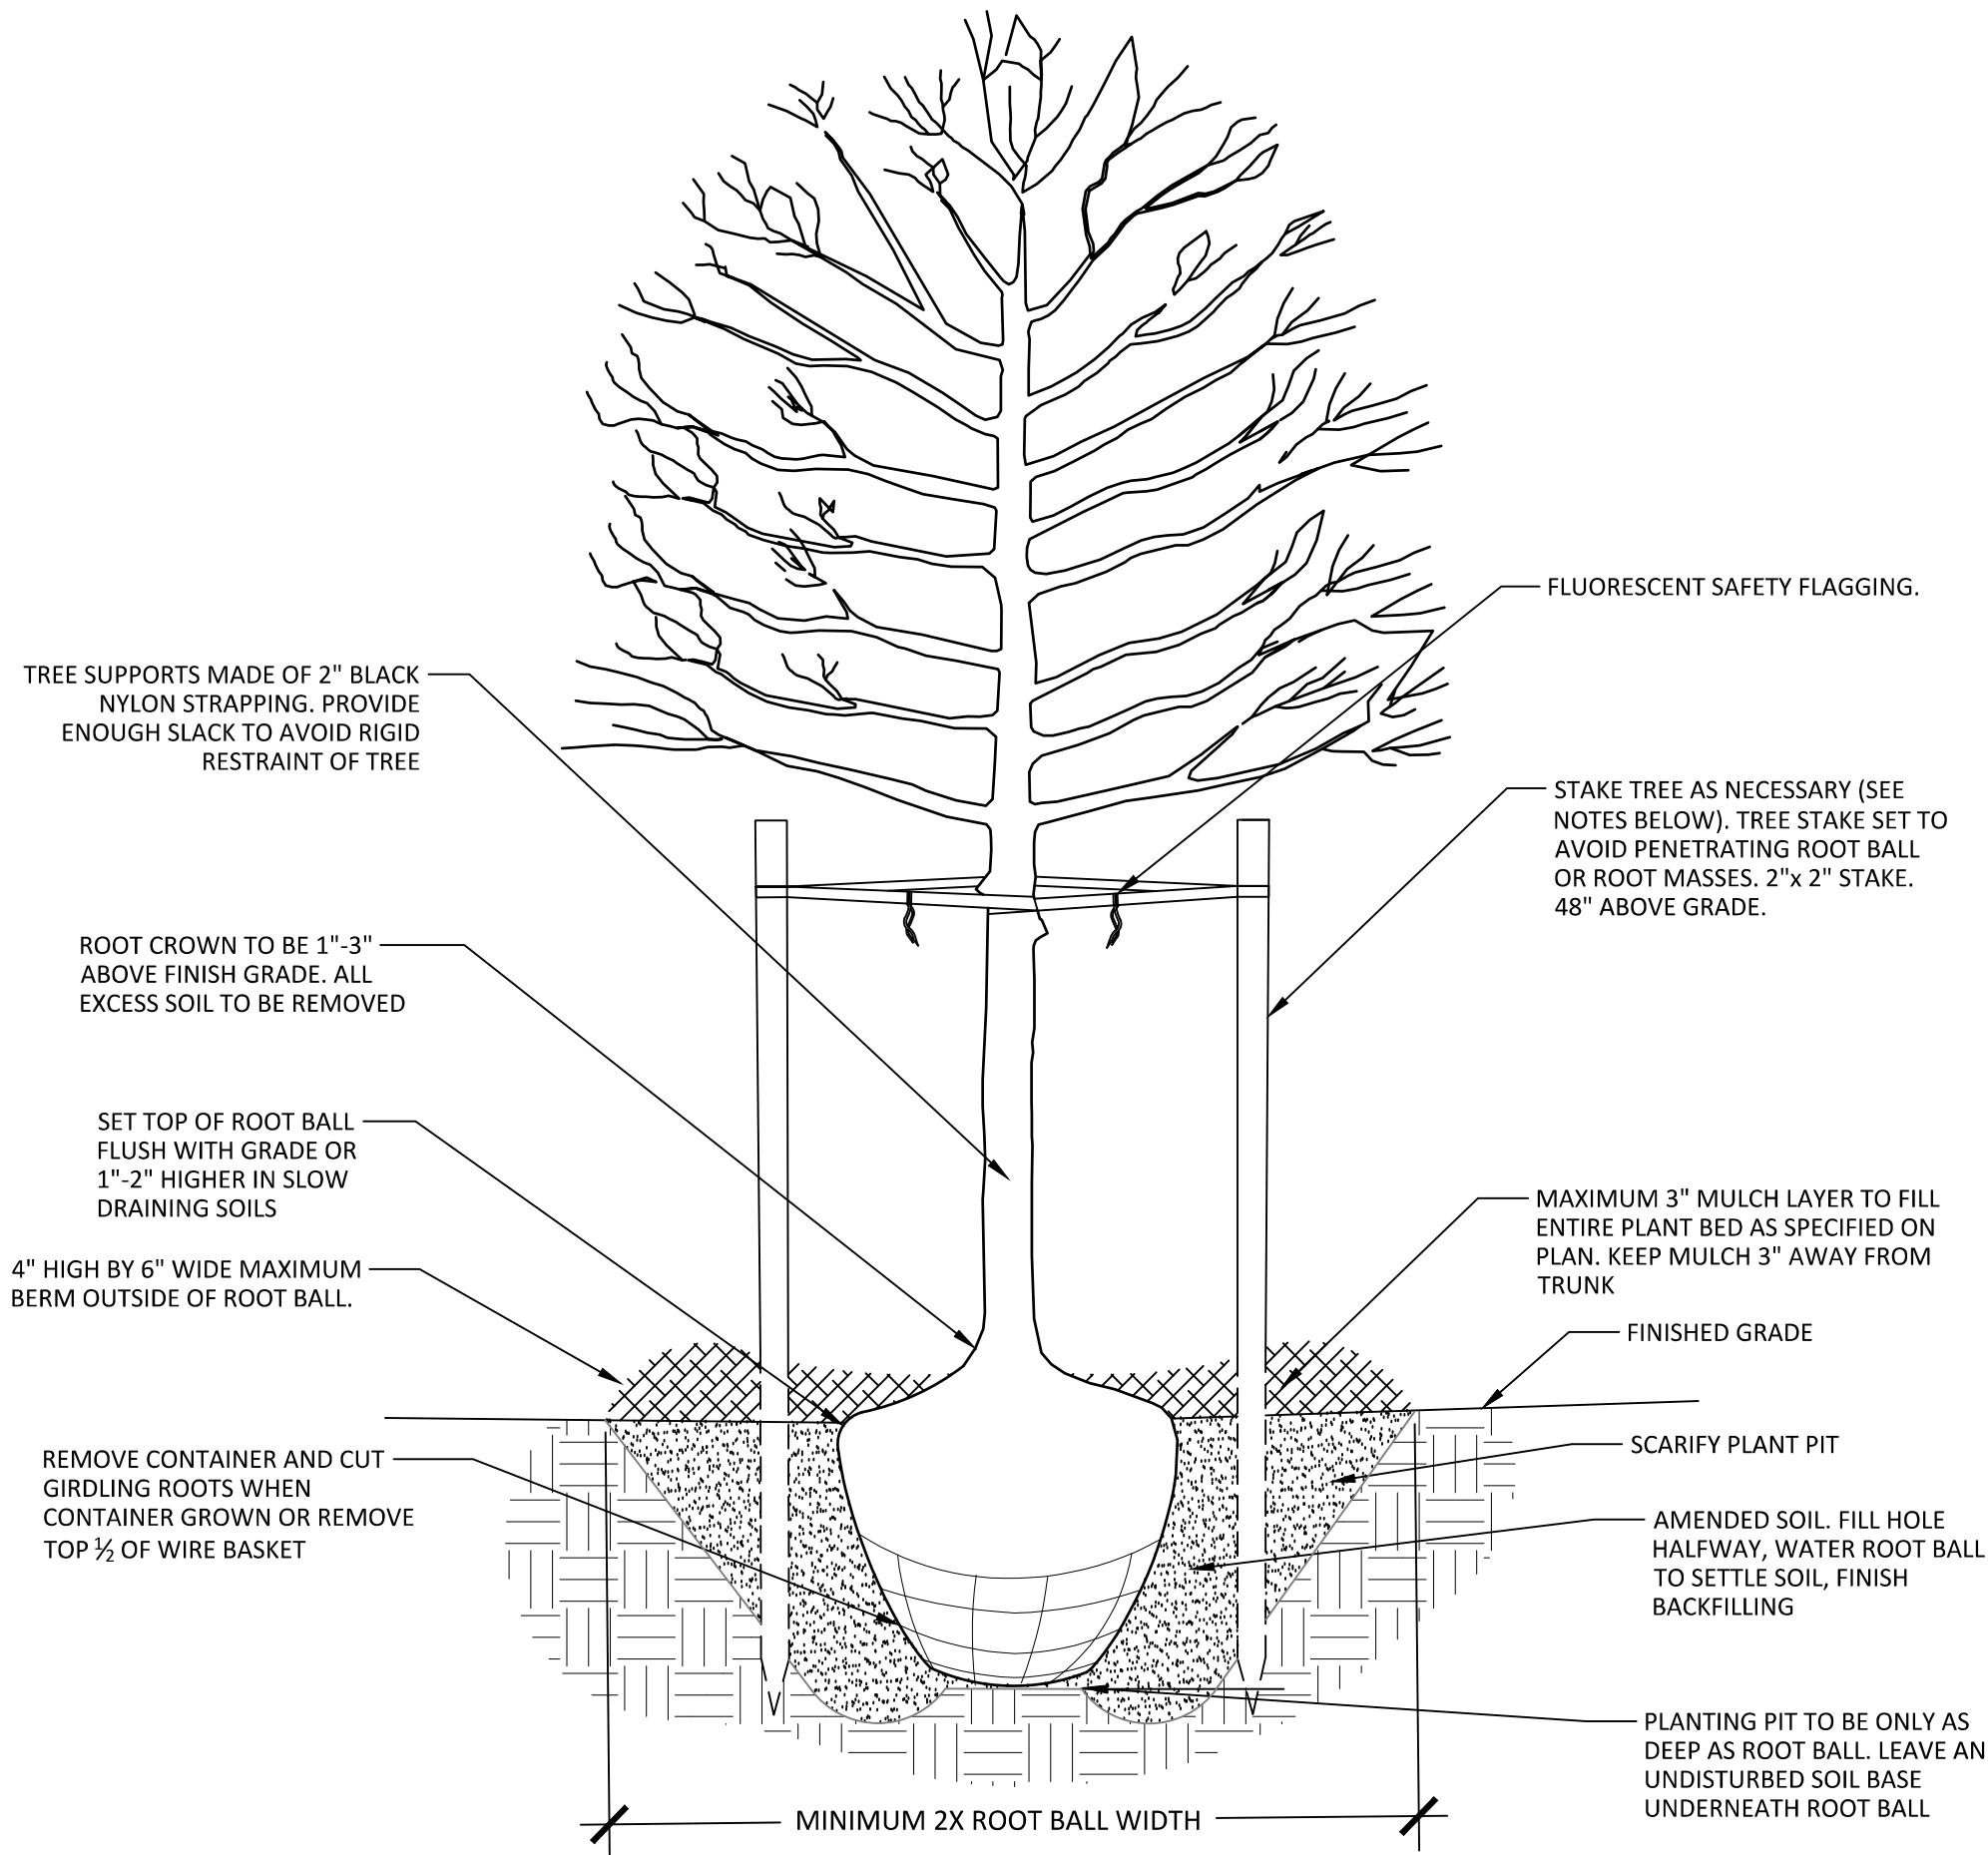


- NOTES
1. All trees shall meet American Standard for Nursery Stock (ANSI z60.1-2004)
 2. Remove wire and nylon twine from ball and canopy.
 3. Soak root ball and plant pit immediately after installation.
 4. Do not stake or wrap trunk unless:
 - a. Tree has a large crown.
 - b. Planting site is consistently windy or is a steep slope.
 - c. Planting site is susceptible to vandalism.
 6. Remove all staking material after 1 year.
 7. Remove all tags and labels from plant material.
 8. Do not heavily prune the tree at planting. Only prune crossover limbs, co-dominant leaders, and broken or dead branches. Do not remove the terminal buds of branches that extend to the edge of the crown. Some interior twigs and lateral branches may be pruned.

1 TYPICAL TREE PLANTING

NOT TO SCALE

P-R-01

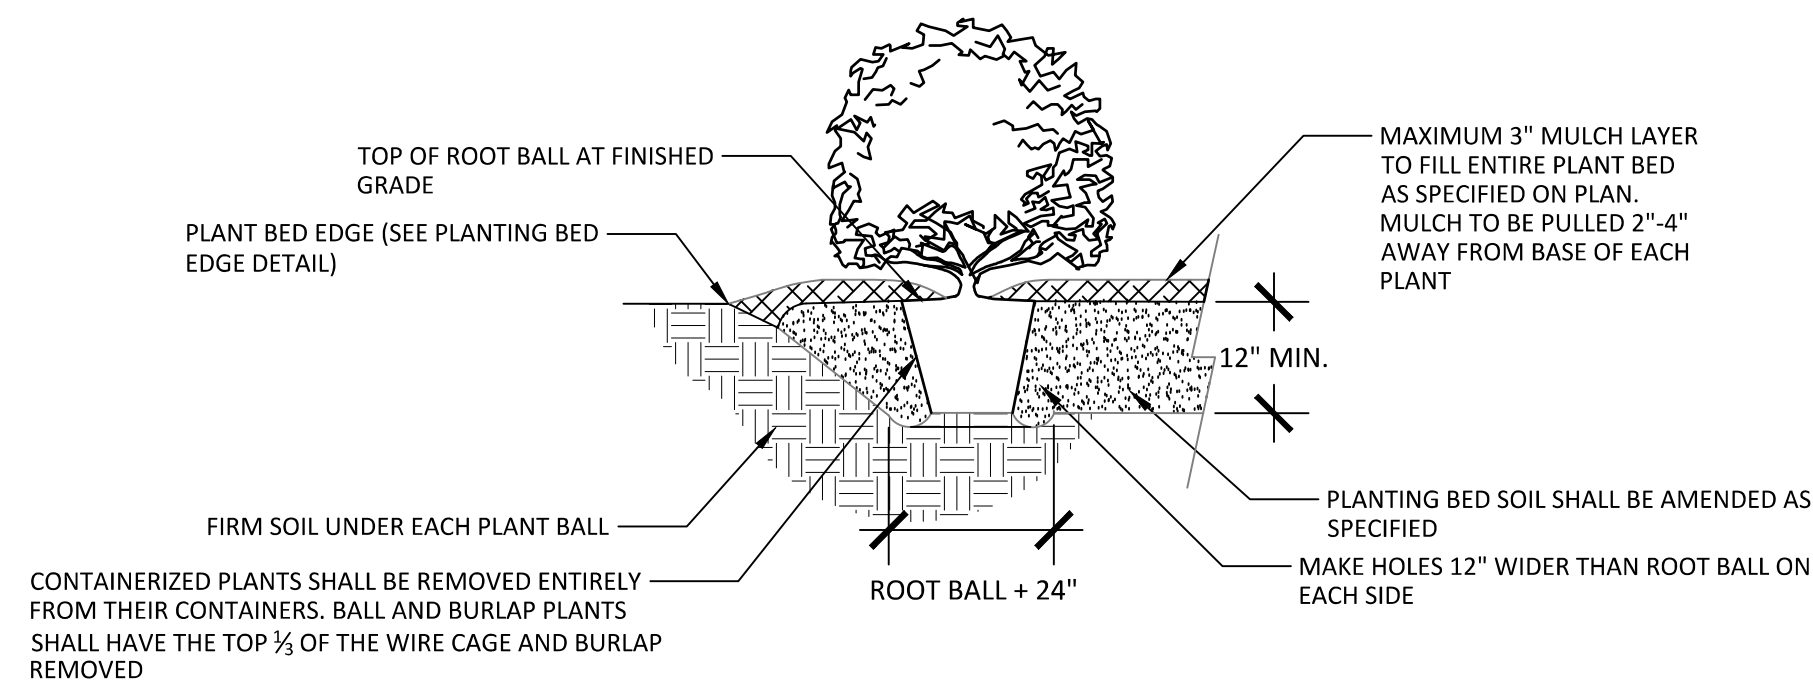


- NOTES
1. SCARIFY ROOT MASS OF CONTAINERIZED PLANTS.
 2. PLANT ROOT BALL SHOULD BE INSTALLED 1"-3" MAXIMUM ABOVE FINISHED GRADE.
 3. WATER EACH PLANT IMMEDIATELY AFTER INSTALLATION AND BEFORE INSTALLATION OF MULCH.
 4. PLANT PITS ONLY FOR SINGLE PLANTS. FOR PLANT BEDS, PREPARE THE ENTIRE BED AREA.
 5. SPACING OF SHRUBS VARIES, REFER TO LANDSCAPE PLANS.

2 TYPICAL SHRUB PLANTING

NOT TO SCALE

P-R-02

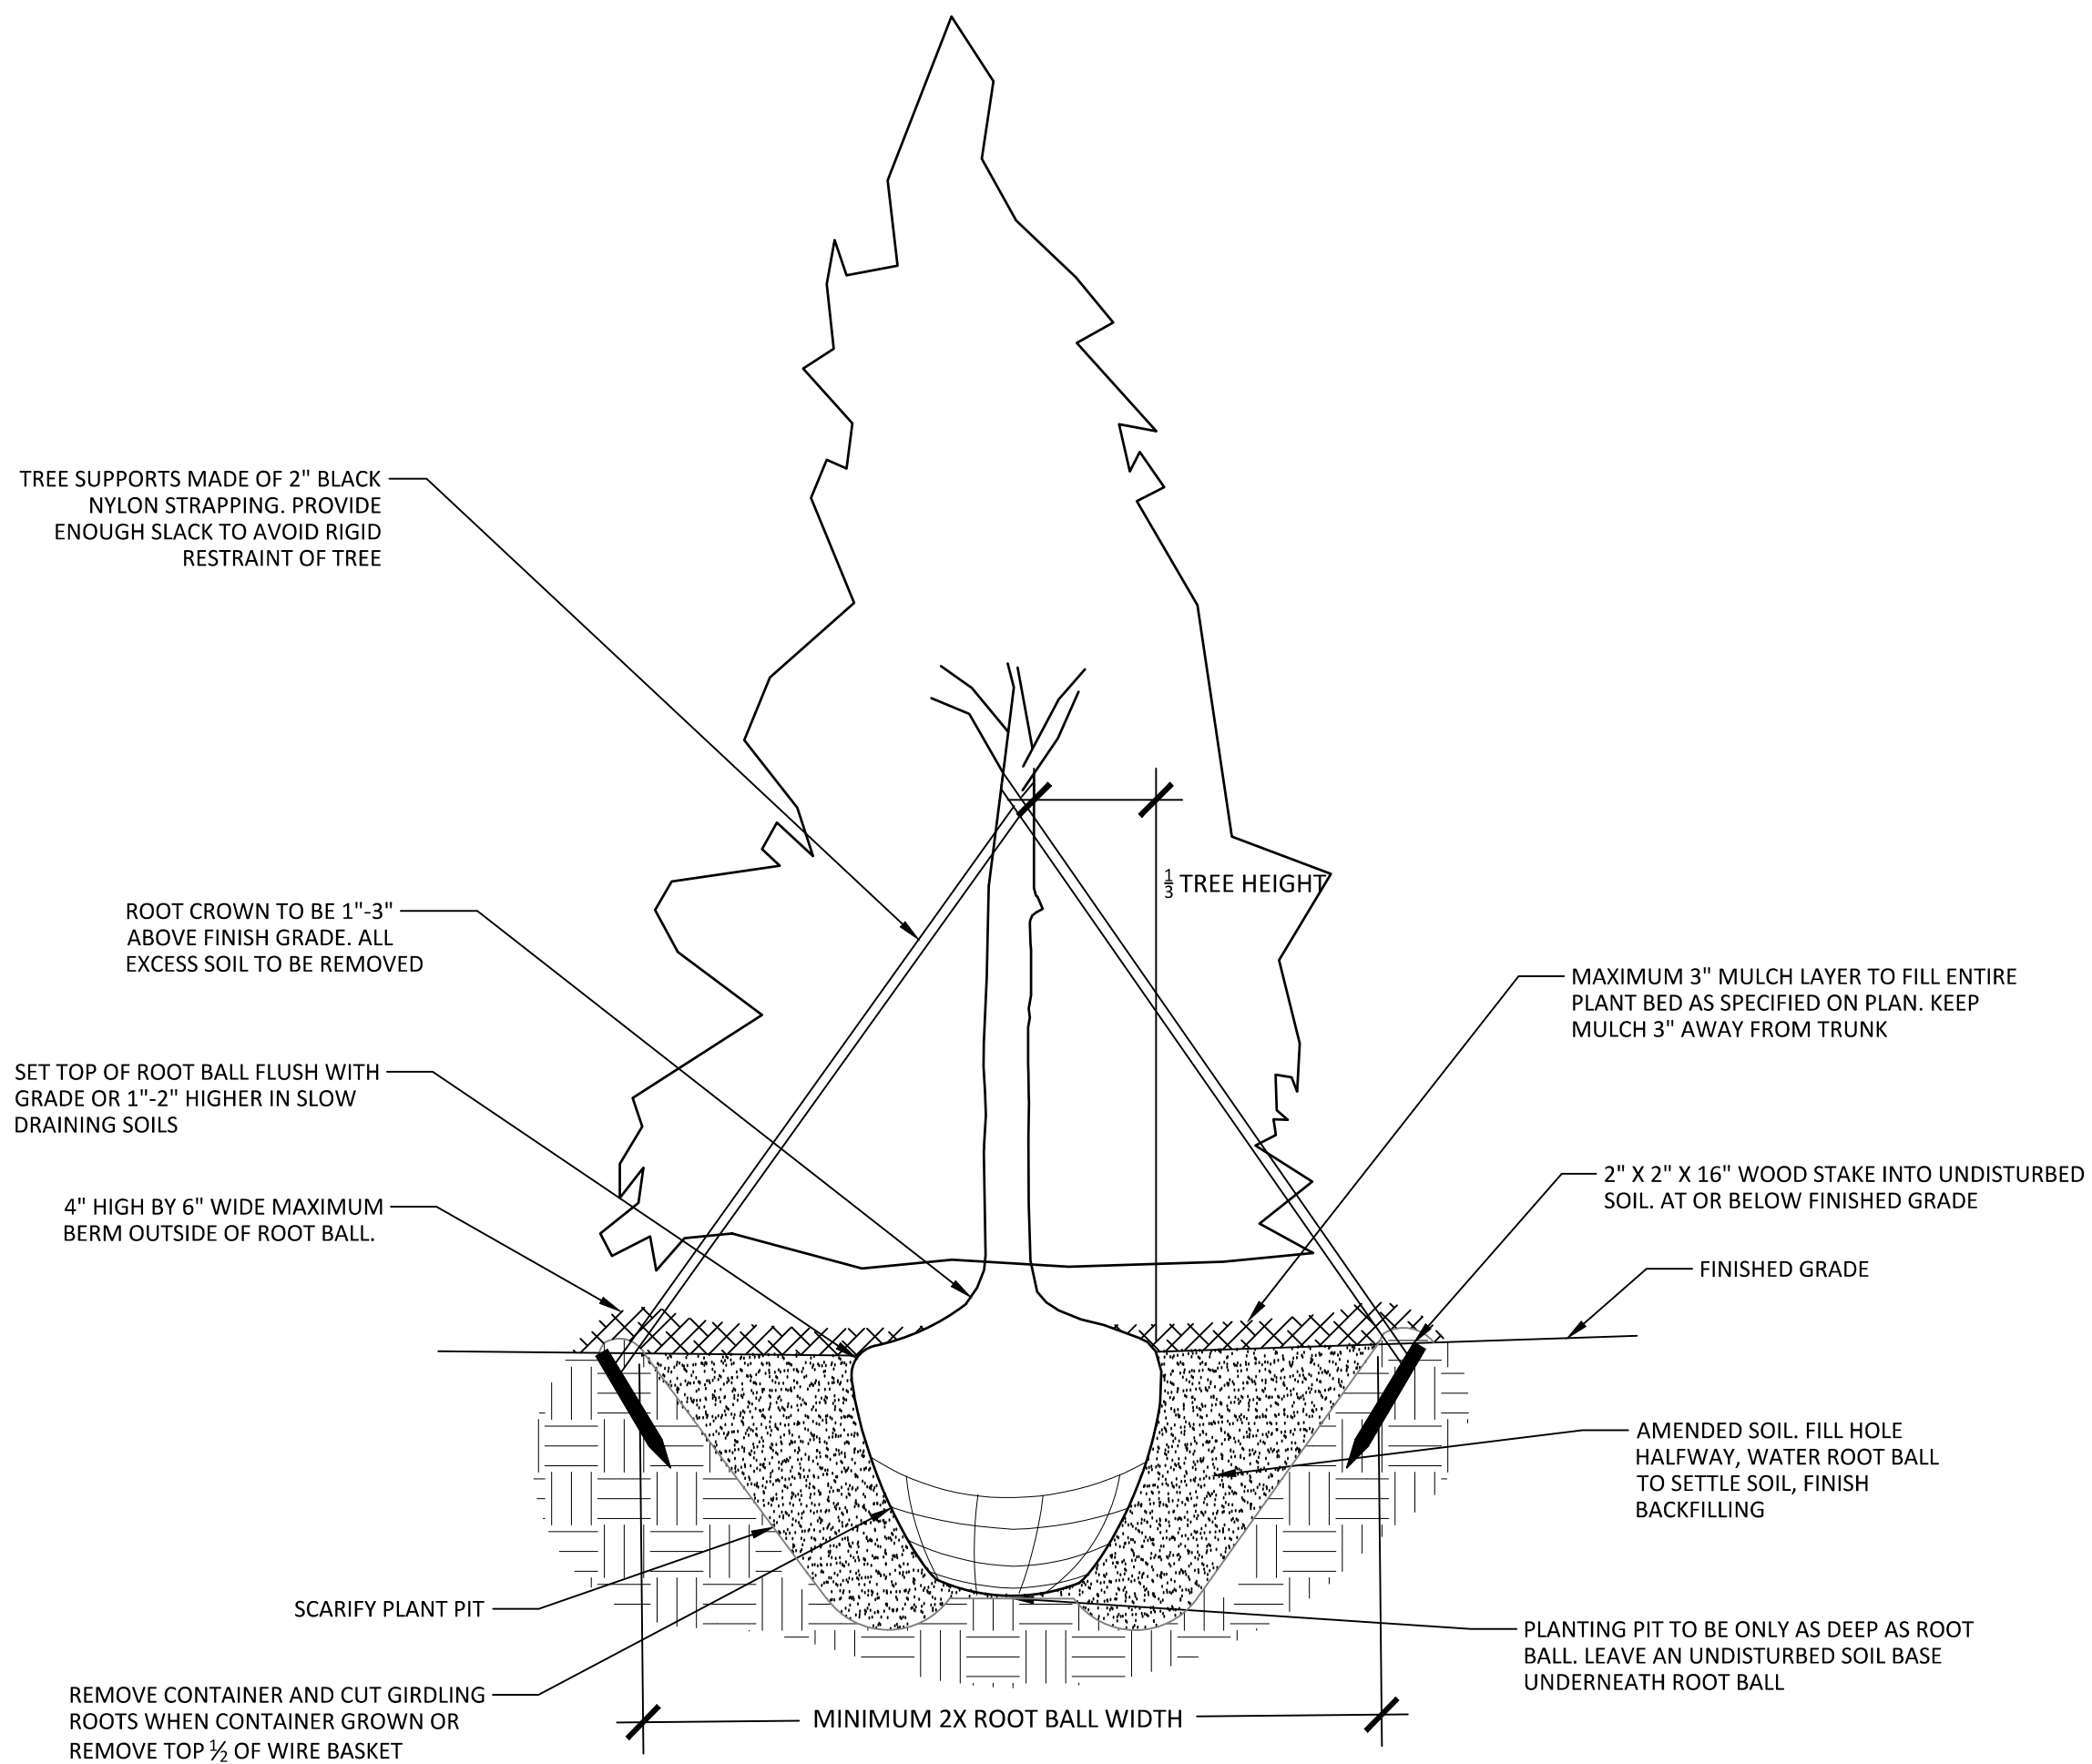

- NOTES
1. All trees shall meet American Standard for Nursery Stock (ANSI z60.1-2004)
 2. Remove wire and nylon twine from ball and canopy.
 3. Soak root ball and plant pit immediately after installation.
 4. Do not stake or wrap trunk unless:
 - a. Tree has a large crown.
 - b. Planting site is consistently windy or is a steep slope.
 - c. Planting site is susceptible to vandalism.
 6. Remove all staking material after 1 year.
 7. Remove all tags and labels from plant material.
 8. Do not heavily prune the tree at planting. Only prune crossover limbs, co-dominant leaders, and broken or dead branches. Do not remove the terminal buds of branches that extend to the edge of the crown. Some interior twigs and lateral branches may be pruned.

3 TYPICAL EVERGREEN TREE PLANTING

NOT TO SCALE

P-R-08




NO.	DATE	REVISION:	CID/SUBMITTAL #1
1	12/23/2024		

STIPULATION FOR REUSE
THIS DRAWING WAS PREPARED FOR USE ON THE SPECIFIC SITE, NAMED HEREON, CONTEMPORANEOUSLY WITH ITS ISSUE DATE AS LISTED, HEREON, AND IT IS NOT SUITABLE FOR USE ON A DIFFERENT PROJECT SITE OR AT A LATER TIME. USE OF THIS DRAWING FOR REFERENCE OR EXAMPLE ON ANOTHER PROJECT REQUIRES THE SERVICES OF PROPERLY LICENSED ARCHITECTS AND ENGINEERS. REPRODUCTION OF THIS DRAWING FOR REUSE ON ANOTHER PROJECT IS NOT AUTHORIZED AND MAY BE CONTRARY TO THE LAW.


KALAS FALLS
PHASE 5
CONSTRUCTION INFRASTRUCTURE
DOCUMENTS
CID-25-01
TOWN OF ROLESVILLE,
WAKE COUNTY, NC

JOB NUMBER: R180115
CHECKED BY: JK
DRAWN BY: GE, RC
DATE: 05-01-2025

SHEET TITLE:
**LANDSCAPE
DETAILS**
SHEET NO.:
LP500

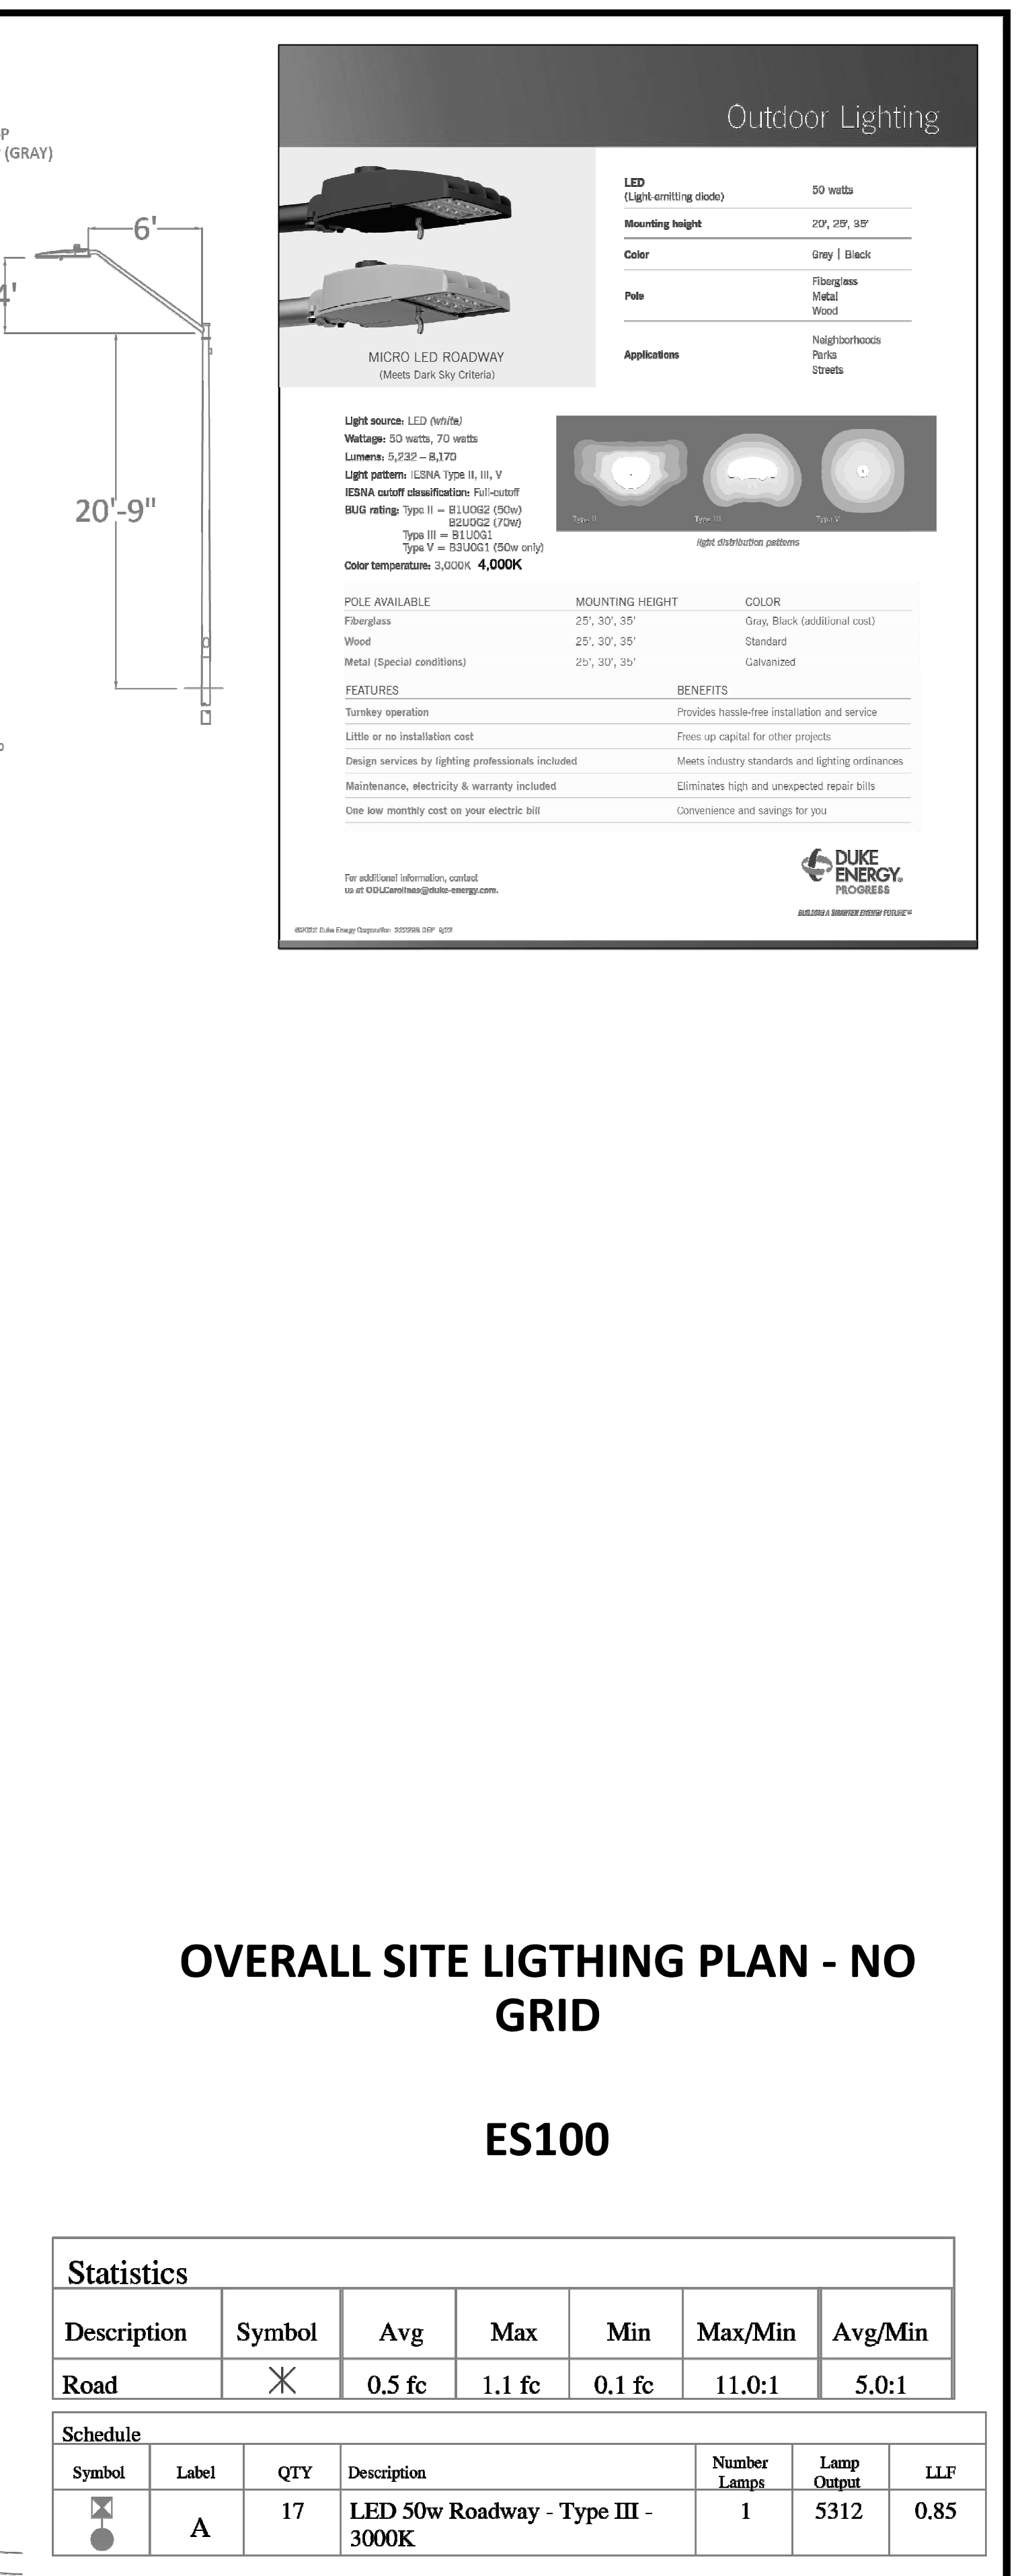

**DUKE
ENERGY®**
PROGRESS

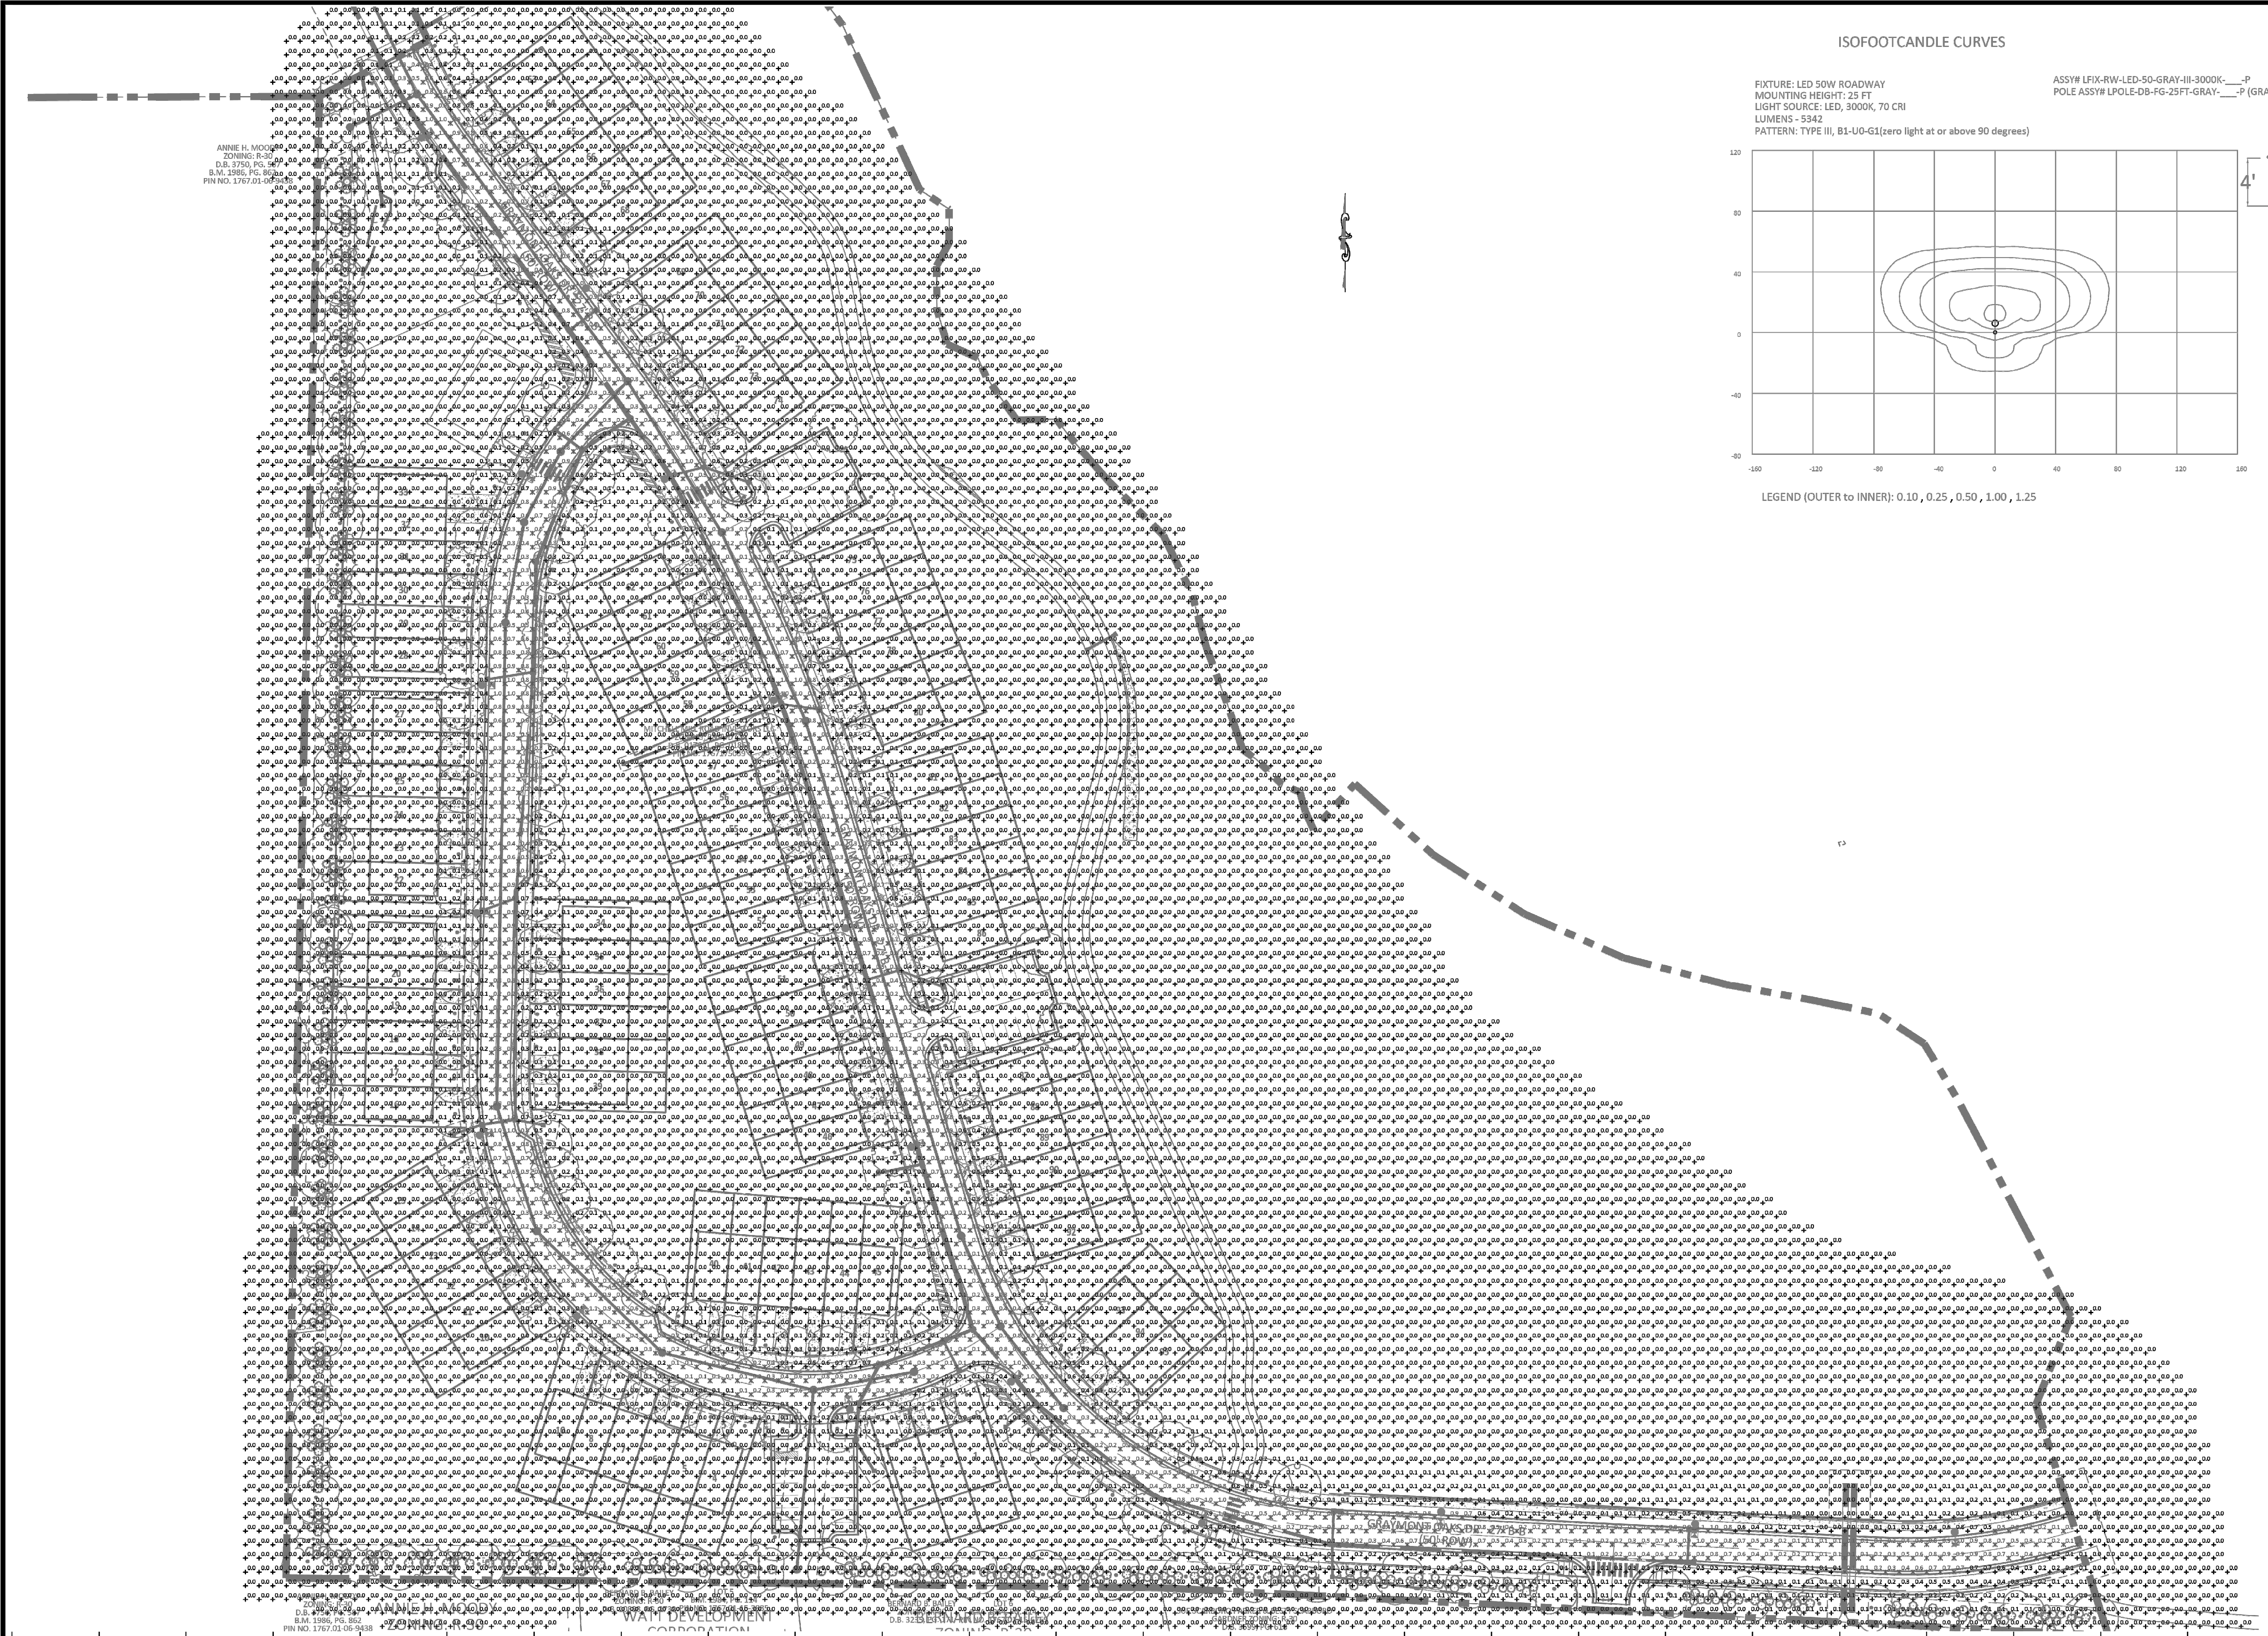

OVERALL SITE LIGHTING PLAN

ES101

Statistics					
Description	Symbol	Avg	Max	Min	Max/Min
Road	✕	0.5 fc	1.1 fc	0.1 fc	11.0:1
Schedule					
Symbol	Label	QTY	Description	Number Lamps	Lamp Output
✕	A	17	LED 50w Roadway - Type III - 3000K	1	5312

KALAS FALLS WAKE FOREST, NC

STREET LIGHTING ARRANGEMENT

Designed by **DUKE ENERGY PROGRESS LIGHTING SOLUTIONS**

Reviewed by **N. Johnson** Scale **1" = 60'**

Date **04/02/2025** Size **Drawing size "D"**


Description **LED ROADWAY**

Drawing No. **25-0123A**

Sht. **1 OF 1**

LIGHTING DESIGN TOLERANCE

The calculated footcandle light levels in this lighting design are predicted values and are based on specific information that has been supplied to Duke Energy. Any inaccuracies in the predicted information, differences in luminaire installation, lighted area geometry including elevation differences, reflective properties of surrounding surfaces, obstructions (foliage or otherwise) in the lighted area, or lighting from sources other than listed in this design may produce different results from the predicted values. Normal tolerances of voltage, lamp output, and ballast and luminaire manufacture will also affect results.

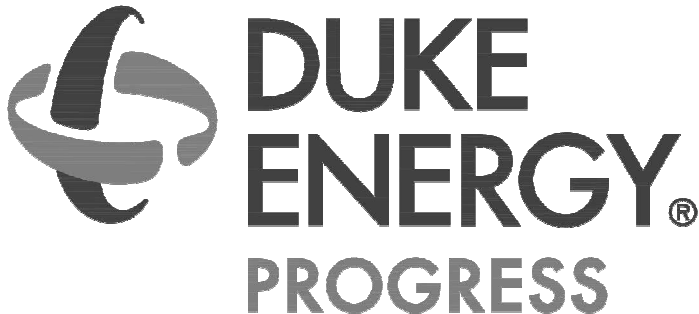

PROPRIETARY & CONFIDENTIAL

This document together with the concepts and designs presented herein, presented as an instrument of service, is the sole property of Duke Energy, and is intended only for the specific purpose and prospective client as stated in the title block of this drawing. Any use, copying, reproduction or disclosure of the drawing, design or any information contained herein by the prospective customer or other entities, including without limitation, architects, engineers, or equipment manufacturers is hereby expressly prohibited and shall not be permitted absent prior written consent from, and payment of compensation to Duke Energy. Duke Energy disclaims any liability or responsibility for any unauthorized use of or reliance on this document.