



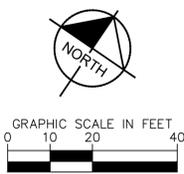

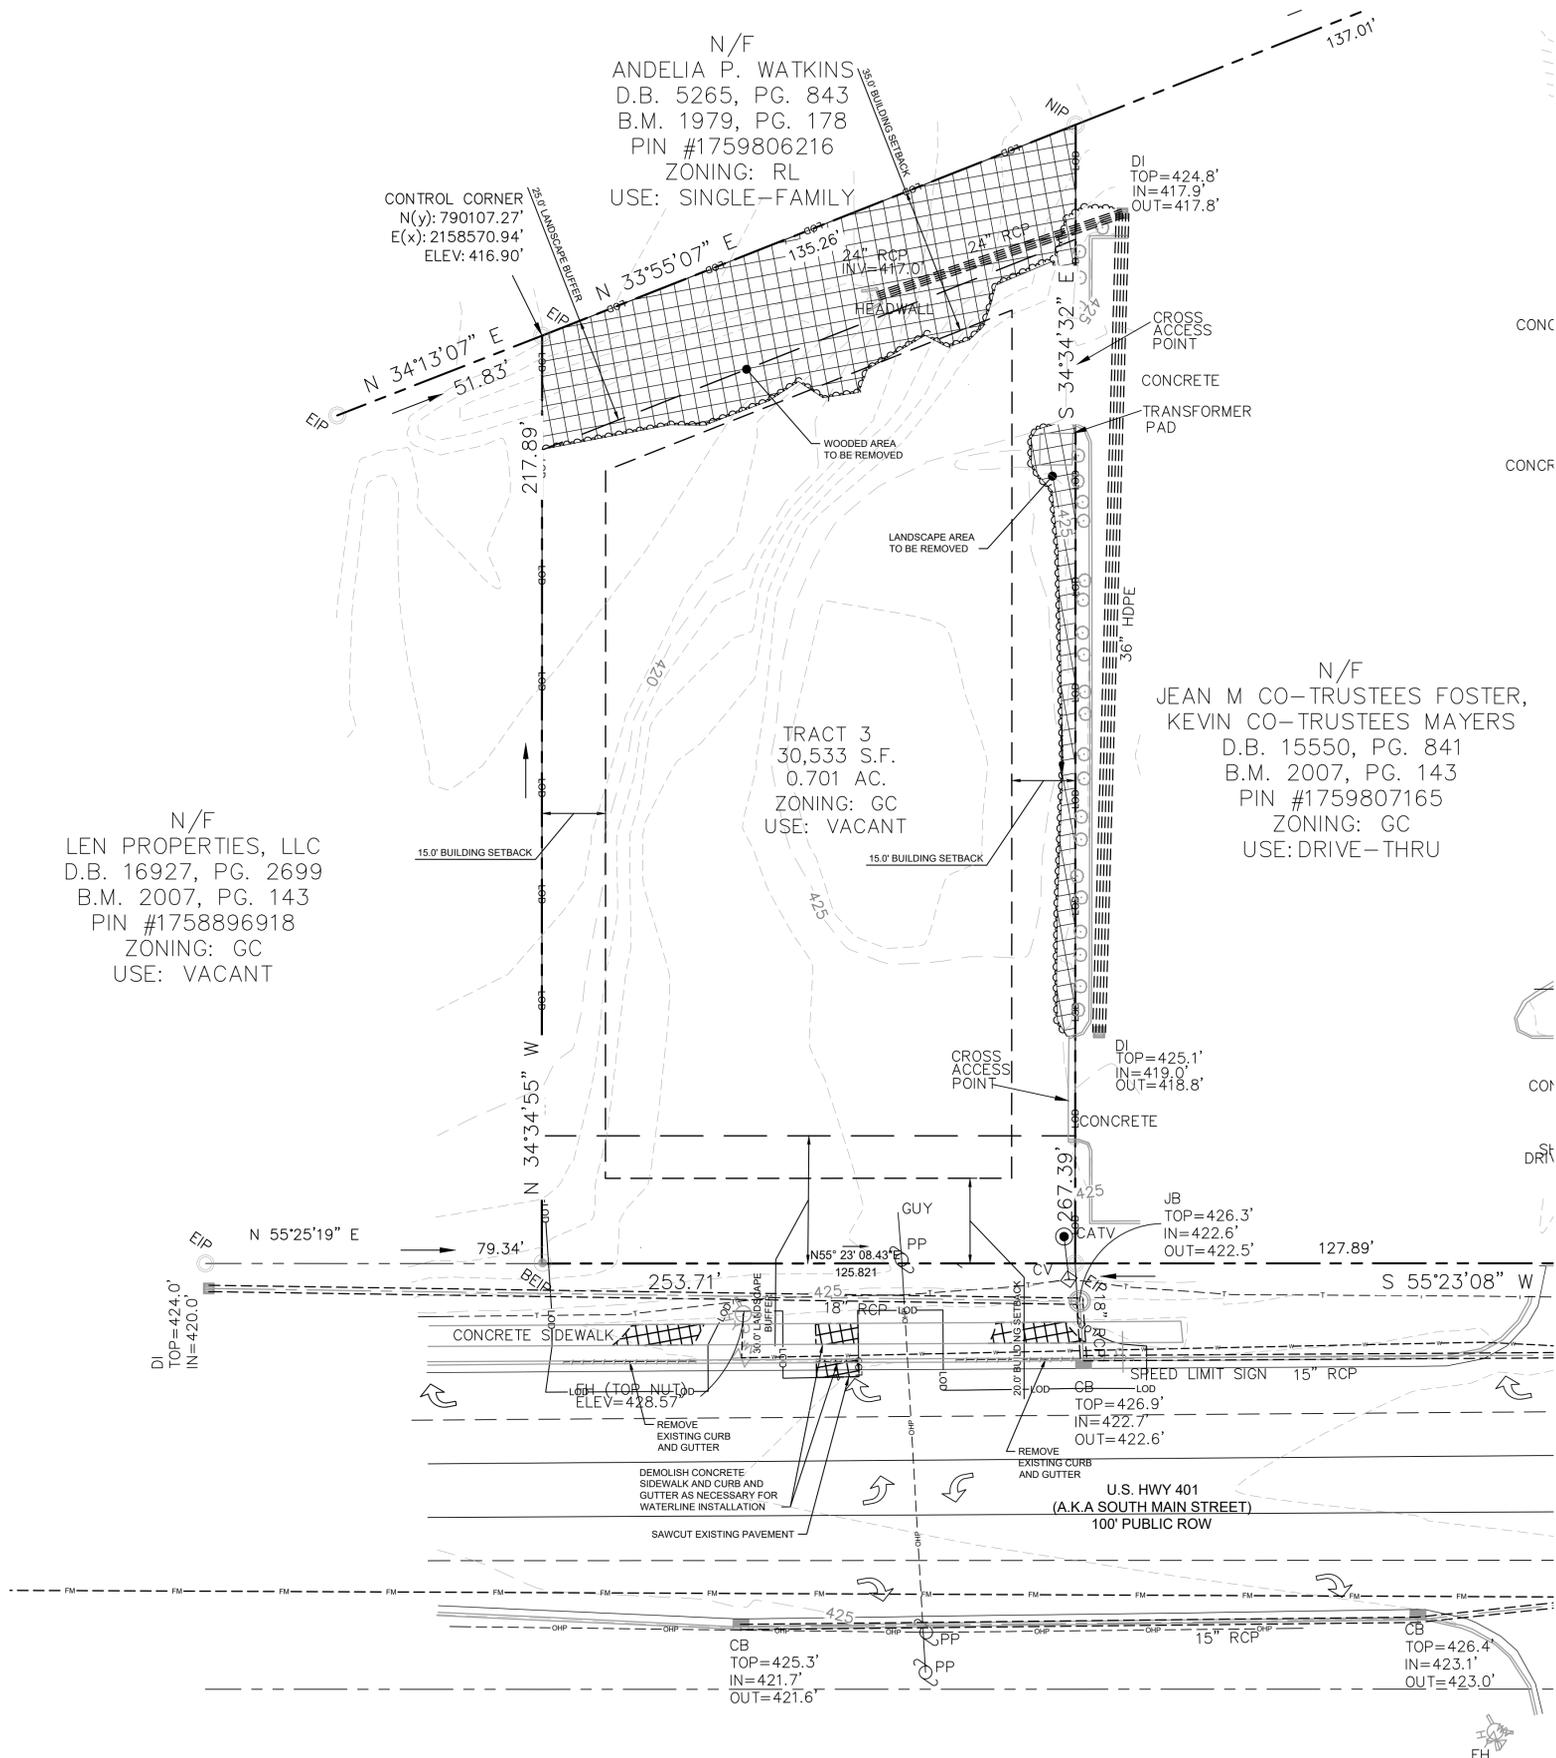

Plotted By: Barnes, Michael. Sheet Set: SCOOTER'S ROLESVILLE. Layout: C1.0 EXISTING CONDITIONS & DEMOLITION PLAN. January 02, 2024. 04:16:00pm. K:\RAL\_LDEV\016485000-Scoters\_Rolesville\Planning\P15\_CAD Files\PlanSheets\C1.0 EXISTING CONDITIONS & DEMOLITION PLAN.dwg. This document, together with the concepts and designs presented herein, is intended only for the specific purpose and client for which it was prepared. Reuse of and improper reliance on this document without written authorization and adaptation by Kimley-Horn and Associates, Inc. shall be without liability to Kimley-Horn and Associates, Inc.



DEMOLITION LEGEND	
	PROPERTY LINE
	LIMITS OF DISTURBANCE
	DEMOLISH SITE ITEM
	DEMOLISH UNDERGROUND UTILITY
	ABANDON UTILITY IN PLACE
	SAWCUT
	DEMOLISH SITE ITEM / TREE TO BE REMOVED
	BUILDINGS TO BE REMOVED
	SIDEWALK/PAVEMENT/GRAVEL TO BE REMOVED

NO.	REVISIONS	DATE	BY
1		01/02/2024	IMDE

**Kimley»Horn**  
 © 2023 KIMLEY-HORN AND ASSOCIATES, INC.  
 421 FAYETTEVILLE STREET, SUITE 800, RALEIGH, NC 27601  
 #F-0102 WWW.KIMLEY-HORN.COM PHONE: 919.677.2000 FAX: 919.677.2050



KHA PROJECT	DATE	SCALE	DESIGNED BY	DRAWN BY	CHECKED BY
016485000	10/31/2023	AS SHOWN	JAA	JAA	COB

**EXISTING CONDITIONS & DEMOLITION PLAN**

**SCOOTER'S ROLESVILLE**  
 PREPARED FOR  
**S&S JAVA ENTERPRISES**  
 ROLESVILLE, NC


SHEET NUMBER  
**C1.0**

**SURVEY NOTE:**  
 EXISTING TOPOGRAPHICAL INFORMATION IS BASED ON A TOPOGRAPHIC SURVEY OBTAINED ON 02/23/2023 BY CMP PROFESSIONAL LAND SURVEYORS, 333 S. WHITE STREET, WAKE FOREST, NC 27588. PHONE: (919) 556-3148. CONTRACTOR SHALL BE RESPONSIBLE FOR VERIFYING ALL EXISTING INFORMATION, DEPICTED OR NOT, PRIOR TO CONSTRUCTION AND REPORT POTENTIAL CONFLICTS TO OWNER AND ENGINEER.





Plotted By: Barnes, Michael. Sheet Set: SCOOTER'S ROLESVILLE. Layout: C3.0 GRADING AND DRAINAGE PLAN. January 02, 2024. 04:16:20pm. K:\RAL\_LDEV\016485000-Scoters Rolesville\Planning\P15\_CAD Files\PlanSheets\C3.0 GRADING AND DRAINAGE PLAN.dwg. This document, together with the concepts and designs presented herein, is intended only for the specific purpose and client for which it was prepared. Reuse of and improper reliance on this document without written authorization and adaptation by Kimley-Horn and Associates, Inc. shall be without liability to Kimley-Horn and Associates, Inc.

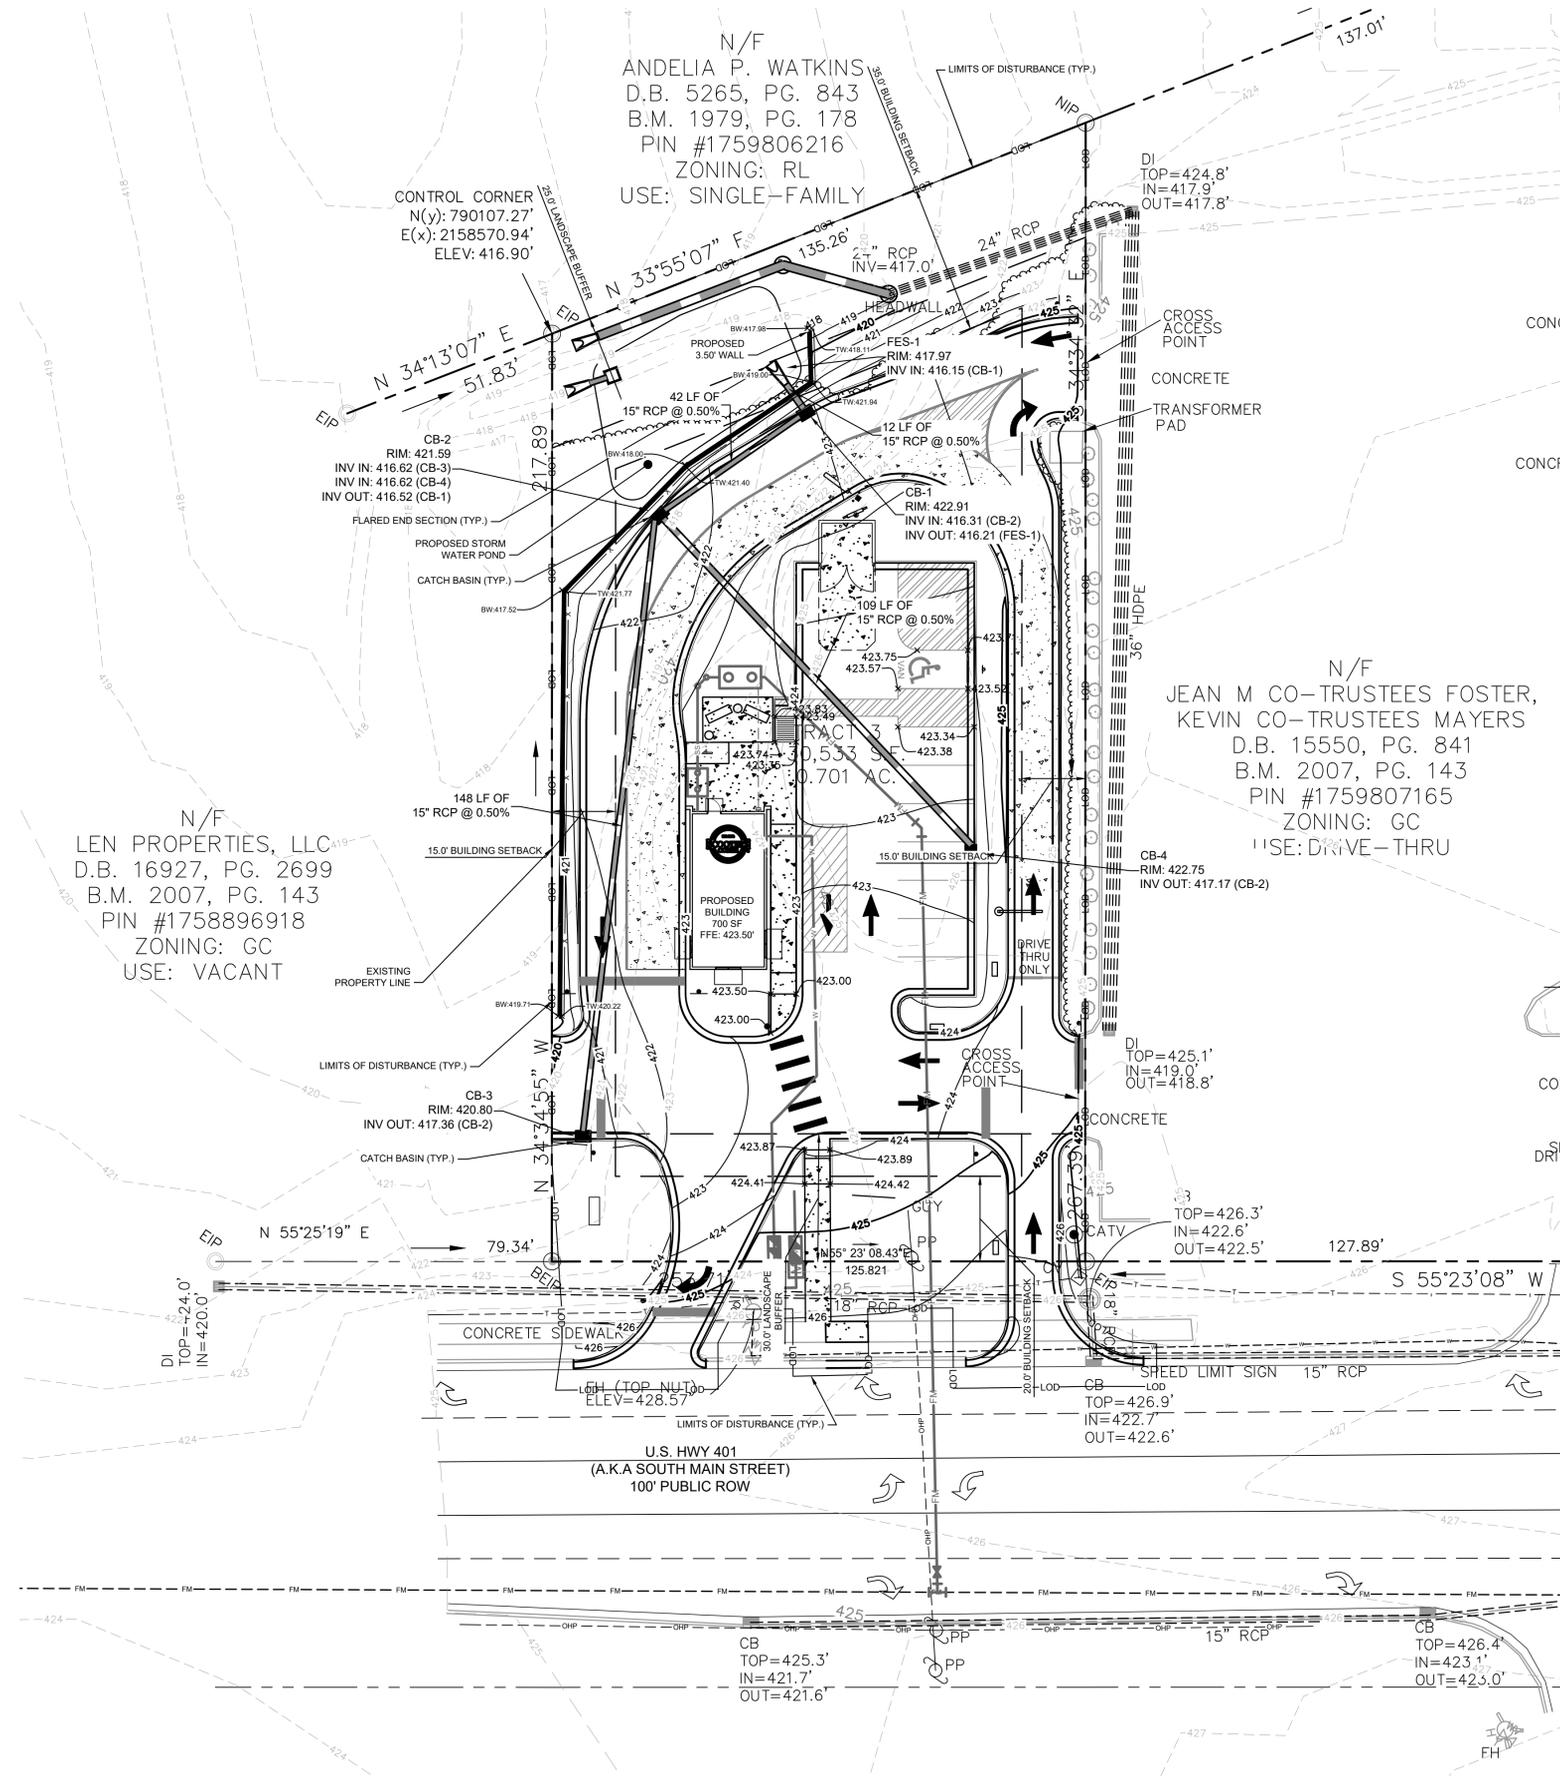

GRADING AND DRAINAGE LEGEND	
	PROPERTY LINE
	TEMPORARY CONSTRUCTION EASEMENT
	STORM DRAIN (≥ 12 INCH)
	STORM DRAIN (< 12 INCH)
	ROOF DRAIN
	UNDER DRAIN
	CURB AND GUTTER
	SPILL CURB AND GUTTER
	CLEARING LIMITS
	EXISTING CONTOUR
	PROPOSED CONTOUR
	SPOT ELEVATION
	CATCH BASIN (CB)
	MANHOLE (SDMH)
	CLEANOUT (SDCO)
	DROP INLET (DI)
	AREA DRAIN (AD)
	CONTROL STRUCTURE (CS)
	FLARED END SECTION (FES)
	CONCRETE HEADWALL (HW)
	RIP-RAP APRON
	FLOW ARROW
	TW TOP OF WALL (GRADE ELEV.)
	BW BOTTOM OF WALL (GRADE ELEV.)
	TP TOP OF PAVEMENT (GRADE ELEV.)
	TC TOP OF CURB (GRADE ELEV.)
	TC/TP FLUSH CURB (GRADE ELEV.)
	WT WATER TIGHT JOINTS (WT)


**SURVEY NOTE:**  
 EXISTING TOPOGRAPHICAL INFORMATION IS BASED ON A TOPOGRAPHIC SURVEY OBTAINED ON 02/23/2023 BY CMP PROFESSIONAL LAND SURVEYORS, 333 S. WHITE STREET, WAKE FOREST, NC. 27588. PHONE: (919) 556-3148. CONTRACTOR SHALL BE RESPONSIBLE FOR VERIFYING ALL EXISTING INFORMATION, DEPICTED OR NOT, PRIOR TO CONSTRUCTION AND REPORT POTENTIAL CONFLICTS TO OWNER AND ENGINEER.




 © 2023 KIMLEY-HORN AND ASSOCIATES, INC. #F-0102 WWW.KIMLEY-HORN.COM PHONE: 919.677.2000 FAX: 919.677.2050 421 FAYETTEVILLE STREET, SUITE 800, RALEIGH, NC 27601	NORTH CAROLINA PRELIMINARY NOT FOR CONSTRUCTION SHEET NO. C3.0	KHA PROJECT 016485000 DATE 10/31/2023 SCALE AS SHOWN DESIGNED BY JAA DRAWN BY JAA CHECKED BY COB	GRADING AND DRAINAGE PLAN	SCOOTER'S ROLESVILLE PREPARED FOR S&S JAVA ENTERPRISES ROLESVILLE, NC	SHEET NUMBER <b>C3.0</b>	TOWN COMMENTS REVISIONS No.	DATE 01/02/2024	BY													
	<table border="1"> <tr> <td>7</td> <td></td> </tr> <tr> <td>6</td> <td></td> </tr> <tr> <td>5</td> <td></td> </tr> <tr> <td>4</td> <td></td> </tr> <tr> <td>3</td> <td></td> </tr> <tr> <td>2</td> <td></td> </tr> <tr> <td>1</td> <td></td> </tr> </table>		7		6		5		4		3		2		1						
7																					
6																					
5																					
4																					
3																					
2																					
1																					



Plotted By: Barnes, Michael. Sheet Set: SCOOTER'S ROLESVILLE Layout: C4.1. MECHANICAL PLAN. January 02, 2024. 04:16:27pm. K:\RAL\_LDEV\016485000-Scoters Rolesville\Planning\P15\_CAD Files\Plan Sheets\C4.1\_MECHANICAL PLAN.dwg  
 This document, together with the concepts and designs presented herein, is an instrument of service, as intended only for the specific purpose and client for which it was prepared. Reuse of and improper reliance on this document without written authorization and adaptation by Kimley-Horn and Associates, Inc. shall be without liability to Kimley-Horn and Associates, Inc.

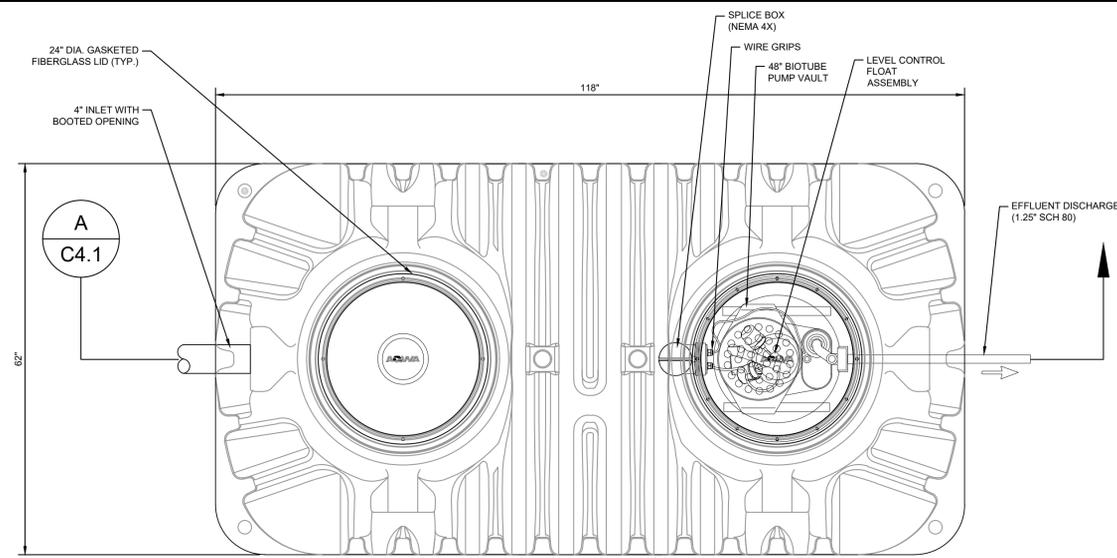

**1** MECHANICAL PLAN VIEW  
SCALE: NTS

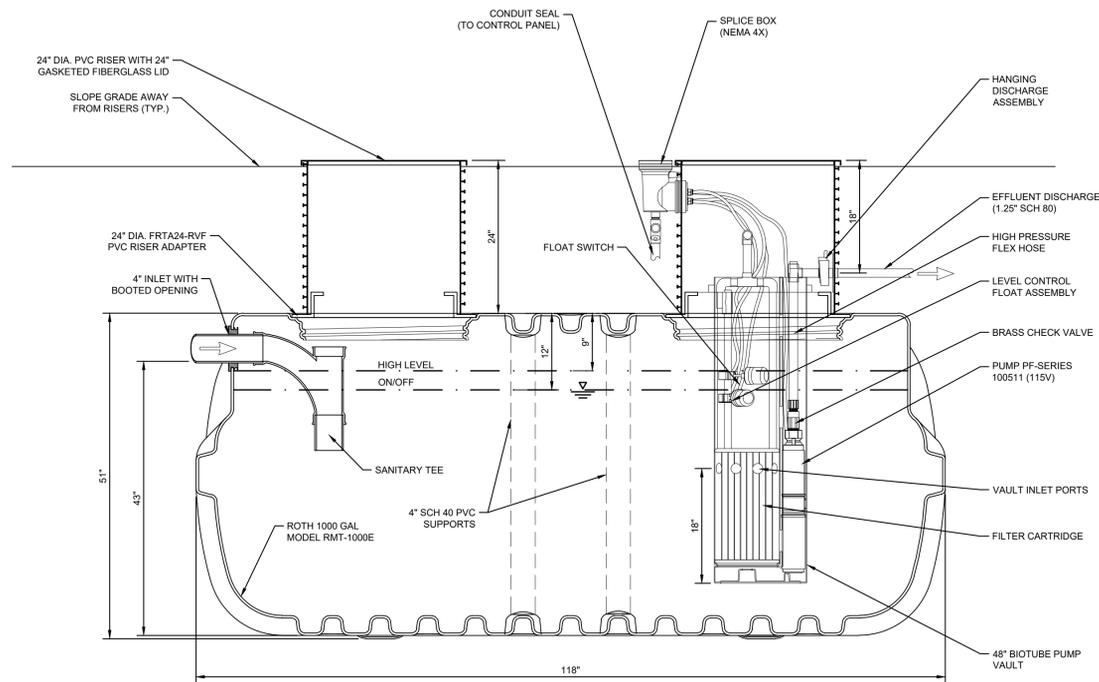


**A** MECHANICAL SECTION VIEW  
SCALE: NTS

NOTES:  
 1) PROPOSED STEP SYSTEM SHALL BE EQUIPPED WITH AN "ORENCO S1" CONTROL PANEL OR APPROVED EQUAL. CONTACT MICHAEL CLAYTON (MCLAYTON@AQWA.NET, 252-292-1667) FOR STEP SYSTEM SPECIFICATIONS.

SEPTIC TANK GENERAL INFORMATION	
AVERAGE DAILY FLOW	306 GPD
TANK	1000 GAL ROTH TANK
TANK DIMENSIONS	118"x62"x52"
DISCHARGE PIPING	1.25"Ø SCH 80 PVC
CONTROL PANEL	ORENCO S1
HORSEPOWER	1 HP (NON-OVERLOADING OVER ENTIRE PUMP CURVE)
VOLTAGE/PHASE/CYCLES	240 V / 1 PHASE / 60 HZ
PUMP	ORENCO PF100511
PRIMARY LEVEL SENSING METHOD	FLOATS (3)
FLOAT SETTINGS	9", 12" (FROM TOP OF TANK)
FLOAT FUNCTIONS	HIGH LEVEL, ON/OFF

**Pump Curves**

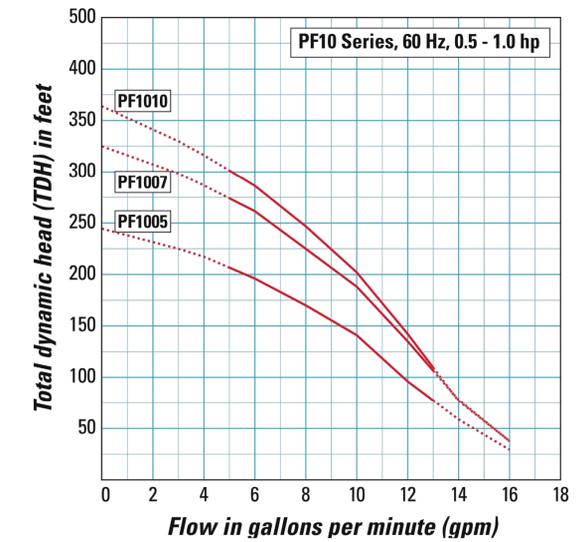

**SURVEY NOTE:**  
 EXISTING TOPOGRAPHICAL INFORMATION IS BASED ON A TOPOGRAPHIC SURVEY OBTAINED ON 02/23/2023 BY CMP PROFESSIONAL LAND SURVEYORS, 333 S. WHITE STREET, WAKE FOREST, NC, 27588. PHONE: (919) 556-3148. CONTRACTOR SHALL BE RESPONSIBLE FOR VERIFYING ALL EXISTING INFORMATION, DEPICTED OR NOT, PRIOR TO CONSTRUCTION AND REPORT POTENTIAL CONFLICTS TO OWNER AND ENGINEER.



SDP-23-07

No.	REVISIONS	BY	DATE

**Kimley»Horn**  
 © 2023 KIMLEY-HORN AND ASSOCIATES, INC.  
 #F-0102 WWW.KIMLEY-HORN.COM PHONE: 919-677-2000 FAX: 919-677-2050  
 421 FAYETTEVILLE STREET, SUITE 600, RALEIGH, NC 27601




KHA PROJECT	016485000
DATE	10/31/2023
SCALE	AS SHOWN
DESIGNED BY	JAA
DRAWN BY	JAA
CHECKED BY	COB

**MECHANICAL PLAN**

**SCOOTER'S ROLESVILLE**  
 PREPARED FOR  
**S&S JAVA ENTERPRISES**  
 ROLESVILLE, NC


SHEET NUMBER  
**C4.1**

Plotted By: Barnes, Michael. Sheet Set: SCOOTER'S ROLESVILLE. Layout: C4.2 SEPTIC TANK DETAILS. January 02, 2024. 04:18:47pm. K:\BAL\_LDEV\016485000-Scooters Rolesville\Planning\P15\_CAD Files\PlanSheets\C4.2 SEPTIC TANK DETAILS.dwg. This document, together with the concepts and designs presented herein, is an instrument of service, is intended only for the specific purpose and client for which it was prepared. Reuse of and improper reliance on this document without written authorization and adaptation by Kimley-Horn and Associates, Inc. shall be without liability to Kimley-Horn and Associates, Inc.

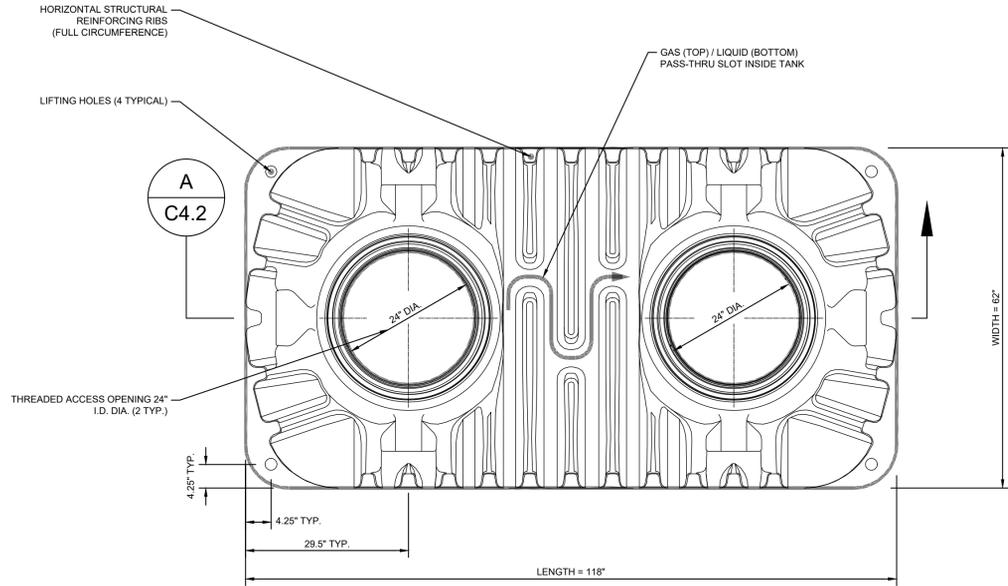


1 SEPTIC TANK PLAN VIEW

SCALE: NTS

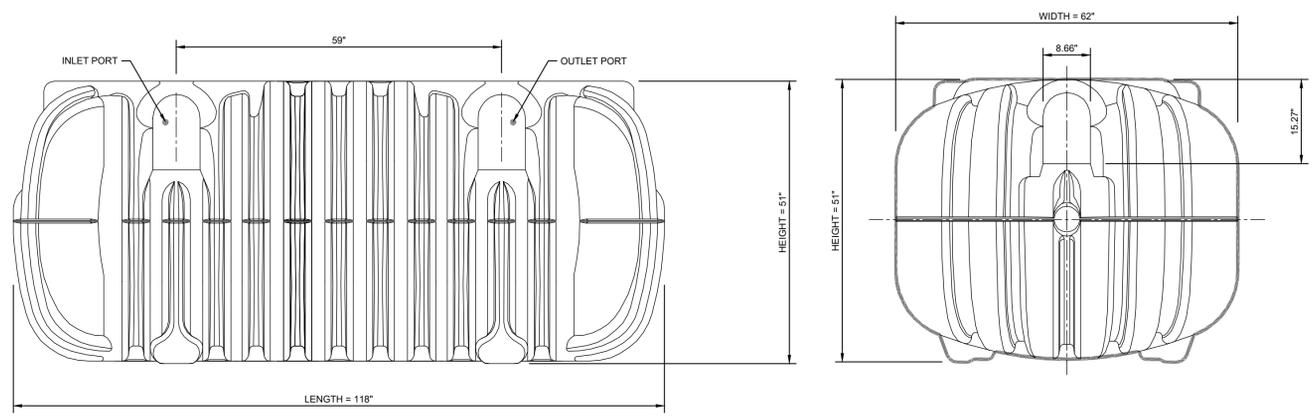

2 SEPTIC TANK ELEVATION VIEW

SCALE: NTS

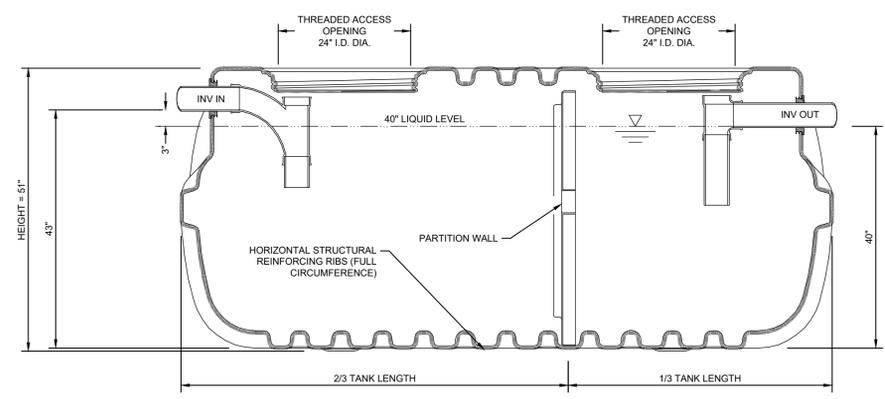

A SEPTIC TANK SECTION VIEW

SCALE: NTS

**SURVEY NOTE:**  
 EXISTING TOPOGRAPHICAL INFORMATION IS BASED ON A TOPOGRAPHIC SURVEY OBTAINED ON 02/23/2023 BY CMP PROFESSIONAL LAND SURVEYORS, 333 S. WHITE STREET, WAKE FOREST, NC, 27588. PHONE: (919) 556-3148. CONTRACTOR SHALL BE RESPONSIBLE FOR VERIFYING ALL EXISTING INFORMATION, DEPICTED OR NOT, PRIOR TO CONSTRUCTION AND REPORT POTENTIAL CONFLICTS TO OWNER AND ENGINEER.



SDP-23-07

<b>Kimley»Horn</b> <small>© 2023 KIMLEY-HORN AND ASSOCIATES, INC.          #F-0102 WWW.KIMLEY-HORN.COM PHONE: 919.677.2000 FAX: 919.677.2050          421 FAYETTEVILLE STREET, SUITE 600, RALEIGH, NC 27601</small>	No. _____ REVISIONS DATE BY
	No. _____ REVISIONS DATE BY
KHA PROJECT 016485000 DATE 10/31/2023 SCALE AS SHOWN DESIGNED BY JAA DRAWN BY JAA CHECKED BY COB	NORTH CAROLINA PRELIMINARY NOT FOR CONSTRUCTION SHEPHERD 02/23/2023
<b>SCOOTER'S ROLESVILLE</b> PREPARED FOR <b>S&amp;S JAVA ENTERPRISES</b> ROLESVILLE NC	<b>SEPTIC TANK DETAILS</b>
SHEET NUMBER <b>C4.2</b>	NC



**SELF MONITORING AND INSPECTION NOTIFICATION**

THE SEDIMENTATION POLLUTION CONTROL ACT WAS AMENDED IN 2006 TO REQUIRE THAT PERSONS RESPONSIBLE FOR LAND-DISTURBING ACTIVITIES INSPECT A PROJECT AFTER EACH PHASE OF THE PROJECT TO MAKE SURE THAT THE APPROVED EROSION AND SEDIMENTATION CONTROL PLAN IS BEING FOLLOWED. RULES DETAILING THE DOCUMENTATION OF THESE INSPECTIONS BECAME EFFECTIVE OCTOBER 1, 2010. TO SIMPLIFY DOCUMENTATION OF SELF-INSPECTION REPORTS AND NPDES SELF-MONITORING REPORTS, A COMBINED FORM IS NOW AVAILABLE. THE NEW FORM WAS DEVELOPED TO SATISFY THE REQUIREMENTS OF THE SEDIMENTATION POLLUTION CONTROL ACT AND THE NPDES STORMWATER PERMIT FOR CONSTRUCTION ACTIVITIES, NCGS 01000, BEGINNING AUGUST 1, 2013. THE DIVISION OF ENERGY, MINERAL, AND LAND RESOURCES IS RESPONSIBLE FOR ADMINISTERING BOTH THE SPCA AND THE NPDES STORMWATER PERMIT FOR CONSTRUCTION ACTIVITIES, NCGS 01000. THE COMBINED FORM SHOULD MAKE IT EASIER TO COMPLY WITH SELF-INSPECTION REQUIREMENTS. THE COMBINED SELF-MONITORING FORM IS AVAILABLE AS A PDF AND WORD DOCUMENT FROM THE LAND QUALITY WEB SITE, [HTTP://PORTAL.NC DENR.ORG/WEB/EROC/EROCSELFMON](http://portal.ncdenr.org/web/eroc/erocselfmon) IF YOU HAVE QUESTIONS, PLEASE CONTACT THE LAND QUALITY SECTION AT NCDEQ REGIONAL OFFICE.

**MAINTENANCE NOTES:**

DURING THE DEVELOPMENT OF A SITE, THE DEVELOPER SHALL INSTALL AND MAINTAIN ALL TEMPORARY AND PERMANENT STORMWATER CONTROL MEASURES AS REQUIRED BY THE APPROVED PLAN OR ANY PROVISION OF THIS ARTICLE. THE ACT OR ANY ORDER ADOPTED PURSUANT TO THIS ARTICLE OR THE ACT AFTER SITE DEVELOPMENT, THE DEVELOPER SHALL INSTALL AND/OR MAINTAIN ALL NECESSARY PERMANENT STORMWATER CONTROL MEASURES SPECIFIED IN THE APPROVED PLAN, EXCEPT THOSE MEASURES INSTALLED WITHIN A ROAD OR STREET RIGHT-OF-WAY OR EASEMENT ACCEPTED FOR MAINTENANCE BY A GOVERNMENTAL AGENCY. CONVEYANCE OF THE PROPERTY SHALL NOT TERMINATE THE ORIGINAL DEVELOPER'S OBLIGATIONS UNDER THIS ARTICLE UNTIL SUCH TIME AS A REPLACEMENT PERMIT IS APPROVED BY THE COUNTY ENGINEER, OR DESIGNEE. THE ORIGINAL DEVELOPER SHALL INCLUDE IN THE DEED CONVEYING THE PROPERTY NOTICE OF THE EXISTENCE OF THE STORMWATER CONTROL MEASURES AND THE PURCHASER'S OBLIGATIONS TO MAINTAIN AND INSPECT THEM AND TO OBTAIN A PERMIT AND OTHERWISE COMPLY WITH THE TERMS OF THIS ARTICLE. REFER TO THE EROSION CONTROL DETAILS SHEET FOR ADDITIONAL MAINTENANCE NOTES. THE FOLLOWING ITEMS WILL BE CHECKED IN PARTICULAR:

- CONSTRUCTION ENTRANCE:**  
INSPECT CONSTRUCTION ROADS AND PARKING AREAS PERIODICALLY FOR CONDITION OF SURFACE. TOP DRESS WITH NEW GRAVEL AS NEEDED. CHECK ROAD DITCHES AND OTHER SEEDED AREAS FOR EROSION AND SEDIMENTATION AFTER RUNOFF-PRODUCING RAINS. MAINTAIN ALL VEGETATION IN A HEALTHY, VIGOROUS CONDITION. SEDIMENT PRODUCING AREAS SHOULD BE TREATED IMMEDIATELY.
- SILT FENCE:**  
INSPECT SEDIMENT FENCES AT LEAST ONCE A WEEK AND AFTER EACH RAINFALL. MAKE ANY REQUIRED REPAIRS IMMEDIATELY. SHOULD THE FABRIC OF A SEDIMENT FENCE COLLAPSE, TEAR, DECOMPOSE, OR BECOME INEFFECTIVE, REPLACE IT IMMEDIATELY. REMOVE SEDIMENT DEPOSITS AS NECESSARY TO PROVIDE ADEQUATE STORAGE VOLUME FOR THE NEXT RAIN AND TO REDUCE PRESSURE ON THE FENCE. TAKE CARE TO AVOID UNDERMINING THE FENCE DURING CLEANOUT. REMOVE ALL FENCING MATERIALS AND UNSTABLE SEDIMENT DEPOSITS AND BRING THE AREA TO GRADE AND STABILIZE IT AFTER THE CONTRIBUTING DRAINAGE AREA HAS BEEN PROPERLY STABILIZED.
- SILT FENCE GRAVEL OUTLET:**  
INSPECT SEDIMENT FENCE GRAVEL OUTLETS AT LEAST ONCE A WEEK AND AFTER EACH RAINFALL. MAKE ANY REQUIRED REPAIRS IMMEDIATELY. REMOVE SEDIMENT DEPOSITS AS NECESSARY TO PROVIDE ADEQUATE STORAGE VOLUME FOR THE NEXT RAIN. ANY RIP RAP DISPLACED MUST BE REPLACED IMMEDIATELY.
- BLOCK AND GRAVEL INLET PROTECTION:**  
INSPECT THE BARRIER OF AFTER EACH RAIN AND MAKE REPAIRS AS NEEDED. REMOVE SEDIMENT AS NECESSARY TO PROVIDE ADEQUATE STORAGE VOLUME FOR SUBSEQUENT RAINS. WHEN THE CONTRIBUTING DRAINAGE AREA HAS BEEN ADEQUATELY STABILIZED, REMOVE ALL MATERIALS AND ANY UNSTABLE SOIL, AND EITHER SALVAGE OR DISPOSE OF IT PROPERLY. BRING THE DISTURBED AREA TO PROPER GRADE, THEN SMOOTH AND COMPACT IT. APPROPRIATELY STABILIZE ALL BARE AREAS AROUND THE INLET.

N/F  
ANDELIA P. WATKINS  
D.B. 5265, PG. 843  
B.M. 1979, PG. 178  
PIN #1759806216  
ZONING: RL  
USE: SINGLE-FAMILY

N/F  
LEN PROPERTIES, LLC  
D.B. 16927, PG. 2699  
B.M. 2007, PG. 143  
PIN #1758896918  
ZONING: GC  
USE: VACANT

N/F  
JEAN M CO-TRUSTEES FOSTER,  
KEVIN CO-TRUSTEES MAYERS  
D.B. 15550, PG. 841  
B.M. 2007, PG. 143  
PIN #1759807165  
ZONING: GC  
USE: DRIVE-THRU

**NPDES GROUND COVER REQUIREMENTS**

SITE AREA DESCRIPTION	STABILIZATION	TIME FRAME EXCEPTIONS
PERIMETER DIKES, SWALES, DITCHES, SLOPES	7 DAYS	NONE
HIGH QUALITY WATER (HQW) ZONES	7 DAYS	NONE
SLOPES STEEPER THAN 3:1	7 DAYS	IF SLOPES ARE 10' OR LESS IN LENGTH AND ARE NOT STEEPER THAN 2:1, 14 DAYS ARE ALLOWED.
SLOPES 3:1 OR FLATTER	14 DAYS	7 DAYS FOR SLOPES GREATER THAN 50' IN LENGTH
ALL OTHER AREAS WITH SLOPES FLATTER THAN 4:1	14 DAYS	NONE EXCEPT FOR PERIMETERS AND HQW ZONES.

SILT FENCES SHOWN ON PLANS ARE FOR REPRESENTATIVE PURPOSES. CONSTRUCT DIRECTLY ALONG THE CLEARING LIMITS WHERE APPLICABLE.

SILT FENCE OUTLETS ARE TO BE PROVIDED ALONG ALL LOW POINTS OF SILT FENCE AND AREAS WHERE RUNOFF MAY CONCENTRATE CAUSING DAMAGE TO SILT FENCE. CONTRACTOR TO INSTALL OUTLETS AS NECESSARY TO ENSURE SILT FENCE IS FULLY FUNCTIONAL THROUGHOUT THE DURATION OF CONSTRUCTION.

REFER TO GENERAL NOTES SHEET C0.1 FOR EROSION CONTROL, SEEDBED PREPARATION, AND SEEDING SCHEDULE NOTES FOR BOTH PHASES.

DISTURBED AREA: 0.77 AC

**EROSION CONTROL LEGEND**



PROPERTY LINE  
 TCE TEMPORARY CONSTRUCTION EASEMENT  
 CL CLEARING LIMITS  
 SF SILT FENCE  
 TPF TREE PROTECTION FENCE  
 SF/TPF COMBINATION TREE PROTECTION/SILT FENCE  
 TD TEMPORARY DIVERSION DITCH  
 TD(CW) CLEAN WATER DIVERSION DITCH  
 X SEDIMENT BASIN POROUS Baffles  
 PUMP DISCHARGE HOSE  
 805 EXISTING CONTOUR  
 805 PROPOSED CONTOUR  
 DRAINAGE AREA BOUNDARY  
 CE CONSTRUCTION ENTRANCE  
 SO SILT FENCE OUTLET  
 CS CONCRETE WASHOUT STATION  
 RCD ROCK CHECK DAM  
 IP INLET PROTECTION  
 RPIP ROCK PIPE INLET PROTECTION  
 SK SKIMMER  
 TSD TEMPORARY SLOPE DRAIN  
 RIP RIP-RAP OUTLET PROTECTION  
 SB SILT BAG  
 DAZ DESIGNATED AREAS TO BE STABILIZED WITHIN 7 DAYS  
 TEMPO TEMPORARY EROSION CONTROL MATTING

**PHASE 2 CONSTRUCTION SEQUENCE:**

- THE FOLLOWING PHASE 2 CONSTRUCTION SEQUENCE IS FURNISHED AS A GENERAL GUIDE FOR PREPARATION OF A SEQUENCE OF CONSTRUCTION EVENTS.
- MAINTAIN CONSTRUCTION ENTRANCE AND SILT FENCE.
- CALL FOR ON-SITE INSPECTION BY INSPECTOR ONCE ALL PHASE 2 EROSION CONTROL MEASURES ARE INSTALLED. OBTAIN CERTIFICATE OF COMPLIANCE FROM WAKE COUNTY.
- CONTRACTOR IS TO CUT AND/OR FILL AREAS TO BRING THE SITE TO THE PROPOSED GRADES SHOWN ON THE GRADING AND DRAINAGE PLANS. GRADING ACTIVITY SHALL BE LIMITED TO WITHIN THE CLEARING LIMITS. MAINTAIN ALL EROSION CONTROL MEASURES AS NECESSARY.
- PROVIDE GROUND COVER ON SLOPES GREATER THAN 3:1 WITHIN 7 DAYS FOLLOWING COMPLETION OF ANY PHASE OF GRADING. PROVIDE GROUND COVER TO ALL OTHER AREAS WITHIN 14 DAYS FOLLOWING COMPLETION OF ANY PHASE OF GRADING OR INACTIVITY.
- INSTALL STORM DRAINAGE AND PROTECT INLETS WITH BLOCK AND GRAVEL INLET CONTROLS, SEDIMENT TRAPS, OR OTHER APPROVED MEASURES AS SHOWN ON THE PLAN.
- STABILIZE SITE AS AREAS ARE BROUGHT UP TO FINISH GRADE WITH VEGETATION, PAVING, DITCH LININGS, ETC. SEED AND MULCH DENUDED AREAS PER GROUND STABILIZATION TIME FRAMES.
- INSPECT AND REPAIR EROSION CONTROL MEASURES AFTER EVERY RAINFALL EVENT OF 1/2" OR GREATER OR EVERY SEVEN (7) CALENDAR DAYS.
- ALL EROSION CONTROL MEASURES SHALL BE CONSTRUCTED IN ACCORDANCE WITH THE NC DENR EROSION AND SEDIMENT CONTROL PLANNING AND DESIGN MANUAL, U.S. DEPARTMENT OF AGRICULTURE, AND CITY OF GREENVILLE EROSION CONTROL ORDINANCE.
- REFER TO SHEET C0.1 - GENERAL NOTES FOR GENERAL EROSION CONTROL NOTES AND MAINTENANCE.
- ALL EROSION CONTROL MEASURES TO REMAIN IN PLACE UNTIL +/- 80% STABILIZATION IS ACHIEVED.
- ONCE CONSTRUCTION IS COMPLETE AND ENTIRE SITE IS STABILIZED, CALL FOR FINAL INSPECTION BY WAKE COUNTY ENVIRONMENTAL CONSULTANT. IF APPROVED, REMOVE REMAINING EROSION CONTROL MEASURES. ALL REMAINING PERMANENT EROSION CONTROL DEVICES SHOULD NOW BE INSTALLED.
- WHEN VEGETATION HAS BECOME ESTABLISHED, CALL FOR A FINAL INSPECTION BY WAKE COUNTY ENVIRONMENTAL CONSULTANT. OBTAIN A CERTIFICATE OF COMPLETION.

LIMITS OF DISTURBANCE: 0.77 AC

**SURVEY NOTE:**  
EXISTING TOPOGRAPHICAL INFORMATION IS BASED ON A TOPOGRAPHIC SURVEY OBTAINED ON 02/23/2023 BY CMP PROFESSIONAL LAND SURVEYORS, 333 S. WHITE STREET, WAKE FOREST, NC 27588. PHONE: (919) 556-3148. CONTRACTOR SHALL BE RESPONSIBLE FOR VERIFYING ALL EXISTING INFORMATION, DEFICIT OR NOT, PRIOR TO CONSTRUCTION AND REPORT POTENTIAL CONFLICTS TO OWNER AND ENGINEER.

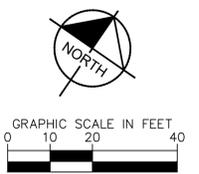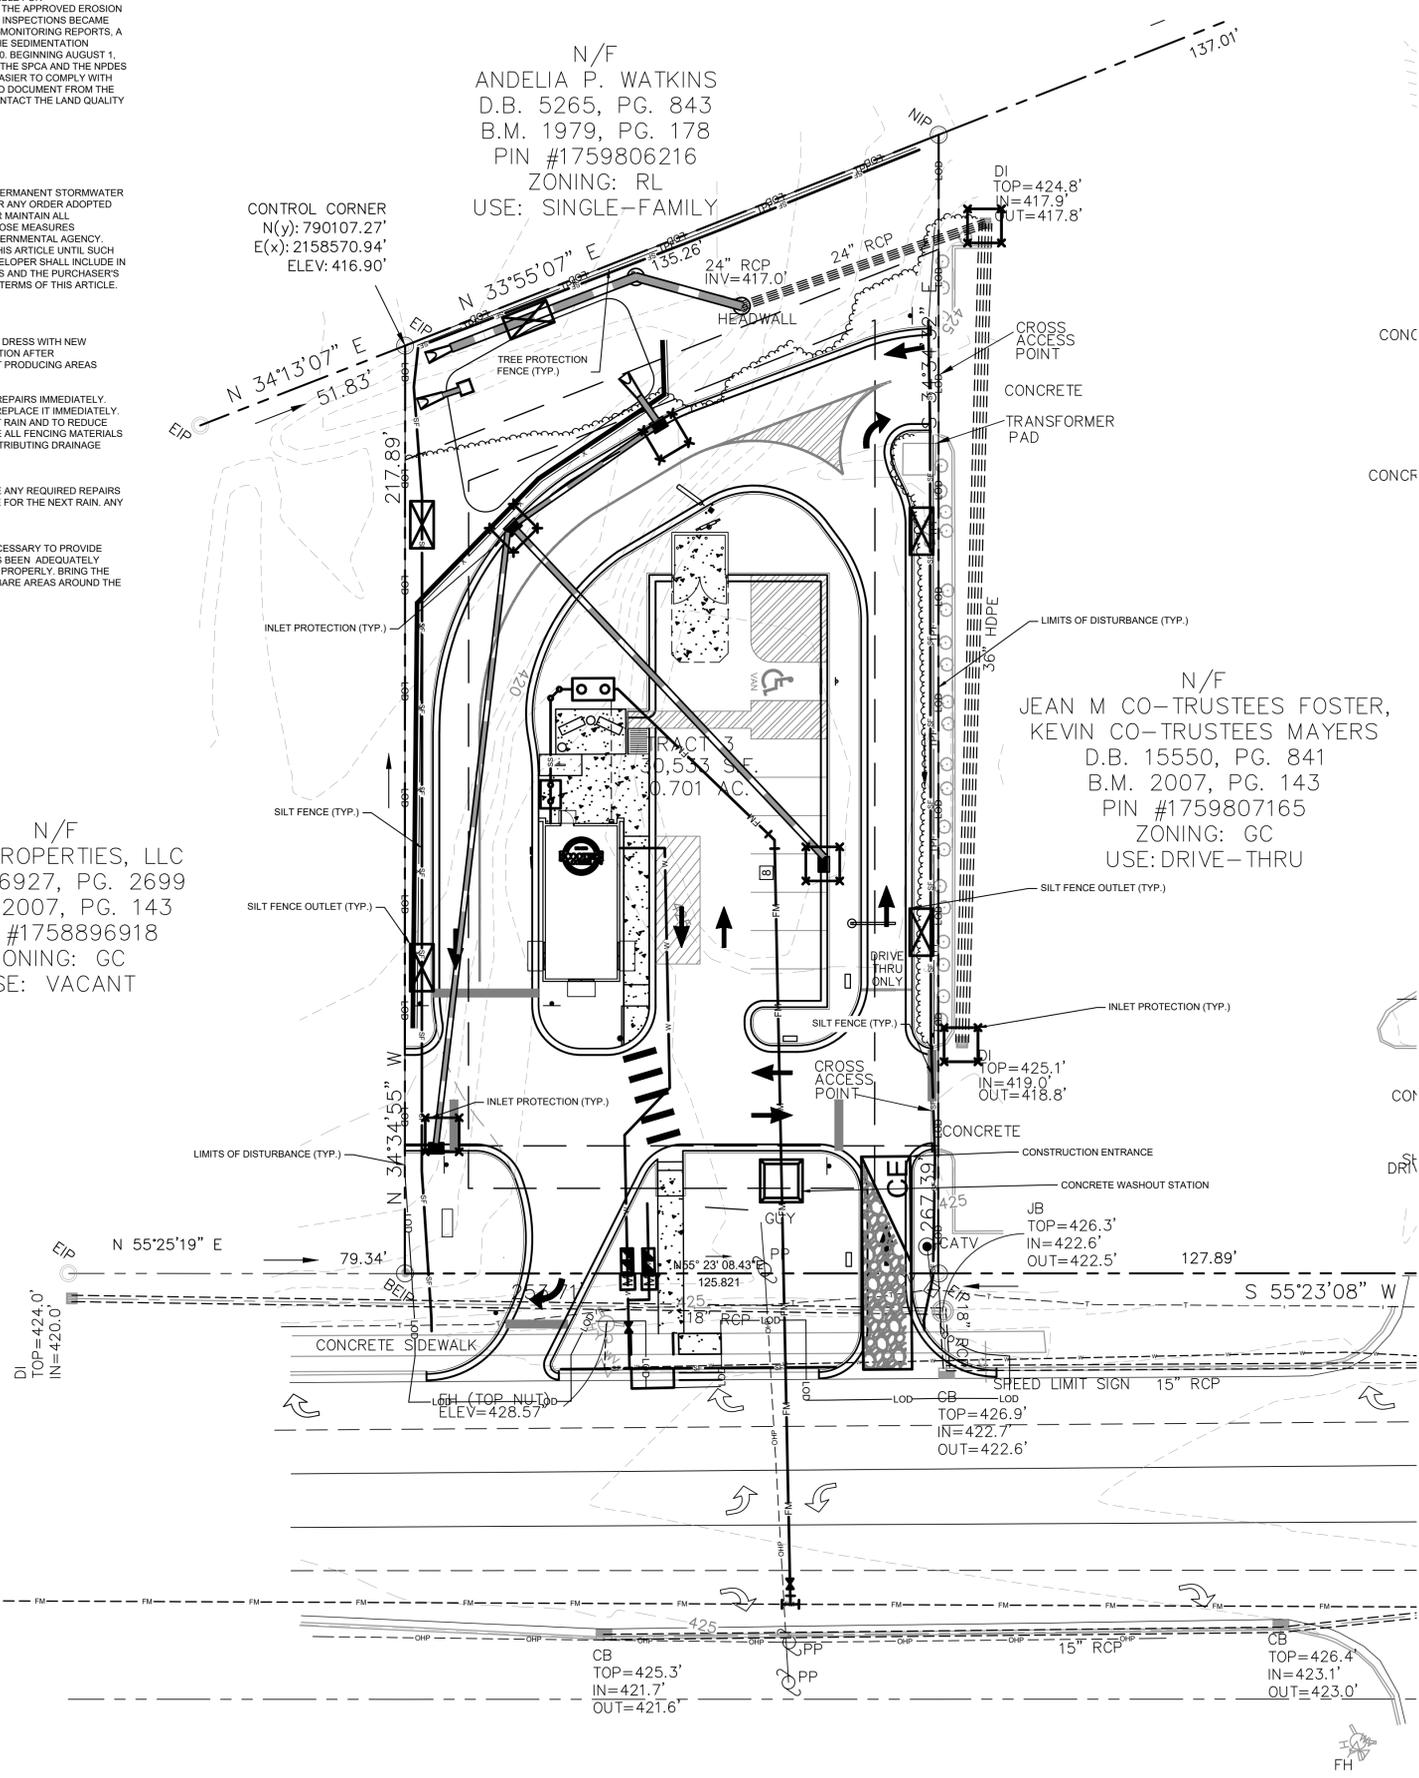

Plotted By: Barnes, Michael. Sheet Set: SCOOTER'S ROLESVILLE Layout.C5.1. EROSION CONTROL PLAN - PHASE 2. January 02, 2024. 04:17:04pm. K:\RAL\_LDEV\016485000-Scooters Rolesville\Planning\15-Cad\Files\PlanSheets\C5.1 EROSION CONTROL PLAN - PHASE 2.dwg  
 This document, together with the concepts and designs presented herein, is intended only for the specific purpose and client for which it was prepared. Reuse of and improper reliance on this document without written authorization and adaptation by Kimley-Horn and Associates, Inc. shall be without liability to Kimley-Horn and Associates, Inc.

**Kimley-Horn**  
 © 2023 KIMLEY-HORN AND ASSOCIATES, INC.  
 #F-0102 WWW.KIMLEY-HORN.COM PHONE: 919.677.2000 FAX: 919.677.2050  
 421 FAYETTEVILLE STREET, SUITE 800, RALEIGH, NC 27601

**SCOOTER'S ROLESVILLE**  
 PREPARED FOR  
**S&S JAVA ENTERPRISES**  
 ROLESVILLE, NC

**EROSION CONTROL PLAN - PHASE 2**














KHA PROJECT: 016485000  
 DATE: 10/31/2023  
 SCALE: AS SHOWN  
 DESIGNED BY: JAA  
 DRAWN BY: JAA  
 CHECKED BY: COB

TOWN COMMENTS: 01/02/2024 IMDB BY: DATE

SHEET NUMBER: C5.1



Plotted By: Barnes, Michael. Sheet Set: SCOOTER'S ROLESVILLE. Layout: C5.2 EROSION CONTROL DETAILS. January 02, 2024. 04:17:14pm. K:\RAL\_LDEV\01648500-Scoters Rolesville\Plan\Sheet\C5.2 EROSION CONTROL DETAILS.dwg  
 This document, together with the concepts and designs presented herein, is intended only for the specific purpose and client for which it was prepared. Reuse of and improper reliance on this document without written authorization and adaptation by Kimley-Horn and Associates, Inc. shall be without liability to Kimley-Horn and Associates, Inc.

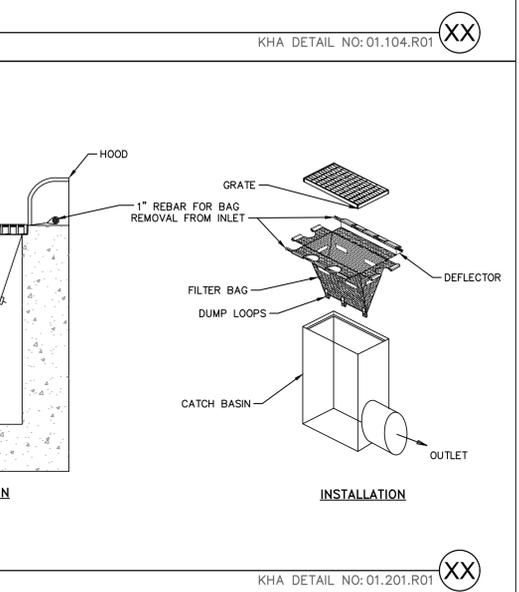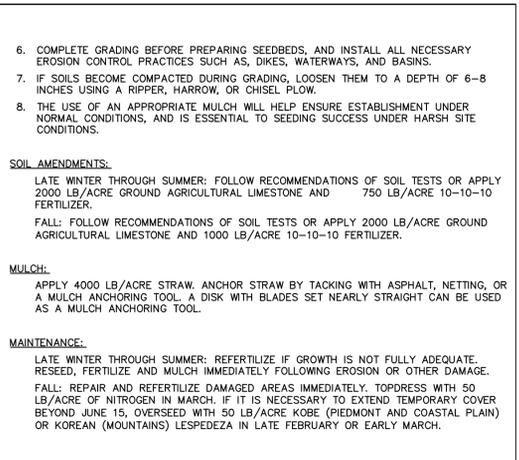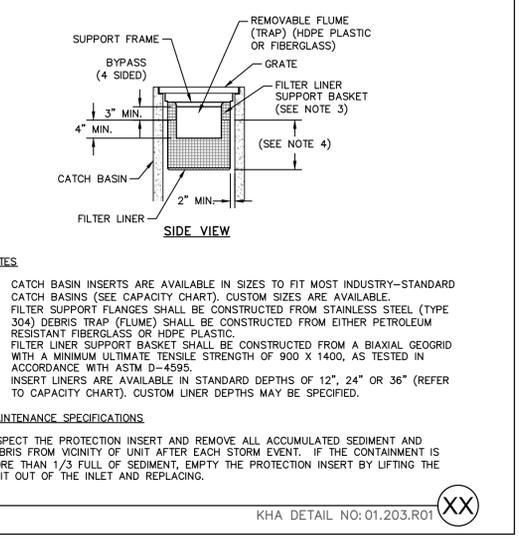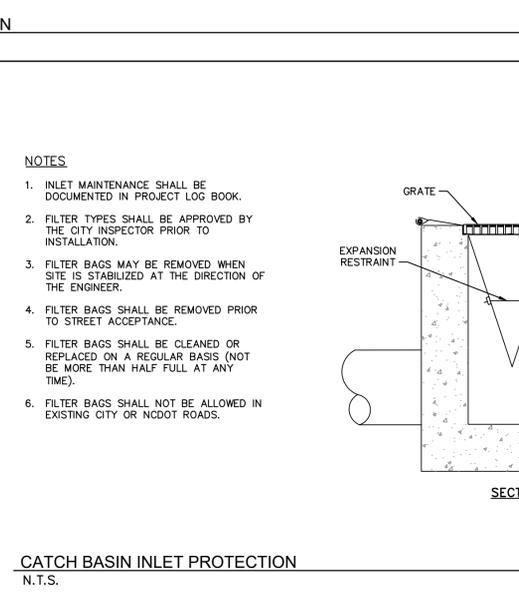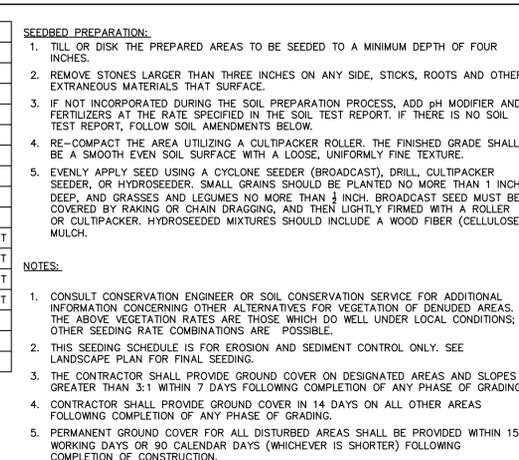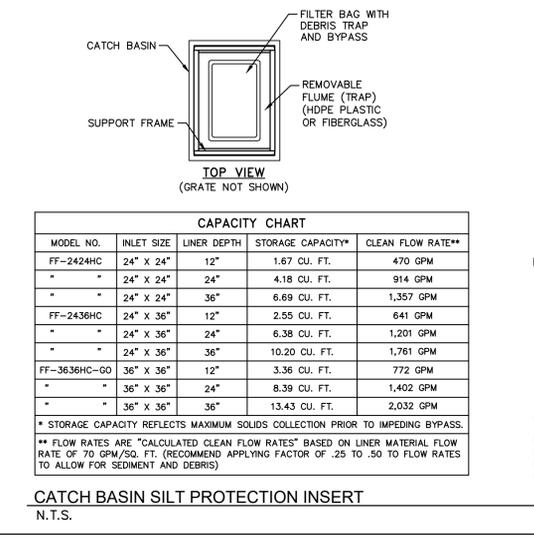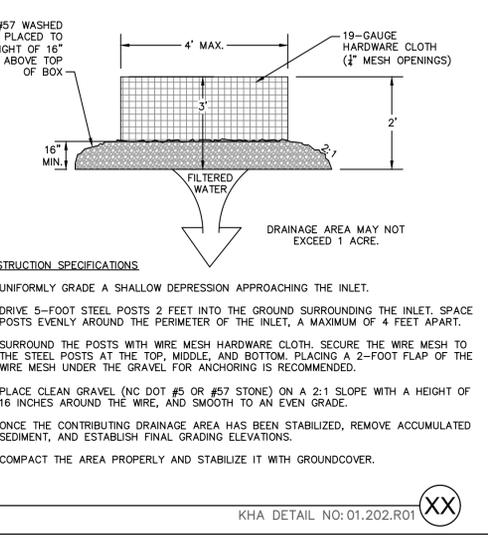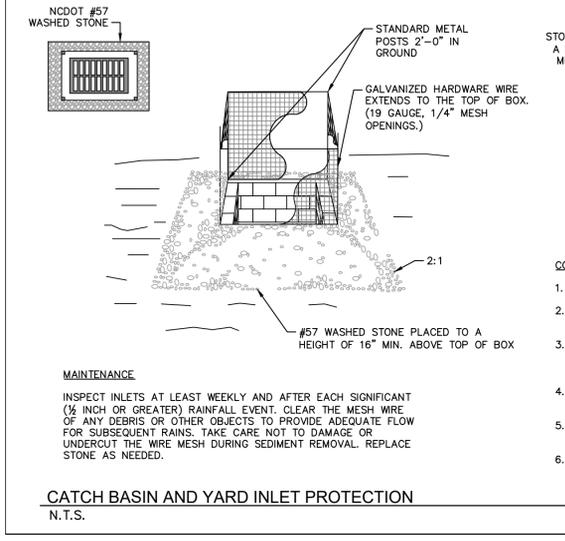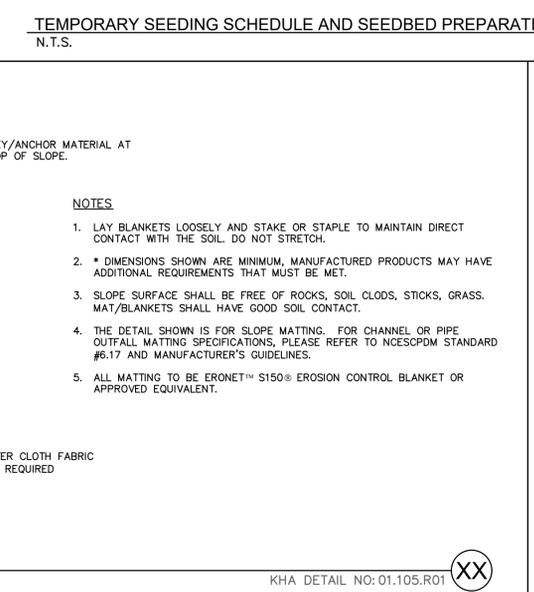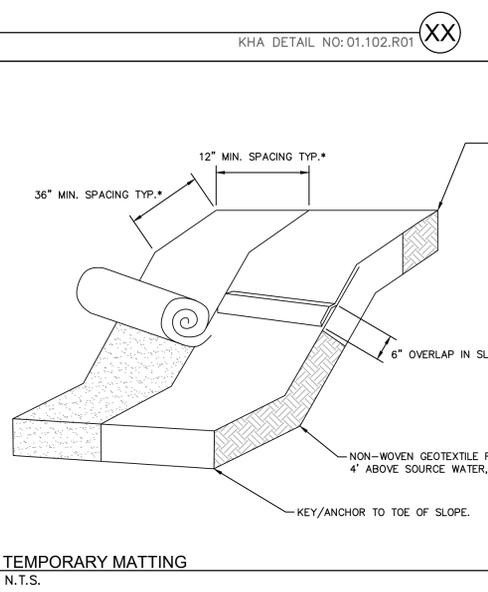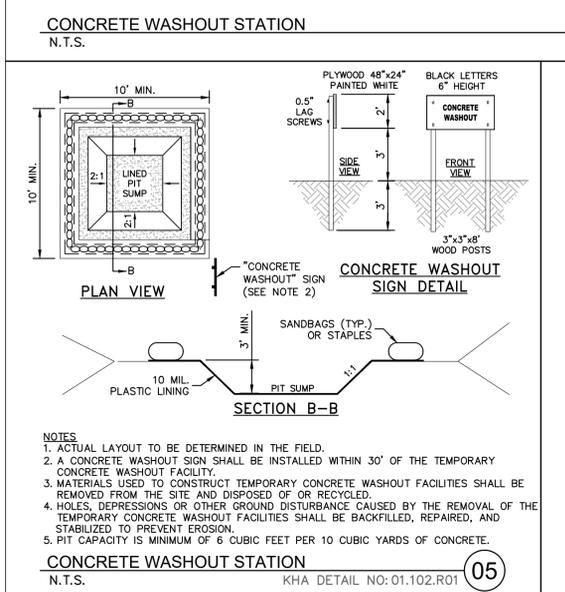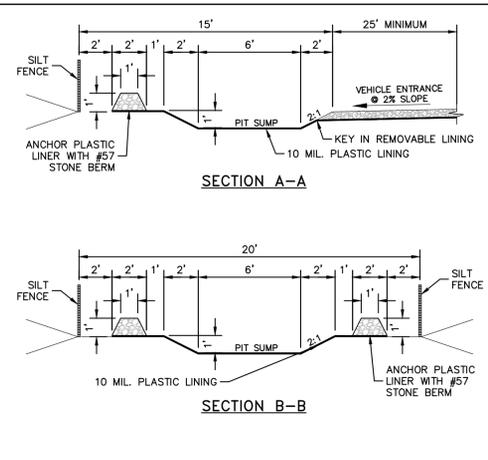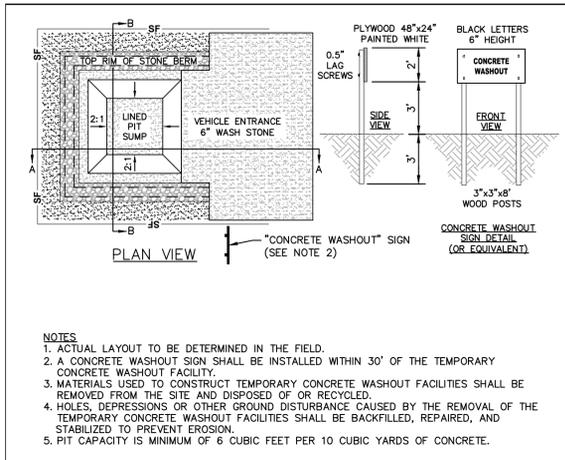

SCOOTER'S ROLESVILLE  
PREPARED FOR  
S&S JAVA ENTERPRISES  
ROLESVILLE, NC

Kimley-Horn  
© 2023 KIMLEY-HORN AND ASSOCIATES, INC.  
#F-0102 WWW.KIMLEY-HORN.COM PHONE: 919-677-2000 FAX: 919-677-2050  
421 FAYETTEVILLE STREET, SUITE 800, RALEIGH, NC 27601

DATE  
REVISIONS  
NO.

**NOT FOR CONSTRUCTION**


DATE: 10/31/2023  
SCALE: AS SHOWN  
DESIGNED BY: JAA  
DRAWN BY: JAA  
CHECKED BY: COB

**EROSION CONTROL DETAILS**

SHEET NUMBER: C5.2




Plotted By: Barnes, Michael. Sheet Set: SCOOTER'S ROLESVILLE Layout: C5.3. EROSION CONTROL DETAILS January 02, 2024. 04:17:15pm. K:\RAL\_LDEV\016485000-Scooters Rolesville\Plan\Sheet\C5.3 Erosion Control Details.dwg  
 This document, together with the concepts and designs presented herein, is an instrument of service, as an instrument of service, is intended only for the specific purpose and client for which it was prepared. Reuse of and improper reliance on this document without written authorization and adaptation by Kimley-Horn and Associates, Inc. shall be without liability to Kimley-Horn and Associates, Inc.

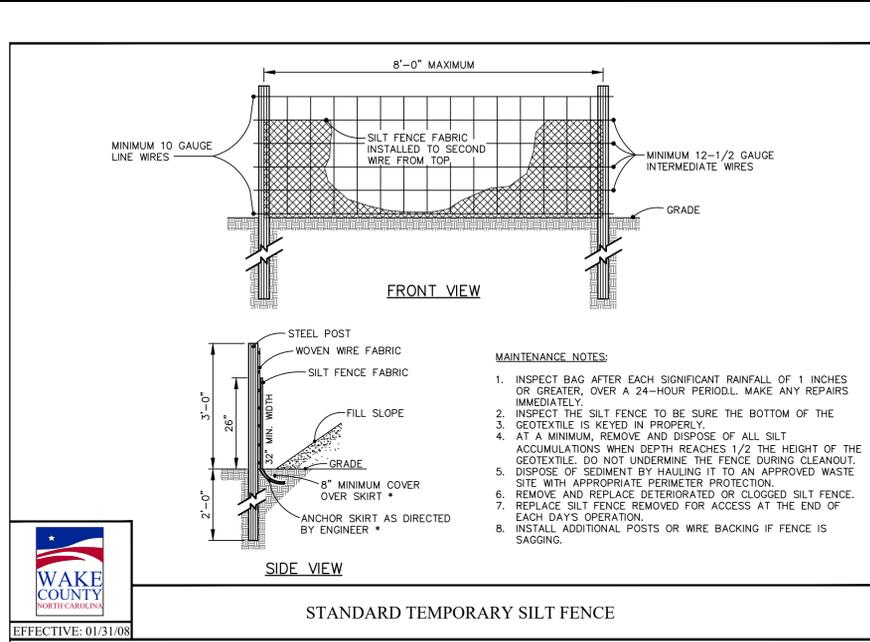

**WAKE COUNTY**  
NORTH CAROLINA

EFFECTIVE: 01/31/08


STANDARD TEMPORARY SILT FENCE

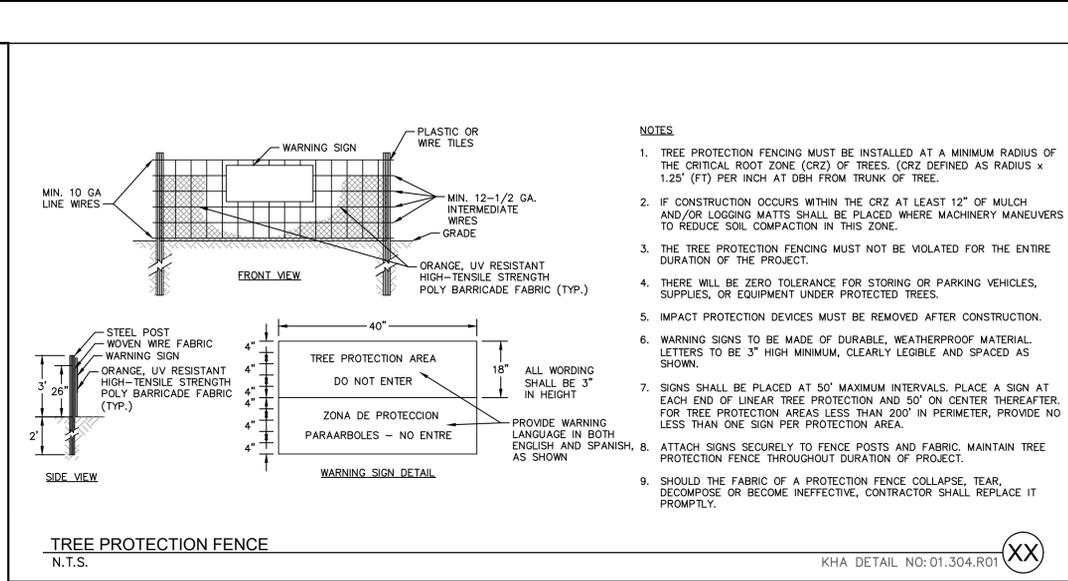

- NOTES:**
- TREE PROTECTION FENCING MUST BE INSTALLED AT A MINIMUM RADIUS OF THE CRITICAL ROOT ZONE (CRZ) OF TREES. (CRZ DEFINED AS RADIUS x 1.25' (FT) PER INCH AT DBH FROM TRUNK OF TREE).
  - IF CONSTRUCTION OCCURS WITHIN THE CRZ AT LEAST 12" OF MULCH AND/OR LOGGING MATS SHALL BE PLACED WHERE MACHINERY MANEUVERS TO REDUCE SOIL COMPACTION IN THIS ZONE.
  - THE TREE PROTECTION FENCING MUST NOT BE VIOLATED FOR THE ENTIRE DURATION OF THE PROJECT.
  - THERE WILL BE ZERO TOLERANCE FOR STORING OR PARKING VEHICLES, SUPPLIES, OR EQUIPMENT UNDER PROTECTED TREES.
  - IMPACT PROTECTION DEVICES MUST BE REMOVED AFTER CONSTRUCTION.
  - WARNING SIGNS TO BE MADE OF DURABLE, WEATHERPROOF MATERIAL. LETTERS TO BE 3" HIGH MINIMUM, CLEARLY LEGIBLE AND SPACED AS SHOWN.
  - SIGNS SHALL BE PLACED AT 50' MAXIMUM INTERVALS. PLACE A SIGN AT EACH END OF LINEAR TREE PROTECTION AND 50' ON CENTER THEREAFTER. FOR TREE PROTECTION AREAS LESS THAN 200' IN PERIMETER, PROVIDE NO LESS THAN ONE SIGN PER PROTECTION AREA.
  - ATTACH SIGNS SECURELY TO FENCE POSTS AND FABRIC. MAINTAIN TREE PROTECTION FENCE THROUGHOUT DURATION OF PROJECT.
  - SHOULD THE FABRIC OF A PROTECTION FENCE COLLAPSE, TEAR, DECOMPOSE OR BECOME INEFFECTIVE, CONTRACTOR SHALL REPLACE IT PROMPTLY.


TREE PROTECTION FENCE  
N.T.S.

KHA DETAIL NO: 01.304.R01 XX

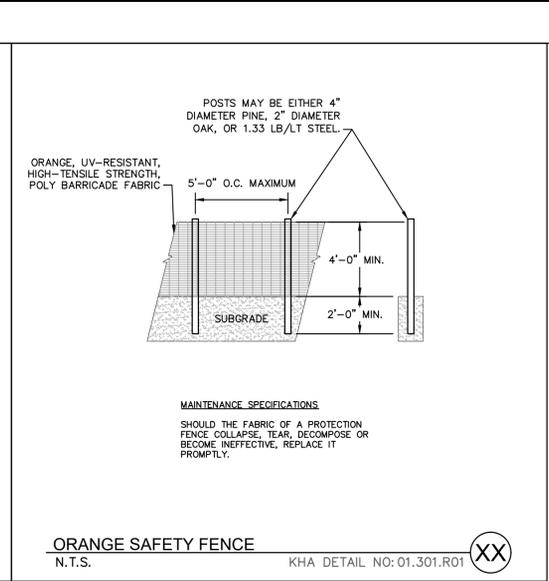

ORANGE SAFETY FENCE  
N.T.S.


KHA DETAIL NO: 01.301.R01 XX

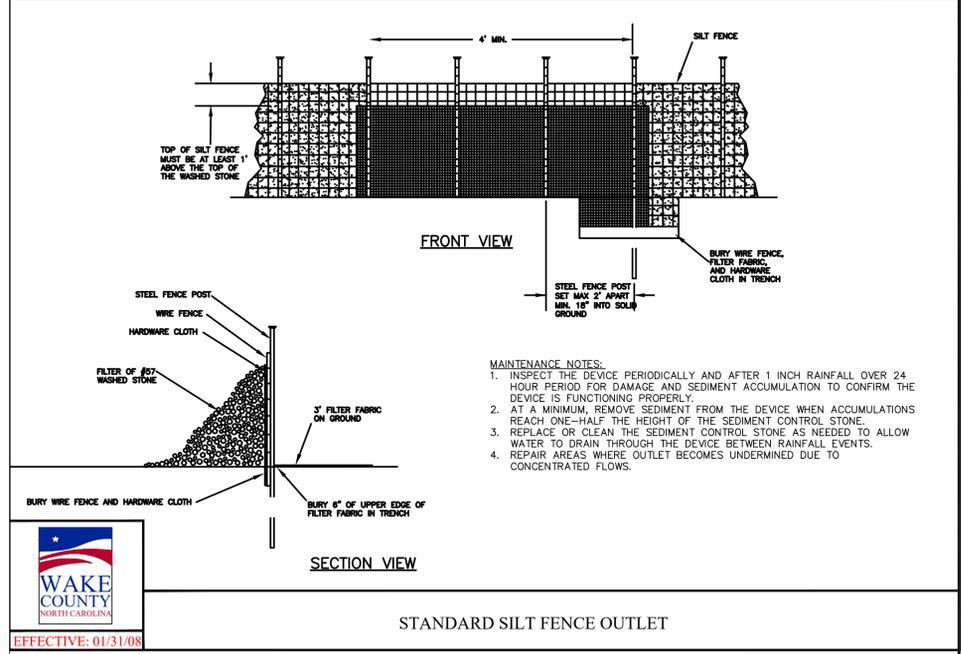

**WAKE COUNTY**  
NORTH CAROLINA

EFFECTIVE: 01/31/08

STANDARD SILT FENCE OUTLET

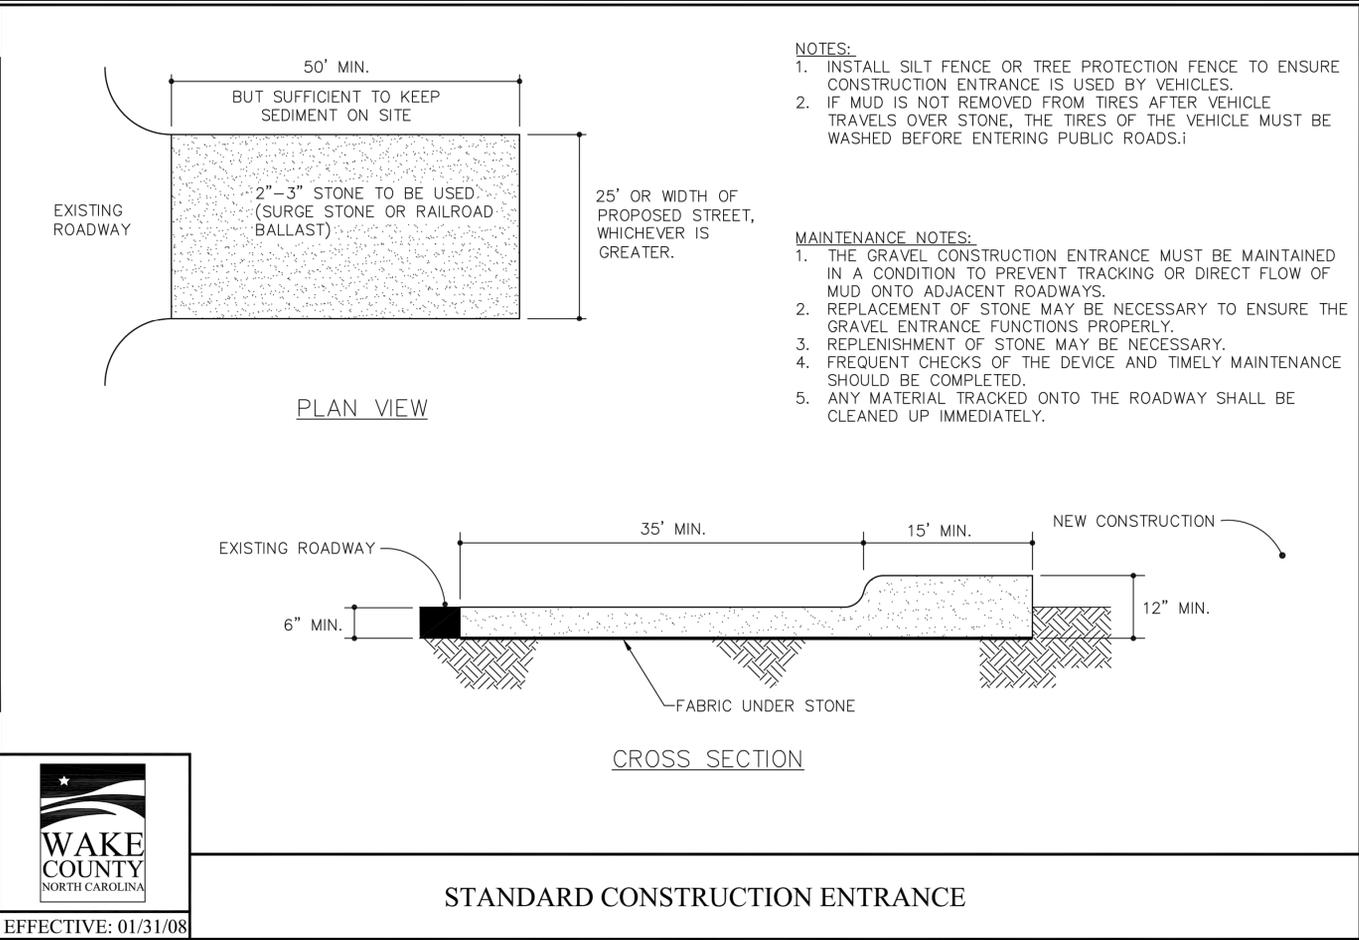

**WAKE COUNTY**  
NORTH CAROLINA

EFFECTIVE: 01/31/08

STANDARD CONSTRUCTION ENTRANCE

**SURVEY NOTE:**  
 EXISTING TOPOGRAPHICAL INFORMATION IS BASED ON A TOPOGRAPHIC SURVEY OBTAINED ON 02/23/2023 BY CMP PROFESSIONAL LAND SURVEYORS, 333 S. WHITE STREET, WAKE FOREST, NC, 27888. PHONE: (919) 556-3148. CONTRACTOR SHALL BE RESPONSIBLE FOR VERIFYING ALL EXISTING INFORMATION, DEPICTED OR NOT, PRIOR TO CONSTRUCTION AND REPORT POTENTIAL CONFLICTS TO OWNER AND ENGINEER.

NO.	REVISIONS	DATE
1		
2		
3		
4		
5		
6		
7		

**Kimley-Horn**

© 2023 KIMLEY-HORN AND ASSOCIATES, INC.  
 #F-0102 WWW.KIMLEY-HORN.COM PHONE: 919.677.2000 FAX: 919.677.2050  
 421 FAYETTEVILLE STREET, SUITE 600, RALEIGH, NC 27601

**NOT FOR CONSTRUCTION**

KHA PROJECT: 016485000  
 DATE: 10/31/2023  
 SCALE: AS SHOWN  
 DESIGNED BY: JAA  
 DRAWN BY: JAA  
 CHECKED BY: COB


**EROSION CONTROL DETAILS**

**SCOOTER'S ROLESVILLE**  
 PREPARED FOR  
**S&S JAVA ENTERPRISES**  
 ROLESVILLE, NC


SHEET NUMBER  
**C5.3**




Plotted By: Barnes, Michael. Sheet: SCOOTER'S ROLESVILLE. Layout: C8.0 SITE DETAILS. January 02, 2024. 04:17:21 PM. K:\RAL\_LDE\016485000-Scooters Rolesville\Planning\15-CAD Files\Plan\Sheets\C8.0 SITE DETAILS.dwg  
 This document, together with the concepts and designs presented herein, is an instrument of service, is intended only for the specific purpose and client for which it was prepared. Reuse of and improper reliance on this document without written authorization and adaptation by Kimley-Horn and Associates, Inc. shall be without liability to Kimley-Horn and Associates, Inc.

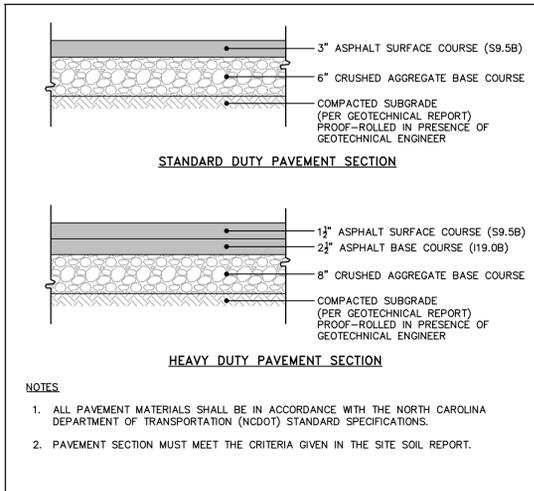


**ASPHALT PAVEMENT SECTIONS**  
N.T.S. KHA DETAIL NO: 02.101.R02 XX

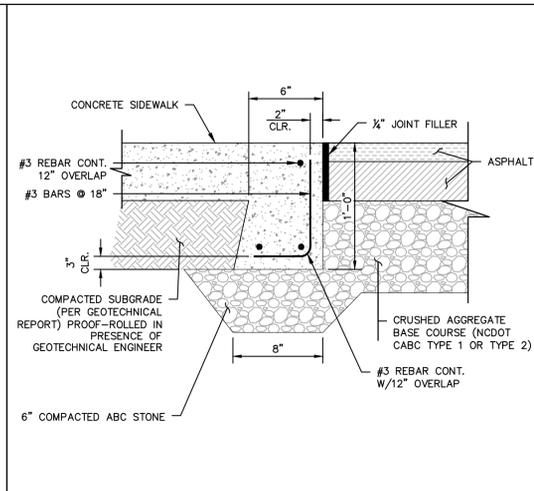


**FLUSH CONCRETE SIDEWALK**  
N.T.S. KHA DETAIL NO: 02.104.R02 XX

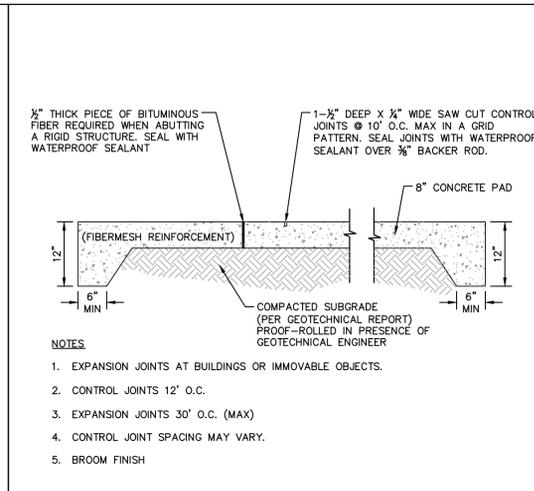


**CONCRETE APRON AND DUMPSTER PAD**  
N.T.S. KHA DETAIL NO: 02.107.R01 XX

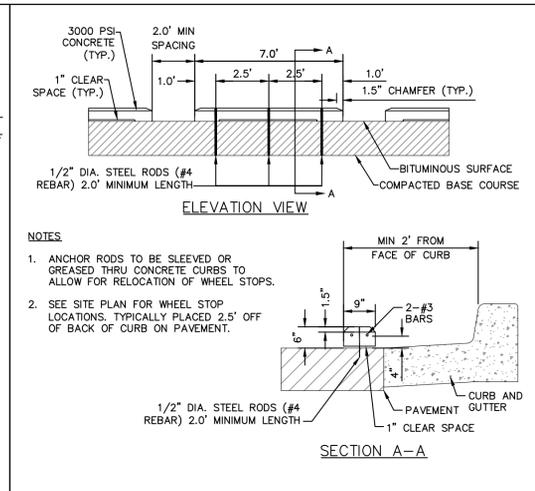


**WHEEL STOP**  
N.T.S. KHA DETAIL NO: 02.111.R02 XX

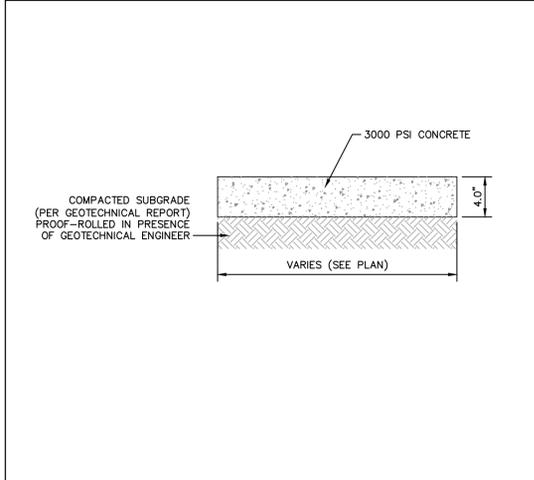


**SIDEWALK SECTION**  
N.T.S. KHA DETAIL NO: 02.102.R01 XX

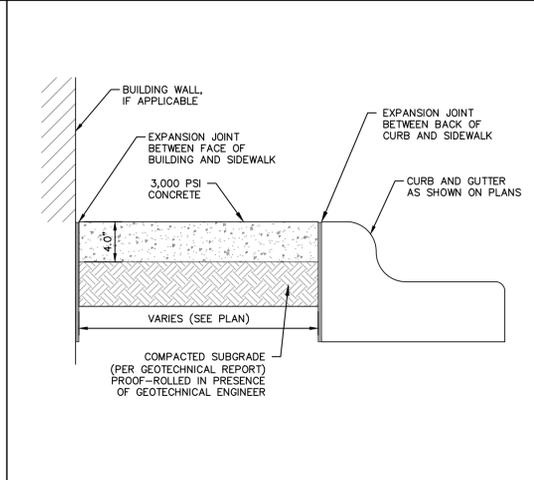


**SIDEWALK ADJACENT TO PARKING AREAS**  
N.T.S. KHA DETAIL NO: 02.105.R02 XX

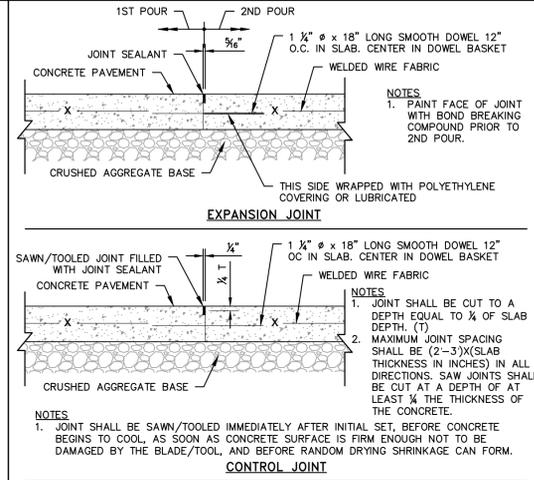


**HEAVY DUTY CONTROL AND EXPANSION JOINTS**  
N.T.S. KHA DETAIL NO: 02.108.R02 XX

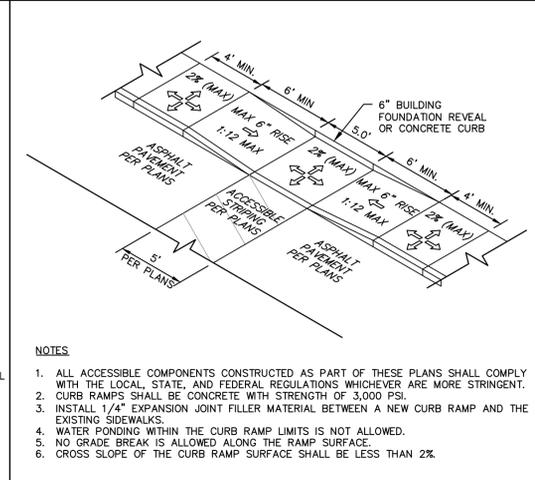

**DEPRESSED CURB RAMP**  
N.T.S. KHA DETAIL NO: 02.109.R02 XX

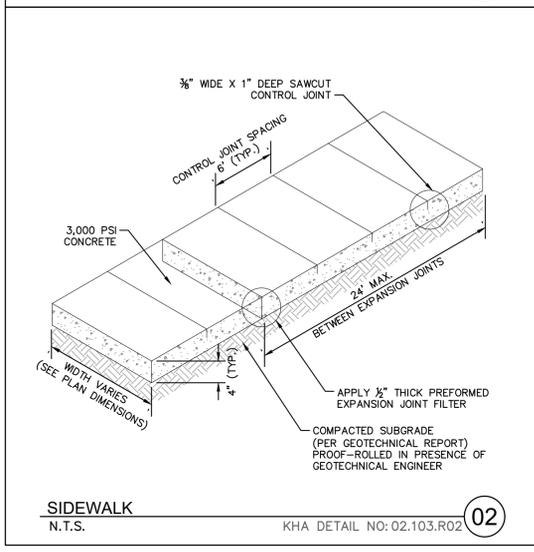

**SIDEWALK**  
N.T.S. KHA DETAIL NO: 02.103.R02 02

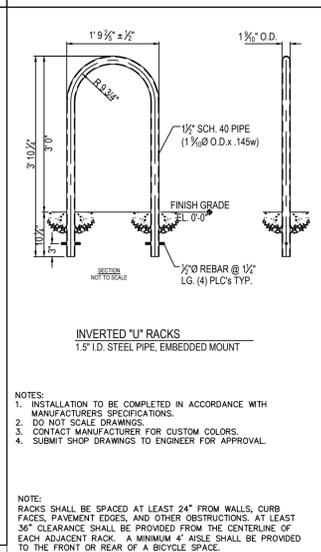

**BIKE RACK DETAIL**  
SCALE: NTS REVISION DATE: 05/10/2016

**SURVEY NOTE:**  
EXISTING TOPOGRAPHICAL INFORMATION IS BASED ON A TOPOGRAPHIC SURVEY OBTAINED ON 02/23/2023 BY CMP PROFESSIONAL LAND SURVEYORS, 333 S. WHITE STREET, WAKE FOREST, NC, 27588. PHONE: (919) 556-3148. CONTRACTOR SHALL BE RESPONSIBLE FOR VERIFYING ALL EXISTING INFORMATION, DEPICTED OR NOT, PRIOR TO CONSTRUCTION AND REPORT POTENTIAL CONFLICTS TO OWNER AND ENGINEER.



DATE
BY

REVISIONS
DATE

No.
No.

© 2023 KIMLEY-HORN AND ASSOCIATES, INC.  
421 FAYETTEVILLE STREET, SUITE 600, RALEIGH, NC 27601

NOT FOR CONSTRUCTION










KHA PROJECT	016485000
DATE	10/31/2023
SCALE	AS SHOWN
DESIGNED BY	JAA
DRAWN BY	JAA
CHECKED BY	COB

SITE DETAILS

SCOOTER'S ROLESVILLE  
PREPARED FOR  
S&S JAVA ENTERPRISES  
ROLESVILLE NC

SHEET NUMBER  
C8.0

Plotted By: Barnes, Michael. Sheet Set: SCOOTER'S ROLESVILLE. Layout: C8.1. SITE DETAILS. January 02, 2024. 04:17:21 PM. K:\RAL\_LDEV\016485000-Scooters Rolesville\Planning\15-CAD Files\PlanSheets\C8.1 SITE DETAILS.dwg  
 This document, together with the concepts and designs presented herein, is an instrument of service, is intended only for the specific purpose and client for which it was prepared. Reuse of and improper reliance on this document without written authorization and adaptation by Kimley-Horn and Associates, Inc. shall be without liability to Kimley-Horn and Associates, Inc.

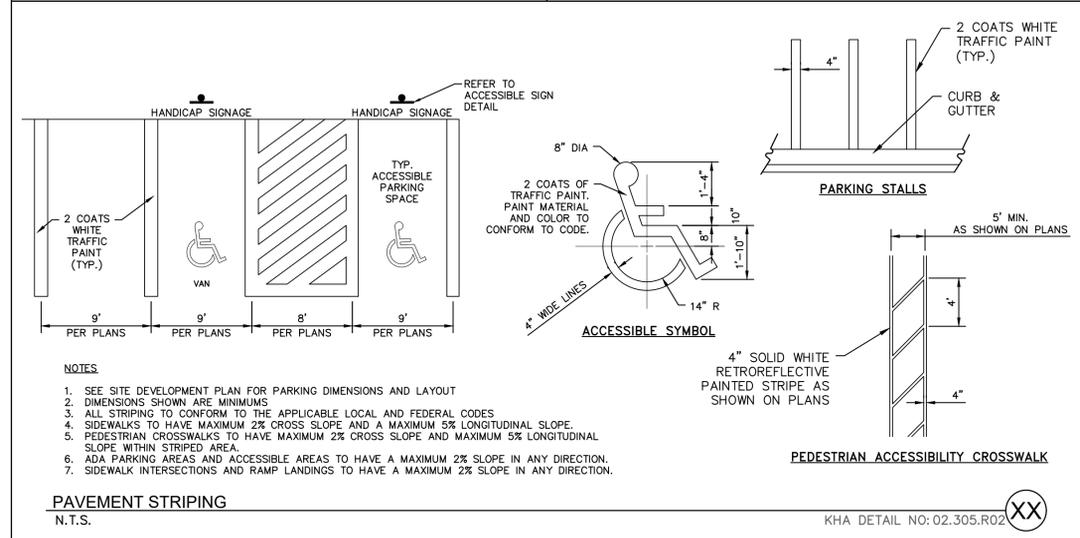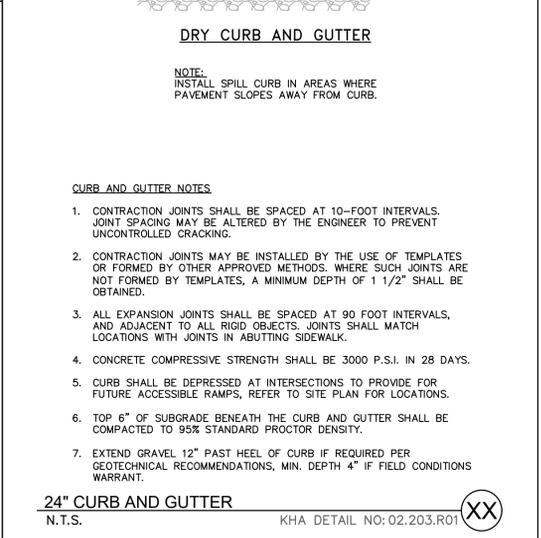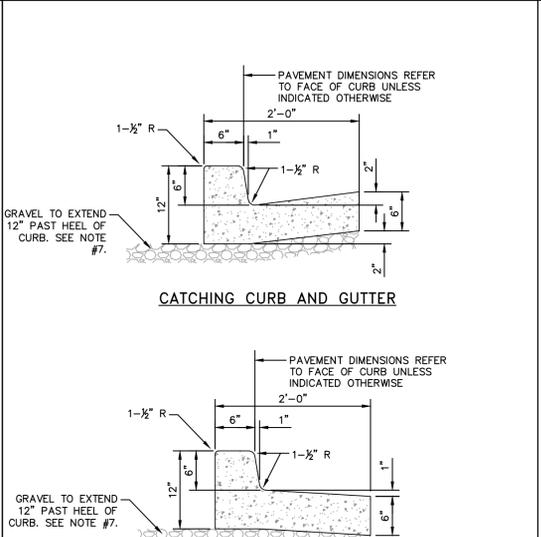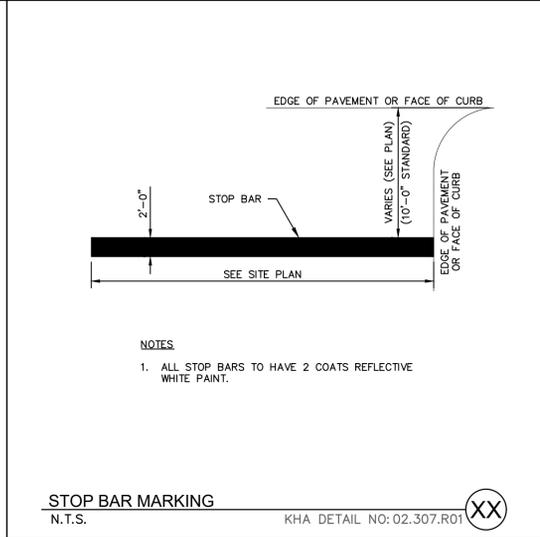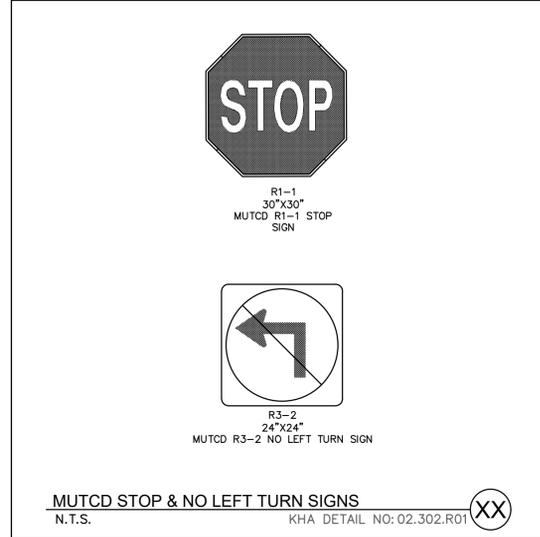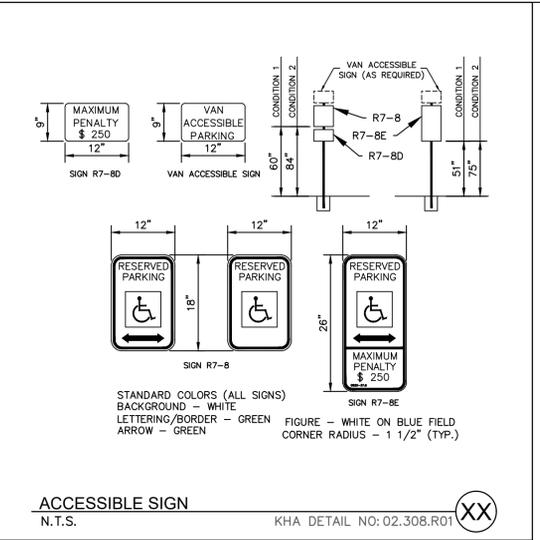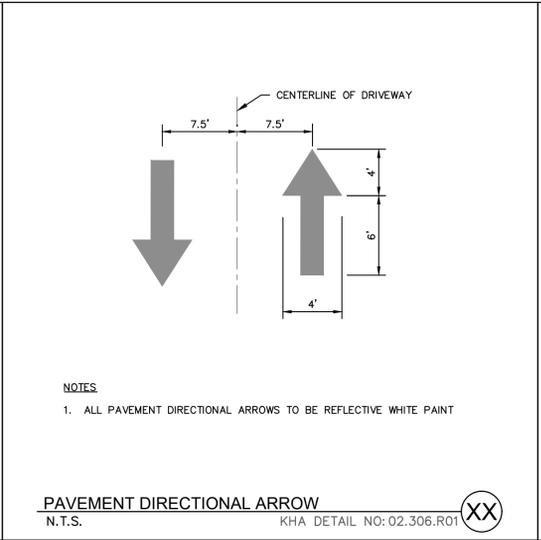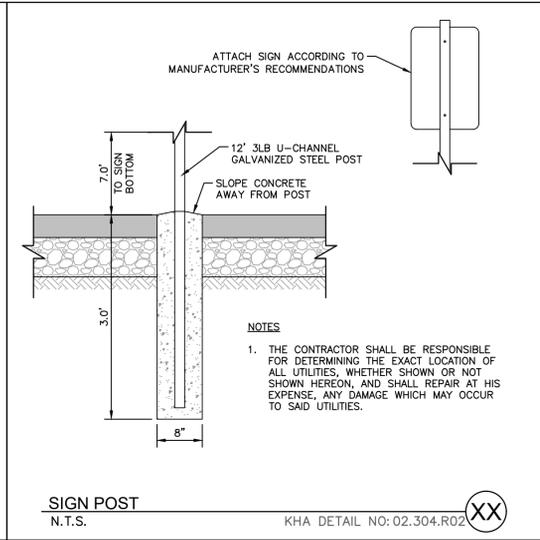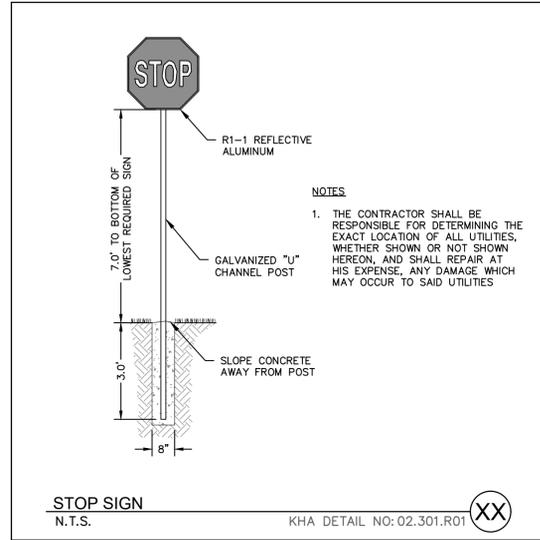

**SURVEY NOTE:**  
EXISTING TOPOGRAPHICAL INFORMATION IS BASED ON A TOPOGRAPHIC SURVEY OBTAINED ON 02/23/2023 BY C&P PROFESSIONAL LAND SURVEYORS, 333 S. WHITE STREET, WAKE FOREST, NC, 27888. PHONE: (919) 556-3148. CONTRACTOR SHALL BE RESPONSIBLE FOR VERIFYING ALL EXISTING INFORMATION, DEPICTED OR NOT, PRIOR TO CONSTRUCTION AND REPORT POTENTIAL CONFLICTS TO OWNER AND ENGINEER.

NO.	REVISIONS	DATE	BY
1			
2			
3			
4			
5			
6			
7			

**Kimley >>> Horn**  
 © 2023 KIMLEY-HORN AND ASSOCIATES, INC.  
 #F-0102 WWW.KIMLEY-HORN.COM PHONE: 919.677.2000 FAX: 919.677.2050  
 421 FAYETTEVILLE STREET, SUITE 600, RALEIGH, NC 27601

**NOT FOR CONSTRUCTION**  
 NORTH CAROLINA  
 PRELIMINARY  
 SHEET 02.203.01C  
 DATE: 10/31/2023  
 SCALE: AS SHOWN  
 DESIGNED BY: JAA  
 DRAWN BY: JAA  
 CHECKED BY: COB

**SITE DETAILS**


**SCOOTER'S ROLESVILLE**  
 PREPARED FOR  
**S&S JAVA ENTERPRISES**  
 ROLESVILLE, NC

SHEET NUMBER  
**C8.1**







Plotted By: Barnes, Michael. Sheet: SCOOTER'S ROLESVILLE Layout.CB.1. STORM DETAILS. January 02, 2024. 04:17:33pm. K:\RAL\_LDEV\016485000-Scoters Rolesville\Planning\15-CAD Files\PlanSheets\C3.2 STORM DETAILS.dwg  
 This document, together with the concepts and designs presented herein, is an instrument of service, as intended only for the specific purpose and client for which it was prepared. Reuse of and improper reliance on this document without written authorization and adaptation by Kimley-Horn and Associates, Inc. shall be without liability to Kimley-Horn and Associates, Inc.

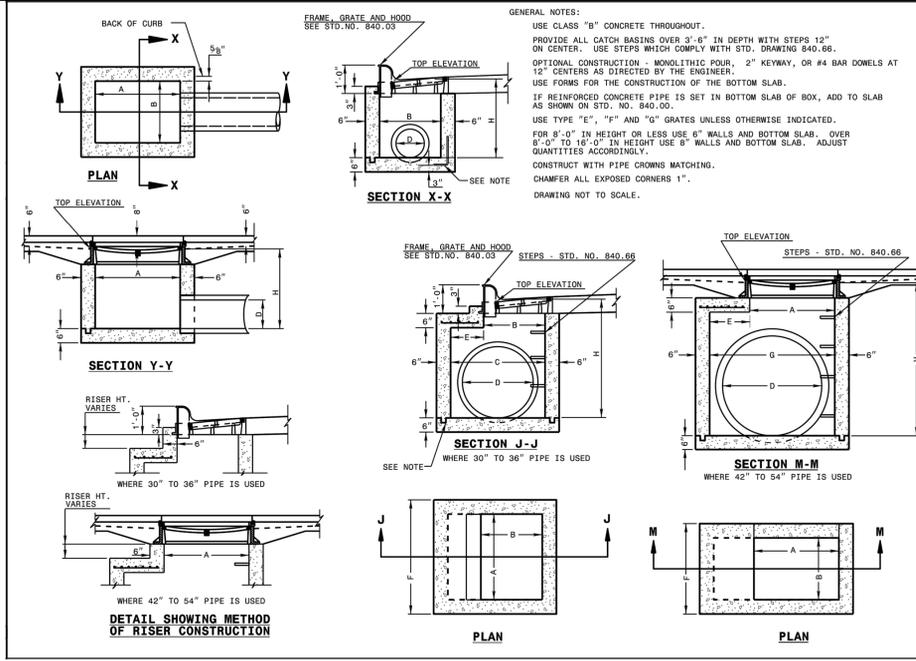

STATE OF NORTH CAROLINA DEPT. OF TRANSPORTATION DIVISION OF HIGHWAYS RALEIGH, N.C.  
 ROADWAY STANDARD DRAWING FOR CONCRETE CATCH BASIN 12" THRU 54" PIPE  
 SHEET 1 OF 2  
**840.02**

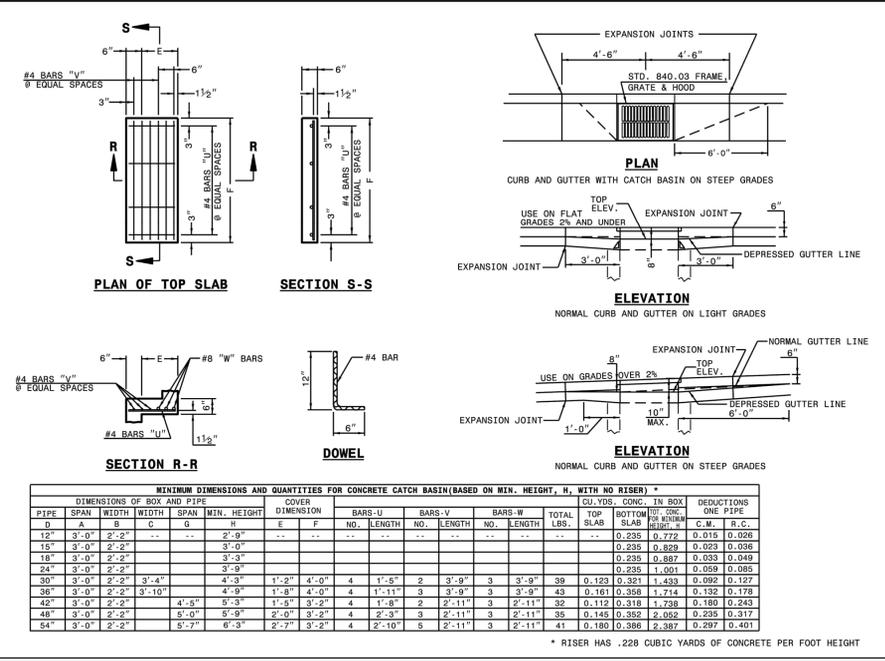

STATE OF NORTH CAROLINA DEPT. OF TRANSPORTATION DIVISION OF HIGHWAYS RALEIGH, N.C.  
 ROADWAY STANDARD DRAWING FOR CONCRETE CATCH BASIN 12" THRU 54" PIPE  
 SHEET 2 OF 2  
**840.02**

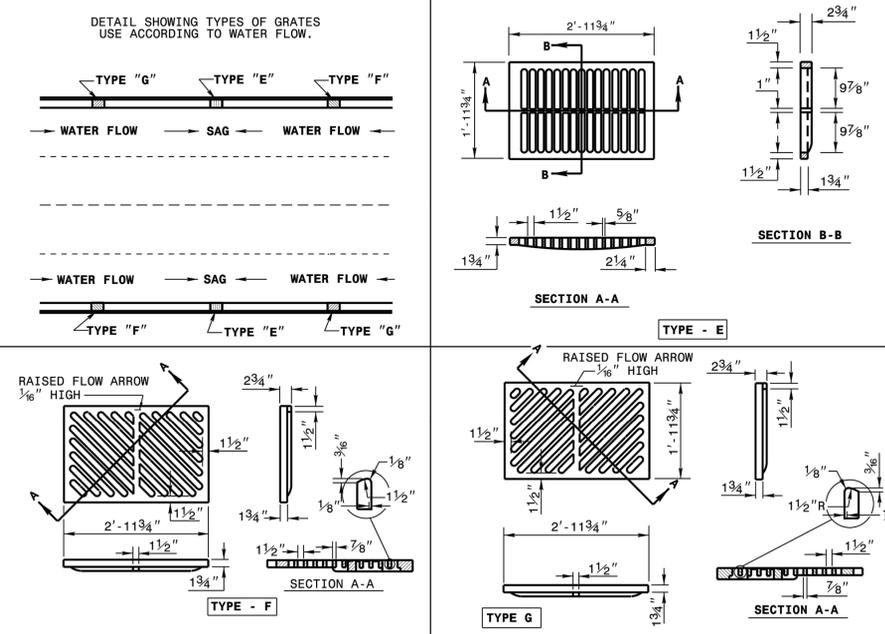

STATE OF NORTH CAROLINA DEPT. OF TRANSPORTATION DIVISION OF HIGHWAYS RALEIGH, N.C.  
 ROADWAY STANDARD DRAWING FOR FRAME, GRATES, AND HOOD FOR USE ON STANDARD CATCH BASIN  
 SHEET 2 OF 2  
**840.03**

**SURVEY NOTE:**  
 EXISTING TOPOGRAPHICAL INFORMATION IS BASED ON A TOPOGRAPHIC SURVEY OBTAINED ON 02/23/2023 BY CMP PROFESSIONAL LAND SURVEYORS, 333 S. WHITE STREET, WAKE FOREST, NC. 27588. PHONE: (919) 556-3148. CONTRACTOR SHALL BE RESPONSIBLE FOR VERIFYING ALL EXISTING INFORMATION, DEPICTED OR NOT, PRIOR TO CONSTRUCTION AND REPORT POTENTIAL CONFLICTS TO OWNER AND ENGINEER.



**Kimley»Horn**  
 © 2023 KIMLEY-HORN AND ASSOCIATES, INC.  
 #F-0102 WWW.KIMLEY-HORN.COM PHONE: 919-677-2000 FAX: 919-677-9050  
 421 FAYETTEVILLE STREET, SUITE 600, RALEIGH, NC 27601

**STORM DETAILS**

SCOOTER'S ROLESVILLE PREPARED FOR S&S JAVA ENTERPRISES ROLESVILLE NC

KHA PROJECT 016485000 DATE 10/31/2023 SCALE AS SHOWN DESIGNED BY JAA DRAWN BY JAA CHECKED BY COE

STATE OF NORTH CAROLINA DEPT. OF TRANSPORTATION DIVISION OF HIGHWAYS RALEIGH, N.C.

STATE OF NORTH CAROLINA DEPT. OF TRANSPORTATION DIVISION OF HIGHWAYS RALEIGH, N.C.


REVISIONS

NO. DATE BY

SHEET NUMBER C9.1

SDP-23-07


Plotted By: Barnes, Michael. Sheet Set: SCOOTER'S ROLESVILLE Layout: C10.0 SANITARY SEWER DETAILS January 02, 2024 04:17:41 pm K:\B\AL\_LDEV\016485000-Scoters Rolesville\Planning\P15\_CAD Files\PlanSheets\C10.1 SANITARY SEWER DETAILS.dwg  
 This document, together with the concepts and designs presented herein, is an instrument of service, as intended only for the specific purpose and client for which it was prepared. Reuse of and improper reliance on this document without written authorization and adaptation by Kimley-Horn and Associates, Inc. shall be without liability to Kimley-Horn and Associates, Inc.

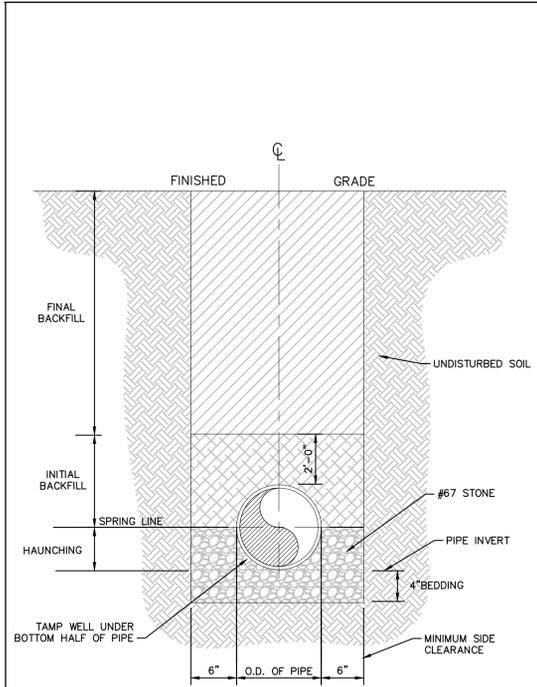


**NOTES**

- FOR TRENCHES REQUIRING SHORING AND BRACING, DIMENSIONS SHALL BE TAKEN FROM THE INSIDE FACE OF THE SHORING AND BRACING.
- NO ROCKS OR BOULDERS 4" OR LARGER TO BE USED IN INITIAL BACKFILL.
- ALL BACKFILL MATERIAL SHALL BE SUITABLE NATIVE MATERIAL.
- BACKFILL SHALL BE TAMPED IN 6" LIFTS IN TRAFFIC AREAS, 12" IN NON-TRAFFIC AREAS.

**BEDDING AND TRENCH**  
N.T.S. KHA DETAIL NO: 04.101.R01 XX

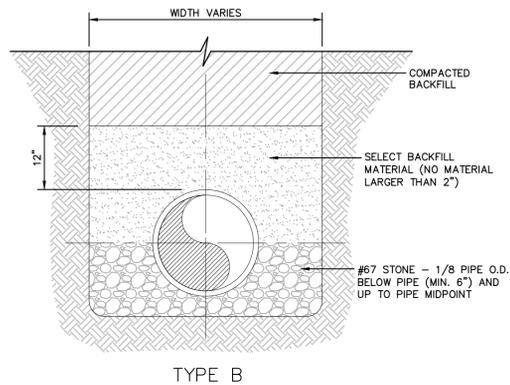


**BACKFILL SECTION**  
N.T.S. KHA DETAIL NO: 04.102.R01 XX

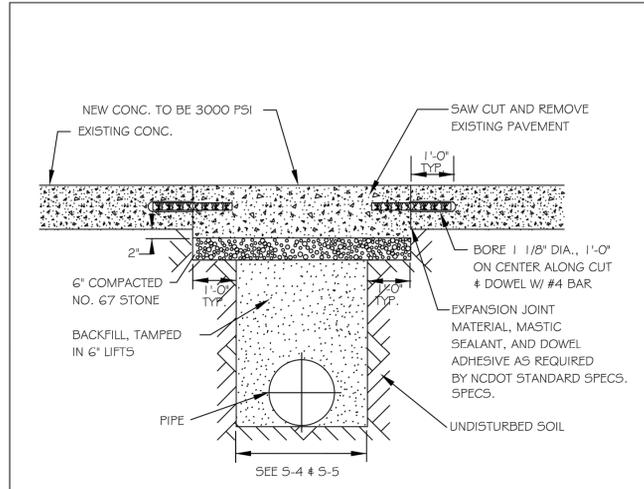


- NOTES:**
- See City of Raleigh standards for trenches and pipe bedding (5-4 & 5-5) for additional details.
  - Pavement cuts over 5'-0" in width shall be reinforced to N.C.D.O.T. standards.
  - Pavement cuts shall be made with an appropriate saw cut machine.
  - Pavement cuts within NCDOT ROW shall conform to the approved on site encroachment permit.

CITY OF RALEIGH				
DEPARTMENT OF PUBLIC UTILITIES				
STANDARD CONCRETE PAVEMENT PATCH DETAIL				
DWG. NO.	REVISIONS	DATE	REVISIONS	DATE
5-2	D.W.C.	6-23-99	A.B.B.	4-19-04
	RRH	3-30-00	J.P.S	0-8-10

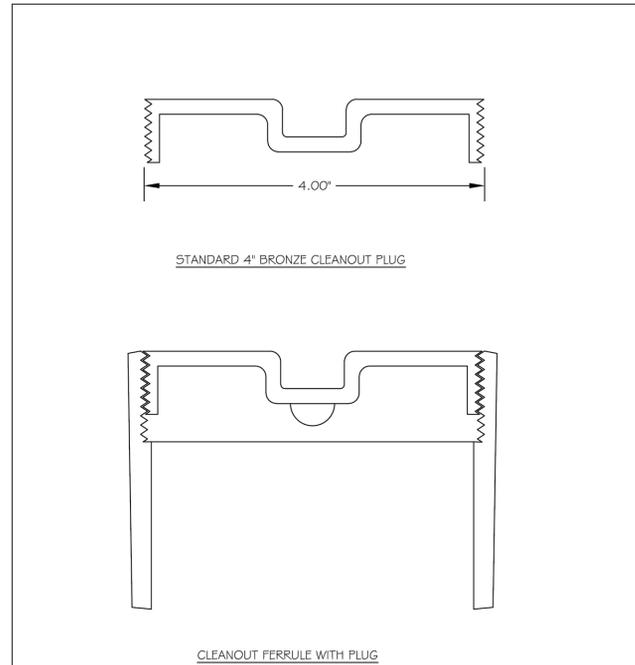

STYLES ACCEPTED:  
INVERTED NUT  
RAISED NUT

CITY OF RALEIGH				
DEPARTMENT OF PUBLIC UTILITIES				
4" CLEANOUT PLUG				
DWG. NO.	REVISIONS	DATE	REVISIONS	DATE
5-34	D.W.C.	3-27-98	RRH	3-30-00

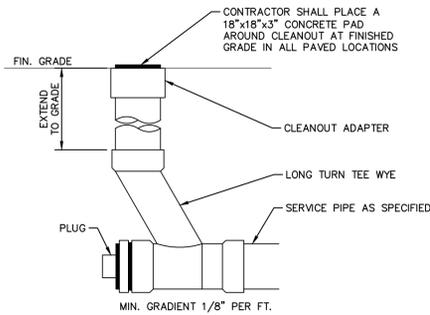

**CLEANOUT**  
N.T.S. KHA DETAIL NO: 04.201.R01 XX

**SURVEY NOTE:**  
EXISTING TOPOGRAPHICAL INFORMATION IS BASED ON A TOPOGRAPHIC SURVEY OBTAINED ON 02/23/2023 BY CMP PROFESSIONAL LAND SURVEYORS, 333 S. WHITE STREET, WAKE FOREST, NC, 27888. PHONE: (919) 556-3148. CONTRACTOR SHALL BE RESPONSIBLE FOR VERIFYING ALL EXISTING INFORMATION, DEPICTED OR NOT, PRIOR TO CONSTRUCTION AND REPORT POTENTIAL CONFLICTS TO OWNER AND ENGINEER.

NO.	REVISIONS	DATE	BY

**Kimley»Horn**  
© 2023 KIMLEY-HORN AND ASSOCIATES, INC.  
WWW.KIMLEY-HORN.COM PHONE: 919.677.2000 FAX: 919.677.2050  
421 FAYETTEVILLE STREET, SUITE 600, RALEIGH, NC 27601



KHA PROJECT	DATE	SCALE	DESIGNED BY	DRAWN BY	CHECKED BY
016485000	10/31/2023	AS SHOWN	JAA	JAA	COB

**SANITARY SEWER DETAILS**





**SCOOTER'S ROLESVILLE**  
PREPARED FOR  
**S&S JAVA ENTERPRISES**  
ROLESVILLE NC

SHEET NUMBER  
**C10.0**



SDP-23-07

Plotted By: Barnes, Michael. Sheet: SCOOTER'S ROLESVILLE Layout: C11.0 WATER DETAILS January 02, 2024 04:17:50pm K:\RAL\DEVELO\6485000-Scoters Rolesville\Plan\Sheet\C11.0 WATER DETAILS.dwg  
 This document, together with the concepts and designs presented herein, is an instrument of service, as an instrument of service, as intended only for the specific purpose and client for which it was prepared. Reuse of and improper reliance on this document without written authorization and adaptation by Kimley-Horn and Associates, Inc. shall be without liability to Kimley-Horn and Associates, Inc.

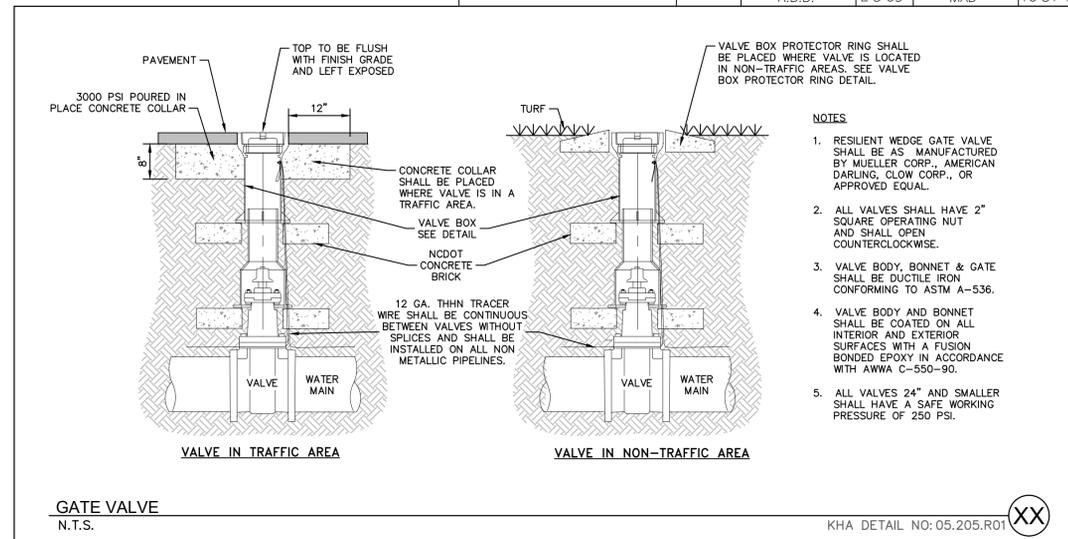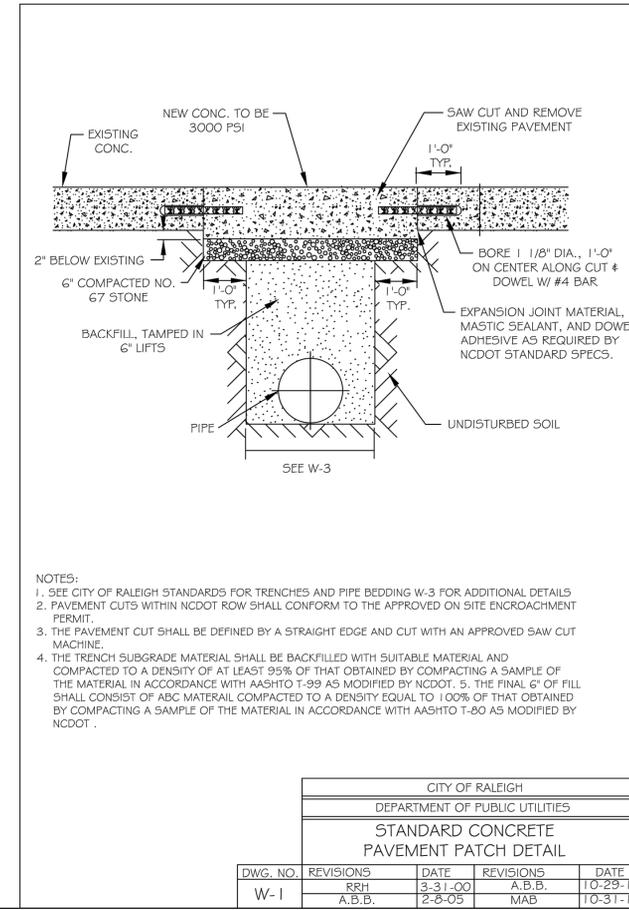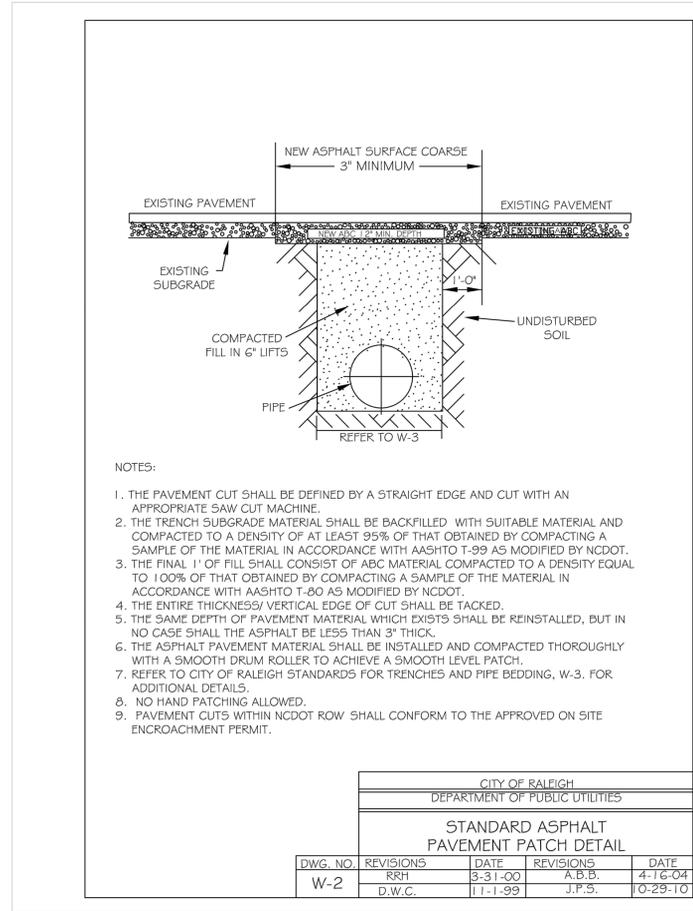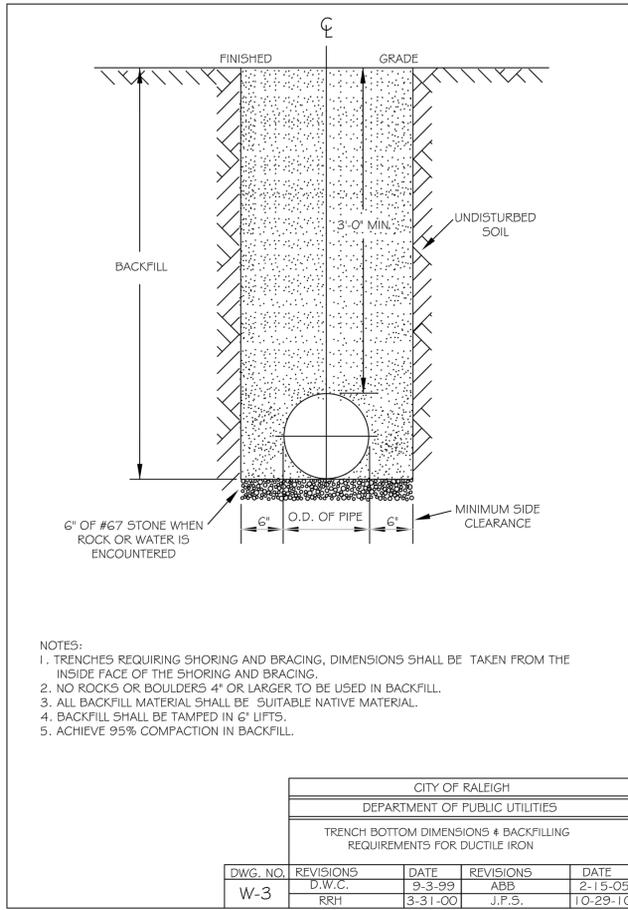

**SURVEY NOTE:**  
 EXISTING TOPOGRAPHICAL INFORMATION IS BASED ON A TOPOGRAPHIC SURVEY OBTAINED ON 02/23/2023 BY CMP PROFESSIONAL LAND SURVEYORS, 333 S. WHITE STREET, WAKE FOREST, NC, 27788. PHONE: (919) 556-3148. CONTRACTOR SHALL BE RESPONSIBLE FOR VERIFYING ALL EXISTING INFORMATION. DEPICTED OR NOT, PRIOR TO CONSTRUCTION AND REPORT POTENTIAL CONFLICTS TO OWNER AND ENGINEER.





SDP-23-07

KHA PROJECT 016485000		DATE 10/31/2023	SCALE AS SHOWN	DESIGNED BY JAA	DRAWN BY JAA	CHECKED BY COB
<b>WATER DETAILS</b>						
<b>SCOOTER'S ROLESVILLE</b>						
PREPARED FOR <b>S&amp;S JAVA ENTERPRISES</b>						
ROLESVILLE NC						
SHEET NUMBER <b>C11.0</b>						
						NO.
						1
						2
						3
						394



Plotted By: Barnes, Michael. Sheet Set: SCOOTER'S ROLESVILLE Layout.L1.0 LANDSCAPE PLAN January 02, 2024 04:21:16pm K:\RAL\_LDEV\016485000-Scoters Rolesville Planning\15\_CAD Files\PlanSheets\L1.0 LANDSCAPE PLAN.dwg  
 This document, together with the concepts and designs presented herein, is an instrument of service, as intended only for the specific purpose and client for which it was prepared. Reuse of and improper reliance on this document without written authorization and adaptation by Kimley-Horn and Associates, Inc. shall be without liability to Kimley-Horn and Associates, Inc.

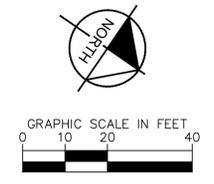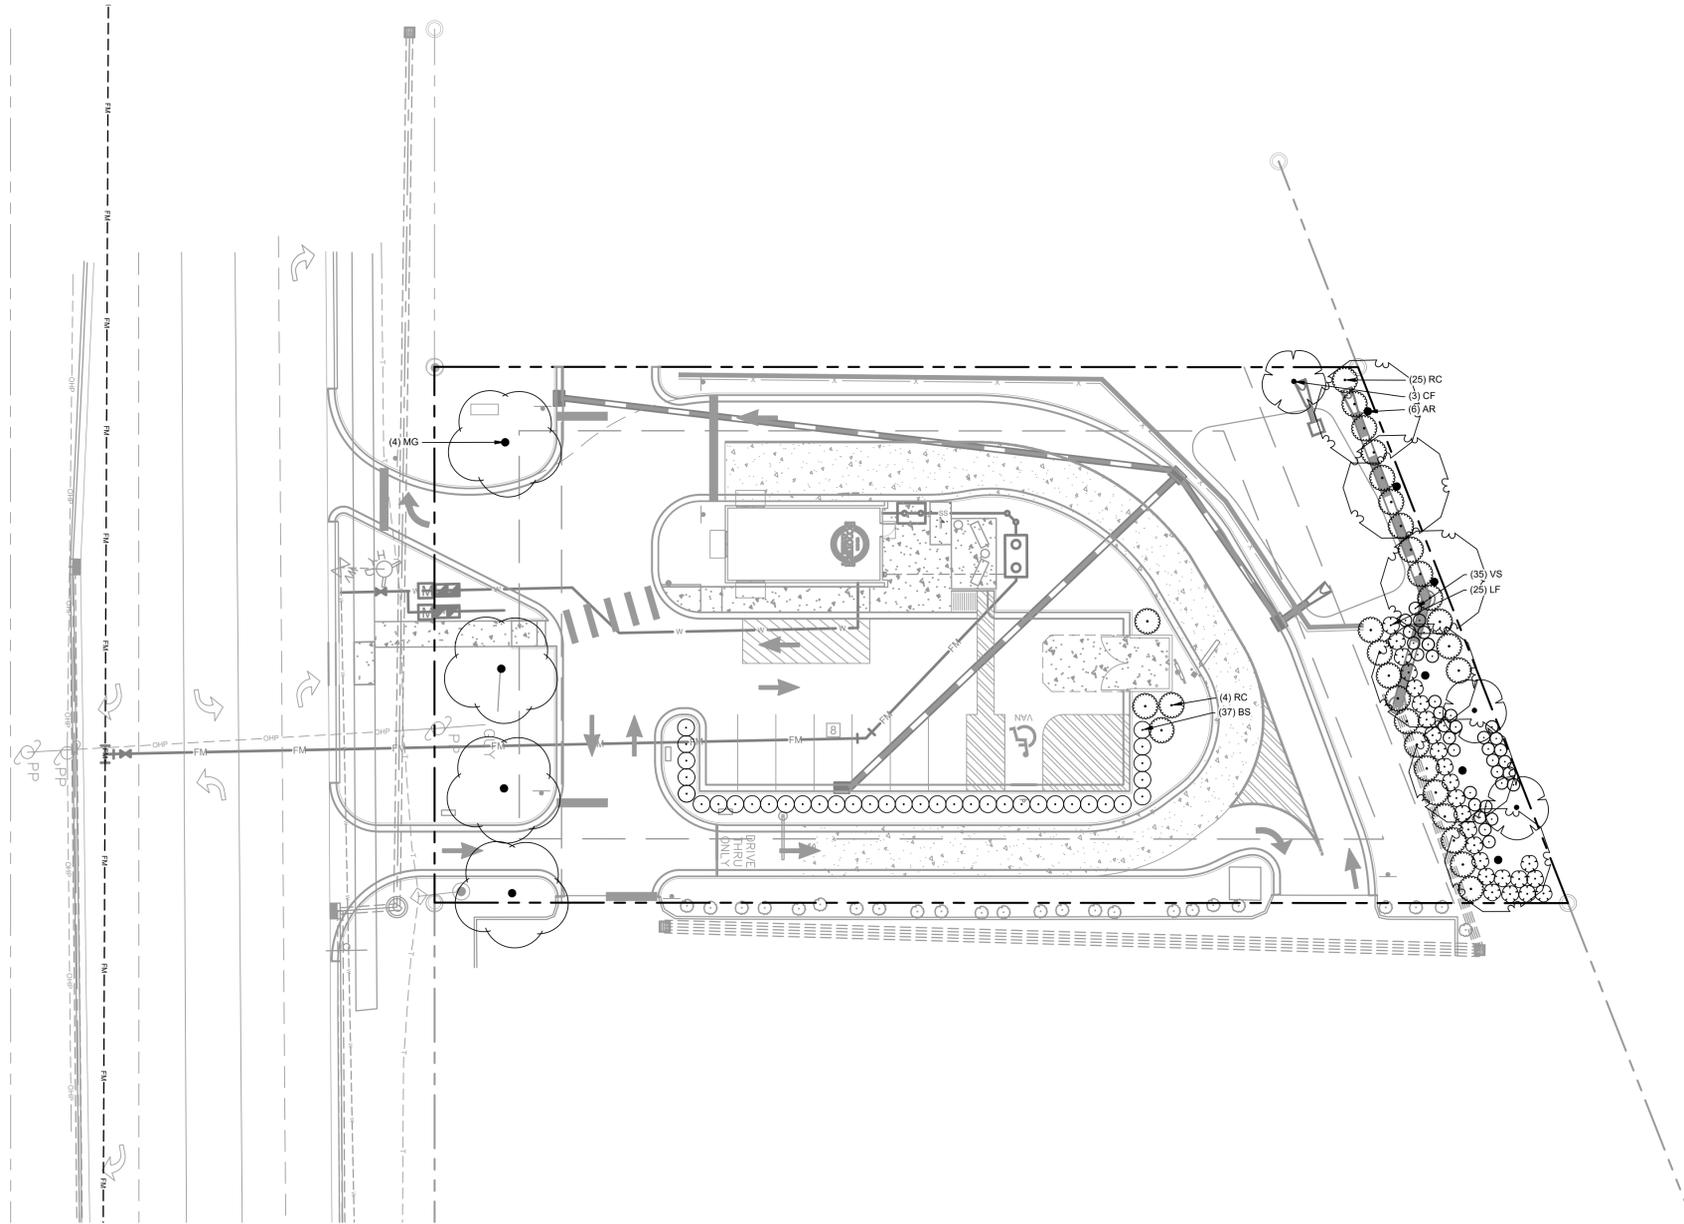

**LANDSCAPE NOTES:**

- ALL LANDSCAPED AREAS ARE TO RECEIVE A MINIMUM OF 3" OF TOPSOIL. DO NOT MOUND MULCH AGAINST ROOT FLARES.
- ALL PLANT MATERIAL SHALL BE HEALTHY, VIGOROUS, AND FREE OF PESTS AND DISEASE.
- ALL MATERIALS ARE SUBJECT TO THE APPROVAL OF THE LANDSCAPE ARCHITECT BEFORE, DURING, AND AFTER INSTALLATION.
- ALL TREES MUST BE GUYED OR STAKED AS SHOWN IN THE DETAILS.
- ALL PLANTING AREAS SHALL BE COMPLETELY MULCHED AS SPECIFIED.
- ANY DISTURBED GRASS AREA IS TO BE REPLANTED. ALL SLOPES 3:1 OR GREATER SHALL BE SEEDED WITH SLOPE MASTER NO-MOW MIX OR OWNER APPROVED EQUAL.
- PRIOR TO CONSTRUCTION, THE CONTRACTOR SHALL BE RESPONSIBLE FOR LOCATING ALL UNDERGROUND UTILITIES AND SHALL AVOID DAMAGE TO ALL UTILITIES DURING THE COURSE OF THE WORK. LOCATIONS OF EXISTING BURIED UTILITY LINES SHOWN ON THE PLANS ARE BASED UPON BEST AVAILABLE INFORMATION AND ARE TO BE CONSIDERED APPROXIMATE. IT SHALL BE THE RESPONSIBILITY OF THE CONTRACTOR 1) TO VERIFY THE LOCATIONS OF UTILITY LINES AND ADJACENT TO THE WORK AREA 2) TO PROTECT OF ALL UTILITY LINES DURING THE CONSTRUCTION PERIOD 3) TO REPAIR ANY AND ALL DAMAGE TO UTILITIES, STRUCTURES, SITE APPURTENANCES, ETC. WHICH OCCURS AS A RESULT OF THE CONSTRUCTION.
- THE CONTRACTOR SHALL BE RESPONSIBLE FOR VERIFYING ALL QUANTITIES SHOWN ON THESE PLANS BEFORE PRICING THE WORK.
- CONTRACTOR SHALL BE RESPONSIBLE FOR DELIVERY SCHEDULE AND PROTECTION BETWEEN DELIVERY AND PLANTING TO MAINTAIN HEALTHY PLANT CONDITIONS.
- THE CONTRACTOR SHALL BE RESPONSIBLE FOR FULLY MAINTAINING (INCLUDING BUT NOT LIMITED TO: WATERING, SPRAYING, MULCHING, FERTILIZING, ETC.) ALL OF THE PLANT MATERIALS AND LAWN FOR THE WARRANTY PERIOD.
- ANY PLANT MATERIAL WHICH IS DISEASED, DISTRESSED, DEAD, OR REJECTED (PRIOR TO SUBSTANTIAL COMPLETION) SHALL BE PROMPTLY REMOVED FROM THE SITE AND REPLACED WITH MATERIAL OF THE SAME SPECIES, QUANTITY, AND SIZE AND MEETING ALL PLANT LIST SPECIFICATIONS.
- THE CONTRACTOR SHALL COMPLETELY GUARANTEE ALL PLANT MATERIAL FOR WARRANTY PERIOD. THE CONTRACTOR SHALL PROMPTLY MAKE ALL REPLACEMENTS DURING THE NORMAL PLANTING SEASON.
- STANDARDS SET FORTH IN "AMERICAN STANDARD FOR NURSERY STOCK" REPRESENT GUIDELINE SPECIFICATIONS ONLY AND SHALL CONSTITUTE MINIMUM QUALITY REQUIREMENTS FOR PLANT MATERIAL.
- ALL LANDSCAPING SHALL BE INSTALLED ACCORDING TO SOUND NURSERY PRACTICES, AND SHALL BE STATE STANDARD OR BETTER.
- ALL INVASIVE / EXOTIC SPECIES AND PROHIBITED TREE SPECIES SHALL BE REMOVED FROM SITE, INCLUDING ROOT BALLS TO THE EXTENT POSSIBLE WITH NO DAMAGE TO ADJACENT EXISTING TREES.
- CONTRACTOR TO DESIGN BUILD SYSTEM AND VERIFY ALL PRODUCTS WITH LANDSCAPE ARCHITECT.
- TREE SUPPORT MATERIALS ARE TO BE REMOVED FROM EACH TREE ONCE IT IS "ESTABLISHED" (AS APPROVED BY THE LANDSCAPE ARCHITECT).
- CONTRACTOR SHALL BE RESPONSIBLE FOR ENSURING ALL UTILITIES ARE ADEQUATELY SCREENED WITH THE REQUIRED PLANTING MATERIAL AND VERIFY PLANT SPECIES WITH LANDSCAPE ARCHITECT.
- ALL PLANT SPECIFICATIONS IN THE PLANT SCHEDULE SHALL BE CONSIDERED THE MINIMUM ALLOWABLE SPECIFICATIONS. CONTRACTOR SHALL PROCURE PLANT MATERIALS AND UPSIZE AS NECESSARY TO MEET THE MOST STRINGENT SPECIFICATION.

**LANDSCAPE REQUIREMENTS**

PERIMETER BUFFER REQUIREMENTS 6.2.2.1		
Type 3 Perimeter Buffer: 136 lf	Required	Provided
Width	25 feet	Provided
Canopy Trees	4 canopy trees per 100 linear feet = 6 canopy trees	6 Canopy Trees
Understory Trees	2 understory trees per 100 linear feet = 3 understory trees	3 Understory Trees
Shrubs	60 shrubs per 100 linear feet = 82 shrubs	83 shrubs
STREET BUFFER 6.2.2.2		
Street Buffer: 126 lf	Required	Provided
Width	30 feet	Provided
Street Tree	1 per 40 linear feet = 4 street trees	4 Street Trees
PARKING LANDSCAPING 6.2.4.4		
Parking Perimeter	Required	Provided
Shrubs	Continuous row of shrubs within 5 feet of the parking lot edge	Provided

- NOTES:**
- ESTABLISH SOD IN ALL DISTURBED AREAS. SEE SPECIFICATIONS FOR MORE INFORMATION.
  - ALL AREAS WITH PROPOSED LANDSCAPE MATERIAL SHALL RECEIVE A MINIMUM THREE (3) INCHES OF SHREDDED HARDWOOD MULCH. SEE LANDSCAPE PLAN FOR MULCH BOUNDARY LINES. SEE LANDSCAPE DETAILS FOR TYPICAL MULCH AREA DIMENSIONS.

**SURVEY NOTE:**  
 EXISTING TOPOGRAPHICAL INFORMATION IS BASED ON A TOPOGRAPHIC SURVEY OBTAINED ON 02/23/2023 BY CMP PROFESSIONAL LAND SURVEYORS, 333 S. WHITE STREET, WAKE FOREST, NC, 27588. PHONE: (919) 556-3148. CONTRACTOR SHALL BE RESPONSIBLE FOR VERIFYING ALL EXISTING INFORMATION, DEPICTED OR NOT, PRIOR TO CONSTRUCTION AND REPORT POTENTIAL CONFLICTS TO OWNER AND ENGINEER.

SYMBOL	CODE	QTY	BOTANICAL NAME	COMMON NAME	CONT.	CAL	HEIGHT
<b>PERIMETER BUFFER TREES</b>							
	CF	3	CORNUS FLORIDA	FLOWERING DOGWOOD	5 GAL	2" CAL. MIN	8' MIN.
	MG	4	MAGNOLIA GRANDIFLORA	SOUTHERN MAGNOLIA	5 GAL	3" CAL.	10-12' MIN
<b>STREET BUFFER TREES</b>							
	AR	6	ACER RUBRUM	RED MAPLE	5 GAL	3" CAL.	10-12' MIN
<b>PERIMETER BUFFER SHRUBS</b>							
	LF	26	LEUCOTHOE FONTANESIANA	DROOPING LEUCOTHOE	5 GAL	24" HT.	
	RC	29	RHODODENDRON CATAWBIENSE	MOUNTAIN ROSEBAY	5 GAL	24" HT.	
	VS	35	ITEA VIRGINICA	VIRGINIA SWEETSPIRE	5 GAL	24" HT.	
<b>PARKING PERIMETER SHRUBS</b>							
	BS	37	BUXUS SEMPERVIRENS	COMMON BOXWOOD	5 GAL	24" HT.	

No.	REVISIONS	DATE	BY
1		01/02/2024	IMDE

**Kimley»Horn**

© 2023 KIMLEY-HORN AND ASSOCIATES, INC.  
 #F-0102 WWW.KIMLEY-HORN.COM PHONE: 919-677-2000 FAX: 919-677-2050  
 421 FAYETTEVILLE STREET, SUITE 800, RALEIGH, NC 27601

**NOT FOR CONSTRUCTION**


KHA PROJECT: 016485000  
 DATE: 10/31/2023  
 SCALE: AS SHOWN  
 DESIGNED BY: JAA  
 DRAWN BY: JAA  
 CHECKED BY: COB

**LANDSCAPE PLAN**


**SCOOTER'S ROLESVILLE**  
 PREPARED FOR  
**S&S JAVA ENTERPRISES**  
 ROLESVILLE, NC




Plotted By: Barnes, Michael. Sheet: SCOOTER'S ROLESVILLE L2.0 LANDSCAPE DETAILS January 02, 2024, 04:21:22pm. K:\RAL\_LDEV\016485000-Scooters Rolesville\Plan\Sheet\L2.0 LANDSCAPE DETAILS.dwg  
 This document, together with the concepts and designs presented herein, is an instrument of service, as intended only for the specific purpose and client for which it was prepared. Reuse of and improper reliance on this document without written authorization and adaptation by Kimley-Horn and Associates, Inc. shall be without liability to Kimley-Horn and Associates, Inc.

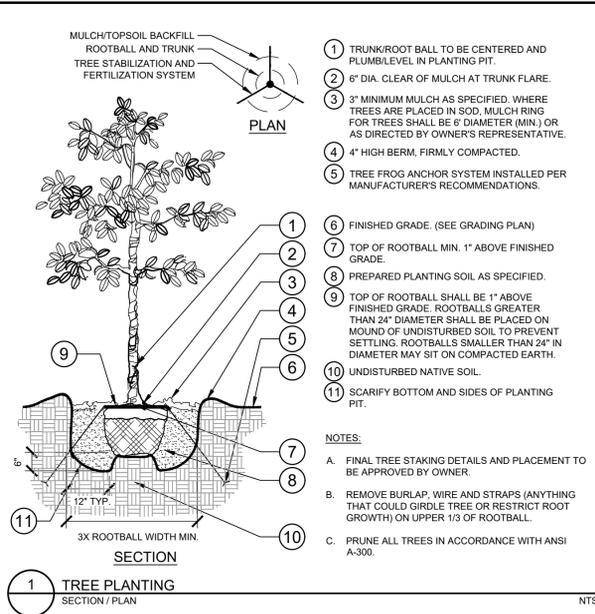


**1 TREE PLANTING**  
SECTION / PLAN NTS

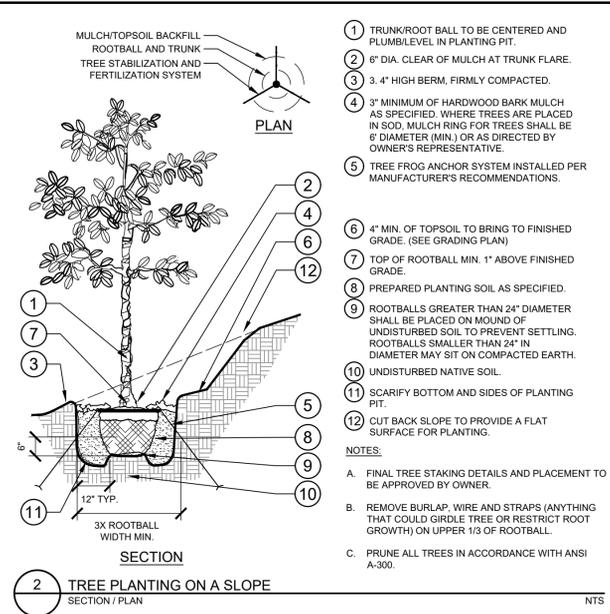


**2 TREE PLANTING ON A SLOPE**  
SECTION / PLAN NTS

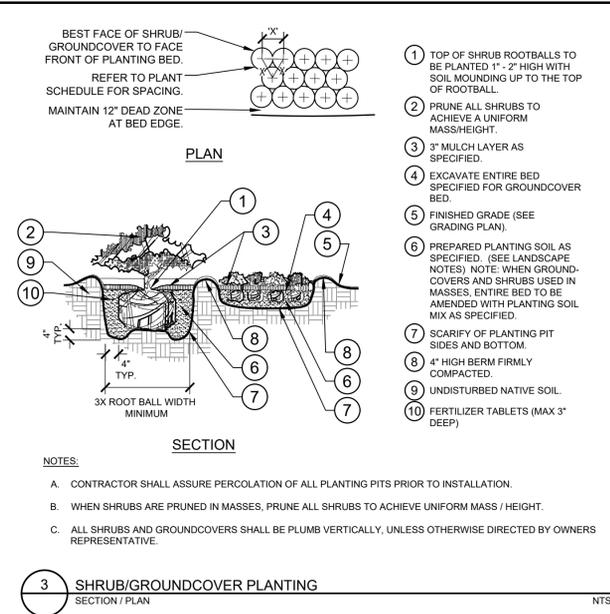


**3 SHRUB/GROUNDCOVER PLANTING**  
SECTION / PLAN NTS

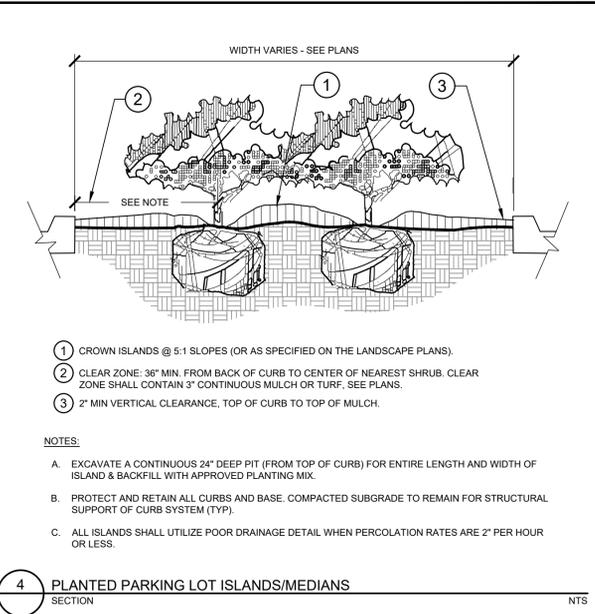


**4 PLANTED PARKING LOT ISLANDS/MEDIANS**  
SECTION NTS

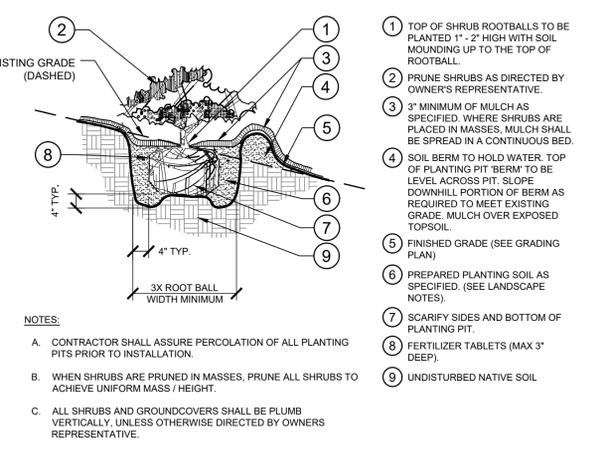


**5 SHRUB/GROUNDCOVER PLANTING ON A SLOPE**  
SECTION NTS

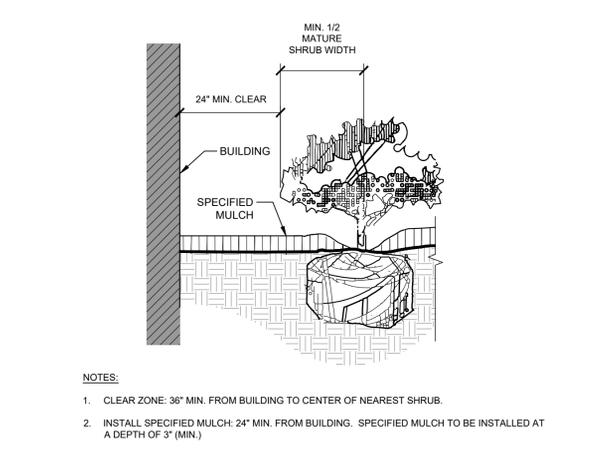


**6 PLANTINGS ADJACENT TO BUILDINGS**  
SECTION NTS

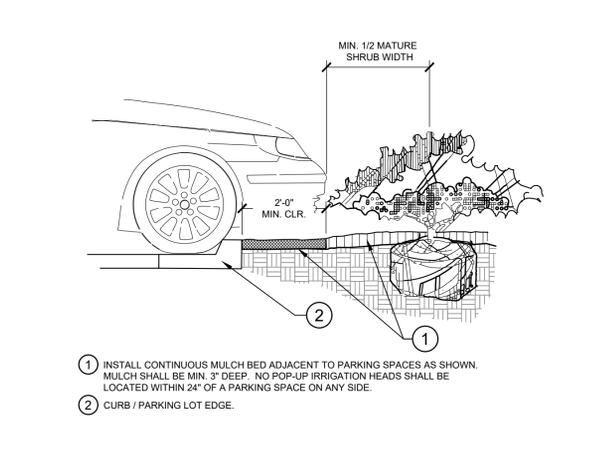


**7 PARKING SPACE/CURB PLANTING**  
SECTION NTS

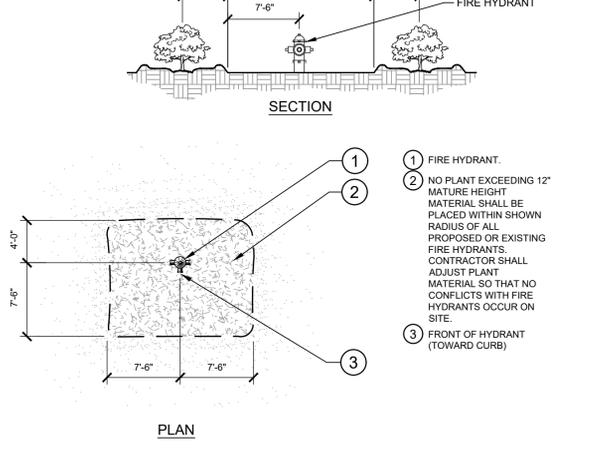


**8 SHRUB PLANTING AT FIRE HYDRANT**  
SECTION / PLAN NTS

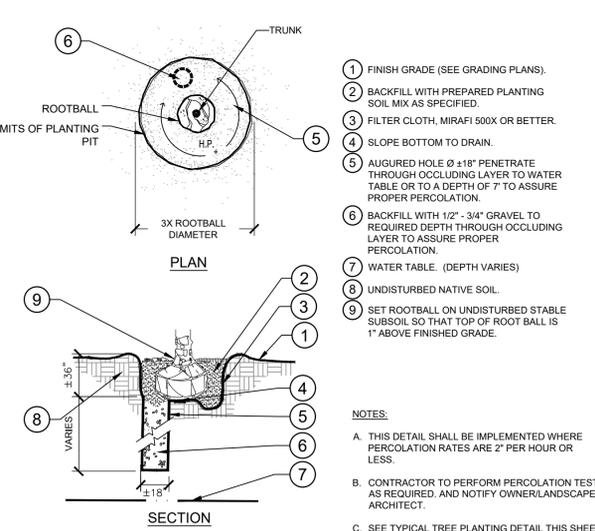

**9 POOR DRAINAGE CONDITION**  
SECTION / PLAN NTS

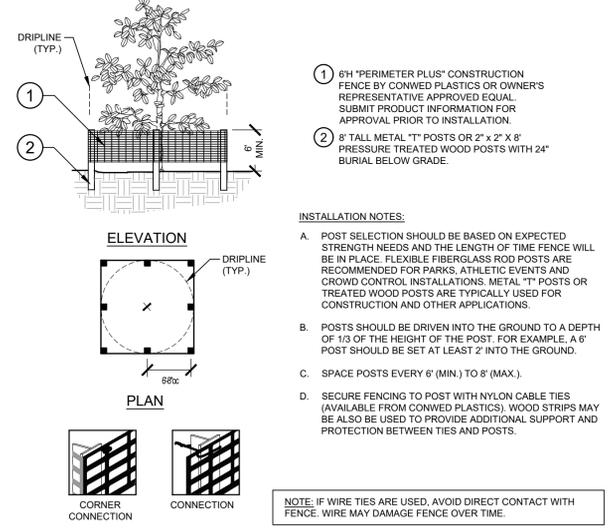


**10 TREE PROTECTION FENCING**  
ELEVATION / PLAN NTS

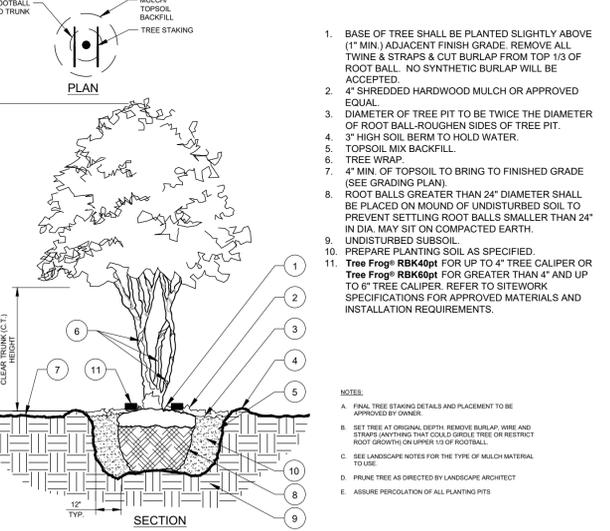

**11 MULTI-TRUNK TREE PLANTING**  
SECTION/PLAN NTS

No.	REVISIONS	DATE	BY
1			
2			
3			
4			
5			
6			
7			
8			
9			
10			
11			
12			
13			
14			
15			
16			
17			
18			
19			
20			
21			
22			
23			
24			
25			
26			
27			
28			
29			
30			
31			
32			
33			
34			
35			
36			
37			
38			
39			
40			
41			
42			
43			
44			
45			
46			
47			
48			
49			
50			

**Kimley >>> Horn**  
 © 2023 KIMLEY-HORN AND ASSOCIATES, INC.  
 #F-0102 WWW.KIMLEY-HORN.COM PHONE: 919.677.2000 FAX: 919.677.2050  
 421 FAYETTEVILLE STREET, SUITE 800, RALEIGH, NC 27601

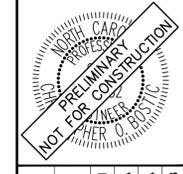

KHA PROJECT	016485000	DATE	10/31/2023
SCALE	AS SHOWN	DESIGNED BY	JAA
DRAWN BY	JAA	CHECKED BY	COB

**LANDSCAPE DETAILS**

**SCOOTER'S ROLESVILLE**  
 PREPARED FOR  
**S&S JAVA ENTERPRISES**  
 ROLESVILLE, NC



Plotted By: Barnes, Michael. Sheet Set: SCOOTER'S ROLESVILLE. Layout: L2.1. LANDSCAPE NOTES. January 02, 2024. 04:21:24pm. K:\RAL\_UIDE\016485000-Scoters Rolesville\Planning\P15\_CAD Files\Plant\Sheets\L2.0 LANDSCAPE DETAILS.dwg  
 This document, together with the concepts and designs presented herein, is an instrument of service, is intended only for the specific purpose and client for which it was prepared. Reuse of and improper reliance on this document without written authorization and adaptation by Kimley-Horn and Associates, Inc. shall be without liability to Kimley-Horn and Associates, Inc.

**GENERAL LANDSCAPE SPECIFICATIONS AND NOTES**

**A. SCOPE OF WORK**

1. THE WORK CONSISTS OF: FURNISHING ALL LABOR, MATERIALS, EQUIPMENT, TOOLS, TRANSPORTATION, AND ANY OTHER APPURTENANCES NECESSARY FOR THE COMPLETION OF THIS PROJECT AS SHOWN ON THE DRAWINGS, AS INCLUDED IN THE PLANT LIST, AND AS SPECIFIED HEREIN.
  2. WORK SHALL INCLUDE MAINTENANCE AND WATERING OF ALL CONTRACT PLANTING AREAS UNTIL CERTIFICATION OF ACCEPTANCE BY THE OWNER.
- B. PROTECTION OF EXISTING STRUCTURES**
1. ALL EXISTING BUILDINGS, WALKS, WALLS, PAVING, PIPING, OTHER SITE CONSTRUCTION ITEMS, AND PLANTING ALREADY COMPLETED OR ESTABLISHED AND DESIGNATED TO REMAIN SHALL BE PROTECTED FROM DAMAGE BY THE CONTRACTOR UNLESS OTHERWISE SPECIFIED. ALL DAMAGE RESULTING FROM NEGLIGENCE SHALL BE REPAIRED OR REPLACED TO THE SATISFACTION OF THE OWNER, AT NO COST TO THE OWNER.
  2. THE CONTRACTOR SHALL BE RESPONSIBLE FOR MAINTAINING ALL NECESSARY BMP DEVICES ACCORDING TO ALL REGULATORY AGENCY'S STANDARDS THROUGHOUT THE DURATION OF ALL CONSTRUCTION ACTIVITIES.
  3. THE CONTRACTOR SHALL SUBMIT A DETAILED PROJECT SPECIFIC WORK ZONE TRAFFIC CONTROL PLAN UNLESS THE WORK REQUIRES NOTHING MORE THAN A DIRECT APPLICATION OF DOT DESIGN STANDARDS, INDEX 600. IF A DIRECT APPLICATION OF INDEX 600 IS PROPOSED, THE CONTRACTOR SHALL SUBMIT IN WRITING A STATEMENT INDICATING THE STANDARD INDEX AND PAGE NUMBER NO LESS THAN 10 BUSINESS DAYS PRIOR TO START OF CONSTRUCTION. WHEN A DIRECT APPLICATION OF DOT STANDARD INDEX 600 IS NOT ACCEPTABLE A PROJECT SPECIFIC WORK ZONE TRAFFIC CONTROL PLAN SHALL BE PREPARED BY A PROFESSIONAL ENGINEER WHO HAS SUCCESSFULLY COMPLETED ADVANCED TRAINING IN MAINTENANCE OF TRAFFIC, AS DEFINED BY DOT FOR APPROVAL BY THE COUNTY ENGINEER'S REPRESENTATIVE.
  4. THE CONTRACTOR SHALL BE RESPONSIBLE FOR LOCATING ALL UTILITIES, WHETHER PUBLIC OR PRIVATE, PRIOR TO EXCAVATION. THE INFORMATION AND DATA SHOWN WITH RESPECT TO EXISTING UNDERGROUND FACILITIES AT OR CONTIGUOUS TO THE SITE IS APPROXIMATE AND BASED ON INFORMATION FURNISHED BY THE OWNER OF SUCH UNDERGROUND FACILITIES OR ON PHYSICAL APPURTENANCES OBSERVED IN THE FIELD. THE OWNER AND DESIGN PROFESSIONAL SHALL NOT BE RESPONSIBLE FOR THE ACCURACY AND COMPLETENESS OF ANY SUCH INFORMATION OR DATA. THE CONTRACTOR SHALL HAVE FULL RESPONSIBILITY FOR REVIEWING AND CHECKING ALL SUCH INFORMATION AND DATA. LOCATING ALL UNDERGROUND FACILITIES DURING CONSTRUCTION; THE SAFETY AND PROTECTION THEREOF; REPAIRING ANY DAMAGE THERE TO RESULTING FROM THE WORK. THE COST OF ALL WORK BE CONSIDERED AS HAVING BEEN INCLUDED IN THE CONTRACT PRICE. THE CONTRACTOR SHALL NOTIFY ANY AFFECTED UTILITY COMPANIES OR AGENCIES IN WRITING AT LEAST 48 HOURS PRIOR TO BEGINNING CONSTRUCTION.

**C. PROTECTION OF EXISTING PLANT MATERIALS**

1. THE CONTRACTOR SHALL BE RESPONSIBLE FOR ALL UNAUTHORIZED CUTTING OR DAMAGE TO TREES AND SHRUBS EXISTING OR OTHERWISE CAUSED BY CARELESS EQUIPMENT OPERATION, MATERIAL STOCKPILING, ETC.. THIS SHALL INCLUDE COMPACTION BY DRIVING OR PARKING INSIDE THE DRIP-LINE AND SPILLING OIL, GASOLINE, OR OTHER DELETERIOUS MATERIALS WITHIN THE DRIP-LINE. NO MATERIALS SHALL BE BURNED ON SITE. EXISTING TREES KILLED OR DAMAGED SO THAT THEY ARE MISSHAPEN AND/OR UNSIGHTLY SHALL BE REPLACED AT THE COST TO THE CONTRACTOR OF THREE HUNDRED DOLLARS (\$300) PER CALIPER INCH ON AN ESCALATING SCALE WHICH ADDS AN ADDITIONAL TWENTY (20) PERCENT PER INCH OVER FOUR (4) INCHES CALIPER AS FIXED AND AGREED LIQUIDATED DAMAGES. CALIPER SHALL BE MEASURED SIX (6) INCHES ABOVE GROUND LEVEL FOR TREES UP TO AND INCLUDING FOUR (4) INCHES IN CALIPER AND TWELVE (12) INCHES ABOVE GROUND LEVEL FOR TREES OVER FOUR (4) INCHES IN CALIPER.
2. SEE TREE MITIGATION PLAN AND NOTES, IF APPLICABLE.

**D. MATERIALS**

**1. GENERAL**

MATERIAL SAMPLES LISTED BELOW SHALL BE SUBMITTED FOR APPROVAL, ON SITE OR AS DETERMINED BY THE OWNER. UPON APPROVAL, DELIVERY OF MATERIALS MAY COMMENCE.

MATERIAL	SAMPLE SIZE
MULCH	ONE (1) CUBIC FOOT
TOPSOIL MIX	ONE (1) CUBIC FOOT
PLANTS	ONE (1) OF EACH VARIETY (OR TAGGED IN NURSERY)

**2. PLANT MATERIALS**

- a. PLANT SPECIES AND SIZE SHALL CONFORM TO THOSE INDICATED ON THE DRAWINGS. ALL PLANTS SHALL BE DETERMINED BY THE STATE DIVISION OF PLANT INDUSTRY. ALL PLANTS SHALL BE HEALTHY, VIGOROUS, SOUND, WELL-BRANCHED, AND FREE OF DISEASE AND INSECTS, INSECT EGGS AND LARVAE AND SHALL HAVE ADEQUATE ROOT SYSTEMS. TREES FOR PLANTING IN ROWS SHALL BE UNIFORM IN SIZE AND SHAPE. ALL MATERIALS SHALL BE SUBJECT TO APPROVAL BY THE OWNER. WHERE ANY REQUIREMENTS ARE OMITTED FROM THE PLANT LIST, THE PLANTS FURNISHED SHALL BE NORMAL FOR THE VARIETY. PLANTS SHALL BE PRUNED PRIOR TO DELIVERY ONLY WITH APPROVAL FROM OWNER OR OWNER'S REPRESENTATIVE. NO SUBSTITUTIONS SHALL BE MADE WITHOUT WRITTEN PERMISSION FROM THE OWNER'S REPRESENTATIVE.
- b. MEASUREMENTS: THE HEIGHT AND/OR WIDTH OF TREES SHALL BE MEASURED FROM THE GROUND OR ACROSS THE NORMAL SPREAD OF BRANCHES WITH THE PLANTS IN THEIR NORMAL POSITION. THIS MEASUREMENT SHALL NOT INCLUDE THE IMMEDIATE TERMINAL GROWTH. PLANTS LARGER IN SIZE THAN THOSE SPECIFIED IN THE PLANT LIST MAY BE USED IF APPROVED BY THE OWNER. IF THE USE OF LARGER PLANTS IS APPROVED, THE BALL OF EARTH OR SPREAD OF ROOTS SHALL BE INCREASED IN PROPORTION TO THE SIZE OF THE PLANT.
- c. INSPECTION: PLANTS SHALL BE SUBJECT TO INSPECTION AND APPROVAL AT THE PLACE OF GROWTH, OR UPON DELIVERY TO THE SITE, AS DETERMINED BY THE OWNER. FOR QUALITY, SIZE, AND VARIETY. SUCH APPROVAL SHALL NOT IMPAIR THE RIGHT OF INSPECTION AND REJECTION AT THE SITE DURING PROGRESS OF THE WORK OR AFTER COMPLETION FOR SIZE AND CONDITION OF ROOT BALLS OR ROOTS, LATENT DEFECTS OR INJURIES. REJECTED PLANTS SHALL BE REMOVED IMMEDIATELY FROM THE SITE. NOTICE REQUESTING INSPECTION SHALL BE SUBMITTED IN WRITING BY THE CONTRACTOR AT LEAST ONE (1) WEEK PRIOR TO ANTICIPATED DATE.

**E. SOIL MIXTURE (PLANTING MEDIUM, PLANTING MIX, TOPSOIL MIX)**

1. CONTRACTOR SHALL TEST EXISTING SOIL AND AMEND AS NECESSARY IN ACCORDANCE WITH THE GUIDELINES BELOW:
2. SOIL MIXTURE (PLANTING MEDIUM FOR PLANT PITS) SHALL CONSIST OF TWO PARTS OF TOPSOIL AND ONE PART SAND, AS DESCRIBED BELOW. CONTRACTOR TO SUBMIT SAMPLES AND PH TESTING RESULTS OF SOIL MIXTURE FOR OWNER'S REPRESENTATIVE APPROVAL PRIOR TO PLANT INSTALLATION OPERATIONS COMMENCE.
  - a. TOPSOIL FOR USE IN PREPARING SOIL MIXTURE FOR BACKFILLING PLANT PITS SHALL BE FERTILE, FRIABLE, AND OF A LOAMY CHARACTER. REASONABLY FREE OF SUBSOIL, CLAY LUMPS, BRUSH WEEDS AND OTHER LITTER; FREE OF ROOTS, STUMPS, STONES LARGER THAN 2" IN ANY DIRECTION, AND OTHER EXTRANEOUS OR TOXIC MATTER HARMFUL TO PLANT GROWTH. IT SHALL CONTAIN THREE (3) TO FIVE (5) PERCENT DECOMPOSED ORGANIC MATTER AND HAVE A PH BETWEEN 5.5 AND 7.0.
  - b. SAND SHALL BE COARSE, CLEAN, WELL-DRAINING, NATIVE SAND.
3. TREES SHALL BE PLANTED IN THE EXISTING NATIVE SOIL ON SITE, UNLESS DETERMINED TO BE UNSUITABLE - AT WHICH POINT THE CONTRACTOR SHALL CONTACT OWNER'S REPRESENTATIVE TO DISCUSS ALTERNATE RECOMMENDATION PRIOR TO PLANTING.

**F. WATER**

1. WATER NECESSARY FOR PLANTING AND MAINTENANCE SHALL BE OF SATISFACTORY QUALITY TO SUSTAIN ADEQUATE PLANT GROWTH AND SHALL NOT CONTAIN HARMFUL, NATURAL OR MAN-MADE ELEMENTS DETRIMENTAL TO PLANTS. WATER MEETING THE ABOVE STANDARD SHALL BE OBTAINED ON THE SITE FROM THE OWNER, IF AVAILABLE, AND THE CONTRACTOR SHALL BE RESPONSIBLE TO MAKE ARRANGEMENTS FOR ITS USE BY HIS TANKS, HOSES, SPRINKLERS, ETC.. IF SUCH WATER IS NOT AVAILABLE AT THE SITE, THE CONTRACTOR SHALL PROVIDE SATISFACTORY WATER FROM SOURCES OFF THE SITE AT NO ADDITIONAL COST TO THE OWNER.
- \* WATERING/IRRIGATION RESTRICTIONS MAY APPLY - REFER TO PROPERTY'S JURISDICTIONAL AUTHORITY.

**G. FERTILIZER**

CONTRACTOR SHALL PROVIDE FERTILIZER APPLICATION SCHEDULE TO OWNER, AS APPLICABLE TO SOIL TYPE, PLANT INSTALLATION TYPE, AND SITE'S PROPOSED USE. SUGGESTED FERTILIZER TYPES SHALL BE ORGANIC OR OTHERWISE NATURALLY-DERIVED.

\* FERTILIZER RESTRICTIONS MAY APPLY - REFER TO PROPERTY'S JURISDICTIONAL AUTHORITY.

**H. MULCH**

1. MULCH MATERIAL SHALL BE MOISTENED AT THE TIME OF APPLICATION TO PREVENT WIND DISPLACEMENT, AND APPLIED AT A DEPTH OF THREE (3) INCHES. CLEAR MULCH FROM EACH PLANTS CROWN (BASE), MULCH SHALL BE FLORIMULCH®, EUCALYPTUS MULCH, OR SIMILAR SUSTAINABLY HARVESTED MULCH UNLESS SPECIFIED OTHERWISE.
2. PROVIDE A THREE (3) INCH MINIMUM LAYER OF SPECIFIED MULCH OVER THE ENTIRE AREA OF EACH SHRUB BED, GROUND COVER, VINE BED, AND TREE PIT (Ø MINIMUM) PLANTED UNDER THIS CONTRACT.

**I. DIGGING AND HANDLING**

1. PROTECT ROOTS OR ROOT BALLS OF PLANTS AT ALL TIMES FROM SUN, DRYING WINDS, WATER AND FREEZING. AS NECESSARY UNTIL PLANTING. PLANT MATERIALS SHALL BE ADEQUATELY PACKED TO PREVENT DAMAGE DURING TRANSIT. TREES TRANSPORTED MORE THAN TEN (10) MILES OR WHICH ARE NOT PLANTED WITHIN THREE (3) DAYS OF DELIVERY TO THE SITE SHALL BE SPRAYED WITH AN ANTITRANSPIRANT PRODUCT ("WILT-PRUF" OR EQUAL) TO MINIMIZE TRANSPIRATIONAL WATER LOSS.
2. BALLED AND BURLAPPED (B&B), AND FIELD GROWN (FG) PLANTS SHALL BE DUG WITH FIRM, NATURAL BALLS OF SOIL OF SUFFICIENT SIZE TO ENCOMPASS THE FIBROUS AND FEEDING ROOTS OF THE PLANTS. NO PLANTS MOVED WITH A ROOT BALL SHALL BE PLANTED IF THE BALL IS

CRACKED OR BROKEN. PLANTS SHALL NOT BE HANDLED BY STEMS.

3. PLANTS MARKED "BR" IN THE PLANT LIST SHALL BE DUG WITH BARE ROOTS. CARE SHALL BE EXERCISED THAT THE ROOTS DO NOT DRY OUT DURING TRANSPORTATION AND PRIOR TO PLANTING.
4. PROTECTION OF PALMS: ONLY A MINIMUM OF FRONDS SHALL BE REMOVED FROM THE CROWN OF THE PALM TREES TO FACILITATE MOVING AND HANDLING. CLEAR TRUNK (CT) SHALL BE AS SPECIFIED AFTER THE MINIMUM OF FRONDS HAVE BEEN REMOVED. ALL PALMS SHALL BE BRACED PER PALM PLANTING DETAIL.
5. EXCAVATION OF TREE PITS SHALL BE PERFORMED USING EXTREME CARE TO AVOID DAMAGE TO SURFACE AND SUBSURFACE ELEMENTS SUCH AS UTILITIES OR HARDSCAPE ELEMENTS, FOOTERS AND PREPARED SUB-BASES.

**J. CONTAINER GROWN STOCK**

1. ALL CONTAINER GROWN MATERIAL SHALL BE HEALTHY, VIGOROUS, WELL-ROOTED PLANTS ESTABLISHED IN THE CONTAINER IN WHICH THEY ARE SOLD. THE PLANTS SHALL HAVE TOPS WHICH ARE OF GOOD QUALITY AND ARE IN A HEALTHY GROWING CONDITION.
2. AN ESTABLISHED CONTAINER GROWN PLANT SHALL BE TRANSPANTED INTO A CONTAINER AND GROWN IN THAT CONTAINER SUFFICIENTLY LONG ENOUGH FOR THE NEW FIBROUS ROOTS TO HAVE DEVELOPED SO THAT THE ROOT MASS WILL RETAIN ITS SHAPE AND HOLD TOGETHER WHEN REMOVED FROM THE CONTAINER. CONTAINER GROWN STOCK SHALL NOT BE HANDLED BY THEIR STEMS.
3. ROOT BOUND PLANTS ARE NOT ACCEPTABLE AND WILL BE REJECTED.
4. RPG= "ROOTS PLUS GROWER" CONTAINER PRODUCTS SHALL BE USED WHERE SPECIFIED.

**K. COLLECTED STOCK**

WHEN THE USE OF COLLECTED STOCK IS PERMITTED AS INDICATED BY THE OWNER OR OWNER'S REPRESENTATIVE, THE MINIMUM SIZES OF ROOTBALLS SHALL BE EQUAL TO THAT SPECIFIED FOR THE NEXT LARGER SIZE OF NURSERY GROWN STOCK OF THE SAME VARIETY.

**L. NATIVE STOCK**

PLANTS COLLECTED FROM WILD OR NATIVE STANDS SHALL BE CONSIDERED NURSERY GROWN WHEN THEY HAVE BEEN SUCCESSFULLY RE-ESTABLISHED IN A NURSERY ROW AND GROWN UNDER REGULAR NURSERY CULTURAL PRACTICES FOR A MINIMUM OF TWO (2) GROWING SEASONS AND HAVE ATTAINED ADEQUATE ROOT AND TOP GROWTH TO INDICATE FULL RECOVERY FROM TRANSPANTING INTO THE NURSERY ROW.

**M. MATERIALS LIST**

QUANTITIES NECESSARY TO COMPLETE THE WORK ON THE DRAWINGS SHALL BE FURNISHED BY THE CONTRACTOR. QUANTITY ESTIMATES HAVE BEEN MADE CAREFULLY, BUT THE LANDSCAPE ARCHITECT OR OWNER ASSUMES NO LIABILITY FOR OMISSIONS OR ERRORS. SHOULD A DISCREPANCY OCCUR BETWEEN THE PLANS AND THE PLANT LIST QUANTITY, THE OWNER'S REPRESENTATIVE SHALL BE NOTIFIED FOR CLARIFICATION PRIOR TO BIDDING OR INSTALLATION. ALL DIMENSIONS AND/OR SIZES SPECIFIED SHALL BE THE MINIMUM ACCEPTABLE SIZE.

**N. FINE GRADING**

1. FINE GRADING UNDER THIS CONTRACT SHALL CONSIST OF FINAL FINISHED GRADING OF LAWN AND PLANTING AREAS THAT HAVE BEEN ROUGH GRADED BY OTHERS. BERMING AS SHOWN ON THE DRAWINGS SHALL BE THE RESPONSIBILITY OF THE CONTRACTOR, UNLESS OTHERWISE NOTED.
2. THE CONTRACTOR SHALL FINE GRADE THE LAWN AND PLANTING AREAS TO BRING THE ROUGH GRADE UP TO FINAL FINISHED GRADE ALLOWING FOR THICKNESS OF SOD AND/OR MULCH DEPTH. CONTRACTOR SHALL FINE GRADE BY HAND AND/OR WITH ALL EQUIPMENT NECESSARY INCLUDING A GRADING TRACTOR WITH FRONT-END LOADER FOR TRANSPORTING SOIL WITHIN THE SITE.
3. ALL PLANTING AREAS SHALL BE GRADED AND MAINTAINED FOR POSITIVE DRAINAGE TO SURFACE/SUBSURFACE STORM DRAIN SYSTEMS. AREAS ADJACENT TO BUILDINGS SHALL SLOPE AWAY FROM THE BUILDINGS. REFER TO CIVIL ENGINEER'S PLANS FOR FINAL GRADES, IF APPLICABLE.

**O. PLANTING PROCEDURES**

1. CLEANING UP BEFORE COMMENCING WORK: THE CONTRACTOR SHALL CLEAN WORK AND SURROUNDING AREAS OF ALL RUBBISH OR OBJECTIONABLE MATTER DAILY. ALL MORTAR, CEMENT, AND TOXIC MATERIAL SHALL BE REMOVED FROM THE SURFACE OF ALL PLANT BEDS. THESE MATERIALS SHALL NOT BE MIXED WITH THE SOIL. SHOULD THE CONTRACTOR FIND SUCH SOIL CONDITIONS BENEATH THE SOIL WHICH WILL IN ANY WAY ADVERSELY AFFECT THE PLANT GROWTH, HE SHALL IMMEDIATELY CALL IT TO THE ATTENTION OF THE OWNER'S REPRESENTATIVE. FAILURE TO DO SO BEFORE PLANTING SHALL MAKE THE CORRECTIVE MEASURES THE RESPONSIBILITY OF THE CONTRACTOR.
2. VERIFY LOCATIONS OF ALL UTILITIES, CONDUITS, SUPPLY LINES AND CABLES, INCLUDING BUT NOT LIMITED TO: ELECTRIC, GAS (LINES AND TANKS), WATER, SANITARY SEWER, STORMWATER SYSTEMS, CABLE, AND TELEPHONE. PROPERLY MAINTAIN AND PROTECT EXISTING UTILITIES. CALL STATE OFFICIAL (811) TO LOCATE UTILITIES AT LEAST 48 HOURS PRIOR TO CONSTRUCTION.
3. SUBGRADE EXCAVATION: CONTRACTOR IS RESPONSIBLE TO REMOVE ALL EXISTING AND IMPORTED LIMEROCK AND LIMEROCK SUB-BASE FROM ALL LANDSCAPE PLANTING AREAS TO A MINIMUM DEPTH OF 36" OR TO NATIVE SOIL. CONTRACTOR IS RESPONSIBLE TO BACKFILL THESE PLANTING AREAS TO ROUGH FINISHED GRADE WITH CLEAN TOPSOIL FROM AN ON-SITE SOURCE OR AN IMPORTED SOURCE. IF LIMEROCK OR OTHER ADVERSE CONDITIONS OCCUR IN PLANTED AREAS AFTER 36" DEEP EXCAVATION BY THE CONTRACTOR, AND POSITIVE DRAINAGE CAN NOT BE ACHIEVED, CONTRACTOR SHALL UTILIZE POOR DRAINAGE CONDITION PLANTING DETAIL.
4. FURNISH NURSERY'S CERTIFICATE OF COMPLIANCE WITH ALL REQUIREMENTS AS SPECIFIED HEREIN. INSPECT AND SELECT PLANT MATERIALS BEFORE PLANTS ARE DUG AT NURSERY OR GROWING SITE.
5. COMPLY WITH APPLICABLE FEDERAL, STATE, COUNTY, AND LOCAL REGULATIONS GOVERNING LANDSCAPE MATERIALS AND WORK. CONFORM TO ACCEPTED HORTICULTURAL PRACTICES AS USED IN THE TRADE. UPON ARRIVAL AT THE SITE, PLANTS SHALL BE THOROUGHLY WATERED AND PROPERLY MAINTAINED UNTIL PLANTED. PLANTS STORED ON SITE SHALL NOT REMAIN UNPLANTED OR APPROPRIATELY HEALED IN FOR A PERIOD EXCEEDING TWENTY-FOUR (24) HOURS. AT ALL TIMES WORKMANLIKE METHODS CUSTOMARY IN GOOD HORTICULTURAL PRACTICES SHALL BE EXERCISED.
6. THE WORK SHALL BE COORDINATED WITH OTHER TRADES TO PREVENT CONFLICTS. COORDINATE PLANTING WITH IRRIGATION WORK TO ASSURE AVAILABILITY OF WATER AND PROPER LOCATION OF IRRIGATION APPURTENANCES AND PLANTS.
7. ALL PLANTING PITS SHALL BE EXCAVATED TO SIZE AND DEPTH IN ACCORDANCE WITH THE USA STANDARD FOR NURSERY STOCK 260.1, UNLESS SHOWN OTHERWISE ON THE DRAWINGS, AND BACK FILLED WITH THE PREPARED PLANTING SOIL MIXTURE AS SPECIFIED IN SECTION E. TEST ALL TREE PITS WITH WATER BEFORE PLANTING TO ASSURE PROPER DRAINAGE PERCOLATION IS AVAILABLE. NO ALLOWANCE WILL BE MADE FOR LOST PLANTS DUE TO IMPROPER DRAINAGE. IF POOR DRAINAGE EXISTS, UTILIZE "POOR DRAINAGE CONDITION" PLANTING DETAIL. TREES SHALL BE SET PLUMB AND HELD IN POSITION UNTIL THE PLANTING MIXTURE HAS BEEN FLUSHED INTO PLACE WITH A SLOW, FULL HOSE STREAM. ALL PLANTING SHALL BE PERFORMED BY PERSONNEL FAMILIAR WITH PLANTING PROCEDURES AND UNDER THE SUPERVISION OF A QUALIFIED LANDSCAPE FOREMAN. "JETTING IN" SHALL BE ASSURED TO ELIMINATE AIR POCKETS AROUND THE ROOTS. "JET STICK" OR EQUAL IS RECOMMENDED.
8. TAKE ALL NECESSARY PRECAUTIONS TO AVOID DAMAGE TO BUILDINGS AND BUILDING STRUCTURES WHILE INSTALLING TREES.
9. SOIL MIXTURE SHALL BE AS SPECIFIED IN SECTION E OF THESE SPECIFICATIONS.
10. TREES AND SHRUBS SHALL BE SET STRAIGHT AT AN ELEVATION THAT, AFTER SETTLEMENT, THE PLANT GROWN WILL STAND ONE (1) TO TWO (2) INCHES ABOVE GRADE. EACH PLANT SHALL BE SET IN THE CENTER OF THE PIT. PLANTING SOIL MIXTURE SHALL BE BACK FILLED, THOROUGHLY TAMPED AROUND THE BALL, AND SETTLED BY WATER (AFTER TAMPING).
11. AMEND PINE AND OAK PLANT PITS WITH ECTOMYCORRHIZAL SOIL APPLICATION PER MANUFACTURER'S RECOMMENDATION. ALL OTHER PLANT PITS SHALL BE AMENDED WITH ENDOMYCORRHIZAL SOIL APPLICATION PER MANUFACTURER'S RECOMMENDATION. PROVIDE PRODUCT INFORMATION SUBMITTAL PRIOR TO INOCULATION.
12. FILL HOLE WITH SOIL MIXTURE, MAKING CERTAIN ALL SOIL IS SATURATED. TO DO THIS, FILL HOLE WITH WATER AND ALLOW TO SOAK MINIMUM TWENTY (20) MINUTES, STIRRING IF NECESSARY TO GET SOIL THOROUGHLY WET. PACK LIGHTLY WITH FEET. ADD MORE WET SOIL MIXTURE. DO NOT COVER TOP OF BALL WITH SOIL MIXTURE. ALL BURLAP, ROPE, WIRES, BASKETS, ETC., SHALL BE REMOVED FROM THE SIDES AND TOPS OF BALLS, BUT NO BURLAP SHALL BE PULLED FROM UNDERNEATH.
13. TREES SHALL BE PRUNED, AT THE DIRECTION OF THE OWNER OR OWNER'S REPRESENTATIVE, TO PRESERVE THE NATURAL CHARACTER OF THE PLANT. ALL SOFT WOOD OR SUCKER GROWTH AND ALL BROKEN OR BADLY DAMAGED BRANCHES SHALL BE REMOVED WITH A CLEAN CUT. ALL PRUNING TO BE PERFORMED BY CERTIFIED ARBORIST, IN ACCORDANCE WITH ANSI A-300.
14. SHRUBS AND GROUND COVER PLANTS SHALL BE EVENLY SPACED IN ACCORDANCE WITH THE DRAWINGS AND AS INDICATED ON THE PLANT LIST. MATERIALS INSTALLED SHALL MEET MINIMUM SPECIMEN REQUIREMENTS OR QUANTITIES SHOWN ON PLANS, WHICHEVER IS GREATER. CULTIVATE ALL PLANTING AREAS TO A MINIMUM DEPTH OF 6". REMOVE AND DISPOSE ALL DEBRIS. MIX TOP 4" OF THE PLANTING SOIL MIXTURE AS SPECIFIED IN SECTION E. THOROUGHLY WATER ALL PLANTS AFTER INSTALLATION.
15. TREE GUYING AND BRACING SHALL BE INSTALLED BY THE CONTRACTOR IN ACCORDANCE WITH THE PLANS TO INSURE STABILITY AND MAINTAIN TREES IN AN UPRIGHT POSITION. IF THE CONTRACTOR AND OWNER DECIDE TO WAIVE THE TREE GUYING AND BRACING, THE OWNER SHALL NOTIFY THE PROJECT LANDSCAPE ARCHITECT IN WRITING AND AGREE TO INDEMNIFY AND HOLD HARMLESS THE PROJECT LANDSCAPE ARCHITECT IN THE EVENT UNSUPPORTED TREES PLANTED UNDER THIS CONTRACT FALL AND DAMAGE PERSON OR PROPERTY.
16. ALL PLANT BEDS SHALL BE KEPT FREE OF NOXIOUS WEEDS UNTIL FINAL ACCEPTANCE OF WORK. IF DIRECTED BY THE OWNER, "ROUND-UP" SHALL BE APPLIED FOR WEED CONTROL BY QUALIFIED PERSONNEL TO ALL PLANTING AREAS IN SPOT APPLICATIONS PER MANUFACTURER'S PRECAUTIONS AND SPECIFICATIONS. PRIOR TO FINAL INSPECTION, TREAT ALL PLANTING BEDS WITH AN APPROVED PRE-EMERGENT HERBICIDE AT AN APPLICATION RATE RECOMMENDED BY THE MANUFACTURER. (AS ALLOWED BY JURISDICTIONAL AUTHORITY)

**P. LAWN SODDING**

1. THE WORK CONSISTS OF LAWN BED PREPARATION, SOIL PREPARATION, AND SODDING COMPLETE, IN STRICT ACCORDANCE WITH THE SPECIFICATIONS AND THE APPLICABLE DRAWINGS TO PRODUCE A TURF GRASS LAWN ACCEPTABLE TO THE OWNER.

2. ALL AREAS THAT ARE TO BE SODDED SHALL BE CLEARED OF ANY ROUGH GRASS, WEEDS, AND DEBRIS BY MEANS OF A SOD CUTTER TO A DEPTH OF THREE (3) INCHES, AND THE GROUND BROUGHT TO AN EVEN GRADE. THE ENTIRE SURFACE SHALL BE ROLLED WITH A ROLLER WEIGHING NOT MORE THAN ONE HUNDRED (100) POUNDS PER FOOT OF WIDTH. DURING THE ROLLING, ALL DEPRESSIONS CAUSED BY SETTLEMENT SHALL BE FILLED WITH ADDITIONAL SOIL, AND THE SURFACE SHALL BE REGRADED AND ROLLED UNTIL PRESENTING A SMOOTH AND EVEN FINISH TO THE REQUIRED GRADE.
3. PREPARE LOOSE BED FOUR (4) INCHES DEEP. HAND RAKE UNTIL ALL BUMPS AND DEPRESSIONS ARE REMOVED. WET PREPARED AREA THOROUGHLY.
4. SODDING
  - a. THE CONTRACTOR SHALL SOD ALL AREAS THAT ARE NOT PAVED OR PLANTED AS DESIGNATED ON THE DRAWINGS WITHIN THE CONTRACT LIMITS, UNLESS SPECIFICALLY NOTED OTHERWISE.
  - b. THE SOD SHALL BE CERTIFIED TO MEET STATE REQUIREMENTS & SPECIFICATIONS, ABSOLUTELY TRUE TO VARIETAL TYPE, AND FREE FROM WEEDS, FUNGUS, INSECTS AND DISEASE OF ANY KIND.
  - c. SOD PANELS SHALL BE LAID TIGHTLY TOGETHER SO AS TO MAKE A SOLID SODDED LAWN AREA. SOD SHALL BE LAID UNIFORMLY AGAINST THE EDGES OF ALL CURBS AND OTHER HARDSCAPE ELEMENTS, PAVED AND PLANTED AREAS. ADJACENT TO BUILDINGS, A 24 INCH STONE MULCH STRIP SHALL BE PROVIDED. IMMEDIATELY FOLLOWING SOD LAYING, THE LAWN AREAS SHALL BE ROLLED WITH A LAWN ROLLER CUSTOMARILY USED FOR SUCH PURPOSES, AND THEN THOROUGHLY IRRIGATED. IF, IN THE OPINION OF THE OWNER, TOP-DRESSING IS NECESSARY AFTER ROLLING TO FILL THE VOIDS BETWEEN THE SOD PANELS AND TO EVEN OUT INCONSISTENCIES IN THE SOD, CLEAN SAND, AS APPROVED BY THE OWNER'S REPRESENTATIVE, SHALL BE UNIFORMLY SPREAD OVER THE ENTIRE SURFACE OF THE SOD AND THOROUGHLY WATERED IN. FERTILIZER INSTALLED SOD AS ALLOWED BY PROPERTY'S JURISDICTIONAL AUTHORITY.

5. DURING DELIVERY, PRIOR TO, AND DURING THE PLANTING OF THE LAWN AREAS, THE SOD PANELS SHALL AT ALL TIMES BE PROTECTED FROM EXCESSIVE DRYING AND UNNECESSARY EXPOSURE OF THE ROOTS TO THE SUN. ALL SOD SHALL BE STACKED SO AS NOT TO BE DAMAGED BY SWEATING OR EXCESSIVE HEAT AND MOISTURE.
6. LAWN MAINTENANCE
  - a. WITHIN THE CONTRACT LIMITS, THE CONTRACTOR SHALL PRODUCE A DENSE, WELL ESTABLISHED LAWN. THE CONTRACTOR SHALL BE RESPONSIBLE FOR THE REPAIR AND RE-SODDING OF ALL ERODED, SUNKEN OR BARE SPOTS (LARGER THAN 12'X12") UNTIL CERTIFICATION OF ACCEPTANCE BY THE OWNER'S REPRESENTATIVE. REPAIRED SODDING SHALL BE ACCOMPLISHED AS IN THE ORIGINAL WORK (INCLUDING REGRADEING IF NECESSARY).
  - b. CONTRACTOR RESPONSIBLE FOR ESTABLISHING AND MAINTAINING SOD/LAWN UNTIL ACCEPTANCE BY THE OWNER'S REPRESENTATIVE. PRIOR TO AND UPON ACCEPTANCE, CONTRACTOR TO PROVIDE WATERING/IRRIGATION SCHEDULE TO OWNER. OBSERVE ALL APPLICABLE WATERING RESTRICTIONS AS SET FORTH BY THE PROPERTY'S JURISDICTIONAL AUTHORITY.

UPON COMPLETION OF ALL PLANTING WORK AND BEFORE FINAL ACCEPTANCE, THE CONTRACTOR SHALL REMOVE ALL MATERIAL, EQUIPMENT, AND DEBRIS RESULTING FROM HIS WORK. ALL PAVED AREAS SHALL BE CLEANED AND THE SITE LEFT IN A NEAT AND ACCEPTABLE CONDITION AS APPROVED BY THE OWNER'S REPRESENTATIVE.

**R. PLANT MATERIAL MAINTENANCE**

ALL PLANTS AND PLANTING INCLUDED UNDER THIS CONTRACT SHALL BE MAINTAINED BY WATERING, CULTIVATING, SPRAYING, AND ALL OTHER OPERATIONS (SUCH AS RE-STAKING OR REPAIRING GUY SUPPORTS) NECESSARY TO INSURE A HEALTHY PLANT CONDITION BY THE CONTRACTOR UNTIL CERTIFICATION OF ACCEPTANCE BY THE OWNER'S REPRESENTATIVE.

**S. FINAL INSPECTION AND ACCEPTANCE OF WORK**

FINAL INSPECTION AT THE END OF THE WARRANTY PERIOD SHALL BE ON PLANTING, CONSTRUCTION AND ALL OTHER INCIDENTAL WORK PERTAINING TO THIS CONTRACT. ANY REPLACEMENT AT THIS TIME SHALL BE SUBJECT TO THE SAME ONE (1) YEAR WARRANTY (OR AS SPECIFIED BY THE LANDSCAPE ARCHITECT OR OWNER IN WRITING) BEGINNING WITH THE TIME OF REPLACEMENT AND ENDING WITH THE SAME INSPECTION AND ACCEPTANCE HEREIN DESCRIBED.

**T. WARRANTY**

1. THE LIFE AND SATISFACTORY CONDITION OF ALL PLANT MATERIAL INSTALLED (INCLUDING SOD) BY THE LANDSCAPE CONTRACTOR SHALL BE WARRANTED BY THE CONTRACTOR FOR A MINIMUM OF ONE (1) CALENDAR YEAR COMMENCING AT THE TIME OF CERTIFICATION OF ACCEPTANCE BY THE OWNER'S REPRESENTATIVE.
2. ANY PLANT NOT FOUND IN A HEALTHY GROWING CONDITION AT THE END OF THE WARRANTY PERIOD SHALL BE REMOVED FROM THE SITE AND REPLACED AS SOON AS WEATHER CONDITIONS PERMIT. ALL REPLACEMENTS SHALL BE PLANTS OF THE SAME KIND AND SIZE AS SPECIFIED IN THE PLANT LIST. THEY SHALL BE FURNISHED PLANTED AND MULCHED AS SPECIFIED AT NO ADDITIONAL COST TO THE OWNER.
3. IN THE EVENT THE OWNER DOES NOT CONTRACT WITH THE CONTRACTOR FOR LANDSCAPE AND IRRIGATION MAINTENANCE, THE CONTRACTOR SHOULD VISIT THE PROJECT SITE PERIODICALLY DURING THE ONE (1) YEAR WARRANTY PERIOD TO EVALUATE MAINTENANCE PROCEDURES BEING PERFORMED BY THE OWNER. CONTRACTOR SHALL NOTIFY THE OWNER IN WRITING OF MAINTENANCE PROCEDURES OR CONDITIONS WHICH THREATEN VIGOROUS AND HEALTHY PLANT GROWTH. SITE VISITS SHALL BE CONDUCTED A MINIMUM OF ONCE PER MONTH FOR A PERIOD OF TWELVE (12) MONTHS FROM THE DATE OF ACCEPTANCE.

7	6	5	4	3	2	1	No.	
							TOWN COMMENTS	REVISIONS
							01/02/2024	IMDB
							DATE	BY

  
 © 2023 KIMLEY-HORN AND ASSOCIATES, INC.  
 #F-0102 WWW.KIMLEY-HORN.COM PHONE: 919-677-2000 FAX: 919-677-2050  
 421 FAYETTEVILLE STREET, SUITE 600, RALEIGH, NC 27601



KHA PROJECT	DATE	SCALE	DESIGNED BY	DRAWN BY	CHECKED BY
016485000	10/31/2023	AS SHOWN	JAA	JAA	COB

**LANDSCAPE NOTES**

**SCOOTER'S ROLESVILLE**  
 PREPARED FOR  
**S&S JAVA ENTERPRISES**  
 ROLESVILLE, NC




Know what's below.  
Call before you dig.

**1 TYPICAL LANDSCAPE SPECIFICATIONS**

Schedule								
Symbol	Label	QTY	Manufacturer	Catalog	Number Lamps	Lamp Output	LLF	Input Power
	A	7	RAB LIGHTING INC.	SLIM12Y/D10	1	2006	0.75	15
	B	130		NF/SP-PROW-120-24V-3000K	1	180	0.8	2.89861

Statistics						
Description	Symbol	Avg	Max	Min	Max/Min	Avg/Min
Calc Zone #1	+	0.3 fc	15.3 fc	0.0 fc	N/A	N/A

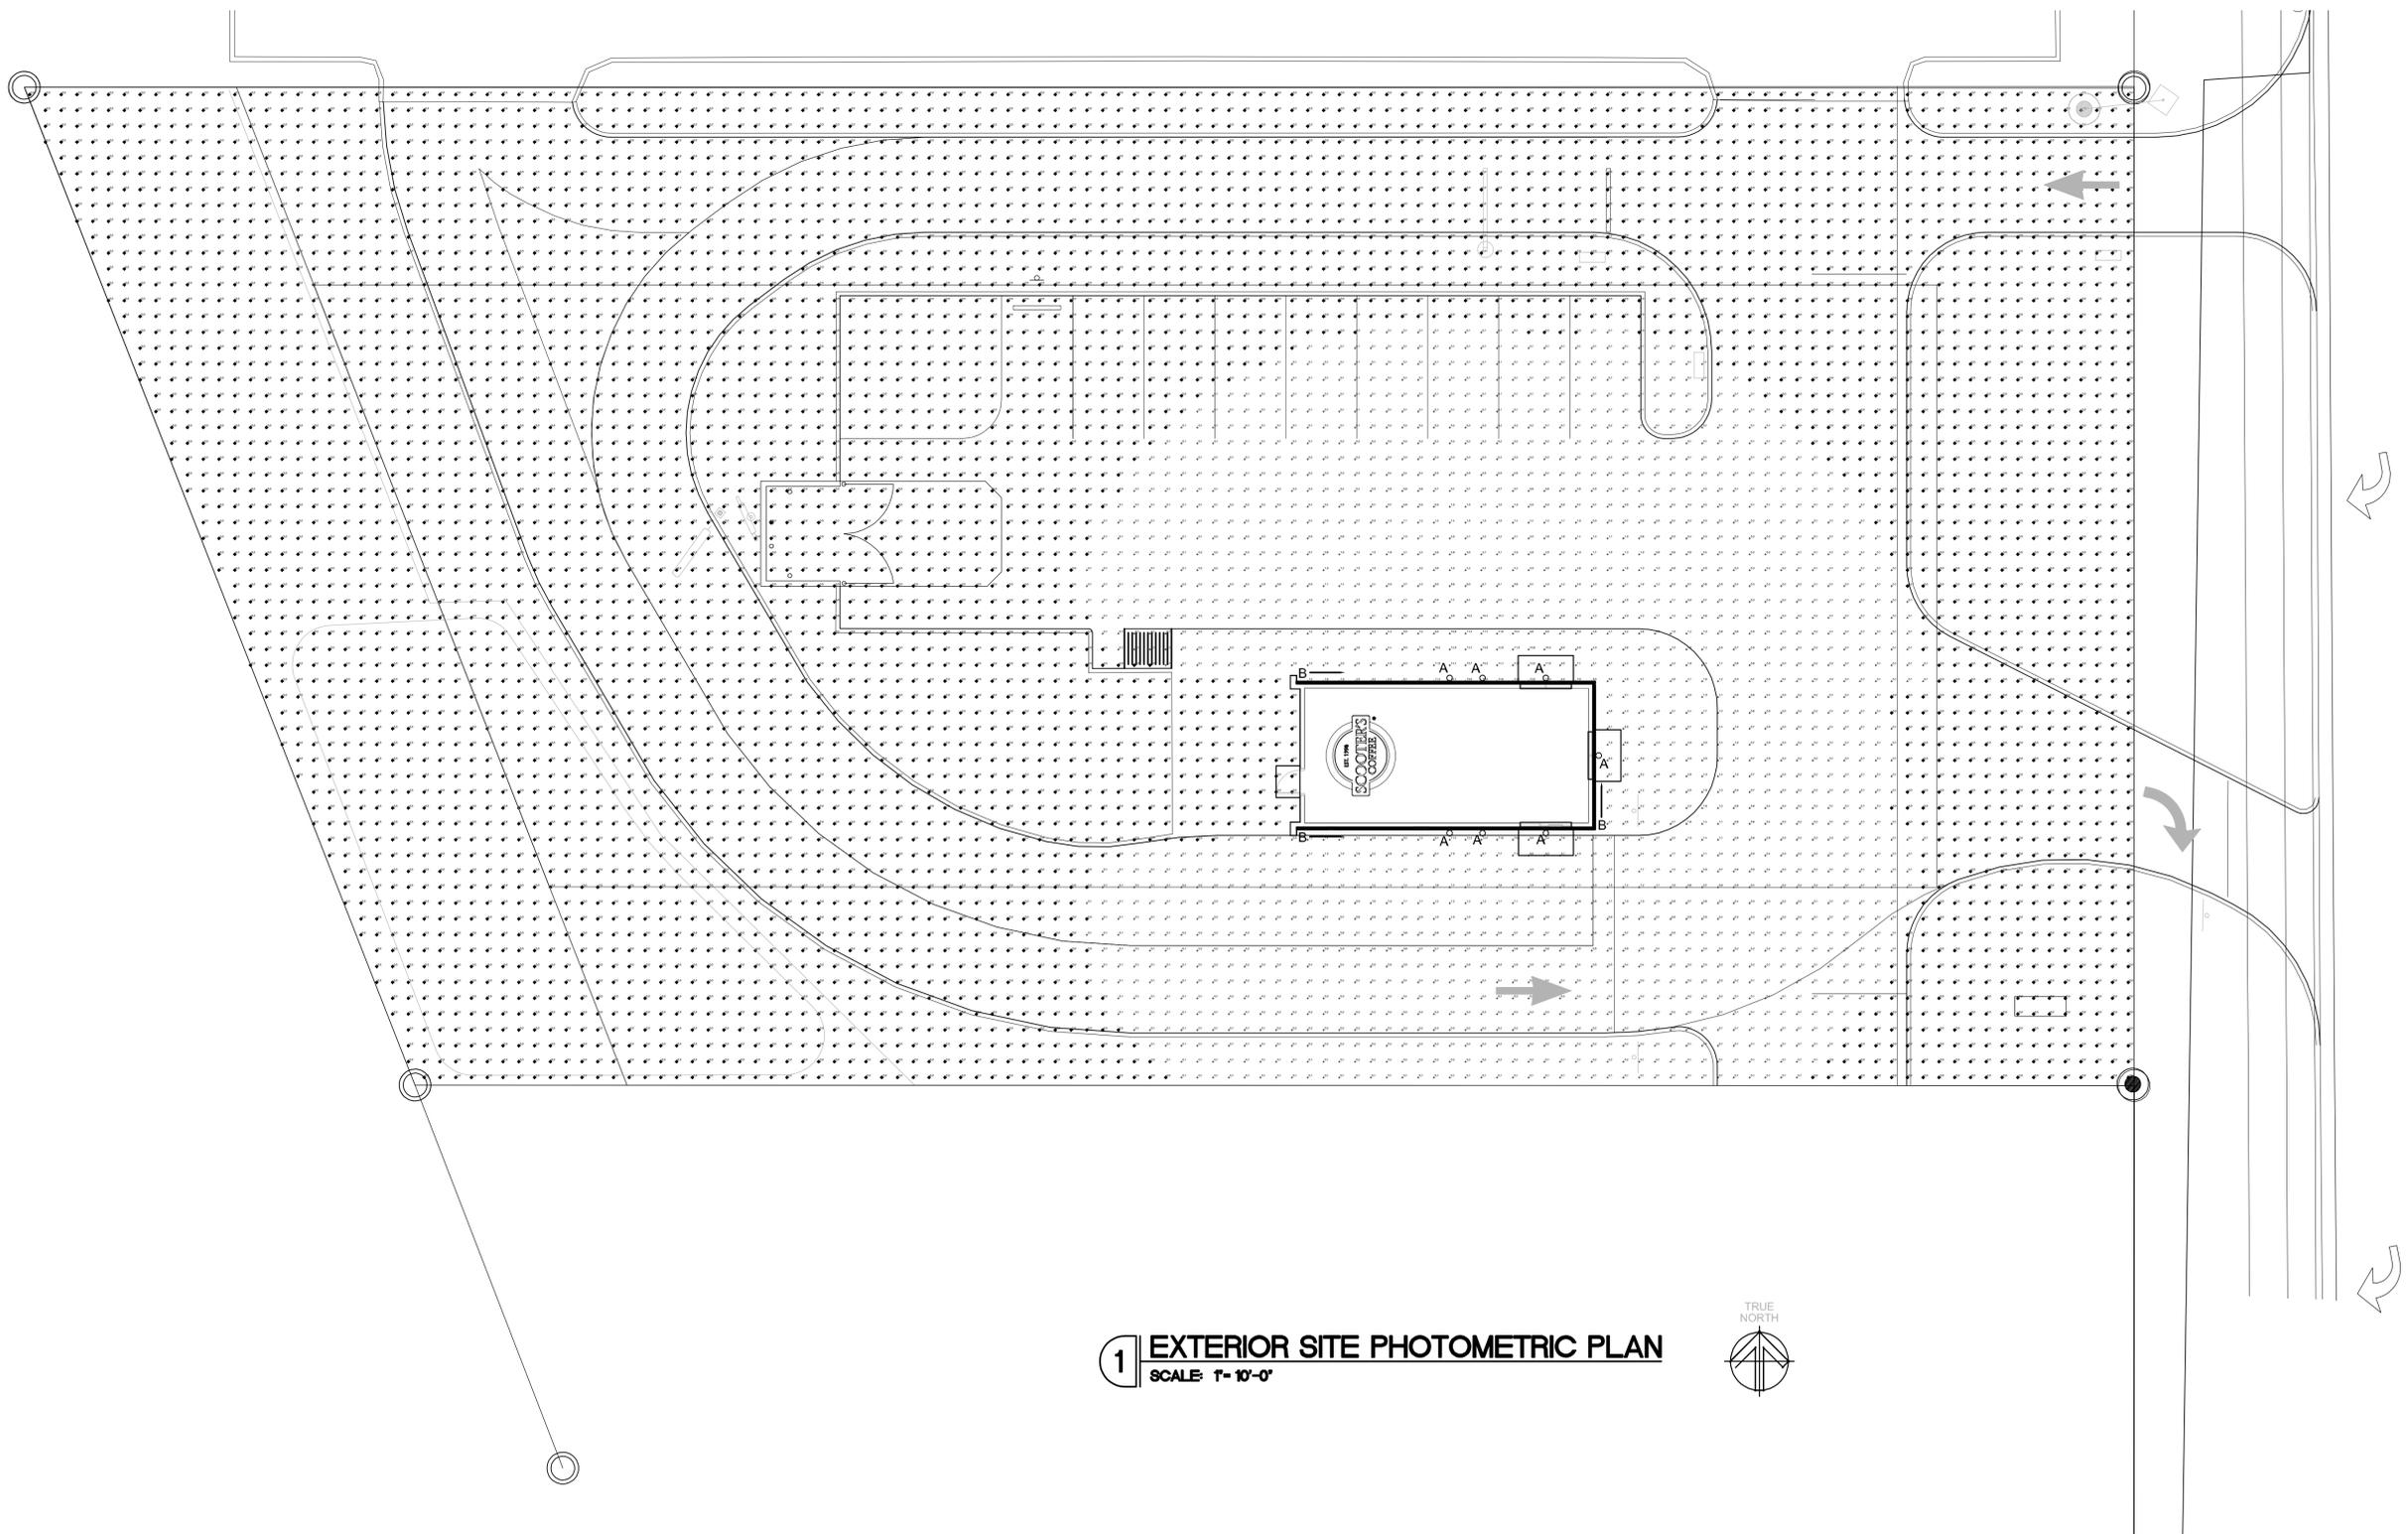

**1 EXTERIOR SITE PHOTOMETRIC PLAN**  
SCALE: 1" = 10'-0"



**U.S. HWY 401  
(A.K.A. SOUTH MAIN STREET)**



**ROBERT L. QUEATHEM**  
ENGINEER  
1950 CRAIG ROAD, SUITE 900  
PH. (914) 415-2400 FAX (314) 415-2300  
ST. LOUIS, MO 63146  
www.arvcv.com



REV	DATE	DESCRIPTION	BY
1	12/15/23	EXTERIOR REVISION	ANG
2			
3			
4			
5			
6			
7			
8			
9			

TITLE:  
**EXTERIOR SITE  
PHOTOMETRIC  
PLAN**

PROJECT ADDRESS:  
306 S. MAIN ST.  
ROLESVILLE, NC 27571  
FRANCHISEE & STORE NUMBER:  
SCOOTER'S COFFEE #562  
P&S JAVA ENTERPRISES, INC.

KIOSK PROTOTYPE:  
4.1 PROTOTYPE  
MAY 2022  
ISSUE DATE:  
08/14/2023  
PROJECT NO.  
230522  
DRAWN BY:  
JDK  
CHECKED BY:  
SAH


SHEET NO.  
**E3.1**

SCOOTER'S COFFEE LIGHTING SCHEDULE										
FIXTURE INFORMATION					LAMP(S) ELECTRICAL CHARACTERISTICS					NOTES
TAG	QTY.	MANUFACTURE	DESCRIPTION	MODEL NUMBER	MOUNTING	QTY.	VOLTS	WATTS	LAMP BASE TYPE	
A	7	RAB	EXTERIOR WALL SCONCE	SLIM12Y	WALL	1	120	12	INTEGRATED	0-10V (120V/277V)
A2	0	RAB	EXTERIOR WALL SCONCE	SLIM18Y	WALL	1	120	18	INTEGRATED	0-10V (120V/277V)
B	131'	NOVA FLEX	LED STRIP LIGHT	NF/SP-PROW-120-24V-3000K	SURFACE	1	120	2.9W/FT	INTEGRATED	0-10V
EM1	4	BEST LIGHTING	MR-16 SEMI-RECESSED THERMOPLASTIC EMERGENCY UNIT.	RMR-16-LED	WALL	1	120	(2) 3.3W	MR-16	N/A
EM2	1	BEST LIGHTING	LED DECORATIVE OUTDOOR DIE-CAST AC/EMERGENCY UNIT.	DBEL-ACEM-HL-B-SDI-CW-PC	WALL	1	120	3	INTEGRATED	N/A
T1	8	AEL	LED 2x4	CB2435MM	RECESSED	1	120/277	40	INTEGRATED	N/A
EX1	1	BEST LIGHTING	LED EXIT SIGN/EMERGENCY UNIT COMBO	LEDXTEU-2-R-W	CEILING	1	120/277	3	INTEGRATED	N/A
FL	2	KITCHLER	GROUND MOUNT LED FLAG POLE LIGHT FIXTURE	NSP 10 TO 15 - 16209	STANCHION GROUND	1	120/277	3	INTEGRATED	N/A
PL	SEE NOTE	LITHONIA LIGHTING	LED POLE LIGHT FIXTURE w/FULL CUT-OFF SHIELDING	KAD LED 60C 700 40K R4 MVOLT	POLE	1	120/277	-	INTEGRATED	N/A

NOTES:  
1. CONTRACTOR TO CONSULT WITH LIGHTING MANUFACTURE TO PROVIDE U.L. LABELING TO REFLECT ACTUAL LAMP WATTAGE USED, NOT MAXIMUM FIXTURE WATTAGE  
2. RECESSED FIXTURES INSTALLED IN AN INSULATED CEILING SHALL BE I.C. RATED  
3. "EXIST" DENOTES EXISTING TO REMAIN

LIGHTING CONTROL DEVICE SCHEDULE							
CALLOUT	SYMBOL	MANUFACTURE MODEL NUMBER	UNOBSTRUCTED RATED COVERAGE	MOUNTING	WATTAGE VOLTAGE	TIME DELAY	DESCRIPTION
OCCUPANCY SENSOR SWITCH	Ⓢ	nLIGHT WSX-PDT	---	WALL	LINE	---	LINE VOLTAGE SWITCH DUAL TECHNOLOGY SENSOR
DIMMER SWITCH	Ⓢ	ACUITY CONTROLS sPDMRD	---	WALL	LINE	---	LINE VOLTAGE PUSH BUTTON SWITCH POD ON/OFF
TOGGLE SWITCH	Ⓢ	HUBBEL #1221	---	WALL	LOW	---	

NOTES:  
1. SENSOR REQUIRES POWER PACK (INSTALL IN ACCESSIBLE LOCATION)  
2. SWIVEL MOUNTING BRACKET INCLUDED  
3. ELECTRICAL CONTRACTOR SHALL COORDINATE COMPATIBILITY OF LIGHT FIXTURES AND LIGHTING CONTROL DEVICES/ SYSTEM WITH CONTROL SYSTEM SUPPLIER PRIOR TO ORDERING/ROUGH-IN  
4. VERIFY POWER REQUIREMENT FOR CEILING SENSOR. IF IT REQUIRES CONTINUOUS HOT, PULL UNDIMMED WIRE FROM AHEAD OF DIMMER SWITCH TO CEILING SENSOR FOR SENSOR OPERATING, AND RUN DIMMED LINE THROUGH SENSOR FOR ON/OFF CONTROL. CONFIRM WITH VENDOR PRIOR TO ORDERING SENSOR TO ENSURE COMPATIBILITY.

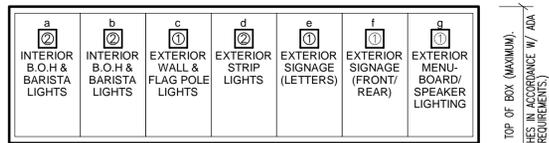

LEGEND  
1. SINGLE POLE SWITCH.  
2. SINGLE POLE DIMMER SWITCH


**JURISDICTIONAL NOTE**

PER LDO SECTION 6.6.G.10, FULL CUT-OFF LIGHTING SHALL BE PROVIDED IN LOADING AREAS.

BUILDING FACADE AND ACCENT LIGHTING SHALL BE SELECTED, LOCATED, AIMED AND SHIELDED SO THAT LIGHT IS DIRECTED ONLY ONTO THE BUILDING FACADE AND SPILLOVER LIGHT IS NEGLIGIBLE.

LIGHTING DESIGN SHALL BE COORDINATED WITH THE LANDSCAPE PLAN TO ENSURE THAT VEGETATION GROWTH WILL NOT SUBSTANTIALLY IMPAIR THE INTENDED ILLUMINATION.

**3 SWITCH BANK DETAIL**  
SCALE: N.T.S.

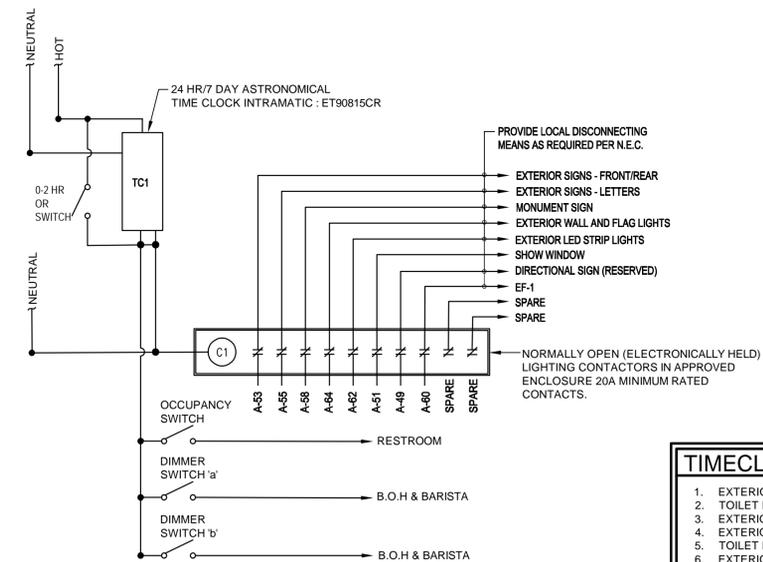


**2 TIME CLOCK DIAGRAM**  
SCALE: NOT TO SCALE

**TIMECLOCK SEQUENCE OF OPERATION**

- EXTERIOR SIGN SHALL TURN ON AT 4:30AM.
- TOILET EXHAUST SHALL TURN ON AT 5AM.
- EXTERIOR SIGN SHALL TURN OFF 30- MINUTES AFTER SUNRISE.
- EXTERIOR SIGNAGE SHALL TURN ON 30-MINUTES BEFORE SUNSET.
- TOILET EXHAUST SHALL SHUT OFF AT 10PM.
- EXTERIOR SIGNAGE SHALL TURN OFF AT 10:30PM.

ALL TIMES ARE ADJUSTABLE.

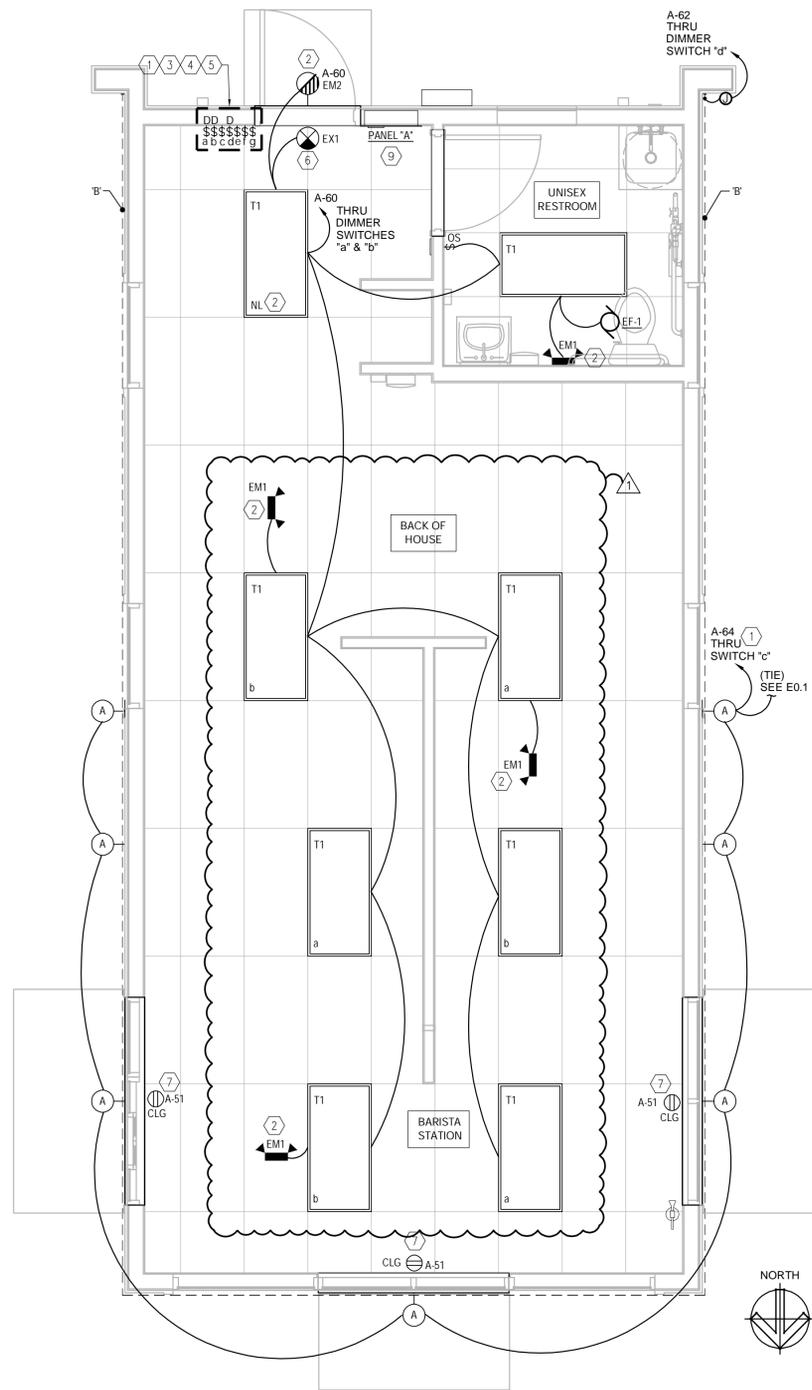

**1 ELECTRICAL LIGHTING PLAN**  
SCALE: 3/8" = 1'-0"

**LIGHTING GENERAL NOTES**

- ELECTRICAL CONTRACTOR SHALL FIELD VERIFY ALL EXISTING CONDITIONS PRIOR TO BASE BID. IN CASE OF ANY DISCREPANCIES WITH EXISTING FIELD CONDITIONS, ELECTRICAL CONTRACTOR SHALL VERIFY THE EXACT DIFFERENCE FOR POSSIBLE REVISIONS TO THIS DOCUMENT.
- INSTALL RECESSED LUMINAIRES USING ACCESSORIES AND FIRE STOPPING MATERIALS TO MEET REGULATORY REQUIREMENTS FOR FIRE RATING.
- COORDINATE ALL EXTERIOR BUILDING MOUNTED LIGHT FIXTURES WITH ARCHITECTURAL BUILDING ELEVATIONS FOR HEIGHTS AND LOCATIONS.
- PROVIDE EXIT SIGNS FOR ALL EXISTS DESIGNATED BY THE CODE STUDY PLAN. REFER TO ARCHITECTURAL CODE PLANS FOR LOCATIONS AND REQUIREMENTS.
- CONDUIT AND WIRING SHOWN FOR REFERENCE ONLY. IT IS THE RESPONSIBILITY OF THE ELECTRICAL CONTRACTOR TO PROVIDE THE NUMBER OF CONDUCTOR REQUIRED FOR HOT-LEGS, NEUTRAL AND GROUNDING AT EACH DEVICE FOR PROPER BRANCH CIRCUITING SHOWN FOR EACH AREA OR ROOM.
- ALL EMERGENCY/EXIT FIXTURES AND ARE TO BE PROVIDED WITH MINIMUM 90 MIN EMERGENCY BATTERY BACK-UP. BYPASS ENERGY MANAGEMENT SYSTEM WHERE REQUIRED.
- WHEN REQUIRED, IT IS THE OWNER'S RESPONSIBILITY TO CONTRACT WITH A COMMISSIONING AUTHORITY TO COMPLY WITH LOCAL CODES.
- THIS DRAWING IS TO BE READ IN CONJUNCTION WITH ALL OTHER DISCIPLINES DRAWINGS. ANY DISCREPANCIES ARE TO BE BROUGHT TO THE ATTENTION OF THE ARCHITECTS AND ENGINEERS PRIOR TO FINAL BID CLOSING.

**GENERAL NOTE**

PROVIDE STRUCTURE ENGINEERING LETTER OF APPROVAL FOR SEISMIC INSTALLATION SUPPORT PRIOR TO INSTALLATION AND AT COMMISSIONING STAGE. ALL EQUIPMENT SEISMIC SUPPORT AND INSTALLATION METHOD MUST BE SUBMITTED TO STRUCTURE ENGINEERING APPROVAL PRIOR TO INSTALLATION.

**LIGHTING CONTROL EXEMPTION**

PER IECC 505.2.2 ADDITIONAL CONTROLS...  
505.2.2.1 LIGHT REDUCTION CONTROLS EXEMPTION #5: SPACES THAT USE LESS THAN 0.6 WATTS PER SQUARE FOOT (6.5 W/m<sup>2</sup>).  
(8 FIXTURES X 40-WATTS) 320 / TOTAL SQ/FT 680 = 0.47 Watts per square foot

**AUTOMATIC CONTROL EXEMPTION**

PER IECC 505.2.2 ADDITIONAL CONTROLS...  
505.2.2.2 AUTOMATIC LIGHTING SHUTOFF BUILDINGS LARGER THAN 5,000 SQUARE FEET (465m<sup>2</sup>) SHALL BE EQUIPPED WITH AN AUTOMATIC LIGHTING CONTROL DEVICE.  
TOTAL BUILDING 680 SQFT = < 5,000 SQFT = NO AUTO CONTROL REQUIRED

**LIGHTING PLAN KEYED NOTES**

- PROVIDE DIMMING SWITCH ON WALL FOR EXTERIOR LED STRIP LIGHTING. COORDINATE EXACT LOCATION WITH OWNER/ ARCHITECT PRIOR TO INSTALLATION.
- NITE-LITE/EMERGENCY EGRESS LIGHT SHALL BE CIRCUITED TO UNSWITCHED LEG OF LOCAL LIGHT CIRCUIT.
- PROVIDE LIGHT SWITCH ON WALL FOR EXTERIOR WALL/ SITE FIXTURE. COORDINATE EXACT LOCATION WITH OWNER/ ARCHITECT PRIOR TO INSTALLATION.
- PROVIDE SWITCH ON WALL FOR ILLUMINATED MONUMENT SIGN AND BUILDING SIGNS COORDINATE EXACT LOCATION WITH OWNER/ ARCHITECT PRIOR TO INSTALLATION.
- PROVIDE SWITCH ON WALL FOR ILLUMINATED MENU BOARD/ SPEAKER. COORDINATE EXACT LOCATION WITH OWNER/ ARCHITECT PRIOR TO INSTALLATION. VERIFY EXACT POWER REQUIREMENTS PRIOR TO ROUGH-IN.
- EXIT LIGHT SHALL BE CIRCUITED TO UNSWITCHED LEG OF LOCAL LIGHT CIRCUIT. PROVIDE CHEVRONS AS NEEDED.
- SHOW WINDOWS RECEPTACLE TO BE INSTALLED PER N.E.C. 210.62 & 220.14(G).



**ROBERT L. QUEATHEM**  
ENGINEER  
1950 CRAIG ROAD, SUITE 900  
ST. LOUIS, MO 63146  
PH. (314) 415-2400 FAX (314) 415-2500  
www.arcv.com



REV	DATE	DESCRIPTION	BY	ANG
1	12/15/23	EXTERIOR REVISION		
2				
3				
4				
5				
6				
7				
8				
9				

TITLE:  
**ELECTRICAL LIGHTING PLAN & DETAILS**

PROJECT ADDRESS:  
306 S. MAIN ST.  
ROLESVILLE, NC 27571

FRANCHISEE & STORE NUMBER:  
SCOOTER'S COFFEE #562  
P&S JAVA ENTERPRISES, INC.

KIOSK PROTOTYPE:  
4.1 PROTOTYPE  
MAY 2022

ISSUE DATE:  
08/14/2023

PROJECT NO.  
230522

DRAWN BY:  
-

CHECKED BY:  
SAH


SHEET NO.  
**E2.1**



**4 DRIVE THRU SIDE EXTERIOR ELEVATION**  
SCALE: 1/4" = 1'-0"



**3 FRONT EXTERIOR ELEVATION**  
SCALE: 1/4" = 1'-0"

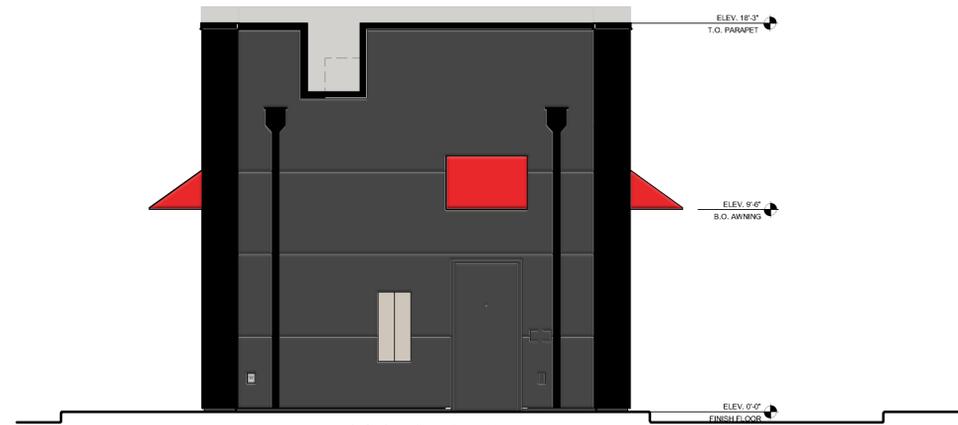

**2 BACK EXTERIOR ELEVATION**  
SCALE: 1/4" = 1'-0"



**1 SIDE EXTERIOR ELEVATION**  
SCALE: 1/4" = 1'-0"

MATERIAL PERCENTAGES		
DRIVE THRU SIDE EXTERIOR ELEVATION		
TOTAL WALL AREA	723 SQ. FT.	100%
STUCCO - INKWELL	0 SQ. FT.	0%
STUCCO - SKYLINE STEEL	1441 SQ. FT.	199%
CARBON LEDGE STONE	252 SQ. FT.	35%
FIBERON COMPOSITE CLADDING	147 SQ. FT.	20%
FENESTRATION	95 SQ. FT.	13%
TRIMS	74 SQ. FT.	10%

MATERIAL PERCENTAGES		
FRONT EXTERIOR ELEVATION		
TOTAL WALL AREA	347 SQ. FT.	100%
STUCCO - INKWELL	0 SQ. FT.	0%
STUCCO - SKYLINE STEEL	0 SQ. FT.	0%
CARBON LEDGE STONE	162 SQ. FT.	47%
FIBERON COMPOSITE CLADDING	36 SQ. FT.	10%
FENESTRATION	113 SQ. FT.	33%
TRIMS	36 SQ. FT.	10%

MATERIAL PERCENTAGES		
BACK EXTERIOR ELEVATION		
TOTAL WALL AREA	357 SQ. FT.	100%
STUCCO - INKWELL	250 SQ. FT.	70%
STUCCO - SKYLINE STEEL	0 SQ. FT.	0%
CARBON LEDGE STONE	0 SQ. FT.	0%
FIBERON COMPOSITE CLADDING	0 SQ. FT.	0%
DOOR	24 SQ. FT.	7%
TRIMS	83 SQ. FT.	23%

MATERIAL PERCENTAGES		
SIDE EXTERIOR ELEVATION		
TOTAL WALL AREA	723 SQ. FT.	100%
STUCCO - INKWELL	0 SQ. FT.	0%
STUCCO - SKYLINE STEEL	144 SQ. FT.	20%
CARBON LEDGE STONE	252 SQ. FT.	35%
FIBERON COMPOSITE CLADDING	147 SQ. FT.	20%
FENESTRATION	95 SQ. FT.	13%
TRIMS	74 SQ. FT.	10%



**FREDERICK J. GOGLIA**  
ARCHITECT, NCARB, RDI  
1950 CRAIG ROAD, SUITE 300  
PH. (314) 415-2400 FAX (314) 415-2400  
ST. LOUIS, MO 63146  
www.arjvcv.com



REV	DATE	DESCRIPTION	BY
1	12/15/23	EXTERIOR REVISION	ANG
2			
3			
4			
5			
6			
7			
8			
9			

TITLE: **EXTERIOR COLOR ELEVATIONS**

PROJECT ADDRESS:  
306 S. MAIN ST.  
ROLESVILLE, NC 27571

FRANCHISEE & STORE NUMBER:  
SCOOTER'S COFFEE #562  
P&S JAVA ENTERPRISES, INC.

KIOSK PROTOTYPE:  
4.1 PROTOTYPE  
MAY 2022

ISSUE DATE:  
08/14/2023

PROJECT NO.  
230522

DRAWN BY:  
ANG, MD

CHECKED BY:  
MD

SHEET NO.  
**A2.0**



MATERIAL PERCENTAGES		
FRONT EXTERIOR ELEVATION		
TOTAL WALL AREA	347 SQ. FT.	100%
STUCCO - INKWELL	0 SQ. FT.	0%
STUCCO - SKYLINE STEEL	0 SQ. FT.	0%
CARBON LEDGE STONE	162 SQ. FT.	47%
FIBERON COMPOSITE CLADDING	36 SQ. FT.	10%
FENESTRATION	113 SQ. FT.	33%
TRIMS	36 SQ. FT.	10%

MATERIAL PERCENTAGES		
SIDE EXTERIOR ELEVATION		
TOTAL WALL AREA	723 SQ. FT.	100%
STUCCO - INKWELL	0 SQ. FT.	0%
STUCCO - SKYLINE STEEL	144 SQ. FT.	20%
CARBON LEDGE STONE	252 SQ. FT.	35%
FIBERON COMPOSITE CLADDING	147 SQ. FT.	20%
FENESTRATION	95 SQ. FT.	13%
TRIMS	74 SQ. FT.	10%

**BLANK WALL SPACE**

1.1	47.4 SQ FT
1.2	48.8 SQ FT
1.3	48.6 SQ FT
2.1	48.5 SQ FT
2.2	48.8 SQ FT
2.3	47.4 SQ FT
3.1	N/A PER CODE

**1 FRONT EXTERIOR ELEVATION**  
SCALE: 3/8" = 1'-0"

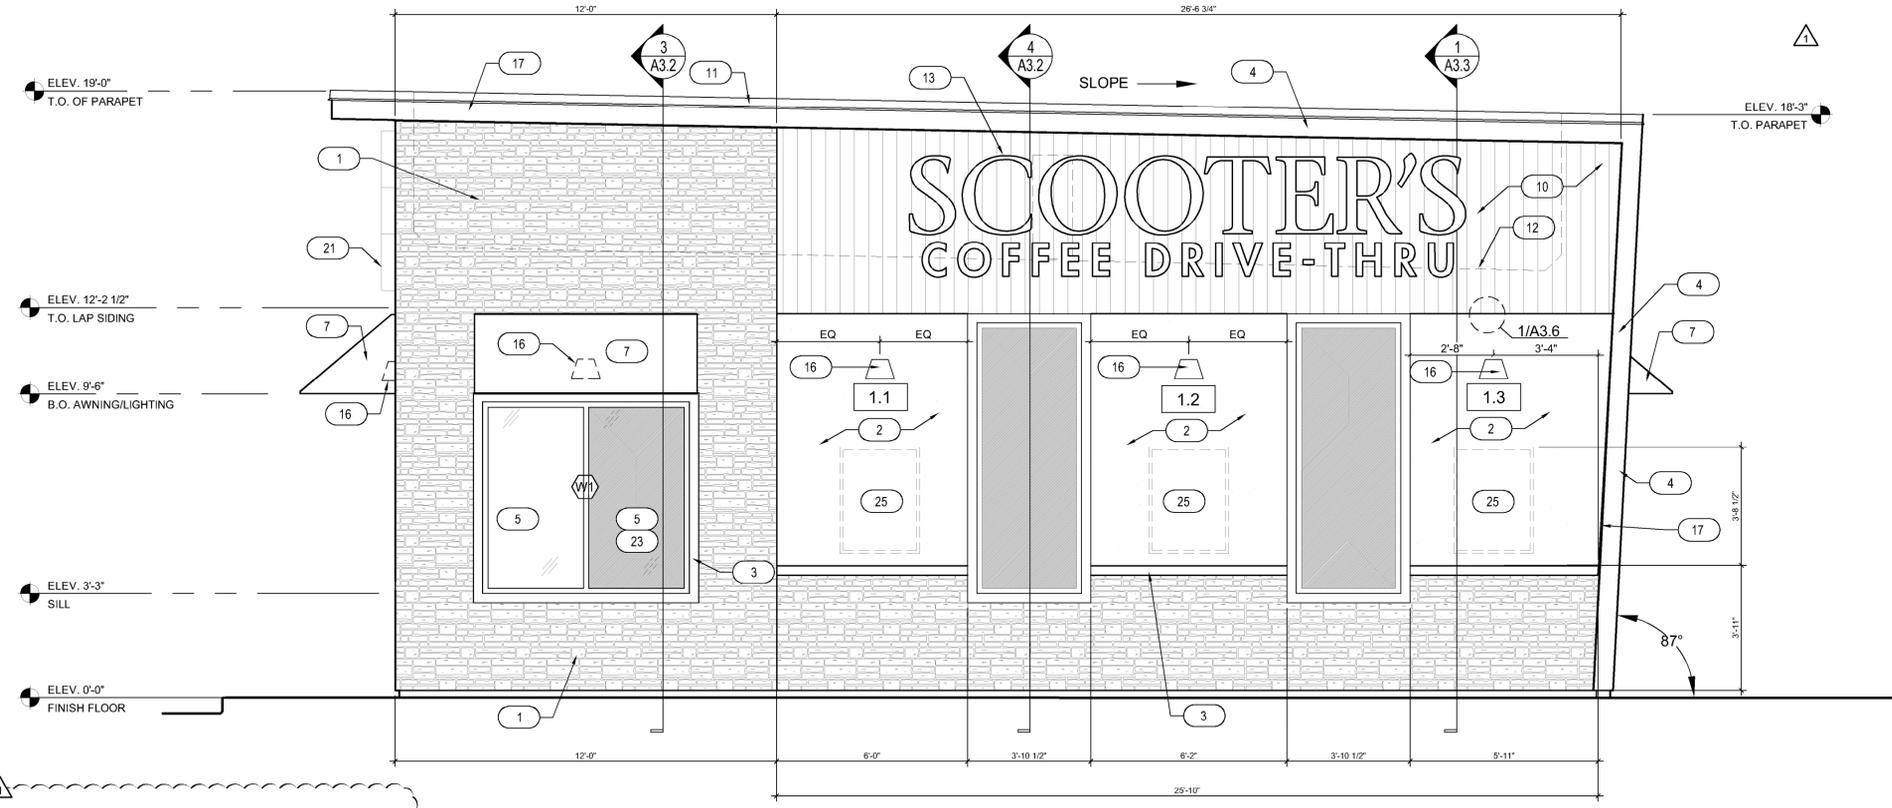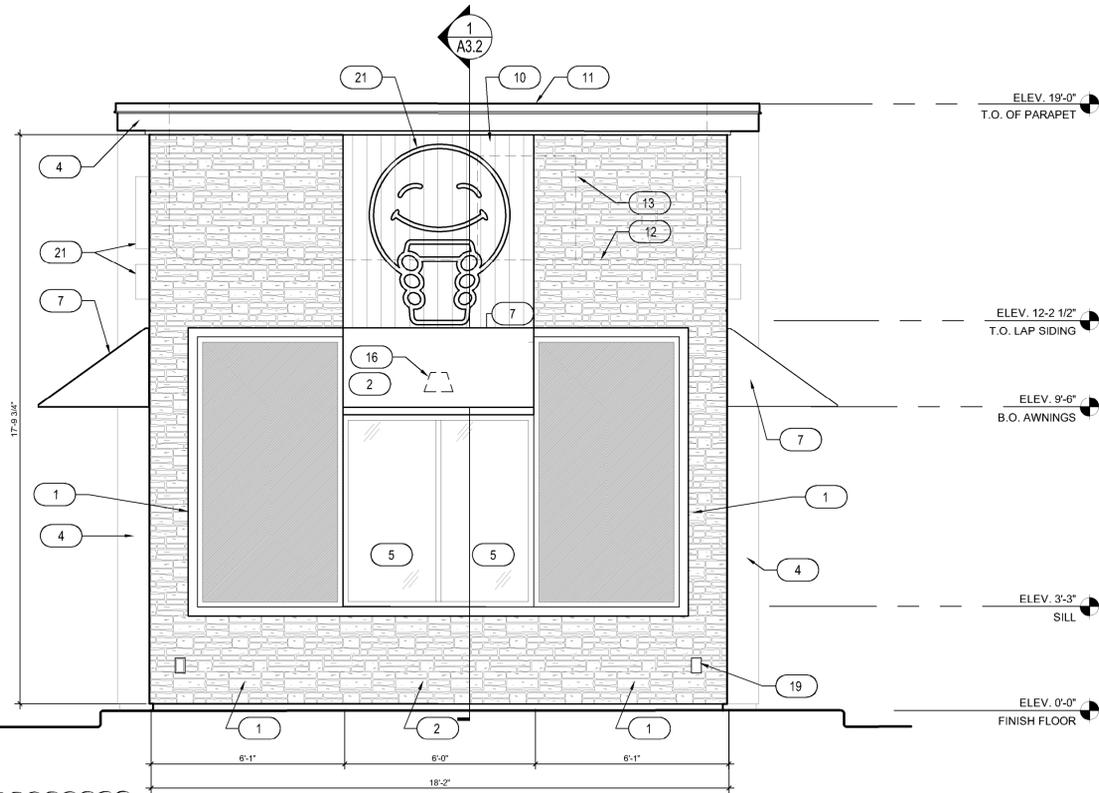

**2 SIDE EXTERIOR ELEVATION**  
SCALE: 3/8" = 1'-0"

**KEYNOTES**

- CARBON LEDGE STONE BY REALSTONE SYSTEMS
- STUCCO - COLOR: SHERWIN WILLIAMS SW1015 SKYLINE STEEL
- 3 1/2" TRIM - COLOR: SHERWIN WILLIAMS SW2848 ROYCROFT PEWTER
- METAL FASCIA - DARK BRONZE
- INSULATED DARK BRONZE ALUMINUM WINDOWS WITH DUAL PANE TEMPERED GLASS
- QUICKSERVE 48X48 WINDOW - COLOR: DARK BRONZE
- AWNING BY OTHERS - COLOR: RED
- INSULATED HOLLOW METAL DOOR & FRAME, PAINT SHERWIN WILLIAMS SW6992
- WIDE ANGLE PEEP HOLE, BY DOOR MANUFACTURER
- FIBERON COMPOSITE CLADDING
- PARAPET CAP FLASHING - DARK BRONZE
- LINE OF ROOF BEYOND
- AIR CONDENSER, SEE MECHANICAL DRAWINGS
- ROOF SCUPPER AND DOWNSPOUT, SEE DETAIL 8/A6.3
- MAILBOX BY GC BLACK
- WALL MOUNTED LIGHT FIXTURE, SEE ELECTRICAL DRAWINGS
- LED LIGHT BAND, SEE ELECTRICAL DRAWINGS
- SES PANEL, SEE ELECTRICAL DRAWINGS
- ELECTRICAL OUTLETS, SEE ELECTRICAL DRAWINGS
- HOSE BIBB, SEE PLUMBING DRAWINGS
- PROPOSED SIGNAGE BY OTHERS, UNDER SEPARATE PERMIT
- CONNECT DOWNSPOUTS TO UNDERGROUND PIPING, REF. CIVIL
- SPANDREL GLASS
- NEW SECURITY CAMERA
- CUSTOMER PROVIDED SIGN PANELS. PANELS TO BE MOUNTED TO FASCIA BY GC (WHEN PROVIDED) IN CUSTOMER SPECIFIED LOCATION USING PROPER HARDWARE AND FASTENERS (NON-CORROSIVE)
- STUCCO - COLOR: SHERWIN WILLIAMS SW6993 INKWELL EGGSHELL FINISH
- STUCCO REVEAL



**FREDERICK J. GOGLIA**  
ARCHITECT, NCARB, RDI  
1950 CRAIG ROAD, SUITE 300  
PH. (314) 415-2400 FAX (314) 415-2300  
ST. LOUIS, MO 63146  
www.arvcv.com



REV	DATE	DESCRIPTION	BY
1	12/15/23	EXTERIOR REVISION	ANG
2			
3			
4			
5			
6			
7			
8			
9			

TITLE:  
**EXTERIOR ELEVATIONS**

PROJECT ADDRESS:  
306 S. MAIN ST.  
ROLESVILLE, NC 27571  
FRANCHISEE & STORE NUMBER:  
SCOOTER'S COFFEE #562  
P&S JAVA ENTERPRISES, INC.


KIOSK PROTOTYPE:  
4.1 PROTOTYPE  
MAY 2022  
ISSUE DATE:  
08/14/2023  
PROJECT NO.  
230522  
DRAWN BY:  
NES, ANG  
CHECKED BY:  
SW

SHEET NO.

**A2.1**



- KEYNOTES**
- CARBON LEDGE STONE BY REALSTONE SYSTEMS
  - STUCCO - COLOR: SHERWIN WILLIAMS SW1015 SKYLINE STEEL
  - 3 1/2" TRIM - COLOR: SHERWIN WILLIAMS SW2848 ROYCROFT PEWTER
  - METAL FASCIA - DARK BRONZE
  - INSULATED DARK BRONZE ALUMINUM WINDOWS WITH DUAL PANE TEMPERED GLASS
  - QUICKSERVE 48X48 WINDOW - COLOR: DARK BRONZE
  - AWNING BY OTHERS - COLOR: RED
  - INSULATED HOLLOW METAL DOOR & FRAME, PAINT SHERWIN WILLIAMS SW6992
  - WIDE ANGLE PEEP HOLE, BY DOOR MANUFACTURER
  - FIBERON COMPOSITE CLADDING
  - PARAPET CAP FLASHING - DARK BRONZE
  - LINE OF ROOF BEYOND
  - AIR CONDENSER, SEE MECHANICAL DRAWINGS
  - ROOF SCUPPER AND DOWNSPOUT, SEE DETAIL 8/A6.3
  - MAILBOX BY GC BLACK
  - WALL MOUNTED LIGHT FIXTURE, SEE ELECTRICAL DRAWINGS
  - LED LIGHT BAND, SEE ELECTRICAL DRAWINGS
  - SES PANEL, SEE ELECTRICAL DRAWINGS
  - ELECTRICAL OUTLETS, SEE ELECTRICAL DRAWINGS
  - HOSE BIBB, SEE PLUMBING DRAWINGS
  - PROPOSED SIGNAGE BY OTHERS, UNDER SEPARATE PERMIT
  - CONNECT DOWNSPOUTS TO UNDERGROUND PIPING, REF. CIVIL.
  - SPANDREL GLASS
  - NEW SECURITY CAMERA
  - CUSTOMER PROVIDED SIGN PANELS. PANELS TO BE MOUNTED TO FASCIA BY GC (WHEN PROVIDED) IN CUSTOMER SPECIFIED LOCATION USING PROPER HARDWARE AND FASTENERS (NON-CORROSIVE)
  - STUCCO - COLOR: SHERWIN WILLIAMS SW6993 INKWELL EGGSHELL FINISH
  - STUCCO REVEAL

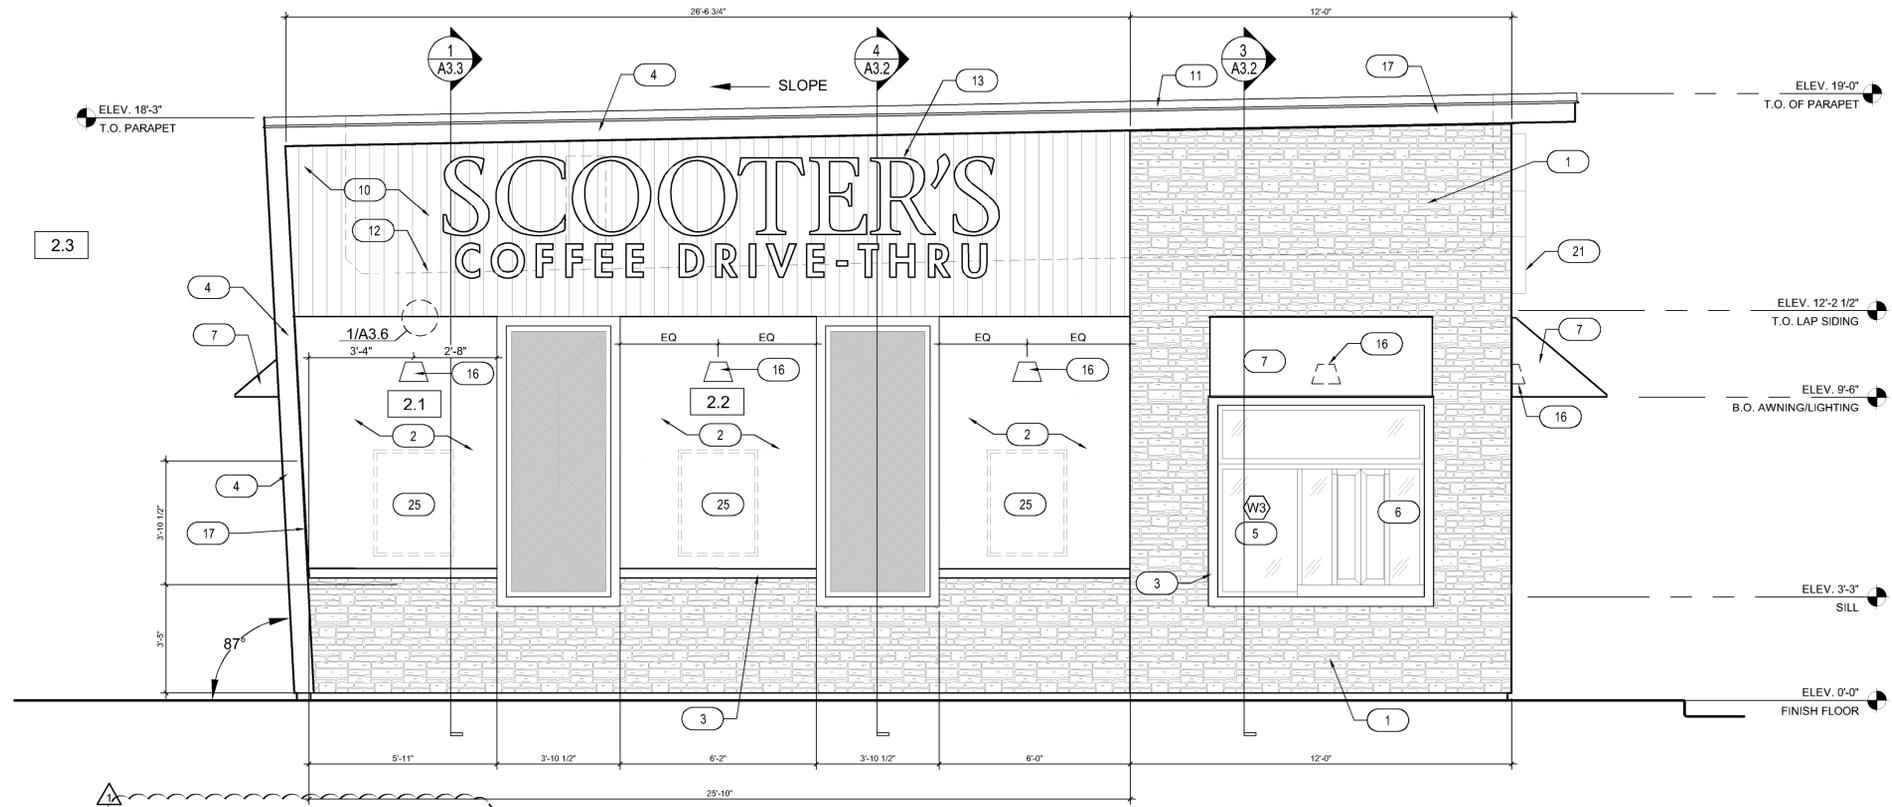

**1 SIDE EXTERIOR ELEVATION**  
SCALE: 3/8" = 1'-0"

**BLANK WALL SPACE**


1.1	47.4 SQ FT
1.2	48.8 SQ FT
1.3	48.6 SQ FT
2.1	48.5 SQ FT
2.2	48.8 SQ FT
2.3	47.4 SQ FT
3.1	N/A PER CODE

**MATERIALPERCENTAGES**  
DRIVE THRU SIDE EXTERIOR ELEVATION

TOTAL WALL AREA	723 SQ. FT.	100%
STUCCO - INKWELL	0 SQ. FT.	0%
STUCCO - SKYLINE STEEL	1441 SQ. FT.	199%
CARBON LEDGE STONE	252 SQ. FT.	35%
FIBERON COMPOSITE CLADDING	147 SQ. FT.	20%
FENESTRATION	95 SQ. FT.	13%
TRIMS	74 SQ. FT.	10%

**MATERIALPERCENTAGES**  
BACK EXTERIOR ELEVATION

TOTAL WALL AREA	357 SQ. FT.	100%
STUCCO - INKWELL	250 SQ. FT.	70%
STUCCO - SKYLINE STEEL	0 SQ. FT.	0%
CARBON LEDGE STONE	0 SQ. FT.	0%
FIBERON COMPOSITE CLADDING	0 SQ. FT.	0%
DOOR	24 SQ. FT.	7%
TRIMS	83 SQ. FT.	23%

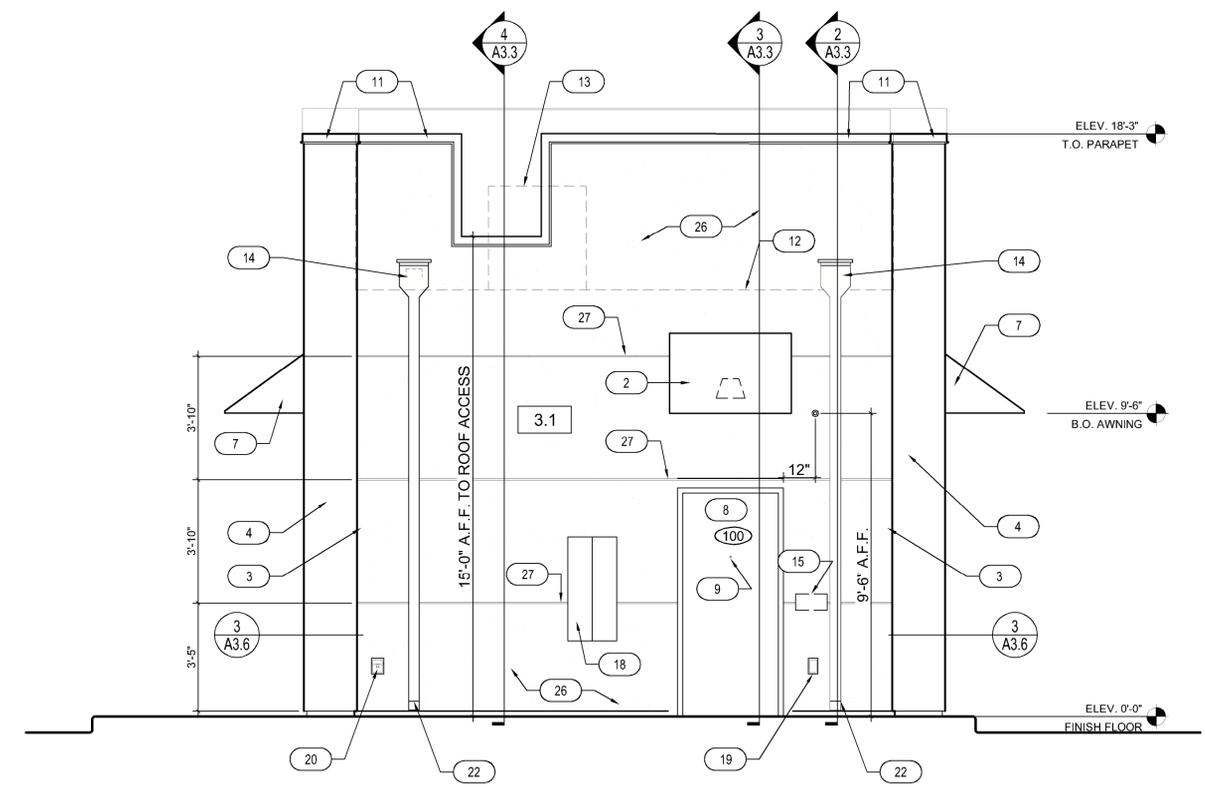

**2 BACK EXTERIOR ELEVATION**  
SCALE: 3/8" = 1'-0"

REV	DATE	DESCRIPTION
1	12/15/23	EXTERIOR REVISION
2		
3		
4		
5		
6		
7		
8		
9		

TITLE:  
**EXTERIOR ELEVATIONS**

PROJECT ADDRESS:  
306 S. MAIN ST.  
ROLESVILLE, NC 27571

FRANCHISEE & STORE NUMBER:  
SCOOTER'S COFFEE #562  
P&S JAVA ENTERPRISES, INC.

KIOSK PROTOTYPE:  
4.1 PROTOTYPE  
MAY 2022

ISSUE DATE:  
08/14/2023

PROJECT NO.  
230522

DRAWN BY:  
NES, ANG

CHECKED BY:  
SW

SHEET NO.

**A2.2**